




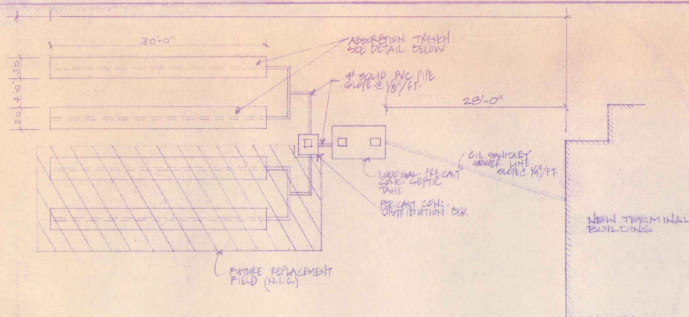


1-20 SANITARY DRAINAGE SYSTEM PLAN
1/8" = 1'-0"

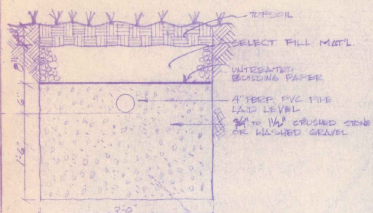

TYPICAL ABSORPTION TRENCH
1" = 1'-0"

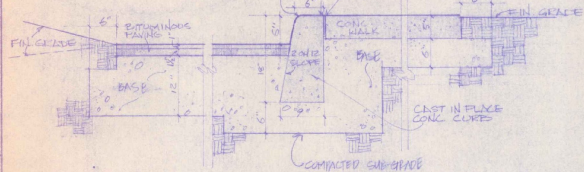


2-20 CONCRETE WALK, CURB, & BITUMINOUS PAVING DETAIL (N.I.C.)
1" = 1'-0"

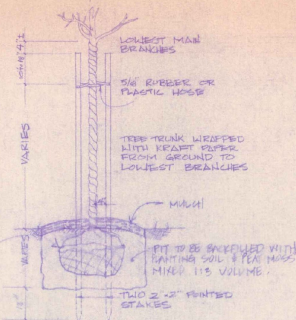


ELEVATION
1/2" = 1'-0"




3-20 PLANTING DETAIL TREES & SHRUBS (N.I.C.)
SHRUB PLANTING DETAIL SIMILAR -
OMIT STAKING & WRAP

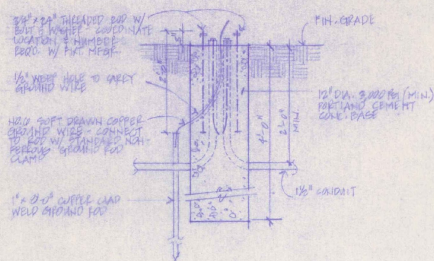


4-20 TYP. CONC. BASE @ SITE LIGHTING (N.I.C.)
1" = 1'-0"

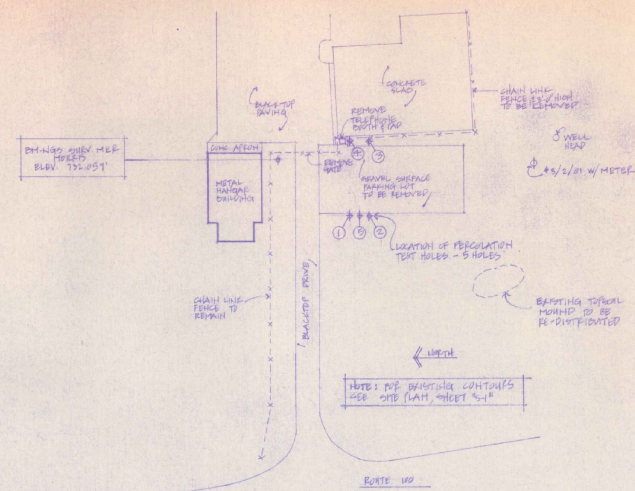


5-20 EXISTING SITE & SITE PREP. PLAN (N.I.C.)
1" = 50'-0"

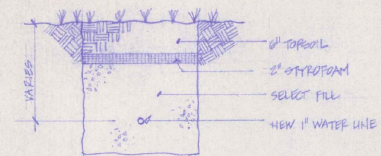

DETAIL @ NEW WATER LINE TRENCH
1" = 1'-0"


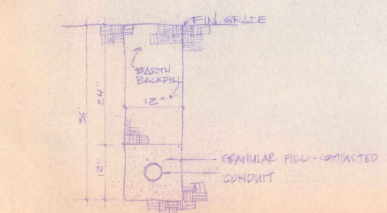


6-20 TYPICAL UTILITY & PLANT TRENCH
1" = 1'-0"

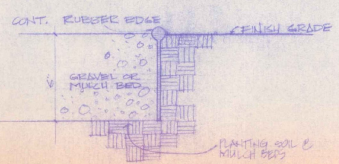

7-20 GRAVEL/MULCH BED DETAIL (N.I.C.)
3" = 1'-0"

STATE OF VERMONT				
DIVISION OF STATE BUILDINGS				
AGENCY OF ADMINISTRATION				
MONTPELIER, VERMONT				
SITE DETAILS				
NEW TERMINAL BUILDING				
MORRISVILLE/STONE STATE ARCADE				
VERMONT				
DATE: 6/1/83	SCALE: 1/8" = 1'-0"	REVISIONS:	DWG. NO. S-2	
DRAWN BY: SP/DMCK	APPROVED BY: CWS		5 OF 10	

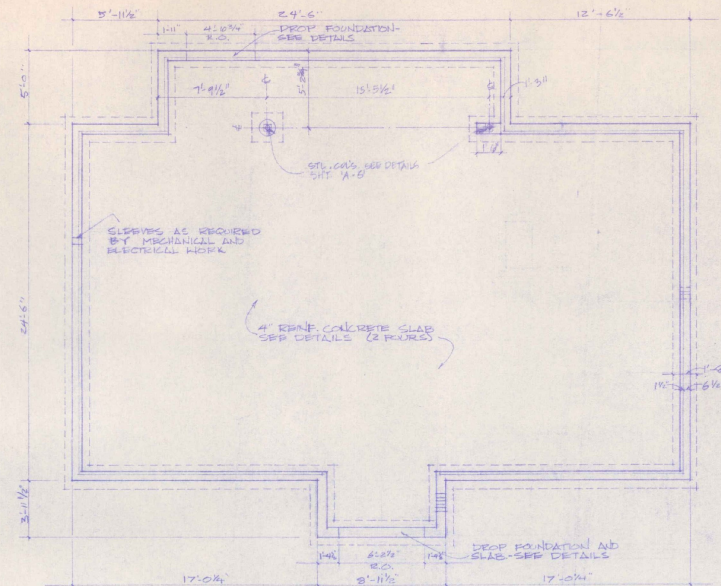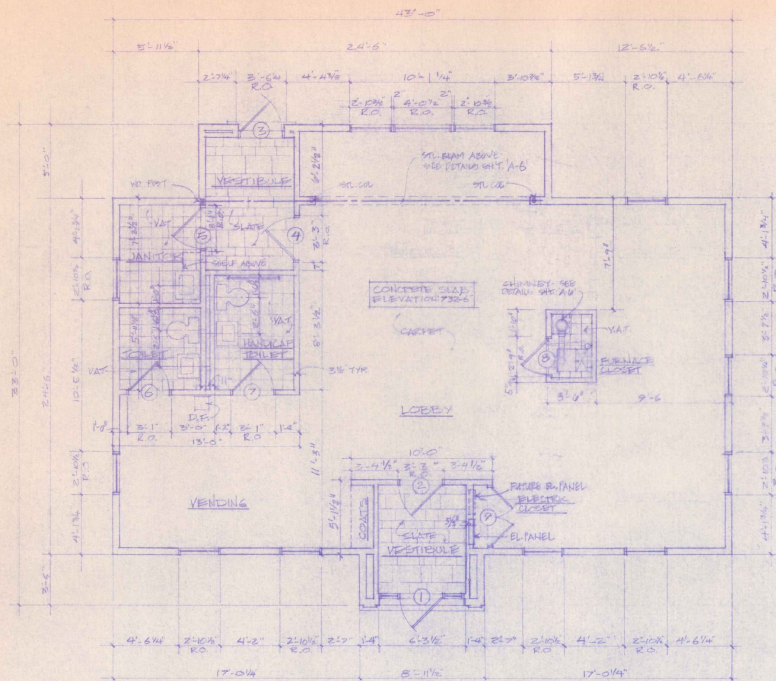

DOOR SCHEDULE

NO.	SIZE	TYPE	HOW	COMMENTS
1	2'-0" x 7'-0" x 1 3/4"	WD. RAIL & STYLE	1	DOOR PLANT UNDERCUT DOOR #1
2	3'-0" x 7'-0" x 1 3/4"	WD. RAIL & STYLE	2	MATCH DOOR NO. 1.
3	3'-0" x 7'-0" x 1 3/4"	WD. RAIL & STYLE	1	TRANSOM, EX. PLANT, SEE NECESSARY.
4	3'-0" x 7'-0" x 1 3/4"	WD. RAIL & STYLE	2	MATCH DOOR NO. 1, UNDERCUT DOOR #1.
5	2'-10" x 6'-8" x 1 3/4"	WD. FLUSH	4	C. LABEL, UNDERCUT DOOR #1.
6	2'-10" x 6'-8" x 1 3/4"	WD. FLUSH	3	UNDERCUT DOOR 3/4".
7	2'-10" x 6'-8" x 1 3/4"	WD. FLUSH	3	UNDERCUT DOOR 3/4".
8	2'-6" x 6'-8" x 1 3/4"	WD. LOUVER	5	-
9	4'-0" x 6'-8" x 1 3/4"	WD. LOUVER	5	PAIR OF DOORS, EX. PLANT, SEE NECESSARY.


GENERAL NOTES

1. ALL DIMENSIONS ARE ROUNDED DIMENSIONS (FACE OF STUD, C&G, ETC.) UNLESS OTHERWISE NOTED.
2. CONCRETE & REINFORCEMENT FOR VESTIBULE AND CORRIDOR TO ALL DIMENSIONS.
3. OBTAIN ALL PERMITS AND PAY ALL FEES REQUIRED FOR CONSTRUCTION.


STATE OF VERMONT
DIVISION OF STATE BUILDINGS
AGENCY OF ADMINISTRATION
MONTPELIER, VERMONT

FLOOR & FOUNDATION PLANS
NEW TERMINAL BUILDING
MORRISVILLE/STOWE STATE AIRPORT
MORRISVILLE, VERMONT

DATE: 11/14/1983 SCALE: 1/4" = 1'-0" REVISIONS: DWG. NO. 1
DRAWN BY: G. H. H. APPROVED BY: G. H. H. 3 OF 10

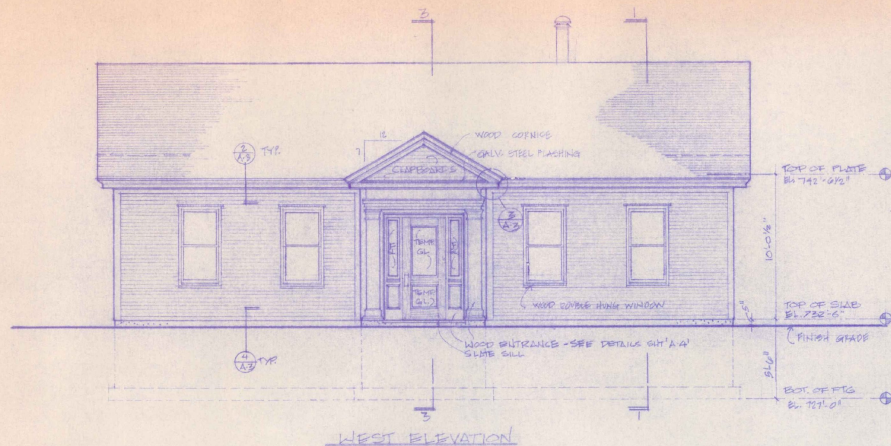


WEST ELEVATION

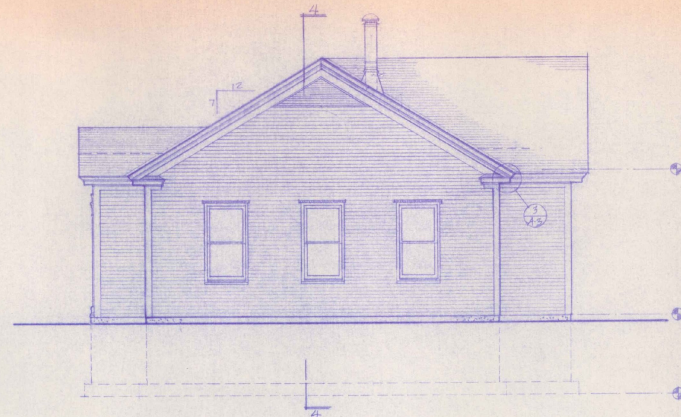


SOUTH ELEVATION

NOTE
TYP. DOUBLE HUNG WINDOW
CARADCO PRIMER WOOD #2828

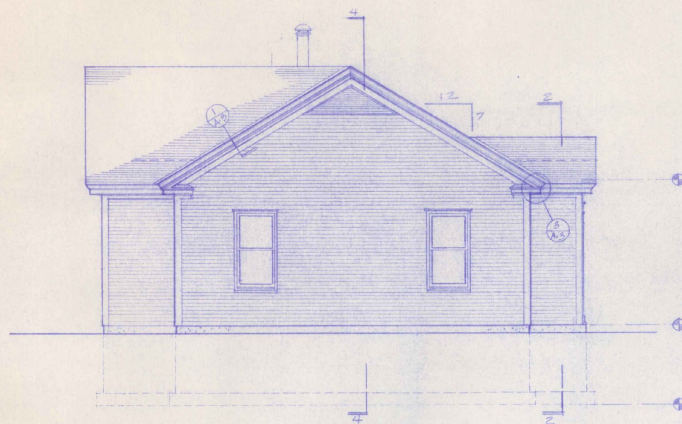

NORTH ELEVATION

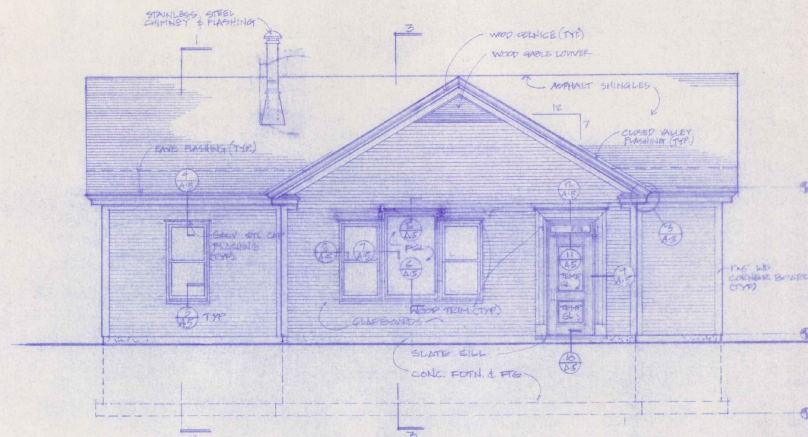


EAST ELEVATION

STATE OF VERMONT
DIVISION OF STATE BUILDINGS
AGENCY OF ADMINISTRATION
MONTPELIER, VERMONT


ELEVATIONS
NEW TERMINAL BUILDING
MORRISVILLE/STOLE STATE AIRPORT
MORRISVILLE VERMONT

DATE: JULY 2, 1988 SCALE: 1/4" = 1'-0" REVISIONS: DWG. NO. 2-2
DRAWN BY: K. BERNICK APPROVED BY: S.M. 1 of 10




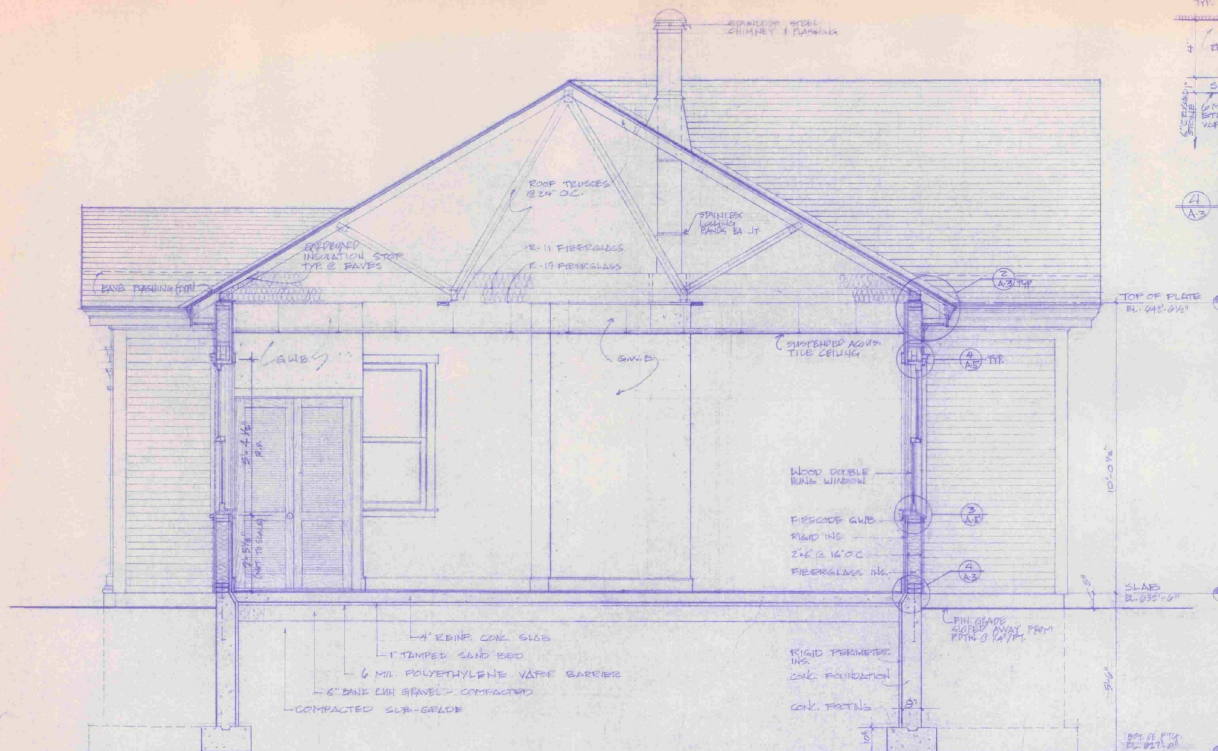


SECTION - 1
1/2" = 1'-0"

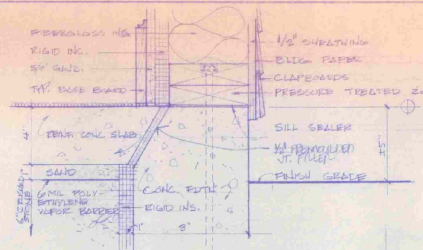


① TYPICAL FOUNDATION SILL
3" = 1'-0"

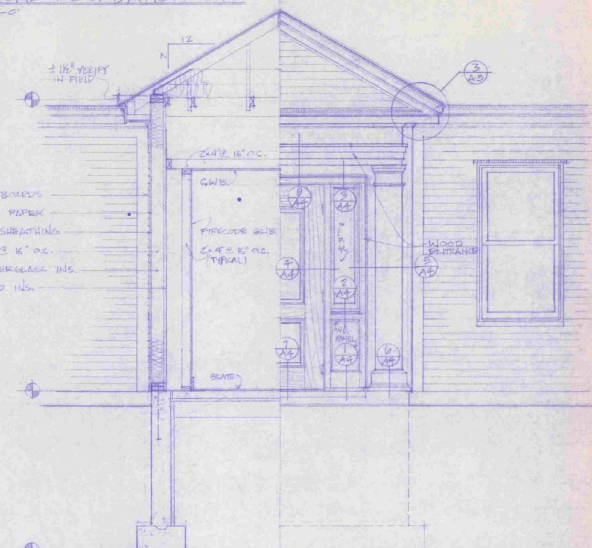


SECTION/ELEVATION - 2
1/2" = 1'-0"

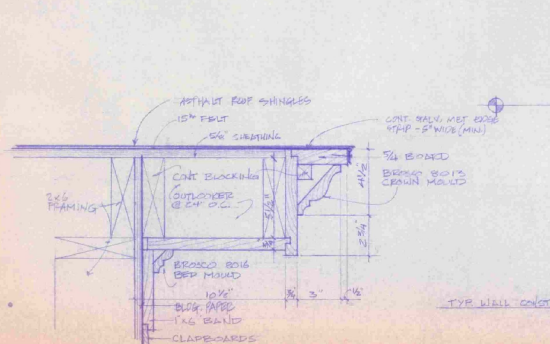

① TYPICAL CORNICE @ GABLE
3" = 1'-0"

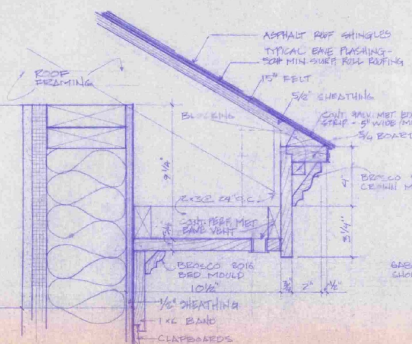


② TYPICAL CORNICE @ FAUCES
3" = 1'-0"

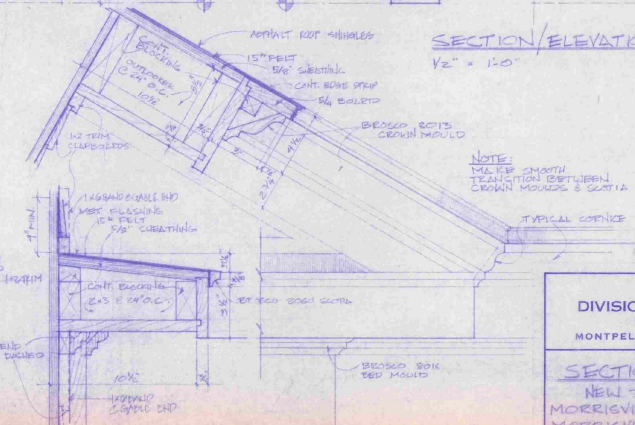


③ PEDIMENT DETAIL @ ENTRANCE
3" = 1'-0" (GABLE END DETAIL SIMILAR)






STATE OF VERMONT			
DIVISION OF STATE BUILDINGS			
AGENCY OF ADMINISTRATION			
MONTPELIER,		VERMONT	
SECTIONS AND DETAILS			
NEW TERMINAL BUILDING			
MORRISVILLE/STONE STATE AIRPORT			
MORRISVILLE		VERMONT	
DATE:	SCALE:	REVISIONS:	DWG. NO.
JULY 6, 1983	AS NOTED		A - 3
DRAWN BY:	APPROVED BY:		
GENEVA	CHS		8 OF 10

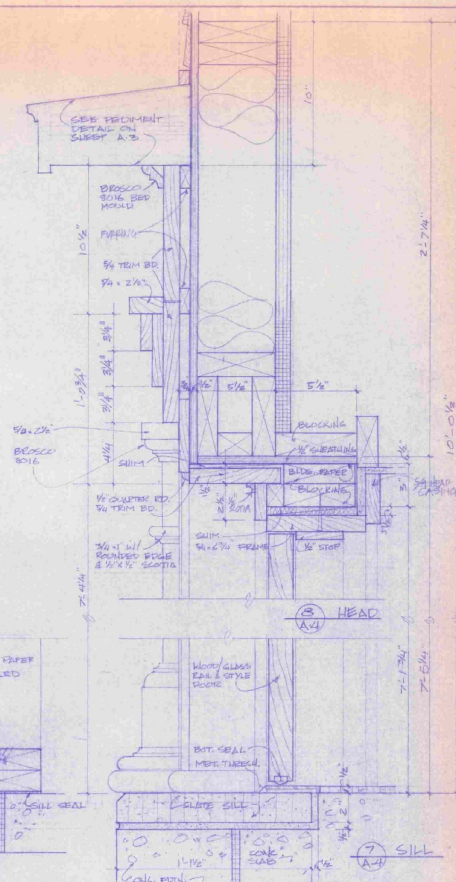

   ENTRANCE / DOOR DETAILS - SECTION
3" = 1'-0"




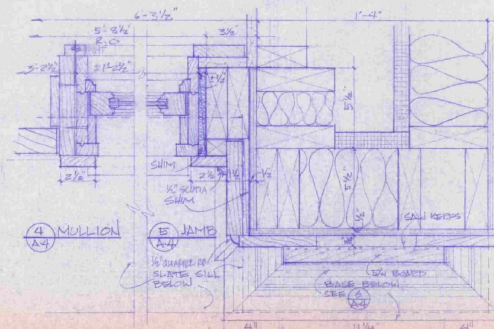





A diagram of a bookshelf with two shelves. A bracket on the right side of the shelves is labeled "SHELF & CORNER HOOKS (N.I.C)".

COAT CL.

    
① INTERIOR ELEVATIONS
1/4" = 1'-0"





DATE: JULY 6, 1983	SCALE: AS NOTED	REVISIONS:	DWG. NO. A-6
DRAWN BY: S. REMER	APPROVED BY: CWS		8 OF 10

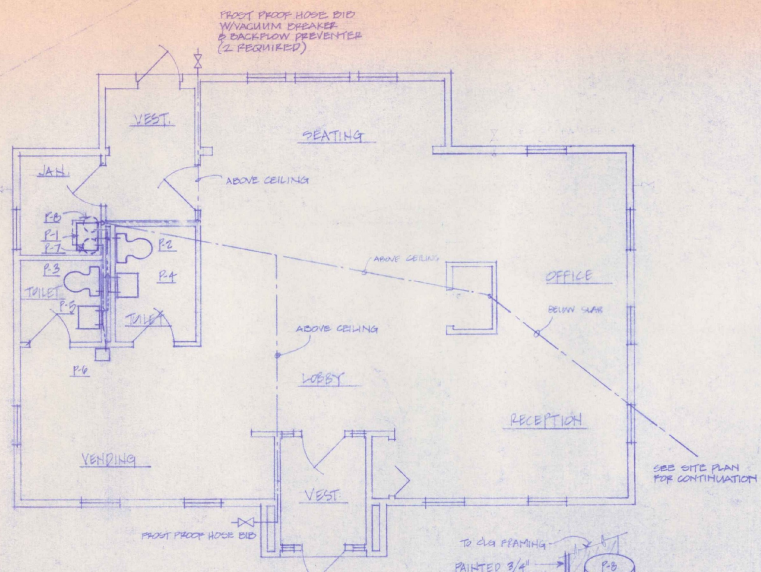

PLUMBING PLAN - WATER SUPPLY
1/4" = 1'-0"

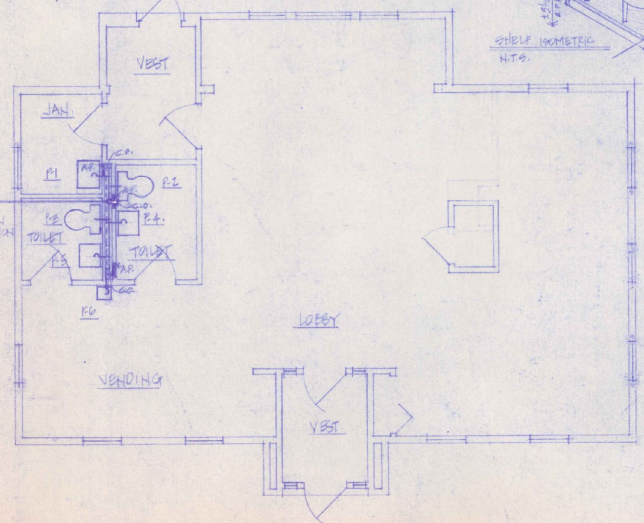


PLUMBING PLAN - SANITARY DRAINAGE
1/4" = 1'-0"

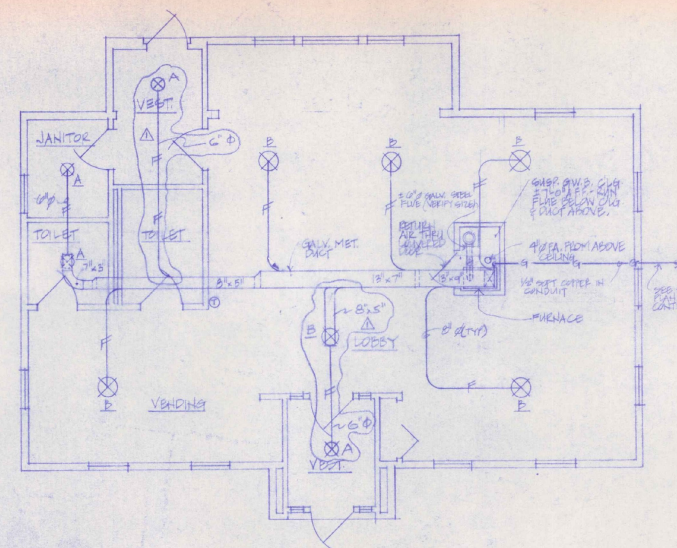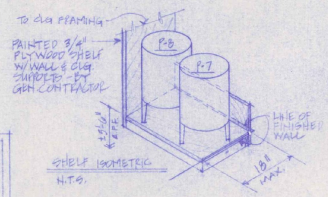


HEATING PLAN
1/4" = 1'-0"

NOTES:
1. OPERATION: FAN RUNS WHEN BONNET REACHES SET TEMPERATURE, FAN CAN OVERRIDE FOR SUMMER COOLING. ROOM THERMOSTAT STARTS GAS BURNER.

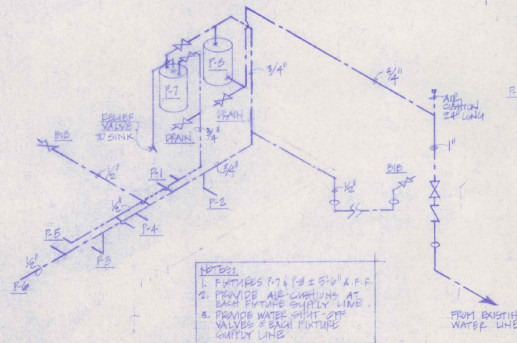

RISE DIAGRAM - WATER SUPPLY

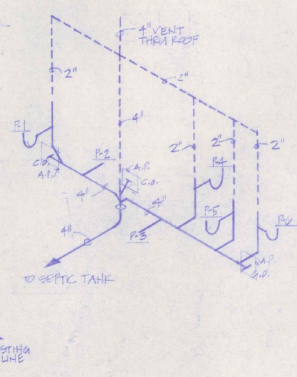

RISE DIAGRAM - SANITARY

HEATING LEGEND

- ⊗ DIFFUSER
- ⊙ THERMOSTAT
- ⊖ DRAFT DAMPER
- FA. FRESH AIR
- G. LIQ. GAS SUPPLY
- △ FLEXIBLE DUCT

PLUMBING LEGEND

- COLD WATER PIPING
- HOT WATER PIPING
- VENT PIPING
- SANITARY PIPING
- ⊗ GATE VALVE/BID
- ⊖ CHECK VALVE
- G.O. CLEAN OUT
- U TRAP
- ⊕ LAB. PENETRATION
- AP. ACCESS PANEL 12"x12" BY REBEKAH CONTRACTOR

PLUMBING FIXTURE SCHEDULE

NO.	MANUFACTURER	MODEL
R1	AMERICAN STD. SERVICE SINK	8379.019 WHITE
R2	AMERICAN STD. WATER CLOSET	8395.002 WHITE
R3	AMERICAN STD. LAVATORY	8395.002 WHITE
R4	AMERICAN STD. LAVATORY	8395.002 WHITE
R5	AMERICAN STD. LAVATORY	8395.002 WHITE
R100	AMERICAN STD. LAVATORY	8395.002 WHITE


HEATING EQUIPMENT SCHEDULE

NO.	MANUFACTURER	MODEL
FURNACE	BOYS-WARNER OR EQUAL	1000 G.P.M.
DIFFUSERS	BOYS-WARNER OR EQUAL	1000 G.P.M.
THERMOSTAT	BOYS-WARNER OR EQUAL	1000 G.P.M.


REVISED 10/11/83. SEE FOR MORE

STATE OF VERMONT
DIVISION OF STATE BUILDINGS
AGENCY OF ADMINISTRATION
MONTPELIER, VERMONT
MECHANICAL PLANS
NEW TERMINAL BUILDING
MORRISVILLE/STONE STATE AIRPORT
MORRISVILLE VERMONT

DATE: 10/11/83	SCALE: 1/4" = 1'-0"	REVISIONS:	DWG. NO. 14-1
DRAWN BY: SWS	APPROVED BY: H. J. S.		3 OF 10

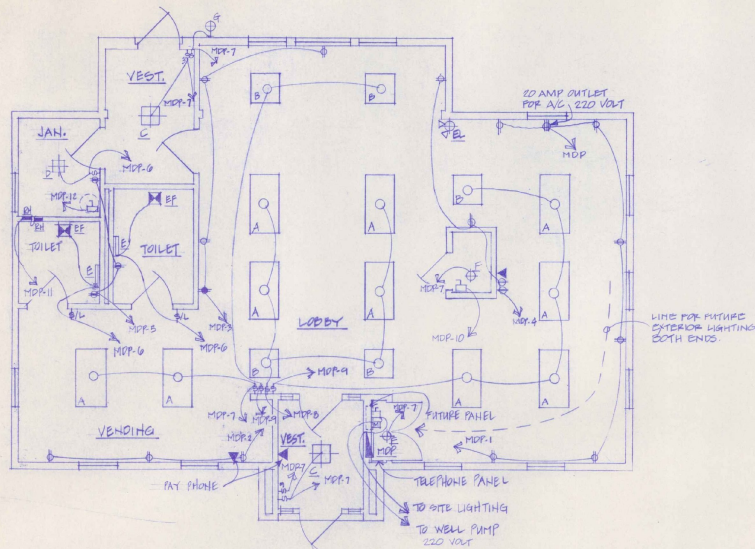

ELECTRICAL PLAN

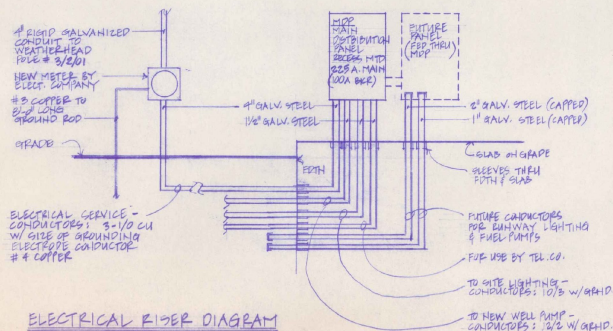

ELECTRICAL RISER DIAGRAM

NOTE: USE PVC CONDUIT EXCEPT AT THE FOLLOWING LOCATIONS - GALV. STEEL ABOVE GRADE AT MOTORS & PRE LINED SHEET PILES.

MARK	DESCRIPTION	MODEL #
A	2"x4" RECESS MTD. FLUOR. FIXT. "LITHONIA" W/2-40 W. LAMPS	2 99 240 AIC
B	2"x2" RECESS MTD. FLUOR. FIXT. "LITHONIA" W/2-40 W. LAMPS	2 99 2440 AIC
C	18"x15" SURFACE MTD. INCAND. FIXT. "PRESOLITE" W/2-60W. BULBS	3601 WH
D	10"x10" RECESS MTD. INCAND. FIXT. "PRESOLITE" W/1-75 W. BULB	1015 HF-1
E	18" SURFACE MTD. FLUOR. FIXT. "PRESOLITE" W/1-40 W. LAMP	WB-10
F	SURFACE MTD. INCAND. FIXT. - RECESSED WITH PAUL GRAY. 1-60W. LAMP	-
G	EXPOSED MTD. INCAND. FIXT. FOR EXTERIOR LOCATIONS. WHITE GLOBE & BLACK BEZEL. 1-100W. LAMP. - FERGUSON LIGHTING	P-5026-60
EF	BATHROOM VENTILATOR 80CFM HORIZONTAL DISCHARGE WITH BACK DRAFT DAMPER. "THERMADORE" TRADE WIND. (SEE NOTE #1, BELOW)	1205
EL	EMERGENCY LIGHT - TWIN CYLINDER "DUAL-LITE" W/ BATTERY & CHARGER, TEST SWITCH.	QWA 206
EH	FORCED AIR WALL HEATER "MARKET MARK-1" 1000 W. 240V WITH THERMAL CUTOFF AND BUILT-IN TWO POLE THERMOSTAT	H3133 T2

NOTE #1: ELECTRICAL CONTRACTOR TO SUPPLY & INSTALL 4" GALV. STEEL DUCT WITH ELBOWS. DUCT TO RUN VERTICALLY FROM EXHAUST PAN TO A POINT ABOVE CEILING INSULATION. PROVIDE SUPPORTS AS NECESSARY.

PANEL "MDP" WESTINGHOUSE TYPE Q10P, RECESS MTD 120/240 VAC 3 WIRE 3/4" 225 AMP W/100 AMP MAIN BRK: CIRCUIT BREAKS 10/200 AIC

CIRCUIT NUMBER	BREAKER AMP	POLES	MARKINGS	REMARKS
1	20	1	RECEPTACLES OFFICE & RECEPT.	
2	20	1	RECEPTACLES VENDING	
3	20	1	RECEPTACLES SEATING & LOBBY	
4	20	1	RECEPTACLES SEATING & LOBBY	
5	20	1	RECEPTACLES JAN. & TOILET	GROUND FAULT BREAKER
6	20	1	LIGHTING JAN. & TOILETS	
7	20	1	LIGHTING VESTIBULES & VENDING	
8	20	1	LIGHTING LOBBY	
9	20	1	LIGHTING SEATING/OFFICE/RECEPT.	
10	20	1	FURNACE	
11	20	2	RESISTANCE HEATERS	
12	20	1	WATER HEATER	
13	20	1	WELL PUMP	
14	20	1	SITE LIGHTING	GROUND FAULT BREAKER
15-20	20	1	SPACES	
21-24	-	-	-	

LEGEND	
⊕	DUPLEX RECEPTACLE 20A. 10" A.F.F.
⊕	DUPLEX RECEPTACLE 20A. 40" A.F.F.
⊕	GROUND FAULT
⊕	QUICK RECEPTACLE 8A" A.F.F.
⊕	TELEPHONE JACK
⊕	DISCONNECT - FIXED
⊕	SINGLE POLE SWITCH 15A 40" A.F.F.
⊕	THREE WAY SWITCH 15A 40" A.F.F.
⊕	SINGLE POLE SWITCH 15A 40" A.F.F. WITH SIGNAL LAMP ON PLATE.
⊕	BATHROOM VENTILATOR
⊕	FLUORESCENT FIXTURE - LOTTER DENOTES TYPE
⊕	INCANDESCENT FIXTURE - LOTTER DENOTES TYPE
⊕	EMERGENCY LIGHT
⊕	FLUORESCENT FIXTURE - LOTTER DENOTES TYPE
⊕	RESISTANCE HEATER WITH INTEGRAL CONTROL
⊕	BURNER WATER HEATER - BY MECH. CONTRACTOR. ELECT. CONTRACTOR TO PROVIDE POWER & DISCONNECT.
⊕	REMOTE MOTOR CONTROL BOX

STATE OF VERMONT
DIVISION OF STATE BUILDINGS
AGENCY OF ADMINISTRATION
MONTPELIER, VERMONT

ELECTRICAL PLAN
NEW TERMINAL BUILDING
MORRISVILLE/STOWE STATE AIRPORT
MORRISVILLE VERMONT

DATE: JULY 6, 1983 SCALE: 1/4" = 1'-0" REVISIONS: DWG. NO. E-1
DRAWN BY: C.W.S. APPROVED BY: 10 OF 10

