
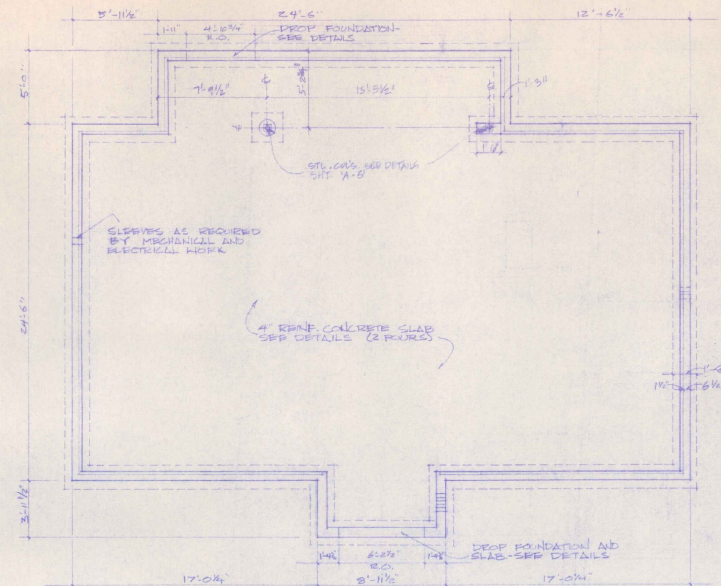


STATE OF VERMONT			
DIVISION OF STATE BUILDINGS			
AGENCY OF ADMINISTRATION		VERMONT	
MONTPELIER.			
<u>SITE DETAILS</u>			
NEW TERMINAL BUILDING			
MORRISVILLE/STONE STATE ASPH			
MORRISVILLE		VERMONT	
DATE: JUNE 5, 1963	SCALE: AS SHOWN	REVISIONS:	DWG. NO. S 2
DRAWN BY: SPENCE	APPROVED BY: CWS	6	

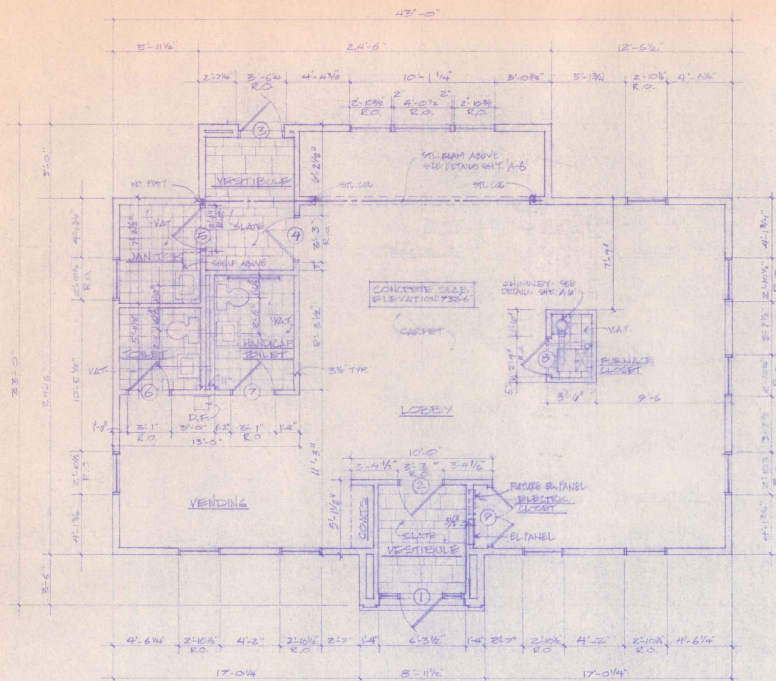

DOOR SCHEDULE

NO.	SIZE	TYPE	HOW	COMMENTS
1	2'-0" x 7'-0" x 1 3/4"	WD. RAIL & STYLE	1	DOOR HANDLE UNDERCUT DOOR #1
2	3'-0" x 7'-0" x 1 3/4"	WD. RAIL & STYLE	2	MATCH DOOR NO. 1.
3	3'-0" x 7'-0" x 1 3/4"	WD. RAIL & STYLE	1	TRANSOM, EX. HAND, SEE NECESSARY.
4	3'-0" x 7'-0" x 1 3/4"	WD. RAIL & STYLE	2	MATCH DOOR NO. 1, UNDERCUT DOOR #1.
5	2'-10" x 6'-8" x 1 3/4"	WD. FLUSH	4	C. LABEL, UNDERCUT DOOR #1.
6	2'-10" x 6'-8" x 1 3/4"	WD. FLUSH	3	UNDERCUT DOOR 3/4".
7	2'-10" x 6'-8" x 1 3/4"	WD. FLUSH	3	UNDERCUT DOOR 3/4".
8	2'-6" x 6'-8" x 1 3/4"	WD. LOUVER	5	-
9	4'-0" x 6'-8" x 1 3/4"	WD. LOUVER	5	PAIR OF DOORS, EX. HAND, SEE NECESSARY.


GENERAL NOTES

1. ALL DIMENSIONS ARE FLOOR DIMENSIONS (FACE OF STUD, C/C, ETC.) UNLESS OTHERWISE NOTED.
2. CONCRETE & REINFORCEMENT FOR VESTIBULE AND CORRIDOR TO ALL DIMENSIONS.
3. OBTAIN ALL PERMITS AND PAY ALL FEES REQUIRED FOR CONSTRUCTION.


STATE OF VERMONT
DIVISION OF STATE BUILDINGS
AGENCY OF ADMINISTRATION
MONTPELIER, VERMONT

FLOOR & FOUNDATION PLANS
NEW TERMINAL BUILDING
MORRISVILLE/STOWE STATE AIRPORT
MORRISVILLE, VERMONT

DATE: 11/14/81
SCALE: 1/4" = 1'-0"
REVISIONS:
DWG. NO. 1
DRAWN BY: G. H. H. H.
APPROVED BY: G. H. H. H.
3 OF 10

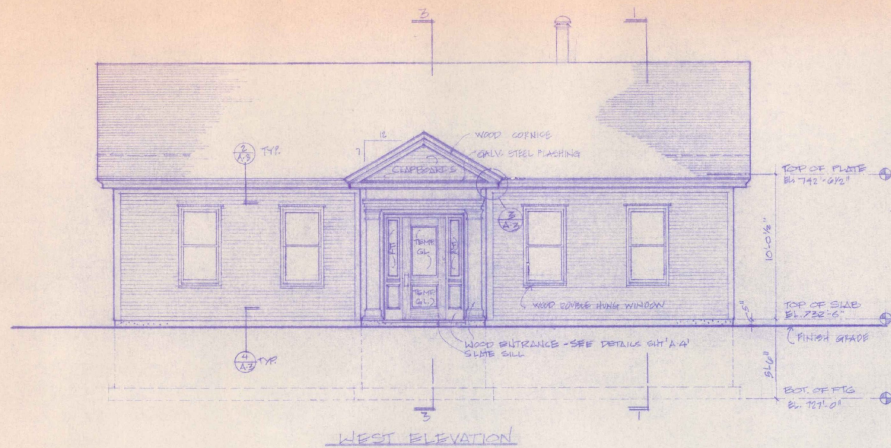


WEST ELEVATION

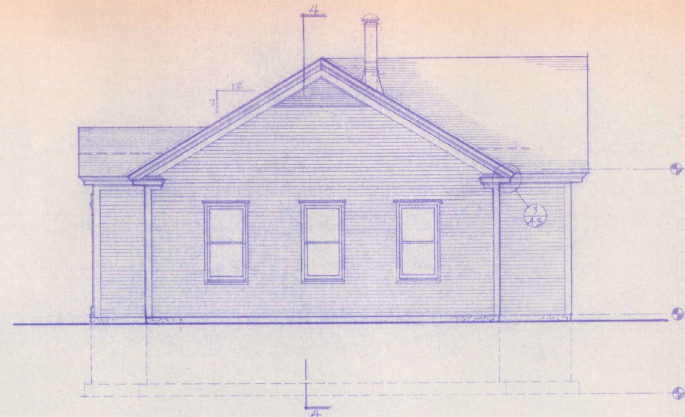


SOUTH ELEVATION

NOTE
TYP. DOUBLE HUNG WINDOW
CARADCO PRIMER WOOD #2828

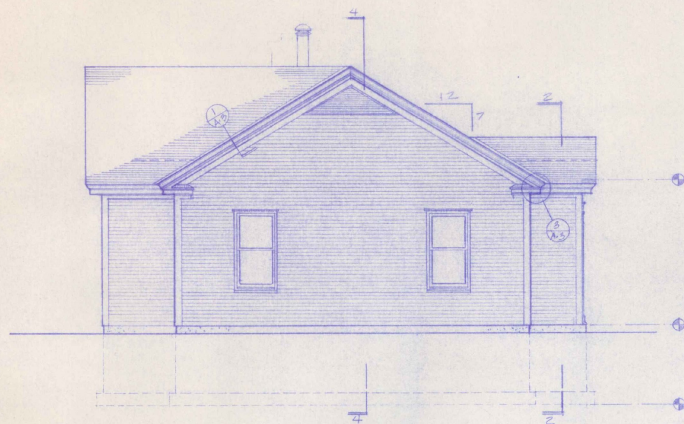

NORTH ELEVATION

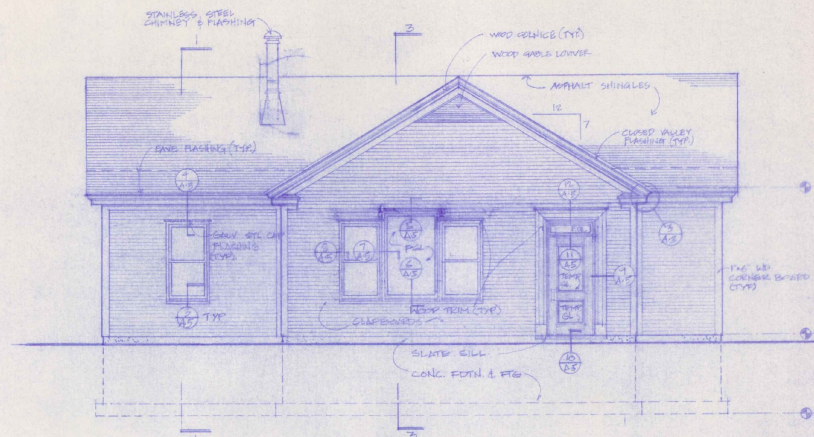

EAST ELEVATION


STATE OF VERMONT
DIVISION OF STATE BUILDINGS
AGENCY OF ADMINISTRATION
MONTPELIER, VERMONT

ELEVATIONS


NEW TERMINAL BUILDING
MORRISVILLE/STOLE STATE AIRPORT
MORRISVILLE VERMONT

DATE: JULY 2, 1988	SCALE: 1/4" = 1'-0"	REVISIONS:	DWG. NO. A-2
DRAWN BY: K. BERNICK	APPROVED BY: S.M.		1 of 10




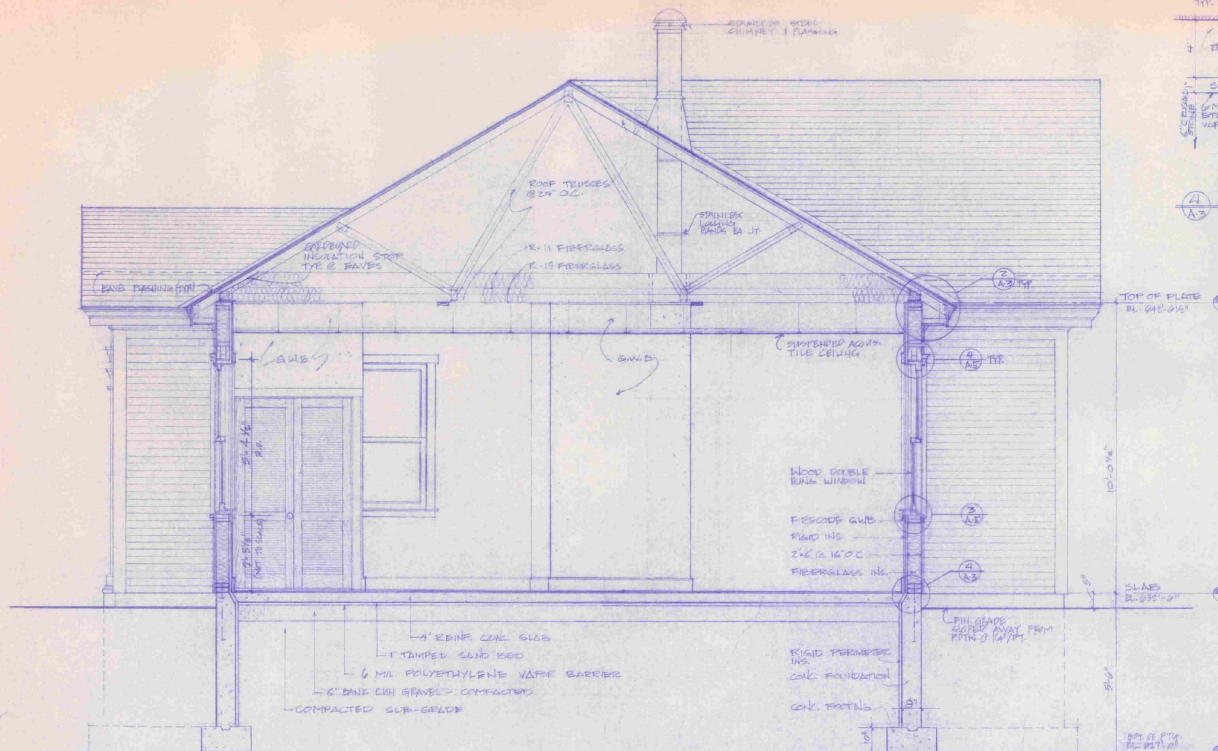


SECTION - 1
1/2" = 1'-0"

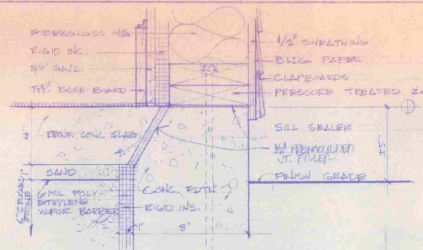


① TYPICAL FOUNDATION SILL
3" = 1'-0"

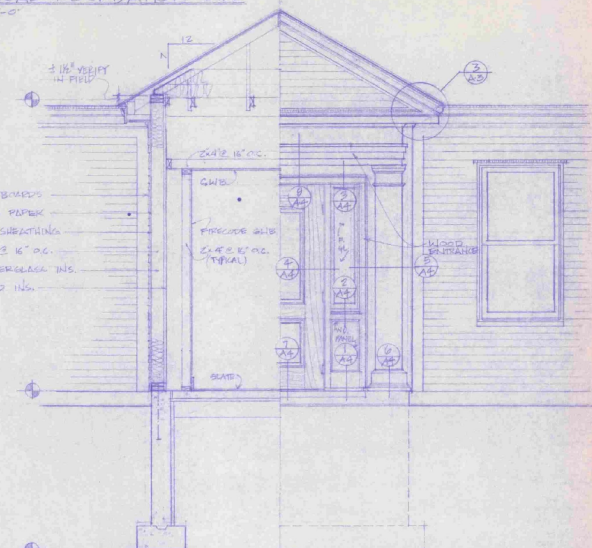


SECTION/ELEVATION - 2
1/2" = 1'-0"

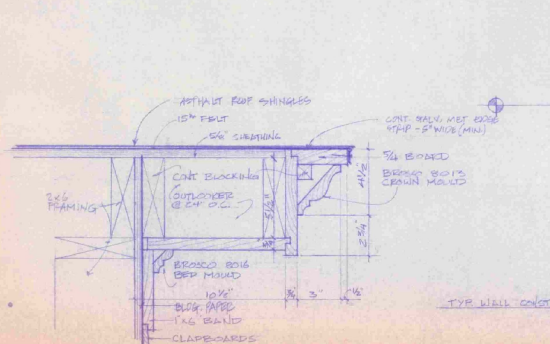

① TYPICAL CORNICE @ GABLE
3" = 1'-0"

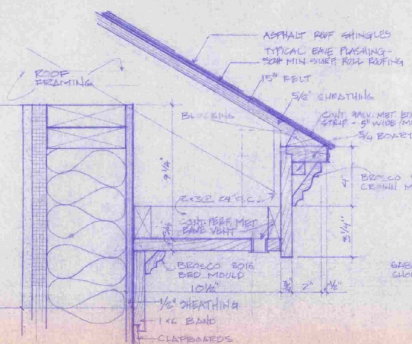


② TYPICAL CORNICE @ FAHES
3" = 1'-0"

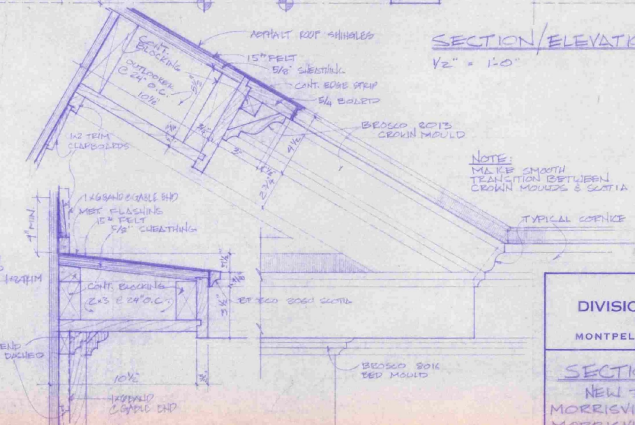


③ PEDIMENT DETAIL @ ENTRANCE
3" = 1'-0" (GABLE END DETAIL SIMILAR)




STATE OF VERMONT			
DIVISION OF STATE BUILDINGS			
AGENCY OF ADMINISTRATION			
MONTPELIER,		VERMONT	
SECTIONS AND DETAILS			
NEW TERMINAL BUILDING			
MORRISVILLE/STONE STATE AIRPORT			
MORRISVILLE		VERMONT	
DATE:	SCALE:	REVISIONS:	DWG. NO.
JULY 6, 1983	AS NOTED		A - 3
DRAWN BY:	APPROVED BY:		
GENEVA	CMS		8 OF 10

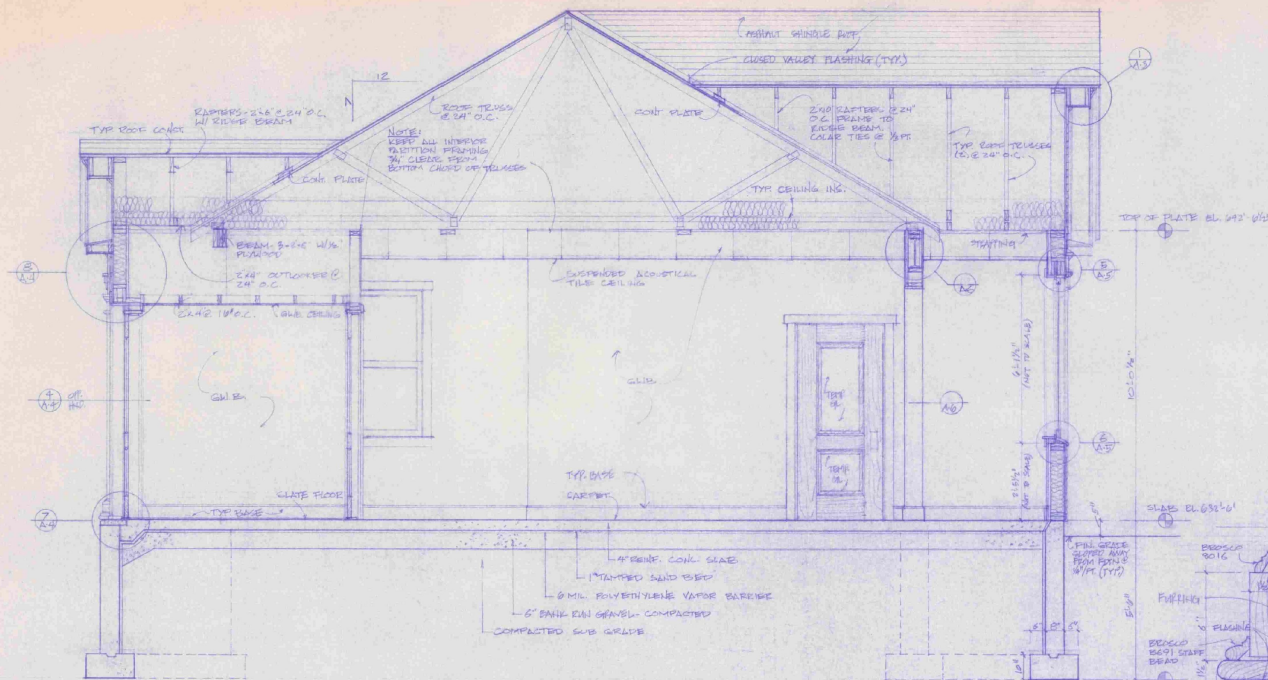


SECTION - 3
1/2" = 1'-0"

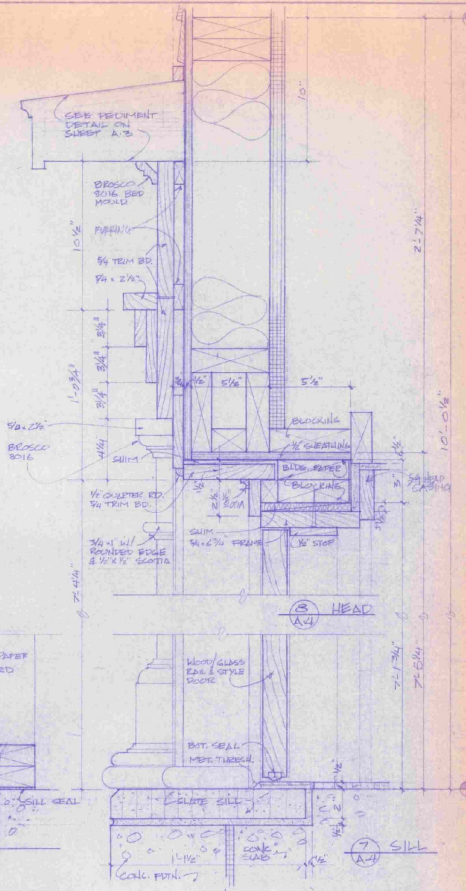

ENTRANCE/DOOR DETAILS - SECTION
3" = 1'-0"

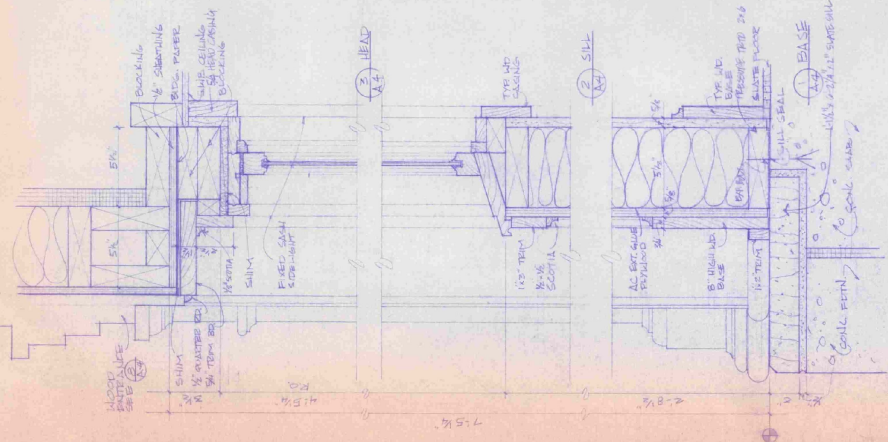

SIDE LIGHT DETAILS @ ENTRANCE - SECTION
3" = 1'-0"

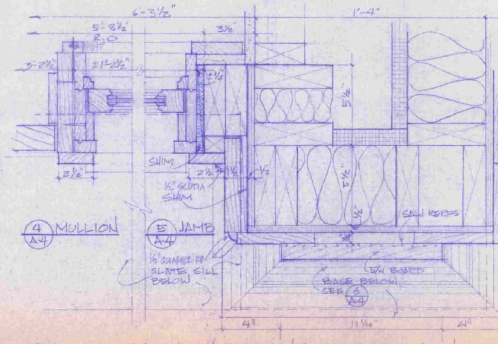

ENTRANCE/SIDE LIGHT DETAILS - PLAN
3" = 1'-0"

STATE OF VERMONT
DIVISION OF STATE BUILDINGS
AGENCY OF ADMINISTRATION
MONTPELIER, VERMONT

SECTIONS AND DETAILS
NEW TERMINAL BUILDING
MORRISVILLE/STOWE STATE AIRPORT
MORRISVILLE, VERMONT

DATE: JULY 6, 1983	SCALE: AS NOTED	REVISIONS:	DWG. NO. A-4
DRAWN BY: S. KENNICOTT	APPROVED BY: C. W. B.		4 OF 10




 
 


Diagram of a shelf with hooks. A note points to the hooks: "SHelf Hooks (N.I.C)".

COAT CL.



 
① INTERIOR ELEVATIONS
AS $\frac{1}{4}'' = 1'-0''$




⑧ TYPICAL INTERIOR DOOR DETAILS
3" = 1'-0"



   
⑦ TYP. WOOD BASE
3" = 1'0"




DATE: JULY 4, 1983	SCALE: AS NOTED	REVISIONS:	DWG. NO. A-6
DRAWN BY: S. REMICK	APPROVED BY: CWS		8 OF 10

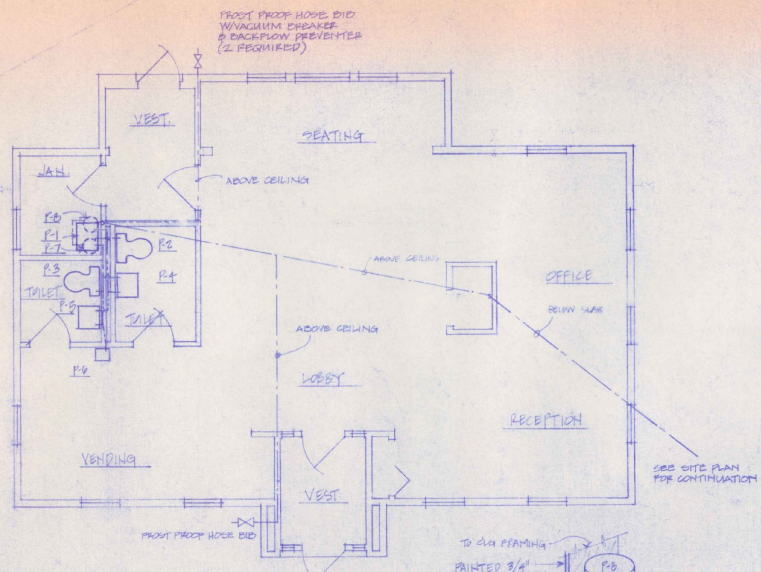

PLUMBING PLAN - WATER SUPPLY
1/4" = 1'-0"

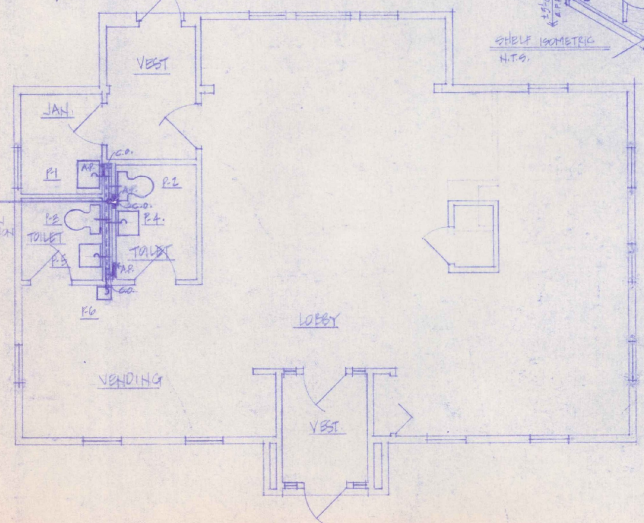


PLUMBING PLAN - SANITARY DRAINAGE
1/4" = 1'-0"

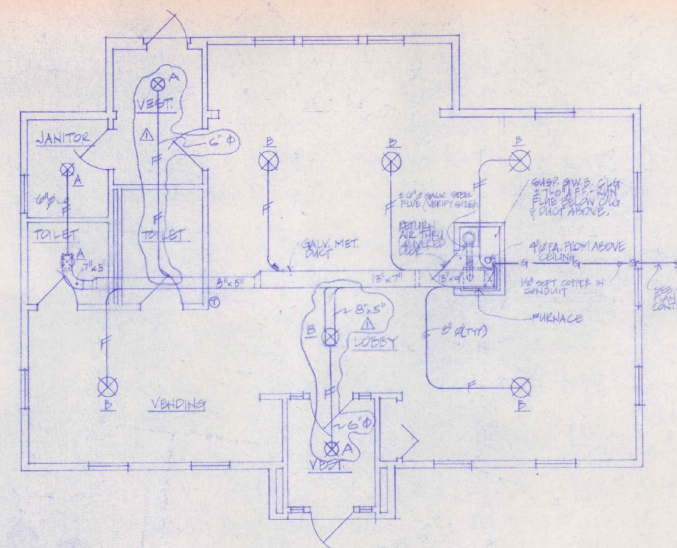


HEATING PLAN
1/4" = 1'-0"

NOTES:
1. OPERATION: FAN RUNS WHEN BONNET REACHES SET TEMPERATURE, FAN CAN OVERRIDE FOR SUMMER COOLING. ROOM THERMOSTAT STARTS GAS BURNER.

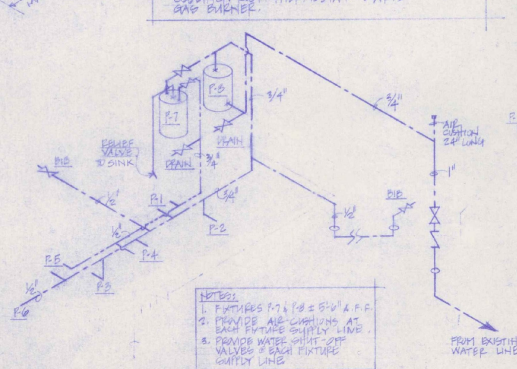

RISE DIAGRAM - WATER SUPPLY

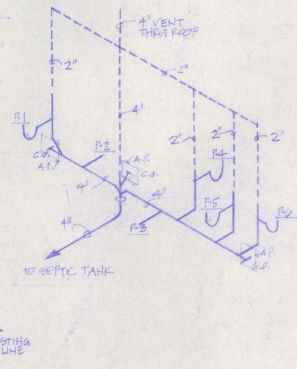

RISE DIAGRAM - SANITARY

HEATING LEGEND

- ⊗ DIFFUSER
- ⊙ THERMOSTAT
- ⊖ DRAFT DAMPER
- FA. FRESH AIR
- G. LIQ. GAS SUPPLY
- △ FLEXIBLE DUCT

PLUMBING LEGEND

- COLD WATER PIPING
- HOT WATER PIPING
- VENT PIPING
- SANITARY PIPING
- ⊗ GATE VALVE/BID
- CHECK VALVE
- G.O. CLEAN OUT
- U TRAP
- ⊕ W/AB PENETRATION
- AP ACCESS PANEL 12"x12" BY REBEKA CONTRACTOR

PLUMBING FIXTURE SCHEDULE

NO.	MANUFACTURER	MODEL
R1	AMERICAN STD. SERVICE SINK	8379.019 WHITE
R2	AMERICAN STD. WATER CLOSET	8395.002 WHITE
R3	AMERICAN STD. LAVATORY	8395.002 WHITE
R4	AMERICAN STD. LAVATORY	8395.002 WHITE
R5	AMERICAN STD. LAVATORY	8395.002 WHITE
R6	AMERICAN STD. LAVATORY	8395.002 WHITE
R7	AMERICAN STD. LAVATORY	8395.002 WHITE
R8	AMERICAN STD. LAVATORY	8395.002 WHITE
R9	AMERICAN STD. LAVATORY	8395.002 WHITE
R10	AMERICAN STD. LAVATORY	8395.002 WHITE
R11	AMERICAN STD. LAVATORY	8395.002 WHITE
R12	AMERICAN STD. LAVATORY	8395.002 WHITE
R13	AMERICAN STD. LAVATORY	8395.002 WHITE
R14	AMERICAN STD. LAVATORY	8395.002 WHITE
R15	AMERICAN STD. LAVATORY	8395.002 WHITE
R16	AMERICAN STD. LAVATORY	8395.002 WHITE
R17	AMERICAN STD. LAVATORY	8395.002 WHITE
R18	AMERICAN STD. LAVATORY	8395.002 WHITE
R19	AMERICAN STD. LAVATORY	8395.002 WHITE
R20	AMERICAN STD. LAVATORY	8395.002 WHITE

HEATING EQUIPMENT SCHEDULE


NO.	MANUFACTURER	MODEL
FURNACE	BOYS-WARNER OR EQUAL	1000 CFM
DIFFUSERS	BOYS-WARNER OR EQUAL	1000 CFM
THERMOSTAT	BOYS-WARNER OR EQUAL	1000 CFM

REVISED 10/11/83. JTO. H.R. HED


STATE OF VERMONT
DIVISION OF STATE BUILDINGS
AGENCY OF ADMINISTRATION
MONTPELIER, VERMONT

MECHANICAL PLANS
NEW TERMINAL BUILDING
MORRISVILLE/STONE STATE AIRPORT
MORRISVILLE VERMONT

DATE: 10/11/83
DRAWN BY: SWS
SCALE: 1/4" = 1'-0"
APPROVED BY: H.J.S.
REVISIONS:
DWG. NO.: 14-1
3 OF 10

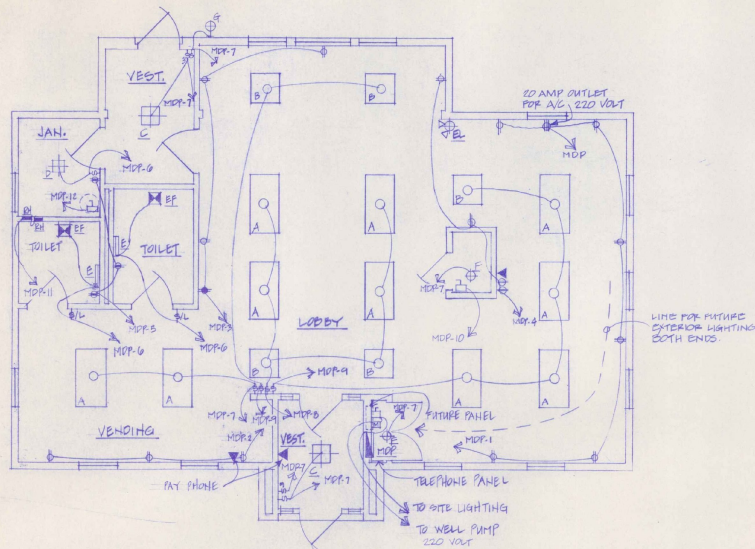

ELECTRICAL PLAN

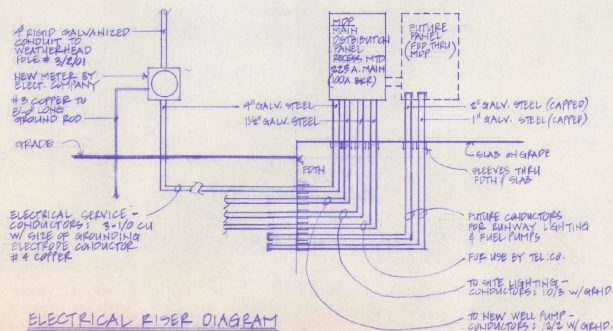

ELECTRICAL RISER DIAGRAM

NOTE: USE PVC CONDUIT EXCEPT AT THE FOLLOWING LOCATIONS - GALV. STEEL ABOVE GRADE AT MOTORS & PRE-LOAN SHEET BENDS.

MARK	DESCRIPTION	MODEL #
A	2"x4" RECESS MTD. FLUOR. FIXT. "LITHONIA" W/2-40 W. LAMPS	2 99 240 AIC
B	2"x2" RECESS MTD. FLUOR. FIXT. "LITHONIA" W/2-40 W. LAMPS	2 99 2440 AIC
C	18"x15" SURFACE MTD. INCAND. FIXT. "PRESOLITE" W/2-60W. BULBS	3601 WH
D	10"x10" RECESS MTD. INCAND. FIXT. "PRESOLITE" W/1-75 W. BULB	1015 HF-1
E	18" SURFACE MTD. INCAND. FIXT. "PRESOLITE" W/1-40 W. LAMP	WB-10
F	SURFACE MTD. INCAND. FIXT. - RECESSED WITH PAUL GRAY. 1-60W. LAMP	-
G	EXHAUST MTD. INCAND. FIXT. FOR EXTERIOR LOCATED. WHITE FLORE & BLACK BEACON 1-100W. LAMP - FLORESC. LIGHTING	P-5026-60
EF	BATHROOM VENTILATOR 80CFM HORIZONTAL DISCHARGE WITH BACK DRAFT DAMPER. "THERMADORE" TRADE WIND. (SEE NOTE #1, BELOW)	1205
EL	EMERGENCY LIGHT - TWIN CYLINDER "DUAL-LITE" W/ BATTERY & CHARGER, TEST SWITCH.	QWA 206
EH	FORCED AIR WALL HEATER "MARKET MARK-1" 1000 W. 240V WITH THERMAL CUTOFF AND BUILT-IN TWO POLE THERMOSTAT	H3133 T2

NOTE #1: ELECTRICAL CONTRACTOR TO SUPPLY & INSTALL 4" GALV. STEEL DUCT WITH ELBOWS. DUCT TO RUN VERTICALLY FROM EXHAUST PAN TO A POINT ABOVE CEILING INSULATION. PROVIDE SUPPORTS AS NECESSARY.

PANEL "MDP" WESTINGHOUSE TYPE Q10P, RECESS MTD 120/240 VAC 3 WIRE 3/4 225 AMP W/100 AMP MAIN BRK: CIRCUIT BREAKS 10/200 AIC

CIRCUIT NUMBER	BREAKER AMP	POLES	MARKINGS	REMARKS
1	20	1	RECEPTACLES OFFICE & RECEPT.	
2	20	1	RECEPTACLES VENDING	
3	20	1	RECEPTACLES SEATING & LOBBY	
4	20	1	RECEPTACLES SEATING & LOBBY	
5	20	1	RECEPTACLES JAN. & TOILET	GROUND FAULT BREAKER
6	20	1	LIGHTING JAN. & TOILETS	
7	20	1	LIGHTING VESTIBULES & VENDING	
8	20	1	LIGHTING LOBBY	
9	20	1	LIGHTING SEATING/OFFICE/RECEPT.	
10	20	1	FURNACE	
11	20	2	RESISTANCE HEATERS	
12	20	1	WATER HEATER	
13	20	1	WELL PUMP	
14	20	1	SITE LIGHTING	GROUND FAULT BREAKER
15-20	20	1	SPACES	
21-24	-	-	-	

LEGEND	
⊕	DUPLEX RECEPTACLE 20A. 10" A.F.F.
⊕	DUPLEX RECEPTACLE 20A. 40" A.F.F.
⊕	GROUND FAULT
⊕	QUICK RECEPTACLE 84" A.F.F.
⊕	TELEPHONE JACK
⊕	DISCONNECT - FIXED
⊕	SINGLE POLE SWITCH 15A 40" A.F.F.
⊕	THREE WAY SWITCH 15A 40" A.F.F.
⊕	SINGLE POLE SWITCH 15A 40" A.F.F. WITH SIGNAL LAMP ON PLATE.
⊕	BATHROOM VENTILATOR
⊕	FLUORESCENT FIXTURE - LOTTER DENOTES TYPE
⊕	INCANDESCENT FIXTURE - LOTTER DENOTES TYPE
⊕	EMERGENCY LIGHT
⊕	FLUORESCENT FIXTURE - LOTTER DENOTES TYPE
⊕	RESISTANCE HEATER WITH INTEGRAL CONTROL
⊕	BLURST WATER HEATER - BY MECH. CONTRACTOR. ELECT. CONTRACTOR TO PROVIDE POWER & DISCONNECT.
⊕	REMOTE MOTOR CONTROL BOX

STATE OF VERMONT
DIVISION OF STATE BUILDINGS
AGENCY OF ADMINISTRATION
MONTPELIER, VERMONT

ELECTRICAL PLAN
NEW TERMINAL BUILDING
MORRISVILLE/STOWE STATE AIRPORT
MORRISVILLE VERMONT

DATE: JULY 6, 1983 SCALE: 1/4" = 1'-0" REVISIONS: DWG. NO. E-1
DRAWN BY: C.W.S. APPROVED BY: 10 OF 10

