


AIR 23-2010
★ 1984

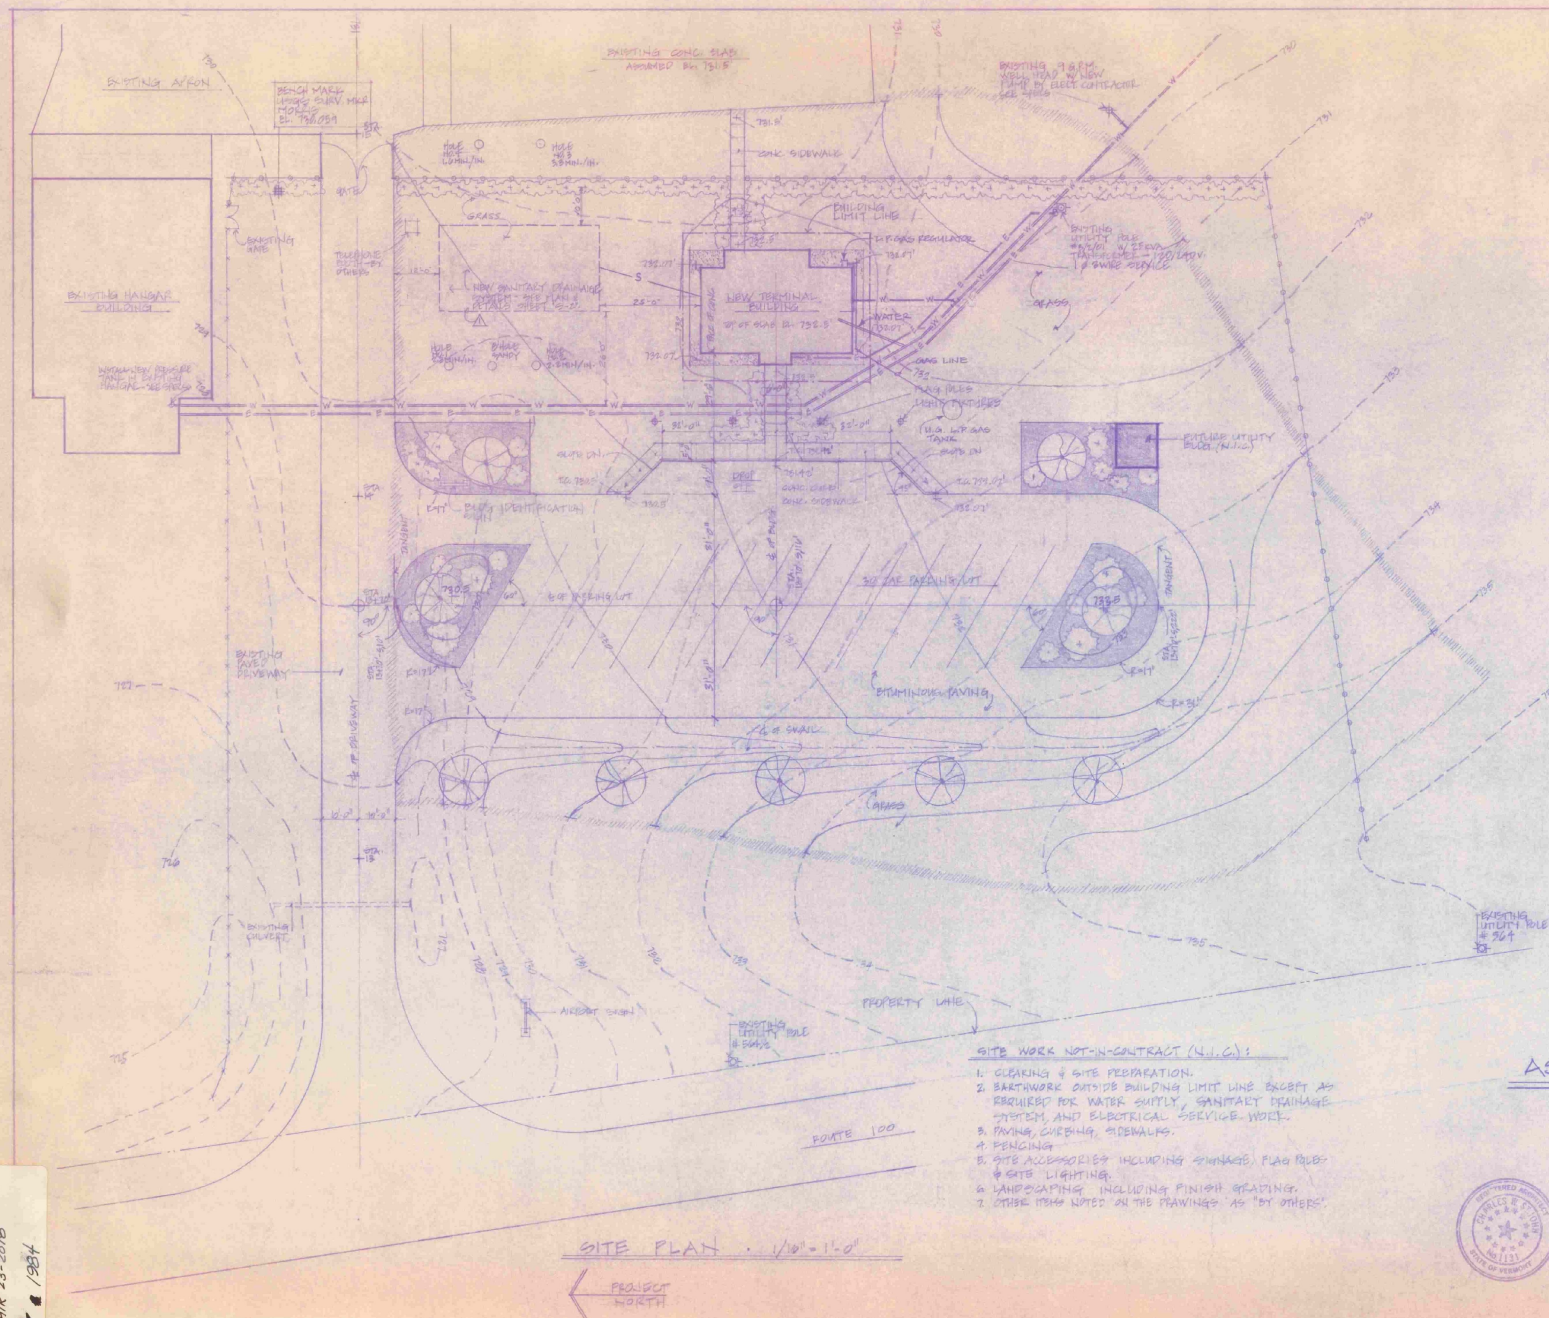

NOTES

1. EXISTING CONSTRUCTION NOT SHOWN ON PLAN IS TO BE REMOVED.
2. CONTOURS TAKEN FROM SURVEY OF MORRISVILLE-STOWE STATE AIRPORT DATED JUNE, 1962. PROJECT-AIR 23-2010 BY STATE OF VERMONT, AGENCY OF TRANSPORTATION.
3. CUT & FILL IS TO BE BALANCED. MAKE FINAL ADJUSTMENTS TO FILL & FINISH GRADING IN FIELD INSTRUCTION.

LEGEND

- EXISTING WATER LINE TO BE ABANDONED
- EXISTING WATER LINE - 1" PVC
- EXISTING ELECTRICAL SERVICE
- SANITARY SEWER LINE
- WATER LINE
- ELECTRICAL SERVICE
- GAS LINE
- EXISTING CHAIN LINK FENCE TO REMAIN
- WOOD POST & BEAM FENCE
- HEDGE
- DECIDUOUS TREE
- MULCH BED
- SHRUB
- CONIFEROUS TREE
- GRAVEL BED
- EXISTING CONTOUR
- NEW CONTOUR
- SUBDIVISION & GRADING LIMITS
- PERCOLATION TEST HOLE REPORTED JUNE 28, 1962 BY STATE OF VERMONT
- BUILDING LIMIT LINE











AS BUILT

SITE WORK NOT-IN-CONTRACT (4.1.6):


1. CLEARING & SITE PREPARATION.
2. BATHWORK OUTSIDE BUILDING LIMIT LINE EXCEPT AS REQUIRED FOR WATER SUPLY, SANITARY DRAINAGE SYSTEM AND ELECTRICAL SERVICE WORK.
3. PAVING, CURBING, SIDEWALKS.
4. FENCING.
5. SITE ACCESSORIES INCLUDING SIGNAGE, FLAG POLES & SITE LIGHTING.
6. LANDSCAPING INCLUDING FINISH GRADING.
7. OTHER ITEMS NOTED ON THE PLANNING AS "BY OTHERS".




STATE OF VERMONT			
DIVISION OF STATE BUILDINGS			
AGENCY OF ADMINISTRATION			
MONTPELIER,		VERMONT	
SITE PLAN			
NEW TERMINAL BUILDING			
MORRISVILLE-STOWE STATE AIRPORT			
VERMONT			
DATE JULY 2, 1984	SCALE 1/8" = 1'-0"	REVISIONS	DWS. NO. 8-1
DRAWN BY C.M.S.	APPROVED BY C.M.S.		1 OF 10

          

STATE OF VERMONT			
DIVISION OF STATE BUILDINGS			
AGENCY OF ADMINISTRATION		VERMONT	
MONTPELIER.			
<u>SITE DETAILS</u> NEW TERMINAL BUILDING MORRISVILLE/STONE STATE ASPH MORRISVILLE VERMONT			
DATE: JUNE 5, 1963	SCALE: AS SHOWN	REVISIONS:	DWG. NO. S 2
DRAWN BY: SPENCE	APPROVED BY: CWS		2

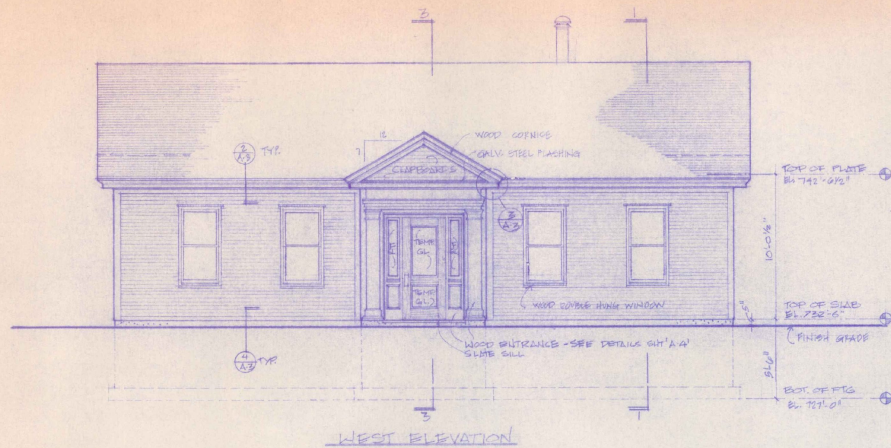


WEST ELEVATION

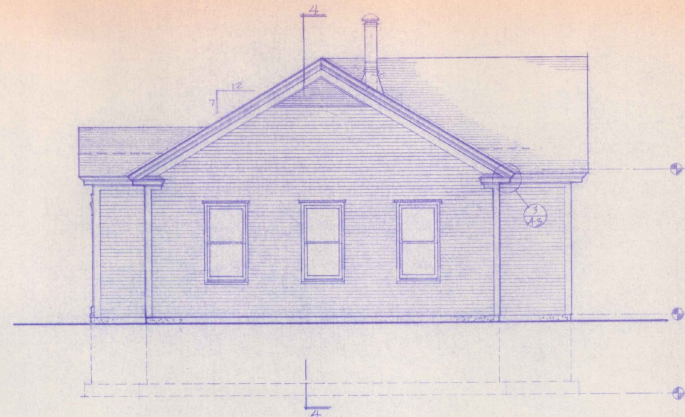


SOUTH ELEVATION

NOTE
TYP. DOUBLE HUNG WINDOW
CARABO PRIMER WOOD #2828

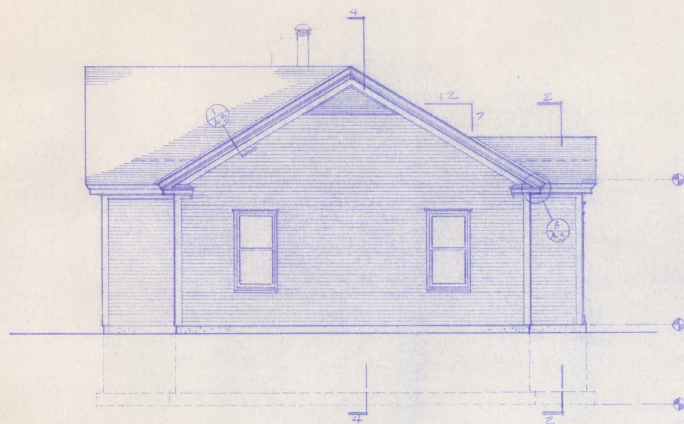

NORTH ELEVATION

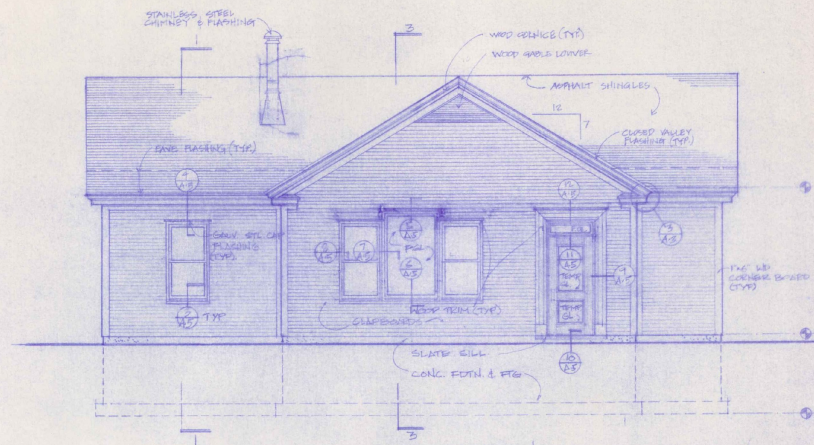


EAST ELEVATION

STATE OF VERMONT
DIVISION OF STATE BUILDINGS
AGENCY OF ADMINISTRATION
MONTPELIER, VERMONT


ELEVATIONS
NEW TERMINAL BUILDING
MORRISVILLE/STOLE STATE AIRPORT
MORRISVILLE VERMONT

DATE: JULY 2, 1949	SCALE: 1/4" = 1'-0"	REVISIONS:	DWG. NO. A-2
DRAWN BY: K. BERNARD	APPROVED BY: S.M.		1 of 10




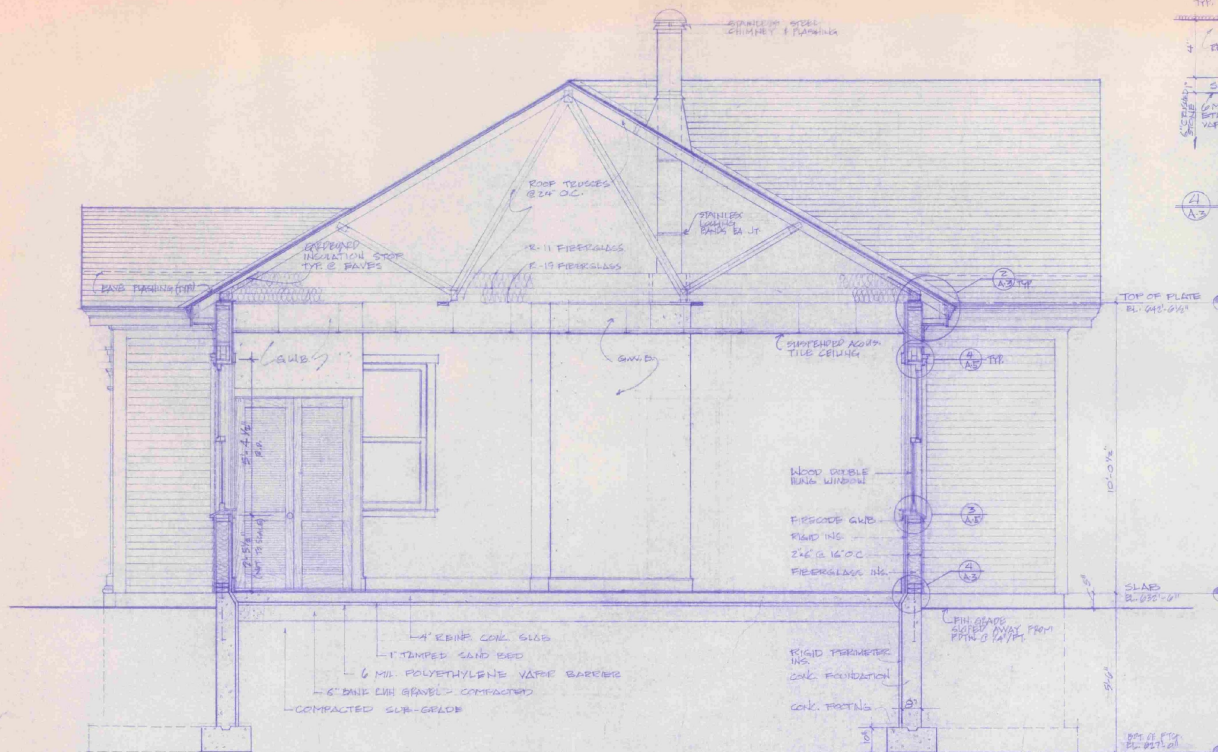


SECTION - 1
1/2" = 1'-0"

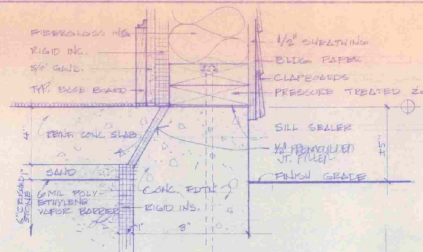


① TYPICAL FOUNDATION SILL
3" = 1'-0"

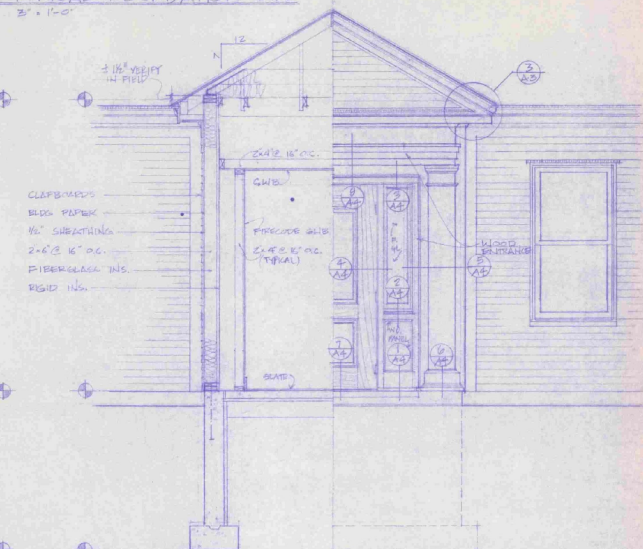


SECTION/ELEVATION - 2
1/2" = 1'-0"

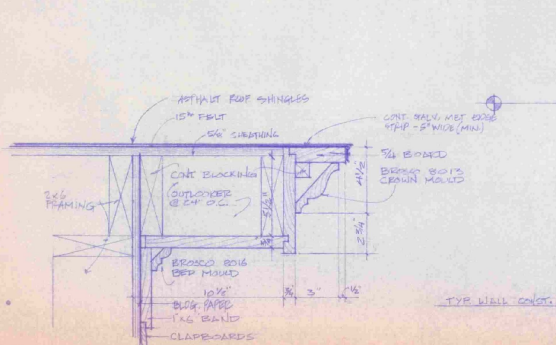

① TYPICAL CORNICE @ GABLE
3" = 1'-0"

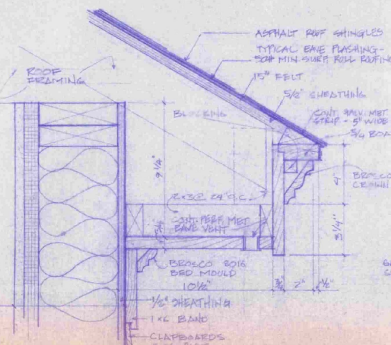

② TYPICAL CORNICE @ PAVES
3" = 1'-0"

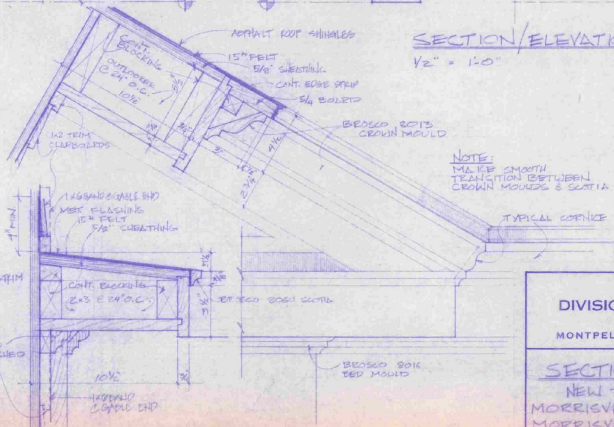


③ PEDIMENT DETAIL @ ENTRANCE
3" = 1'-0" (GABLE END DETAIL SIMILAR)




STATE OF VERMONT
DIVISION OF STATE BUILDINGS
AGENCY OF ADMINISTRATION
MONTPELIER, VERMONT

SECTIONS AND DETAILS
NEW TERMINAL BUILDING
MORRISVILLE/STONE STATE AIRPORT
MORRISVILLE VERMONT


DATE: JULY 6, 1983	SCALE: AS NOTED	REVISIONS:	DWG. NO. A - 3
DRAWN BY: GEMMEL	APPROVED BY: GMA		8 OF 10

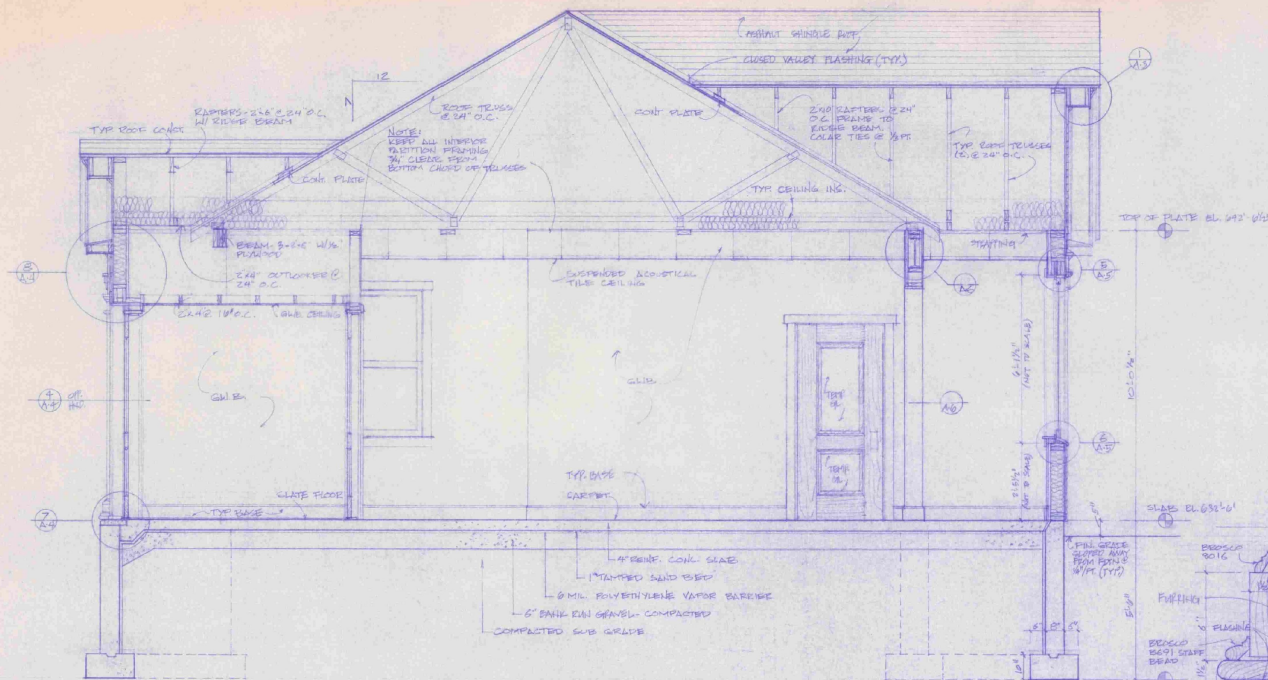


SECTION - 3
1/2" = 1'-0"

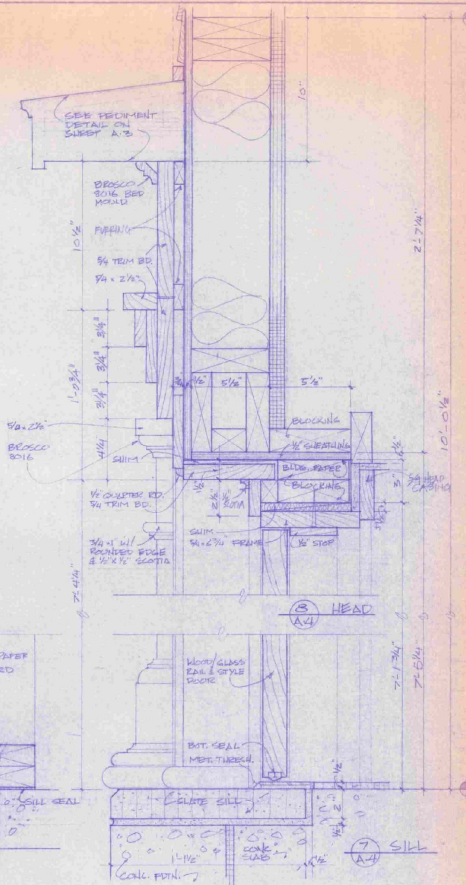

ENTRANCE/DOOR DETAILS - SECTION
3/8" = 1'-0"



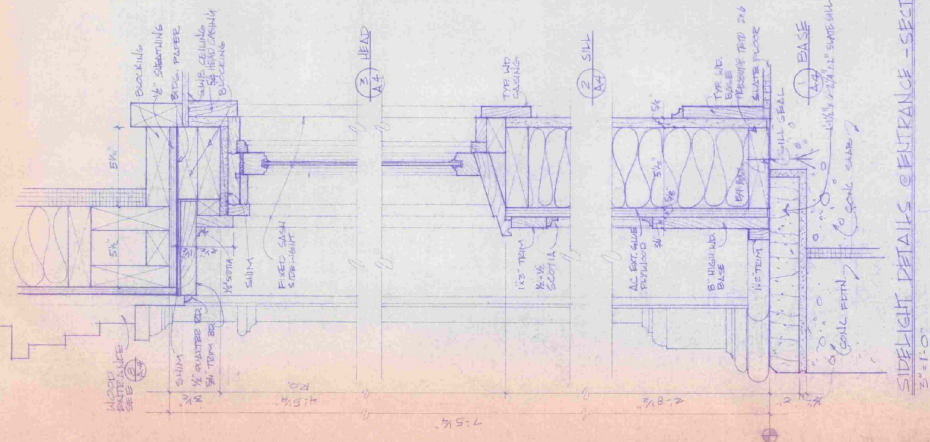


SIDEWALL DETAILS @ ENTRANCE - SECTION
3/8" = 1'-0"

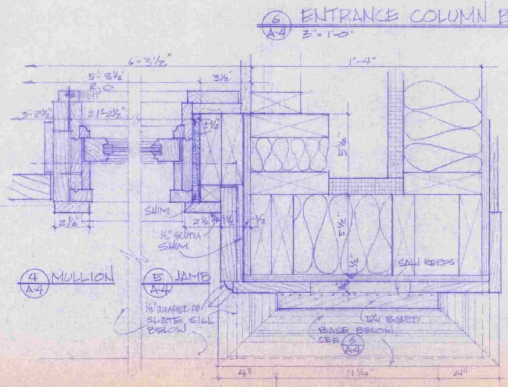

ENTRANCE/SIDEWALL DETAILS - PLAN
3/8" = 1'-0"

STATE OF VERMONT			
DIVISION OF STATE BUILDINGS			
AGENCY OF ADMINISTRATION			
MONTPELIER, VERMONT			
SECTIONS AND DETAILS			
NEW TERMINAL BUILDING			
MORRISVILLE/STOWE STATE AIRPORT			
VERMONT			
DATE:	SCALE:	REVISIONS:	DWG. NO.
JULY 6, 1983	AS NOTED		A-4
DRAWN BY:	APPROVED BY:		
S. KENNICOTT	C. W. B.		4 OF 10

   

A diagram of a bookshelf with two shelves. The top shelf is labeled 'SHELF' and the bottom shelf is labeled 'HOOKS (N.I.C)'. The diagram shows the shelves and the hooks attached to the side of the shelf.

COAT CL.

 
 
① INTERIOR ELEVATIONS
A5 $\frac{1}{4}'' = 1'-0''$




⑧ TYPICAL INTERIOR DOOR DETAILS
3" = 1'-0"




⑦ TYP. WOOD BASE
3" x 1 1/2"





DATE: JULY 4, 1983	SCALE: AS NOTED	REVISIONS:	DWG. NO. A-6
DRAWN BY: S. REMICK	APPROVED BY: CWS		8 OF 10

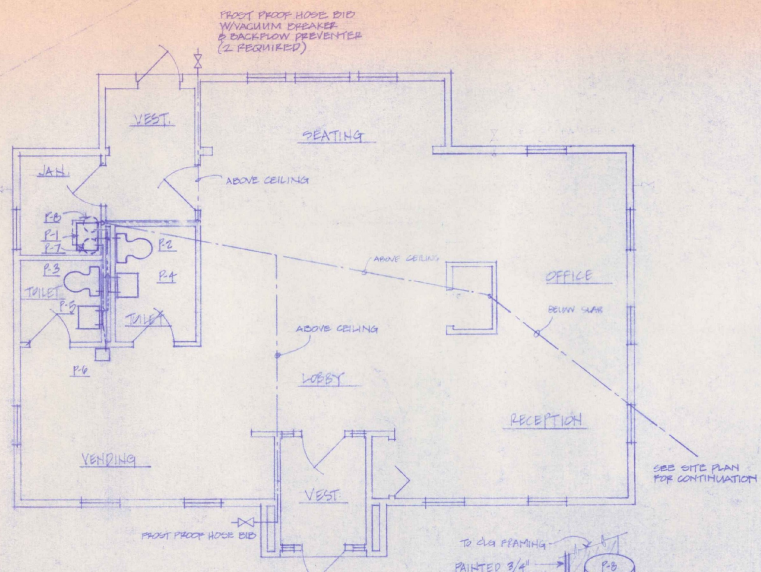

PLUMBING PLAN - WATER SUPPLY
1/4" = 1'-0"

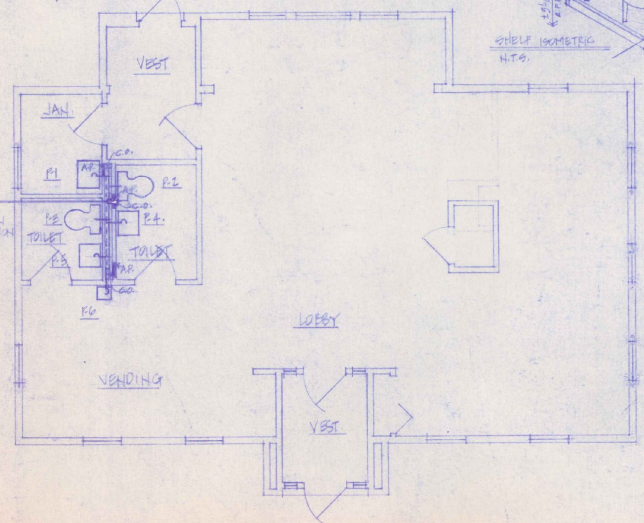


PLUMBING PLAN - SANITARY DRAINAGE
1/4" = 1'-0"

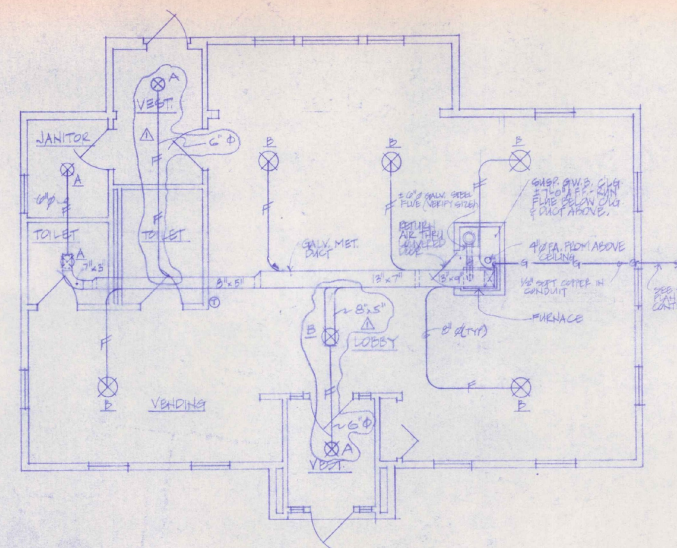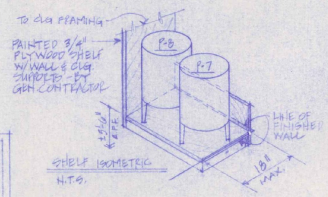


HEATING PLAN
1/4" = 1'-0"

NOTES:
1. OPERATION: FAN RUNS WHEN BONNET REACHES SET TEMPERATURE, FAN CAN OVERRIDE FOR SUMMER COOLING. ROOM THERMOSTAT STARTS GAS BURNER.

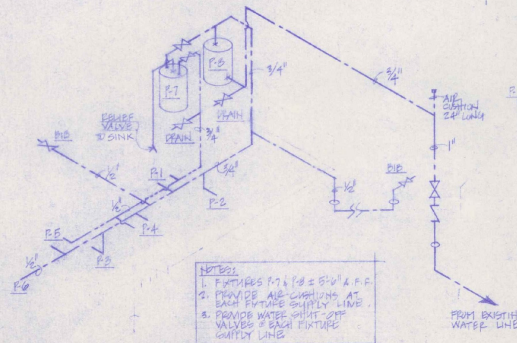

RISE DIAGRAM - WATER SUPPLY

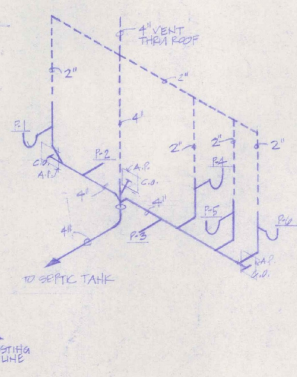

RISE DIAGRAM - SANITARY

HEATING LEGEND

- ⊗ DIFFUSER
- ⊙ THERMOSTAT
- ⊖ DRAFT DAMPER
- FA. FRESH AIR
- G. LIQ. GAS SUPPLY
- △ FLEXIBLE DUCT

PLUMBING LEGEND

- COLD WATER PIPING
- HOT WATER PIPING
- VENT PIPING
- SANITARY PIPING
- ⊗ GATE VALVE/BID
- ⊖ CHECK VALVE
- G.O. CLEAN OUT
- U TRAP
- ⊕ LAB. PENETRATION
- AP. ACCESS PANEL 12"x12" BY REBEKAH CONTRACTOR

PLUMBING FIXTURE SCHEDULE

NO.	MANUFACTURER	MODEL
R1	AMERICAN STD. SERVICE SINK	8379.019 WHITE
R2	AMERICAN STD. WATER CLOSET	8395.002 WHITE
R3	AMERICAN STD. LAVATORY	8395.002 WHITE
R4	AMERICAN STD. LAVATORY	8395.002 WHITE
R5	AMERICAN STD. LAVATORY	8395.002 WHITE
R6	AMERICAN STD. LAVATORY	8395.002 WHITE
R7	AMERICAN STD. LAVATORY	8395.002 WHITE
R8	AMERICAN STD. LAVATORY	8395.002 WHITE
R9	AMERICAN STD. LAVATORY	8395.002 WHITE
R10	AMERICAN STD. LAVATORY	8395.002 WHITE
R11	AMERICAN STD. LAVATORY	8395.002 WHITE
R12	AMERICAN STD. LAVATORY	8395.002 WHITE
R13	AMERICAN STD. LAVATORY	8395.002 WHITE
R14	AMERICAN STD. LAVATORY	8395.002 WHITE
R15	AMERICAN STD. LAVATORY	8395.002 WHITE
R16	AMERICAN STD. LAVATORY	8395.002 WHITE
R17	AMERICAN STD. LAVATORY	8395.002 WHITE
R18	AMERICAN STD. LAVATORY	8395.002 WHITE
R19	AMERICAN STD. LAVATORY	8395.002 WHITE
R20	AMERICAN STD. LAVATORY	8395.002 WHITE

HEATING EQUIPMENT SCHEDULE


NO.	MANUFACTURER	MODEL
F1	AMERICAN STD. SERVICE SINK	8379.019 WHITE
F2	AMERICAN STD. WATER CLOSET	8395.002 WHITE
F3	AMERICAN STD. LAVATORY	8395.002 WHITE
F4	AMERICAN STD. LAVATORY	8395.002 WHITE
F5	AMERICAN STD. LAVATORY	8395.002 WHITE
F6	AMERICAN STD. LAVATORY	8395.002 WHITE
F7	AMERICAN STD. LAVATORY	8395.002 WHITE
F8	AMERICAN STD. LAVATORY	8395.002 WHITE
F9	AMERICAN STD. LAVATORY	8395.002 WHITE
F10	AMERICAN STD. LAVATORY	8395.002 WHITE
F11	AMERICAN STD. LAVATORY	8395.002 WHITE
F12	AMERICAN STD. LAVATORY	8395.002 WHITE
F13	AMERICAN STD. LAVATORY	8395.002 WHITE
F14	AMERICAN STD. LAVATORY	8395.002 WHITE
F15	AMERICAN STD. LAVATORY	8395.002 WHITE
F16	AMERICAN STD. LAVATORY	8395.002 WHITE
F17	AMERICAN STD. LAVATORY	8395.002 WHITE
F18	AMERICAN STD. LAVATORY	8395.002 WHITE
F19	AMERICAN STD. LAVATORY	8395.002 WHITE
F20	AMERICAN STD. LAVATORY	8395.002 WHITE

REVISED 10/11/83. JTD. H.R. HED


STATE OF VERMONT
DIVISION OF STATE BUILDINGS
AGENCY OF ADMINISTRATION
MONTPELIER, VERMONT

MECHANICAL PLANS
NEW TERMINAL BUILDING
MORRISVILLE/STONE STATE AIRPORT
MORRISVILLE VERMONT

DATE: 10/11/83	SCALE: 1/4" = 1'-0"	REVISIONS:	DWG. NO. 14-1
DRAWN BY: SWS	APPROVED BY: H.J.S.		3 OF 10

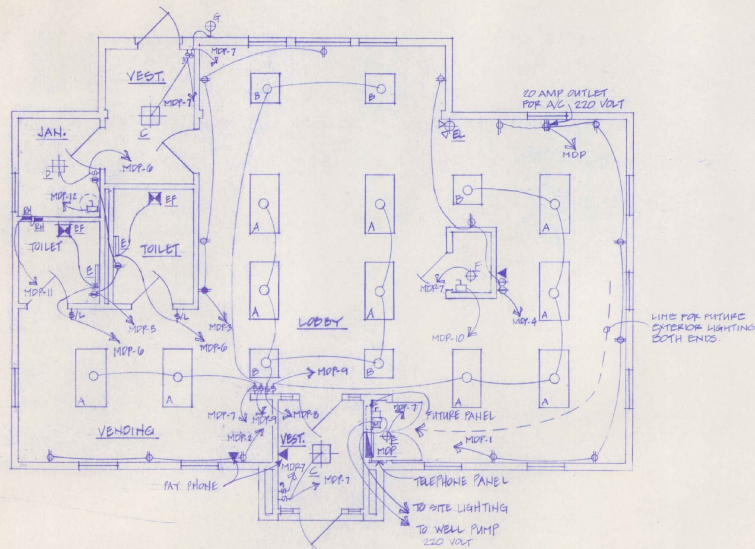

ELECTRICAL PLAN

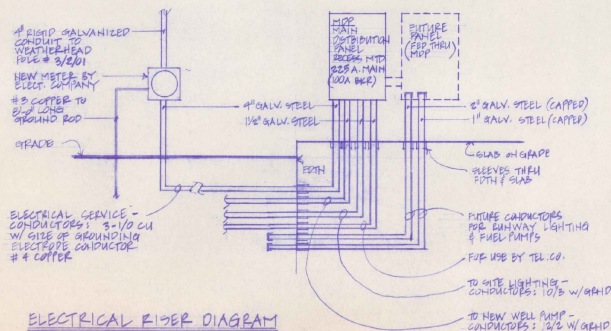

ELECTRICAL Riser DIAGRAM

NOTE: USE PVC CONDUIT EXCEPT AT THE FOLLOWING LOCATIONS - GALV. STEEL ABOVE GRADE AT MOTORS & PRE LINED SHEEP BENDS.

MARK	DESCRIPTION	MODEL #
A	2"x4" RECESS MTD. FLUOR. FIXT. "LITHONIA" W/2-40 W. LAMPS	2 99 240 AIC
B	2"x2" RECESS MTD. FLUOR. FIXT. "LITHONIA" W/ 2-40 W. LAMPS	2 99 2440 AIC
C	18"x15" SURFACE MTD. INCAND. FXT. "PRESOLITE" W/ 2-60W. BULBS	3601 WH
D	10"x10" RECESS MTD. INCAND. FXT. "PRESOLITE" W/ 1-75 W. BULB	1015 HF-1
E	18" SURFACE MTD. FLUOR. FIXT. "PRESOLITE" W/ 1-40 W. LAMP	WB-10
F	SURFACE MTD. INCAND. FXT. - RECESSED WITH PAUL GRAY. 1-60W LAMP	-
G	EXHAUST MTD. INCAND. FXT. FOR EXTERIOR LOCATED. WHITE FLOOR & BLACK BEACON. 1-100W. LAMP. - PRESOLITE LIGHTING	P-5026-60
EF	BATHROOM VENTILATOR 80CFM HORIZONTAL DISCHARGE WITH BACK DRAFT DAMPER. "THERMADORE" TRADE WIND. (SEE NOTE #1, BELOW)	1205
EL	EMERGENCY LIGHT - TWIN CYLINDER "DUAL-LITE" W/ BATTERY & CHARGER, TEST SWITCH.	QWA 206
EH	FORCED AIR WALL HEATER "MARKET MARK-1" 1000 W. 240V WITH THERMAL CUTOFF AND BUILT-IN TWO POLE THERMOSTAT	H3133 T2

NOTE #1: ELECTRICAL CONTRACTOR TO SUPPLY & INSTALL 4" GALV. STEEL DUCT WITH ELBOWS. DUCT TO RUN VERTICALLY FROM EXHAUST PAN TO A POINT ABOVE CEILING INSULATION. PROVIDE SUPPORTS AS NECESSARY.

CIRCUIT NUMBER	BREAKER AMP	POLES	MARKINGS	REMARKS
1	20	1	RECEPTACLES OFFICE & RECEPT.	
2	20	1	RECEPTACLES VENDING	
3	20	1	SEATING & LOBBY RECEPTACLES	
4	20	1	SEATING & LOBBY RECEPTACLES	
5	20	1	RECEPTACLES JAN. & TOILET	GROUND FAULT BREAKER
6	20	1	LIGHTING JAN. & TOILET	
7	20	1	LIGHTING VESTIBULES & VENDING	
8	20	1	LIGHTING LOBBY	
9	20	1	LIGHTING SEATING/OFFICE/RECEPT	
10	20	1	FURNACE	
11	20	2	RESISTANCE HEATERS	
12	20	1	WATER HEATER	
13	20	1	WELL PUMP	
14	20	1	SITE LIGHTING	GROUND FAULT BREAKER
15-20	20	1	SPACES	
21-24	-	-	-	

⊕	DUPLEX RECEPTACLE 20A. 10" A.F.F.
⊕	DUPLEX RECEPTACLE 20A. 40" A.F.F.
⊕	GROUND FAULT
⊕	QUICK RECEPTACLE 8A" A.F.F.
⊕	TELEPHONE JACK
⊕	DISCONNECT - FIXED
⊕	SINGLE POLE SWITCH 15A 40" A.F.F.
⊕	THREE WAY SWITCH 15A 40" A.F.F.
⊕	SINGLE POLE SWITCH 15A 40" A.F.F. WITH SIGNAL LAMP ON PLATE.
⊕	BATHROOM VENTILATOR
⊕	FLUORESCENT FIXTURE - LETTER DENOTES TYPE
⊕	FLUORESCENT FIXTURE - LETTER DENOTES TYPE
⊕	EMERGENCY LIGHT
⊕	FLUORESCENT FIXTURE - LETTER DENOTES TYPE
⊕	RESISTANCE HEATER WITH INTEGRAL CONTROL
⊕	BLURST WATER HEATER - BY MECH. CONTRACTOR. ELECT. CONTRACTOR TO PROVIDE POWER & DISCONNECT.
⊕	REMOTE MOTOR CONTROL BOX

STATE OF VERMONT			
DIVISION OF STATE BUILDINGS			
AGENCY OF ADMINISTRATION			
MONTPELIER, VERMONT			
<u>ELECTRICAL PLAN</u>			
NEW TERMINAL BUILDING			
MORRISVILLE/STOWE STATE AIRPORT			
MORRISVILLE VERMONT			
DATE: JULY 6, 1983	SCALE: 1/4" = 1'-0"	REVISIONS:	DWG. NO. E-1
DRAWN BY: C.W.S.	APPROVED BY:		10 OF 10

