










DOOR #	SIZE	TYPE	HWN	FINISH	COMMENTS
1	3'6" x 2'4"	PULL & SHUT	1	STAIN	TRANSOM
2	3'6" x 2'4"	PULL & SHUT	2	STAIN	TRANSOM
3	3'6" x 1'4"	FLUSH	1	STAIN	LITE
4	2'6" x 1'4"	FLUSH	4	-	-
5	2'6" x 1'4"	FLUSH	4	-	1' LABEL
6	2'6" x 1'4"	FLUSH	3	-	-
7	2'6" x 1'4"	FLUSH	3	-	-




- GENERAL NOTES**
1. ALL DIMENSIONS ARE ROUGH DIMENSIONS (FACE OF STUD, CONC, ETC.) UNLESS NOTED OTHERWISE.
 2. SEE DEMOLITION PLAN FOR CONSTRUCTION UNITS.
 3. CONTRACTOR SHALL FIELD CHECK AND VERIFY EXISTING CONDITIONS AND SHALL BE RESPONSIBLE FOR CORRELATION WITH NEW CONSTRUCTION.
 4. PLANS OF THE EXISTING BUILDINGS WILL BE MADE AVAILABLE TO THE CONTRACTOR FOR REFERENCE ONLY, AT THE DISCRETION OF THE ARCHITECT.

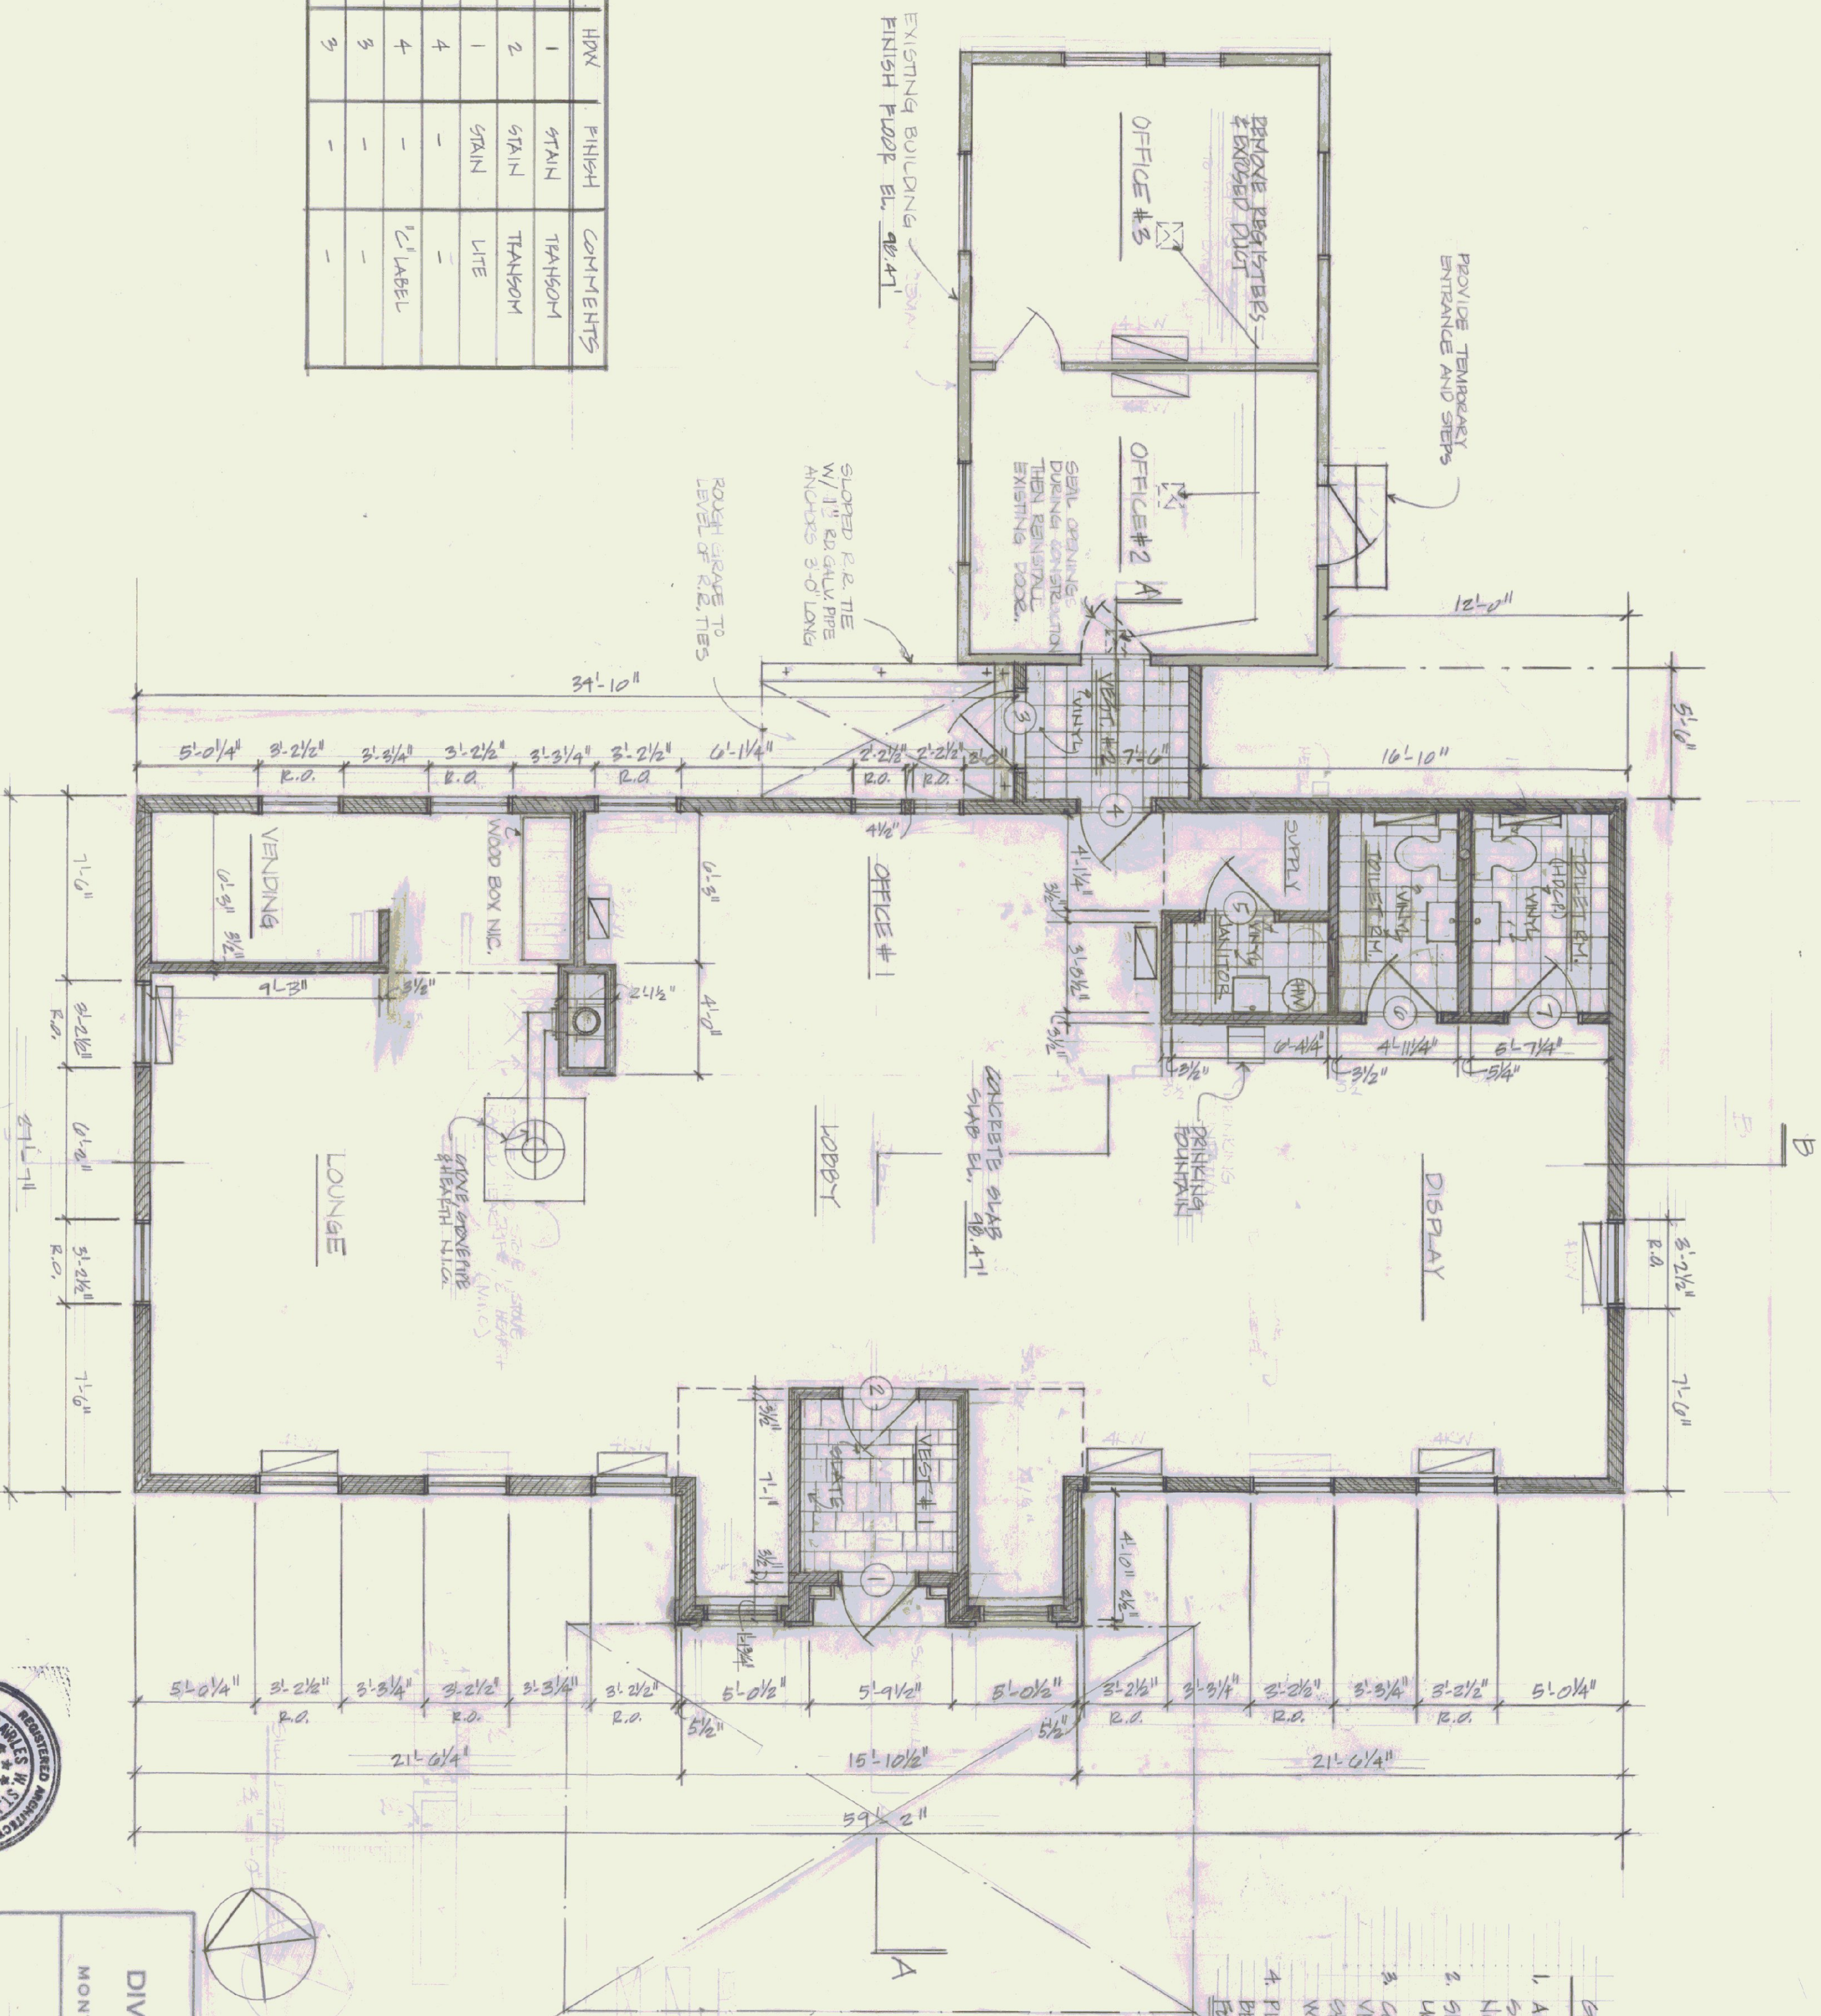


STATE OF VERMONT			
DIVISION OF STATE BUILDINGS			
AGENCY OF ADMINISTRATION			
MONTPELIER, VERMONT			
FLOOR PLAN			
SPRINGFIELD STATE AIRPORT TERMINAL			
SPRINGFIELD VERMONT			
DATE: AUG 22, 1981	SCALE: 1/4" = 1'-0"	REVISIONS:	DWG. NO. A-1
DRAWN BY: H4	APPROVED BY: CWS		2 OF 7

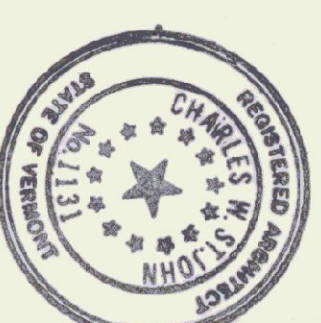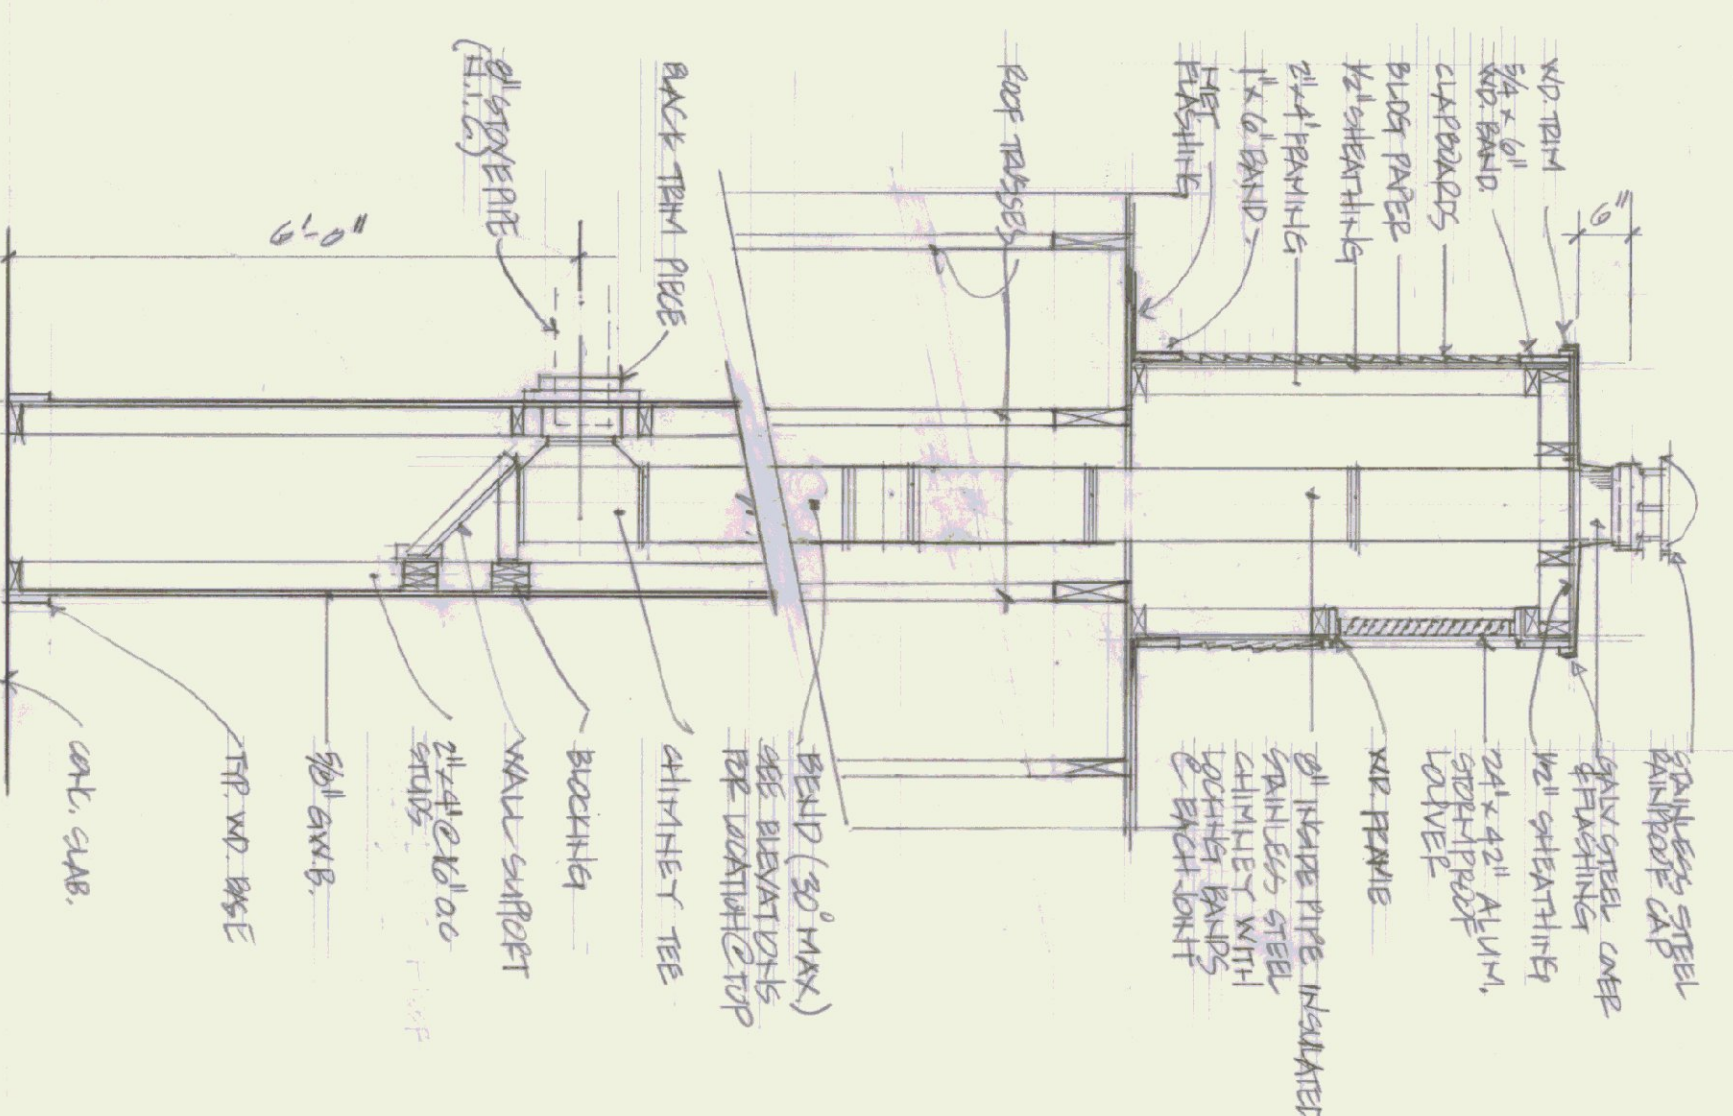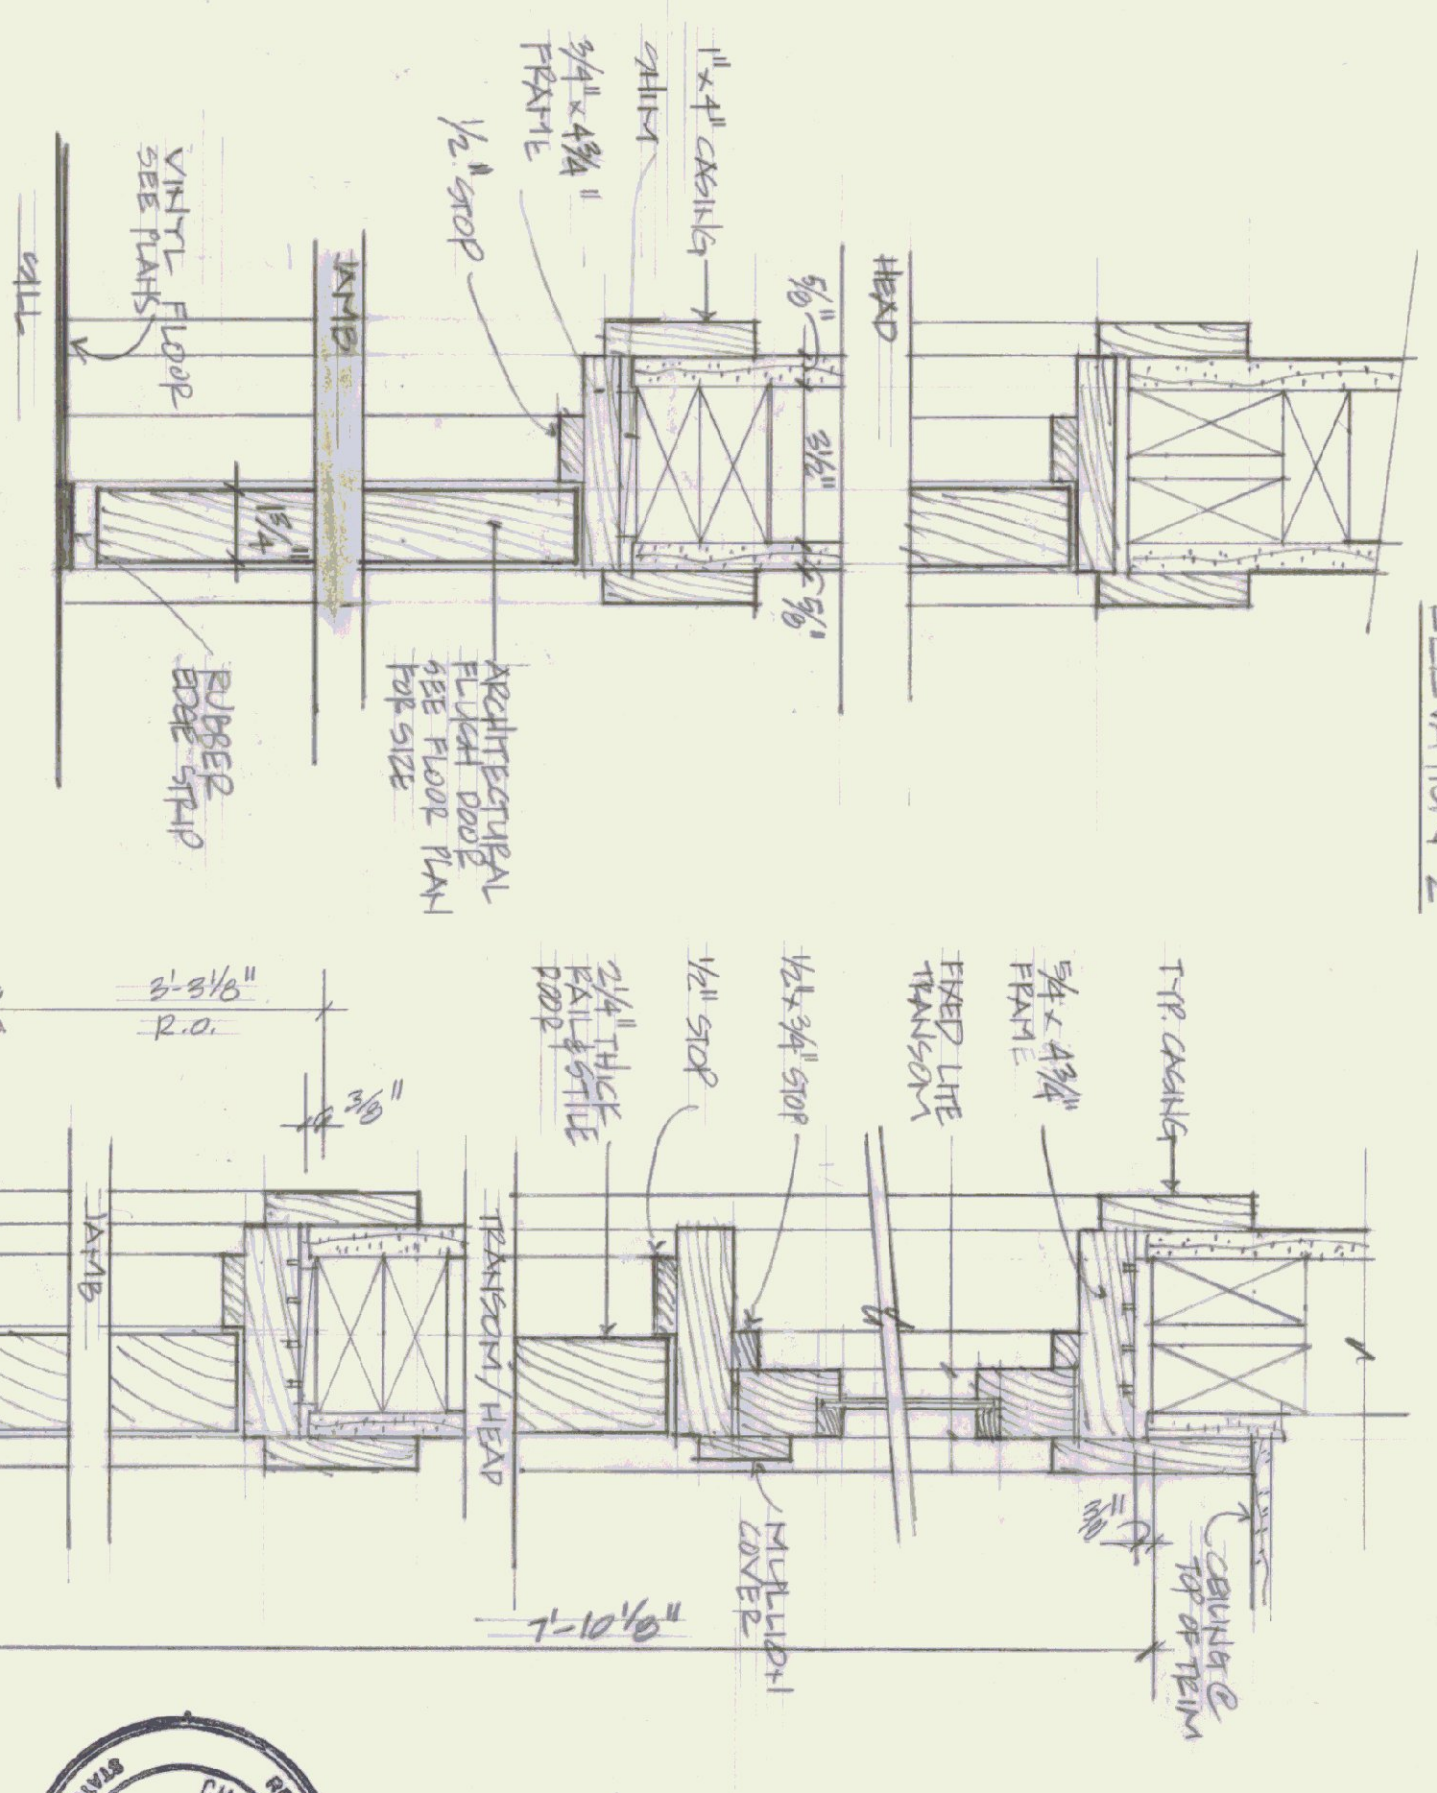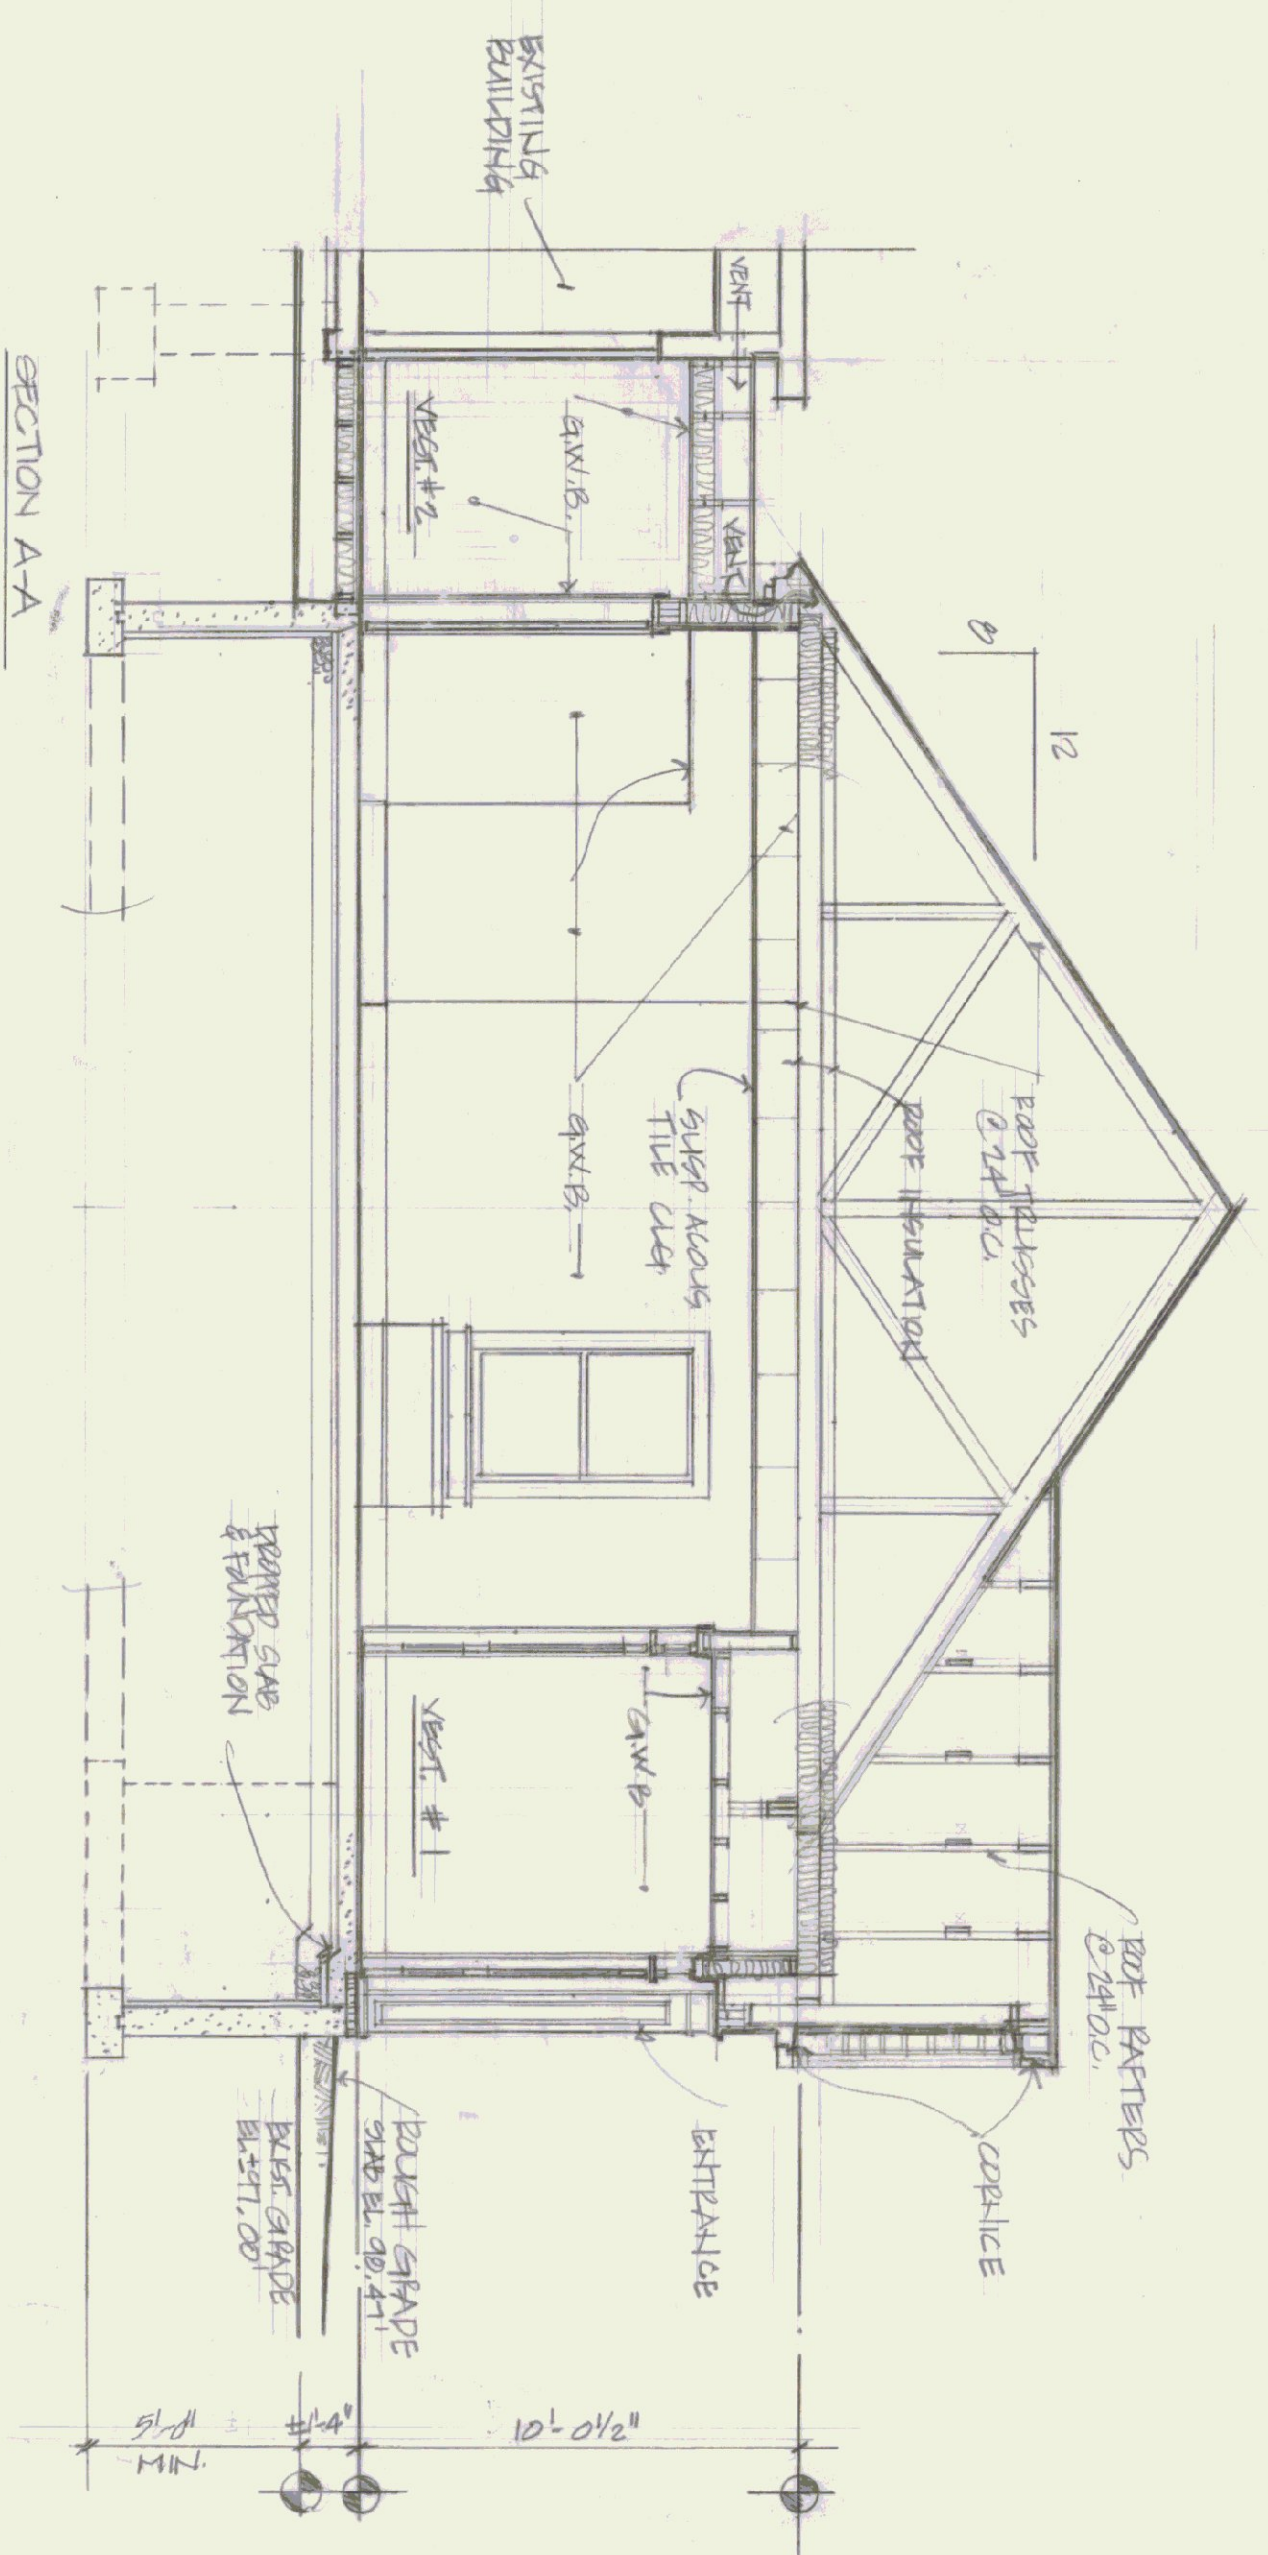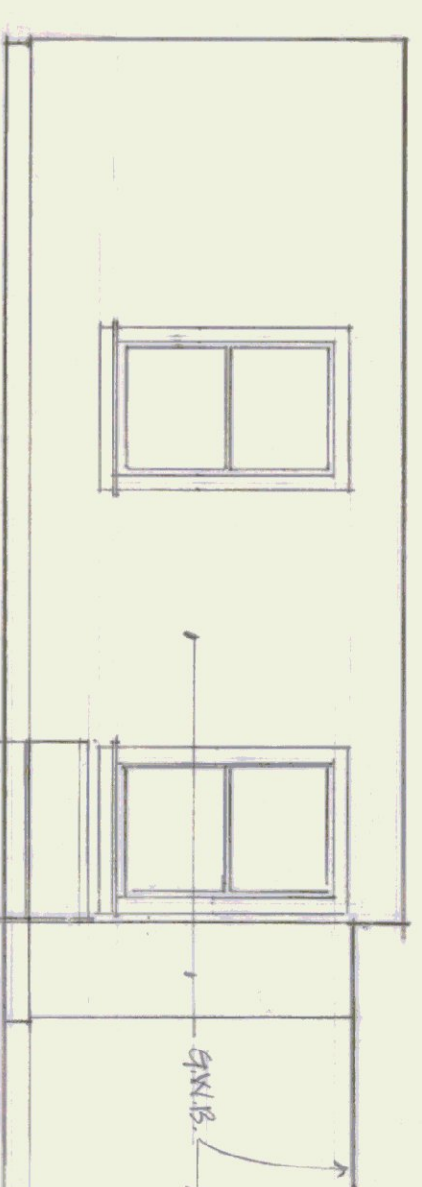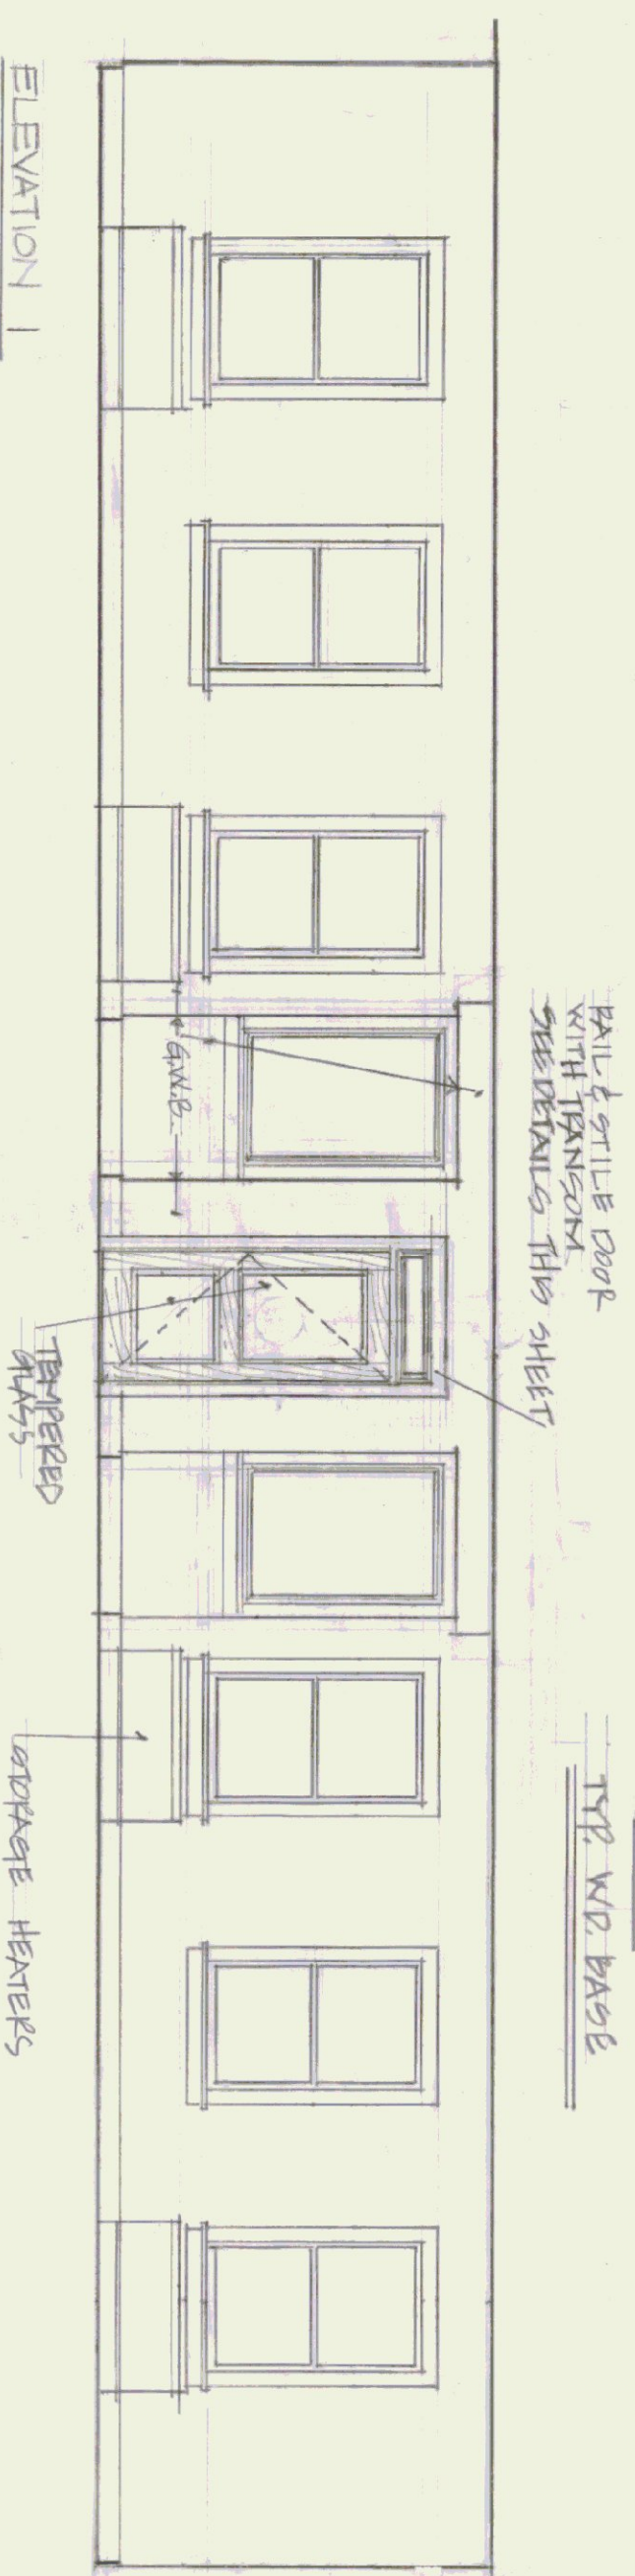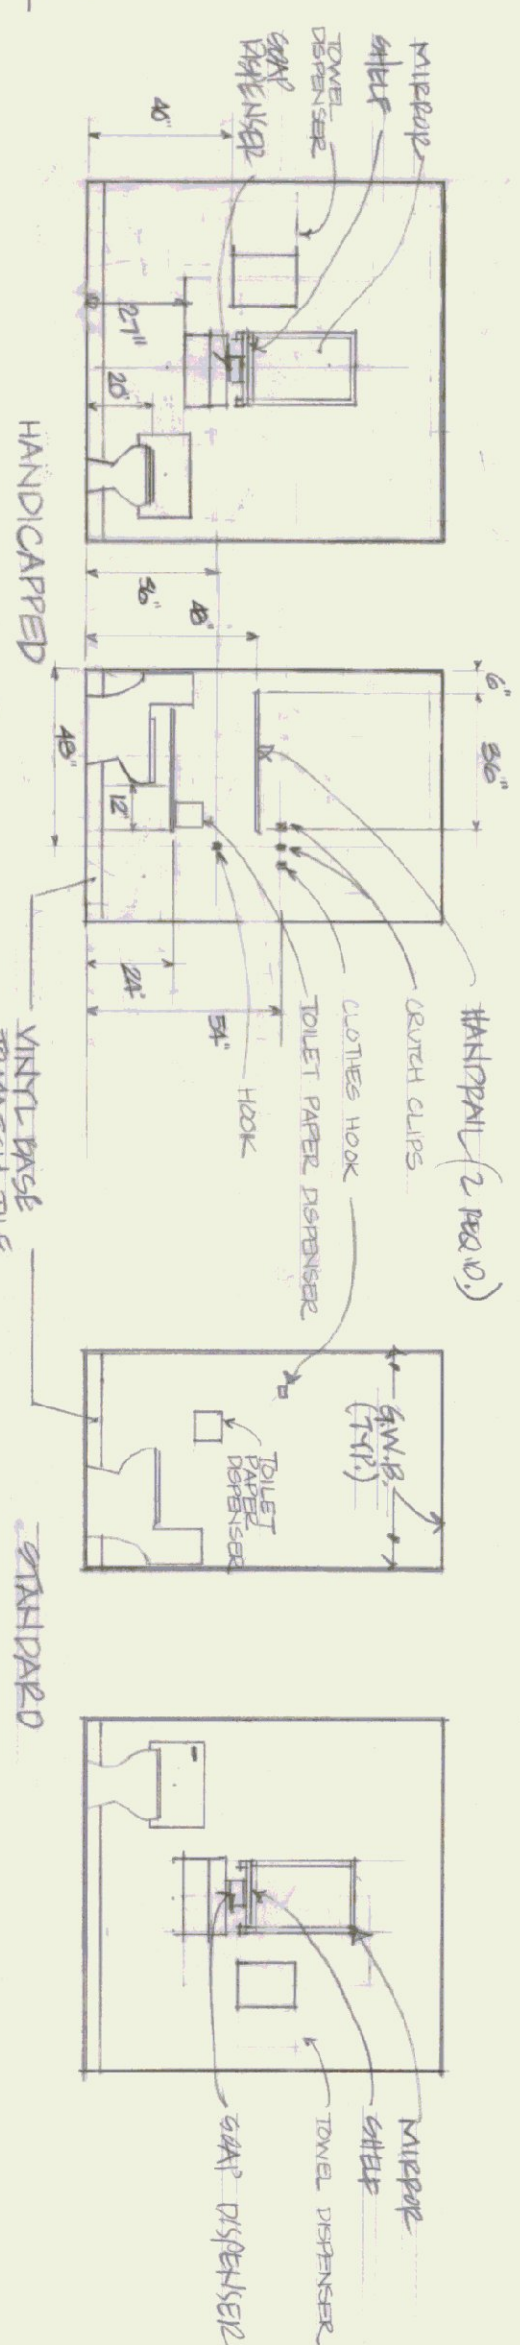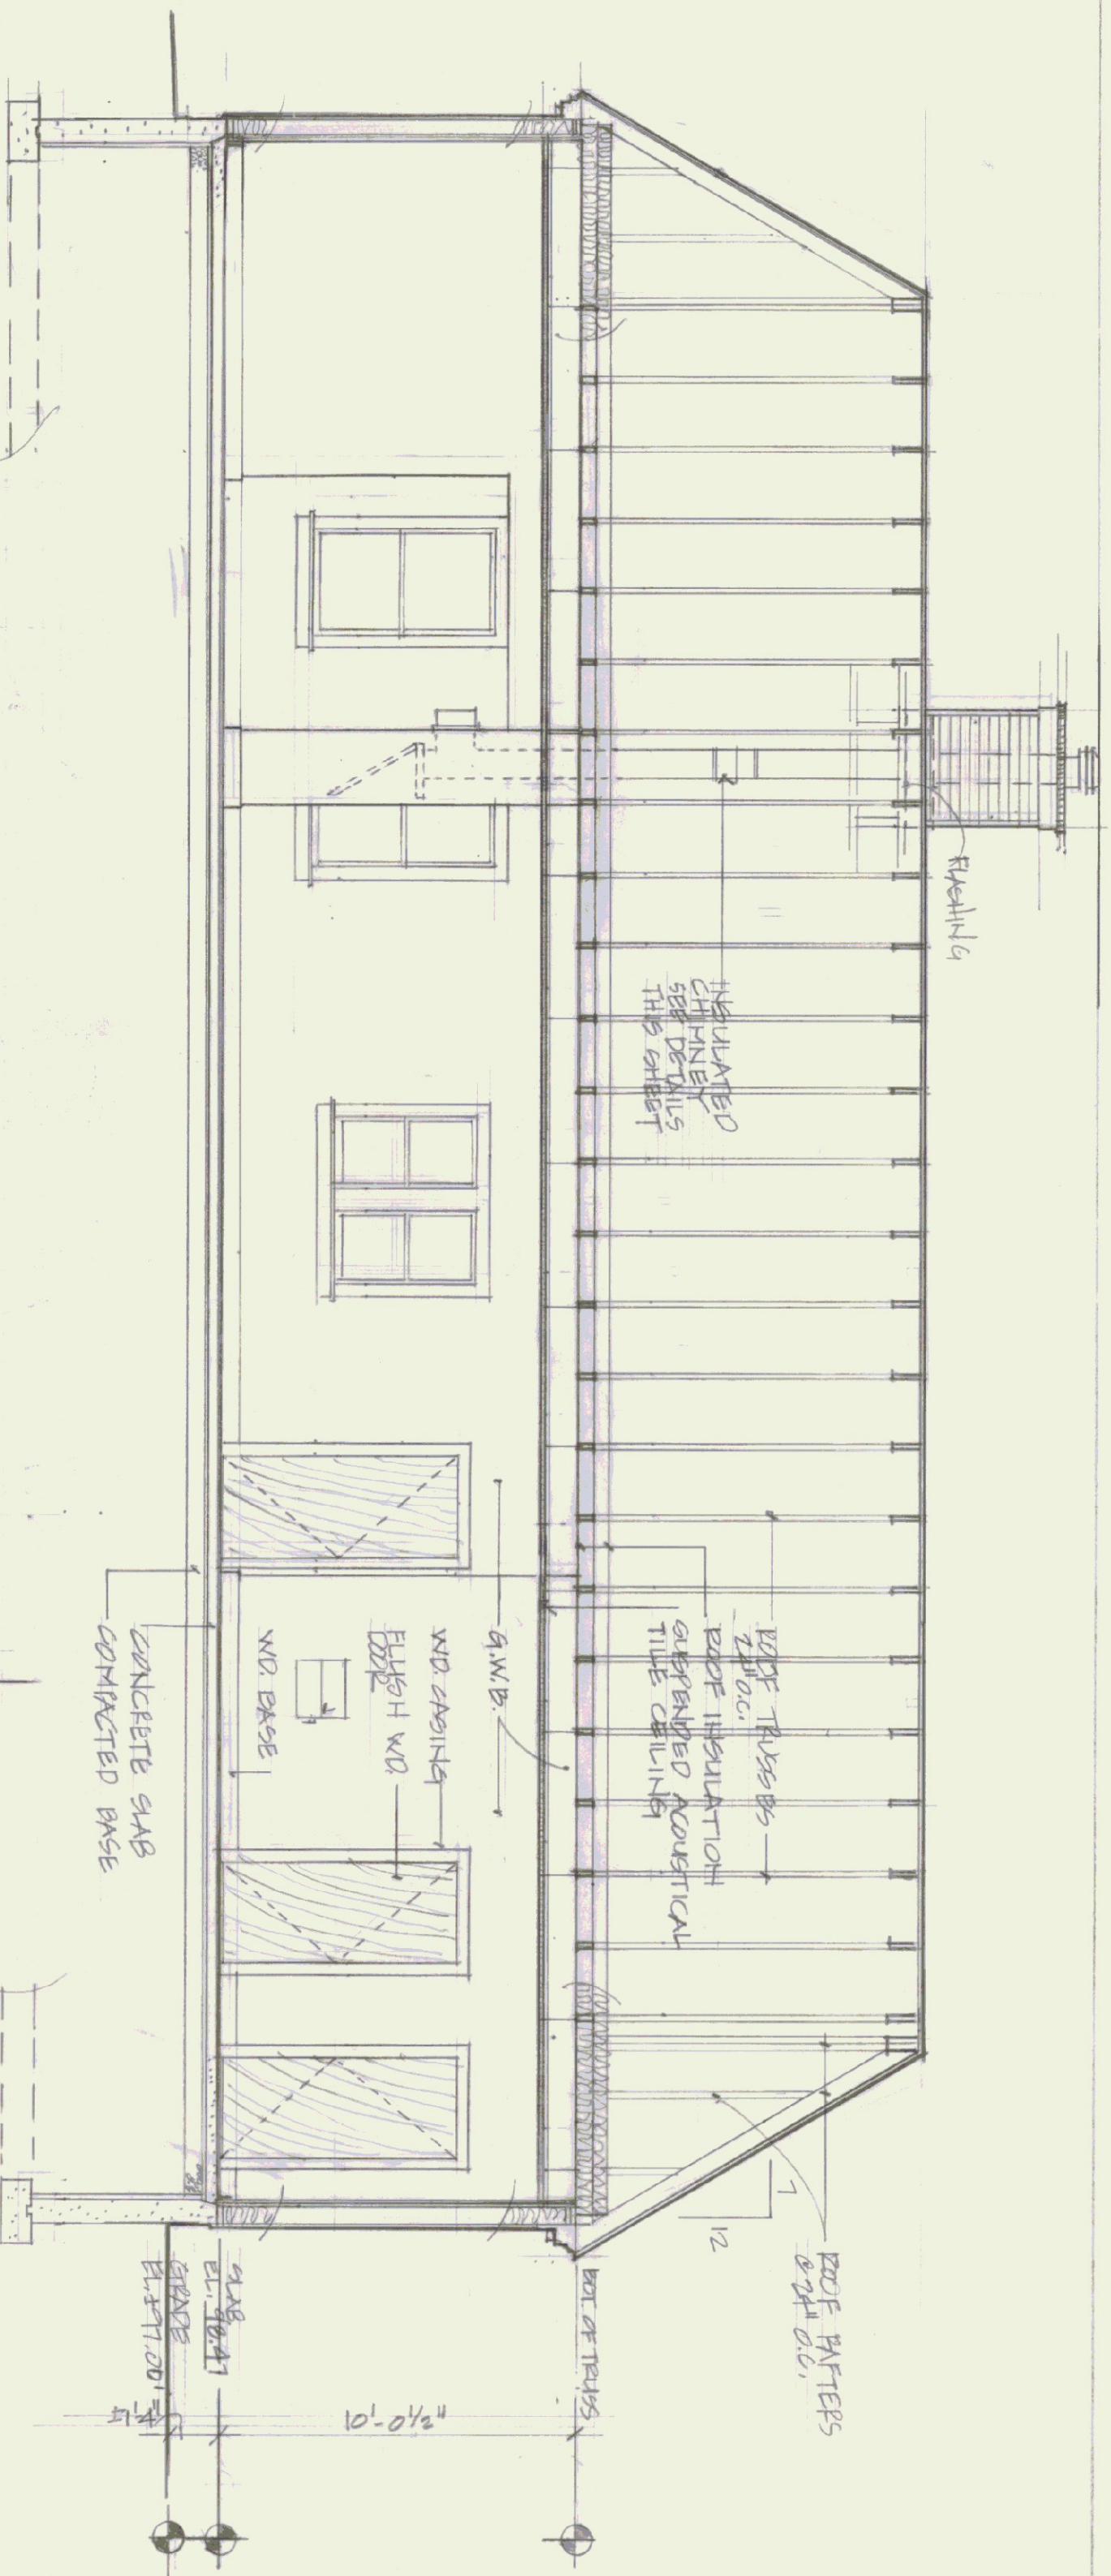


DATE:		AUG. 26, 1921	
DRAWN BY:		H. F. COWS	
SCALE:		1" = 10'	
APPROVED BY:		H. F. COWS	
REVISIONS:			
DWG. NO.		A.3	
4 OF 9			

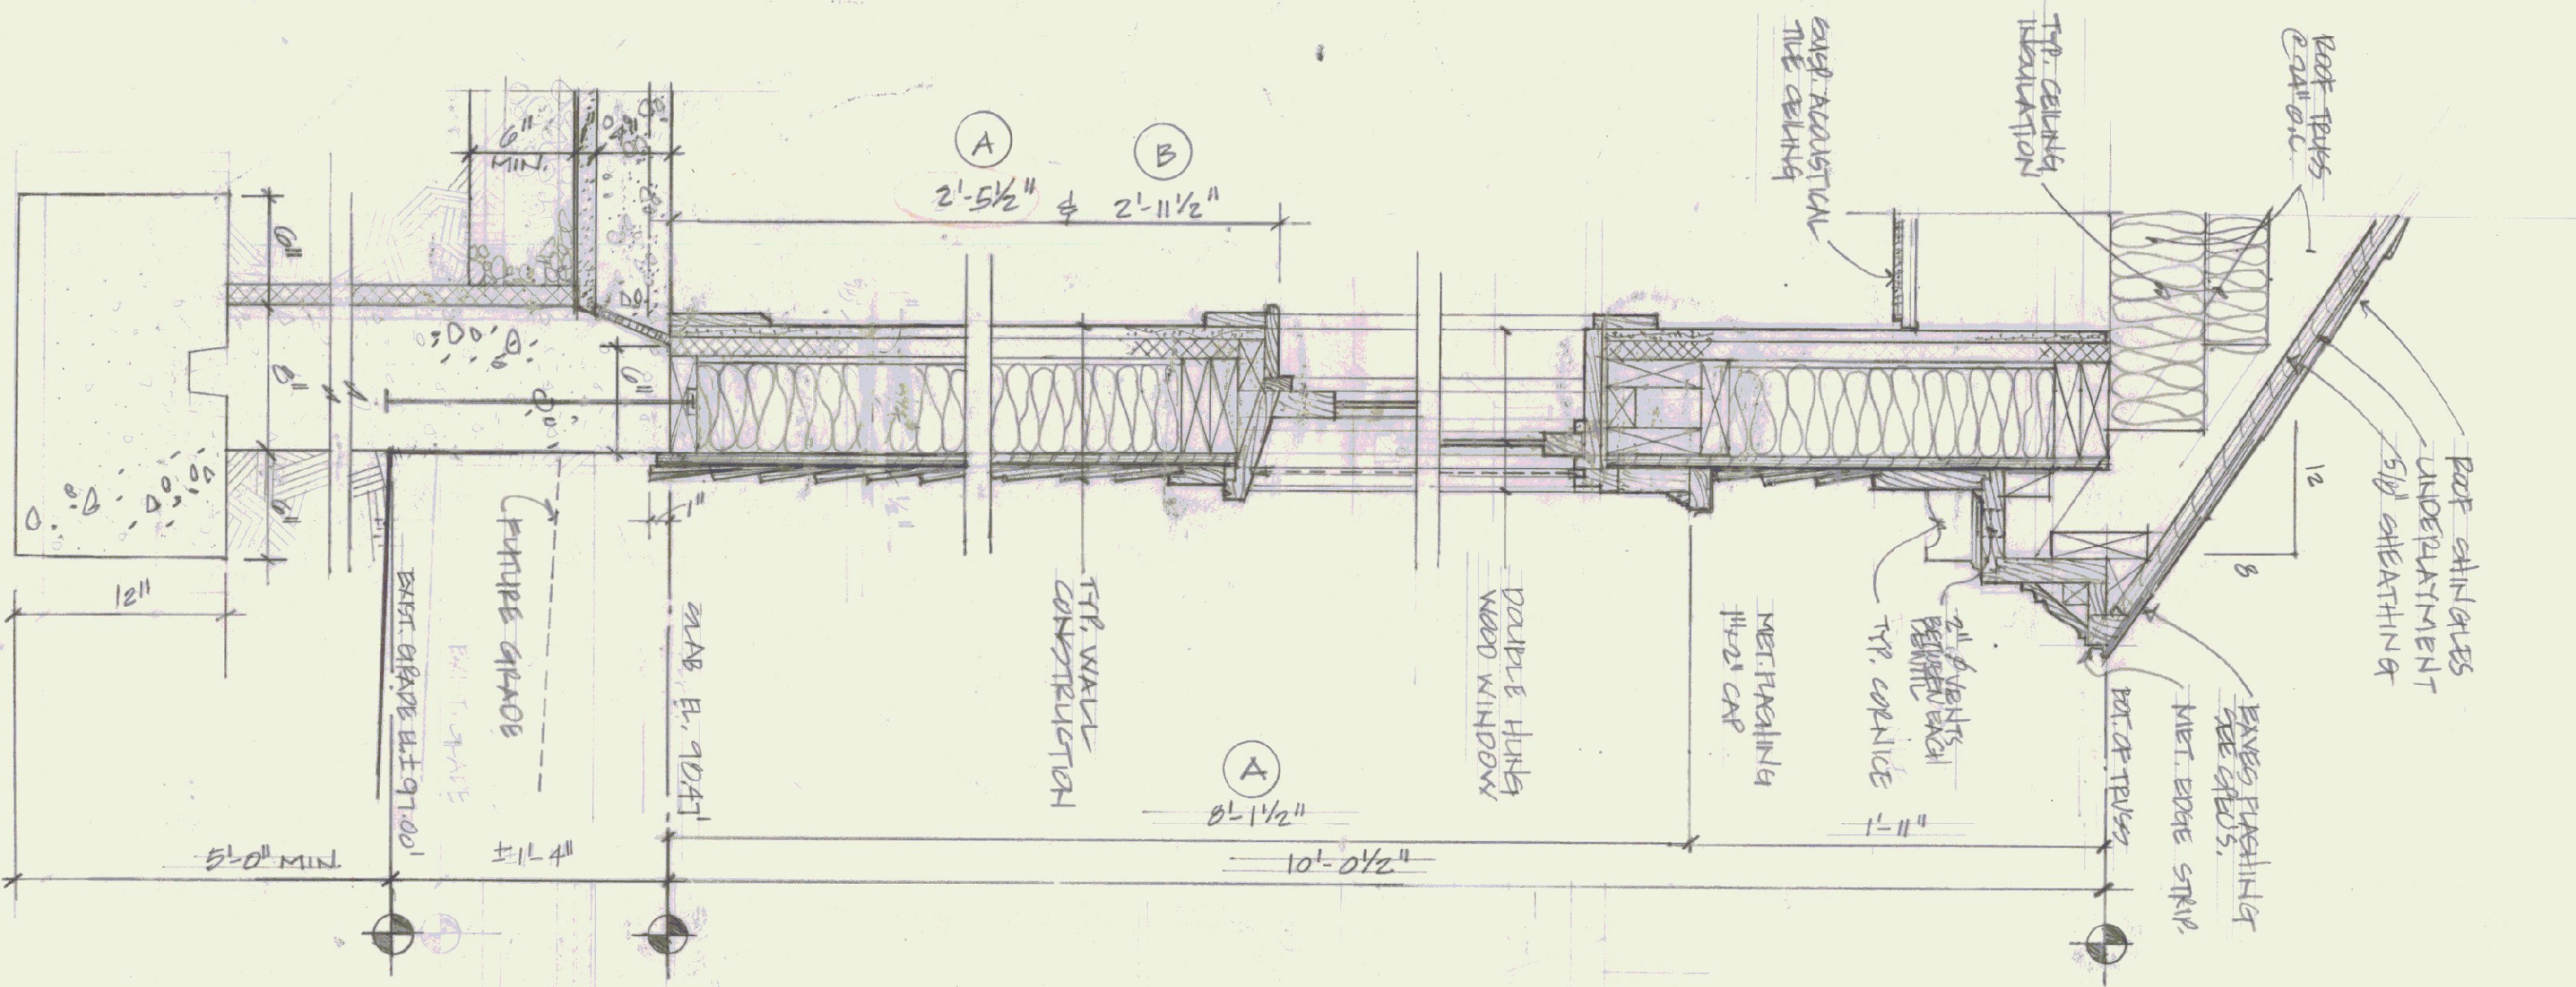


1 SECTION
A-A

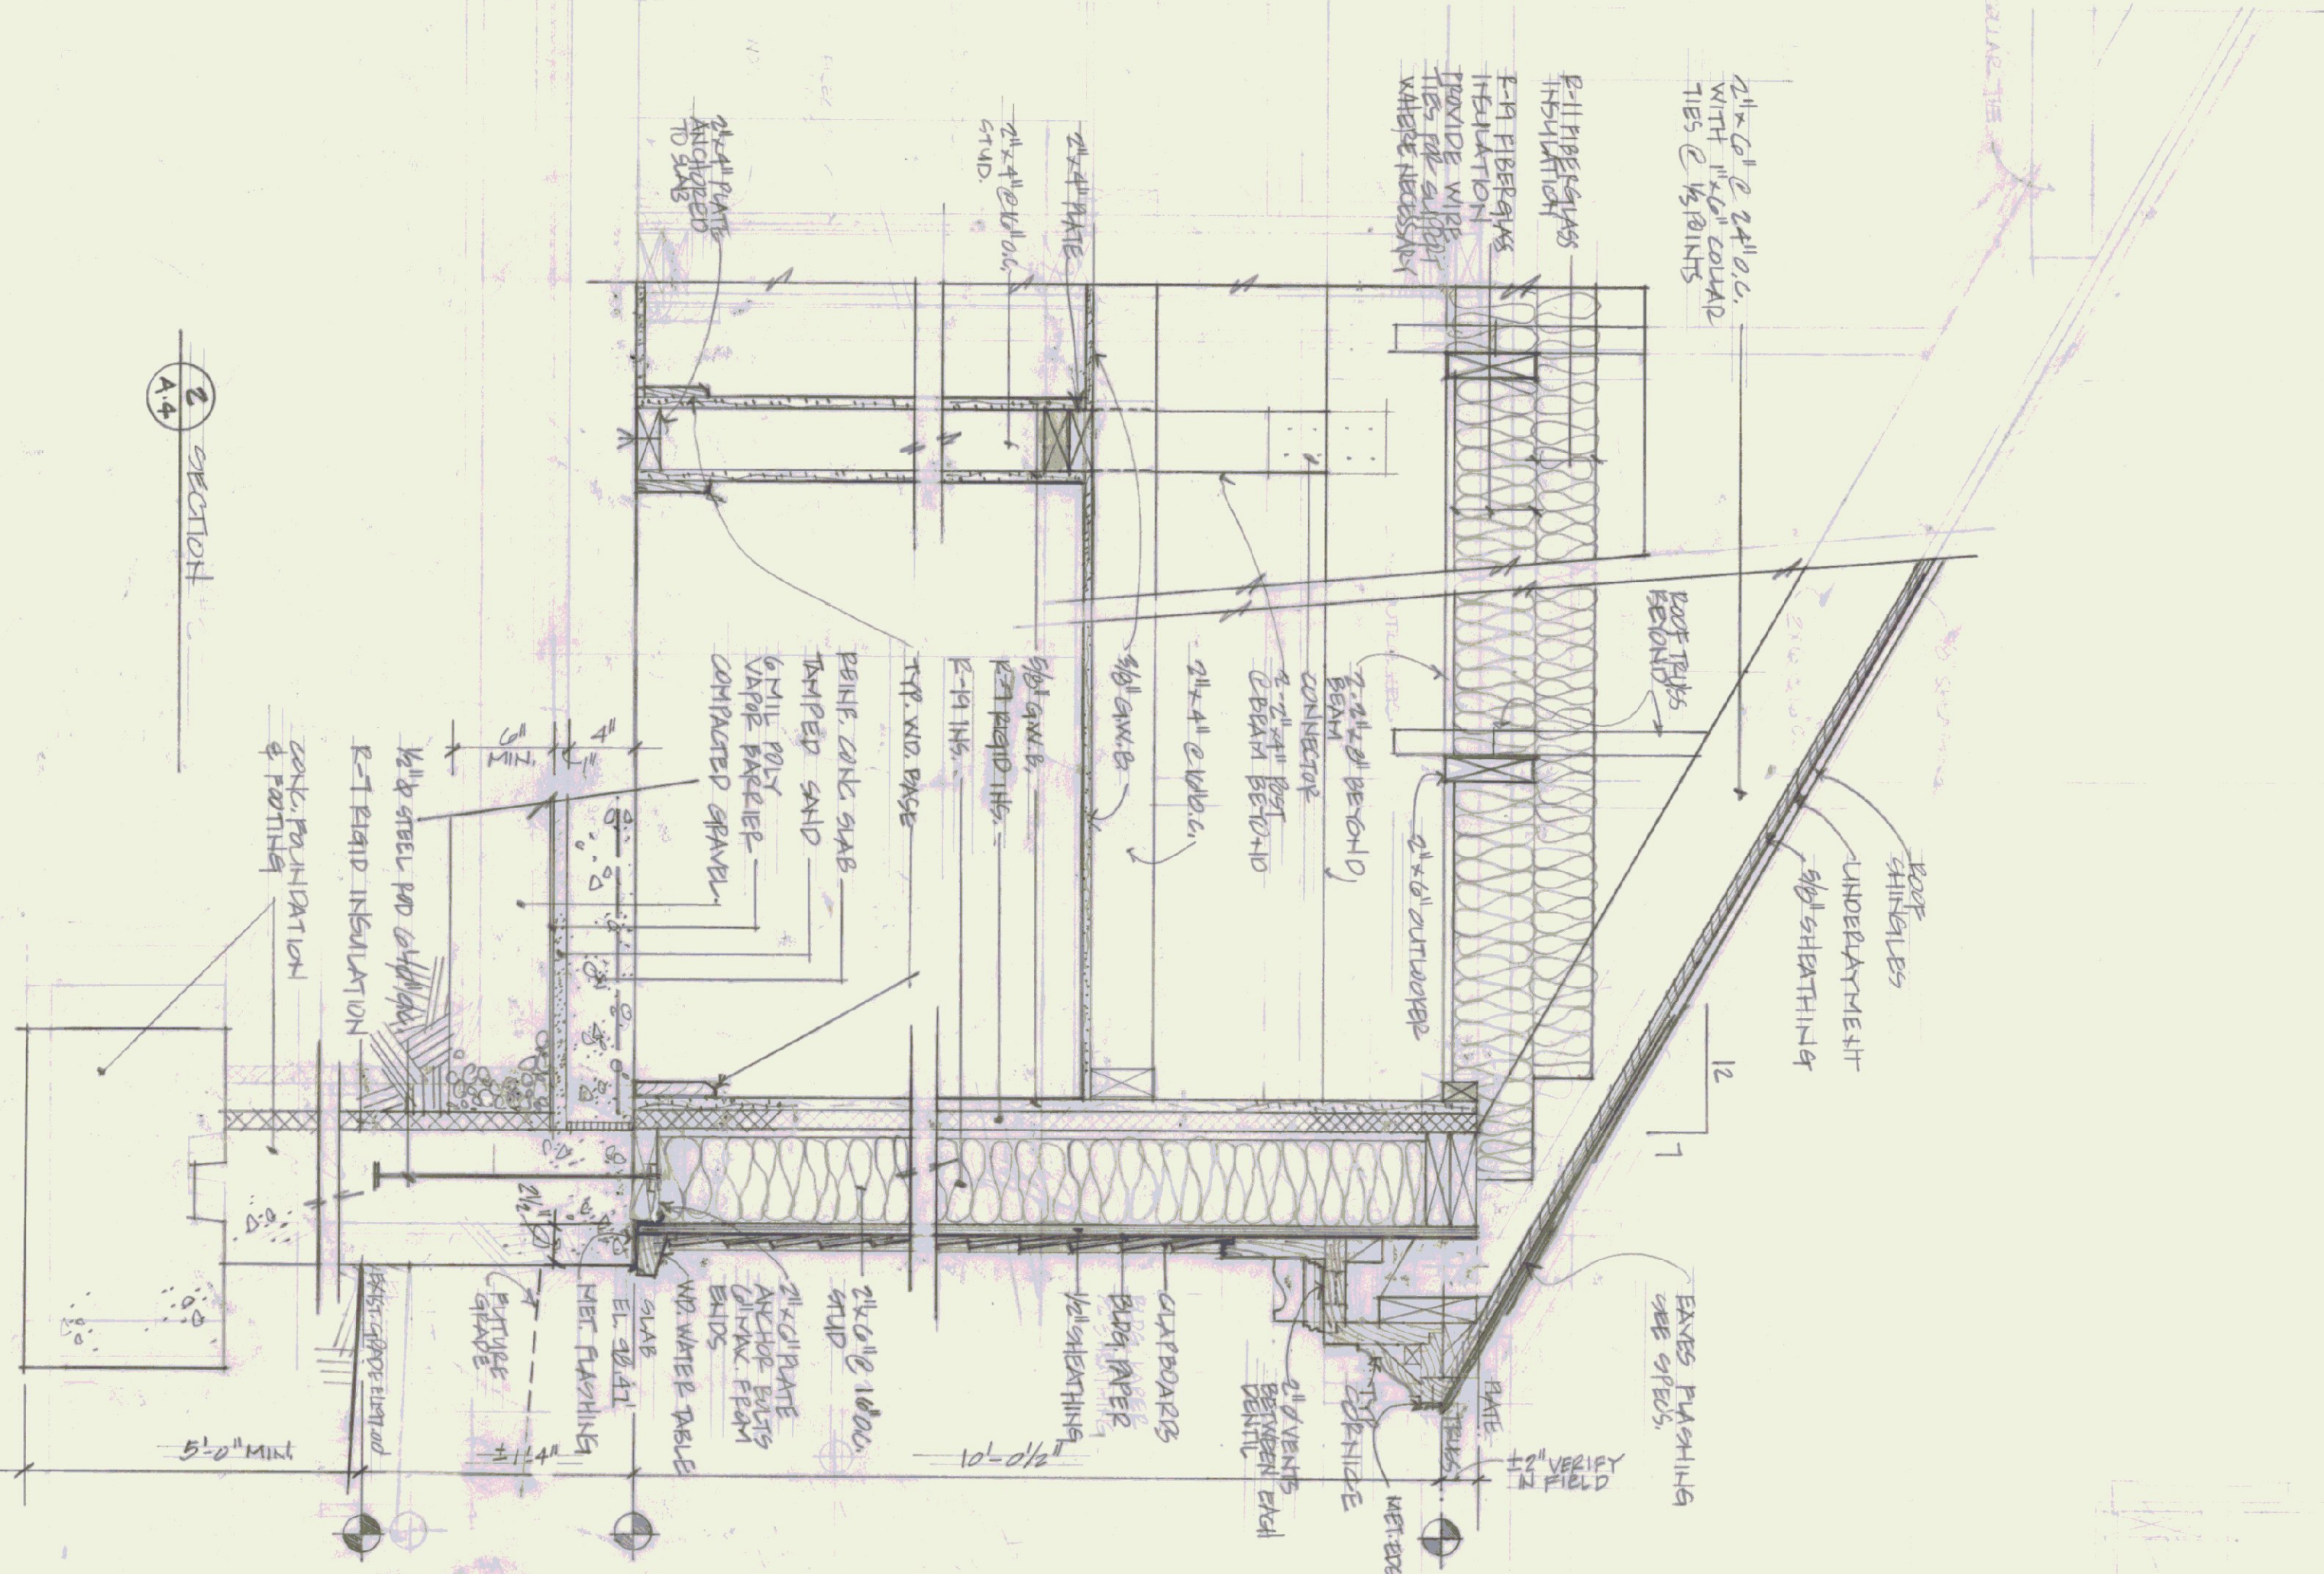


2 SECTION
A-A

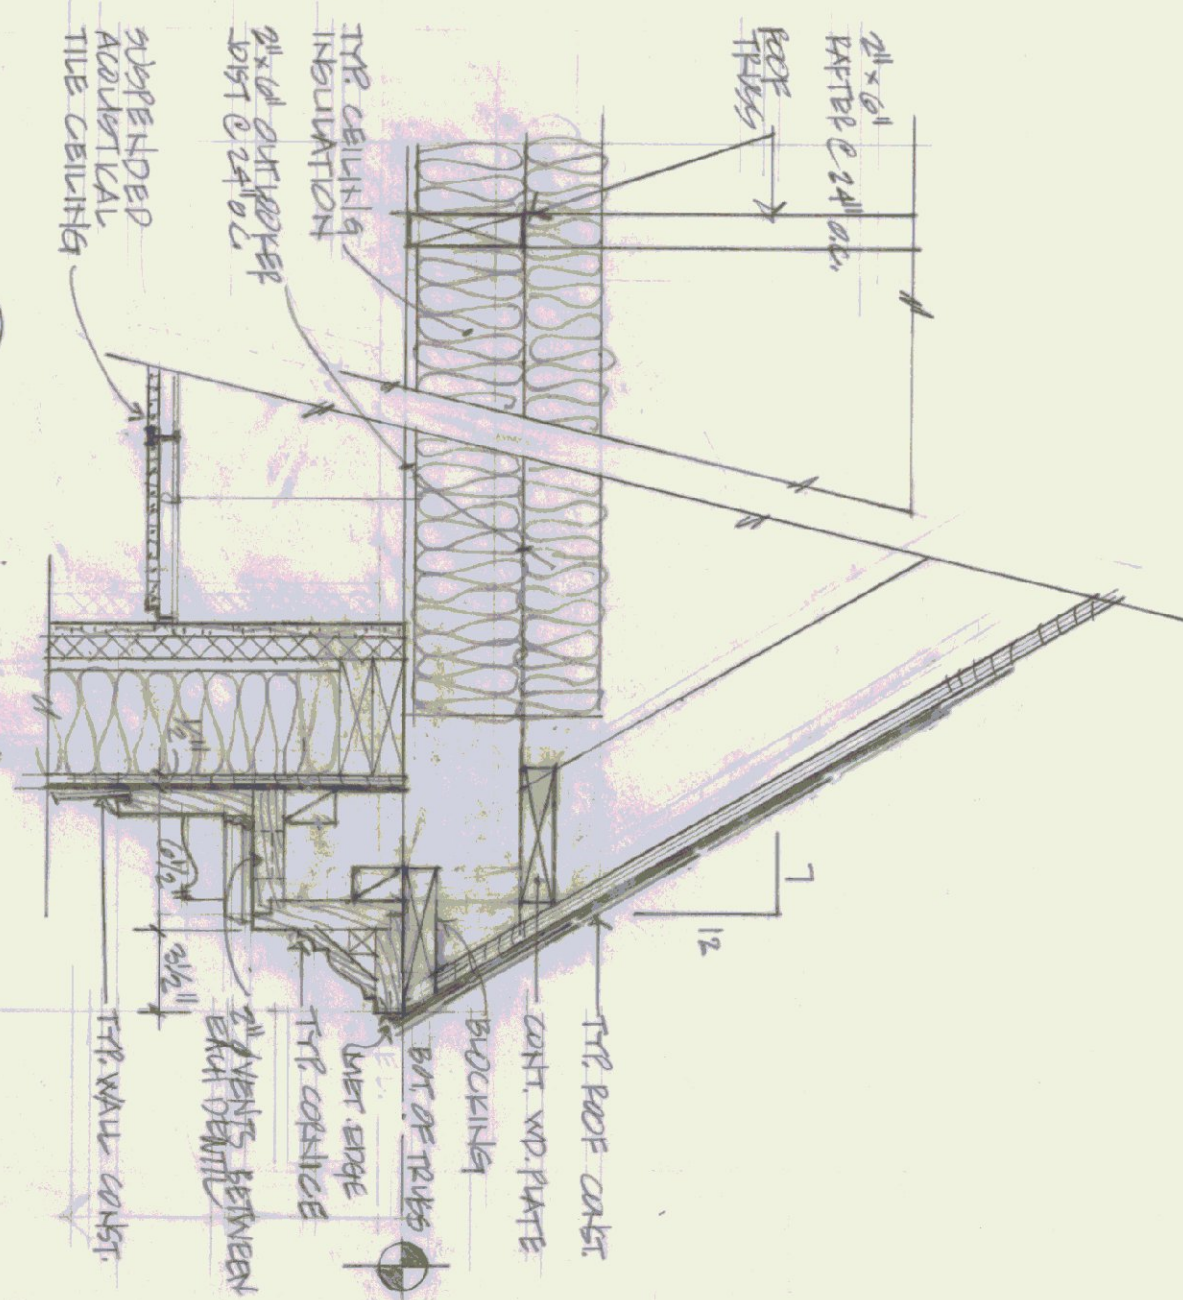

3 SECTION
A-A

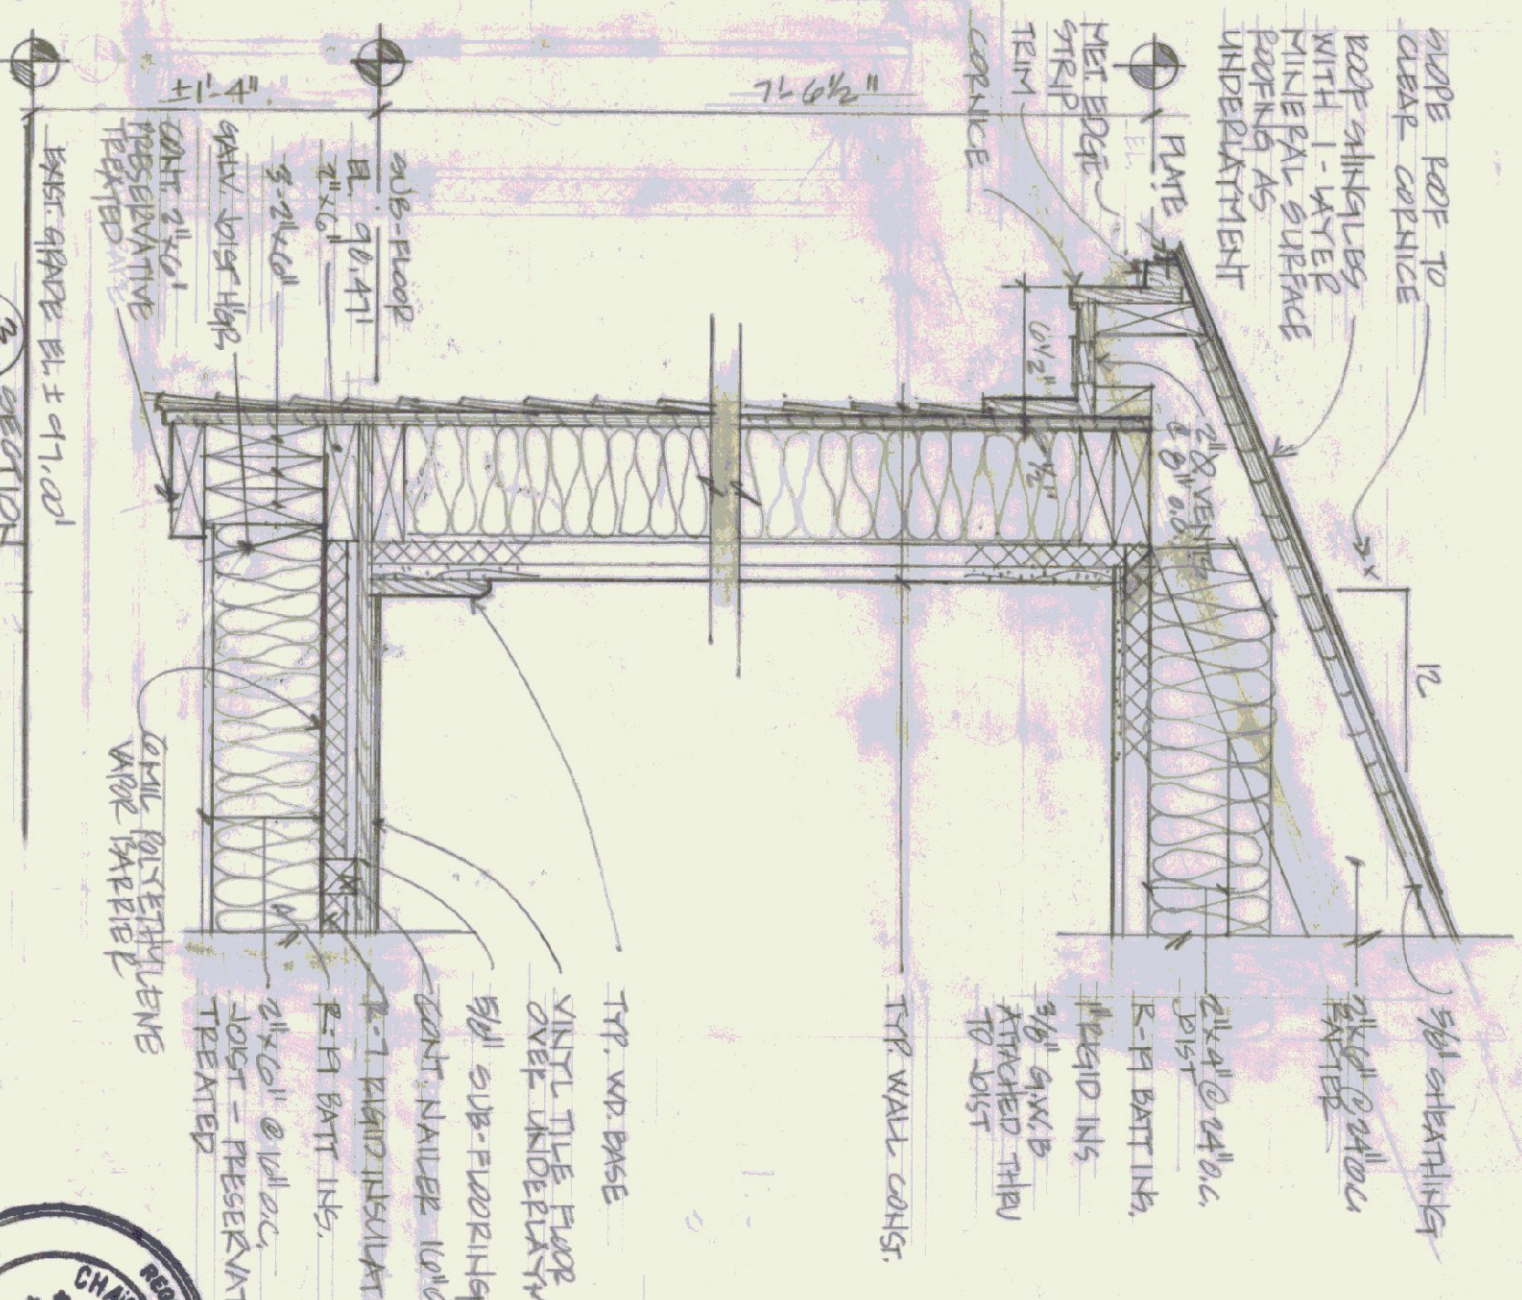

4 SECTION
A-A

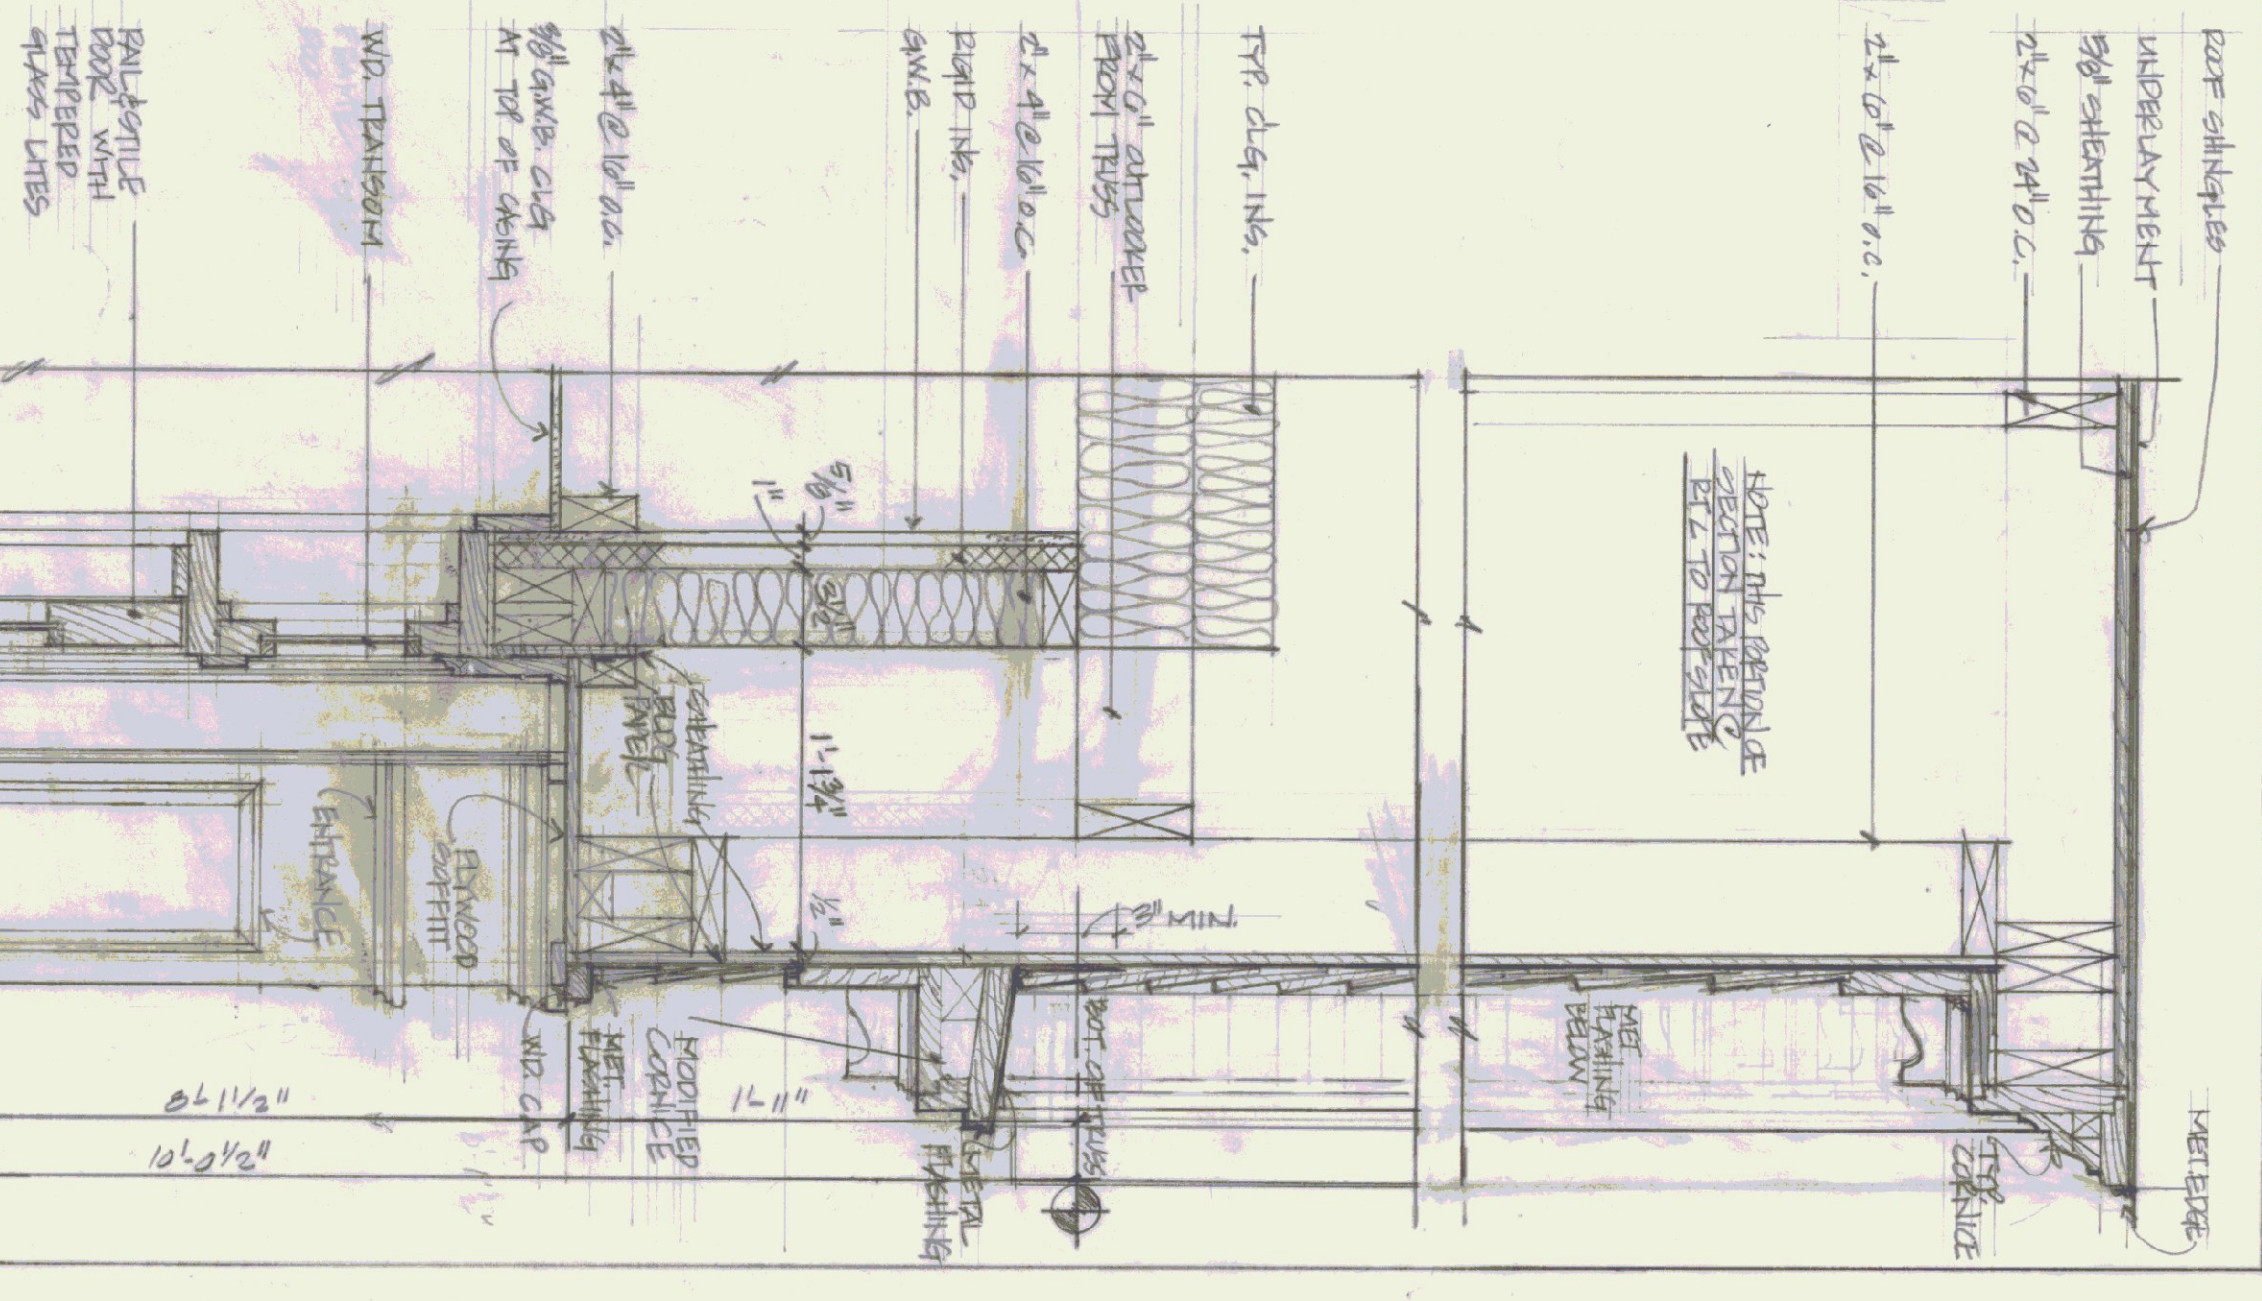






















NOTE: THE SHINGLE
SECTION TAKEN
IS TO BE SHOWN

STATE OF VERMONT
DIVISION OF STATE BUILDINGS
AGENCY OF ADMINISTRATION
MONTPELIER, VERMONT


WALL SECTIONS
SPRINGFIELD STATE AIRPORT TERMINAL
SPRINGFIELD VERMONT

DATE: AUG. 20, 1981	SCALE: 1 1/2" = 1'-0"	REVISIONS:	DWG. NO. A-4
DRAWN BY: HJF & CWS	APPROVED BY:		5 OF 9




      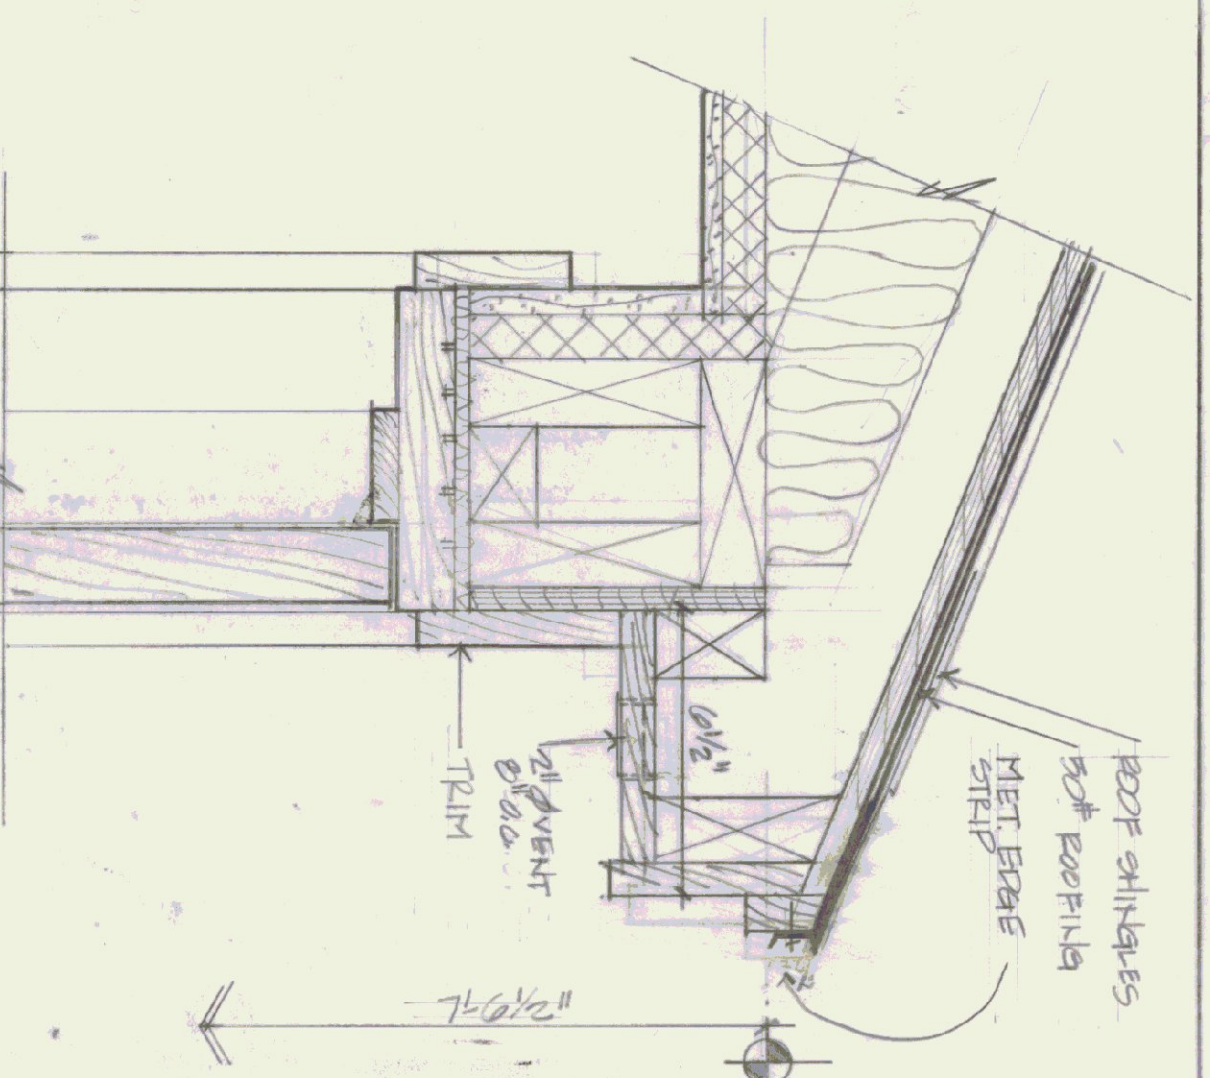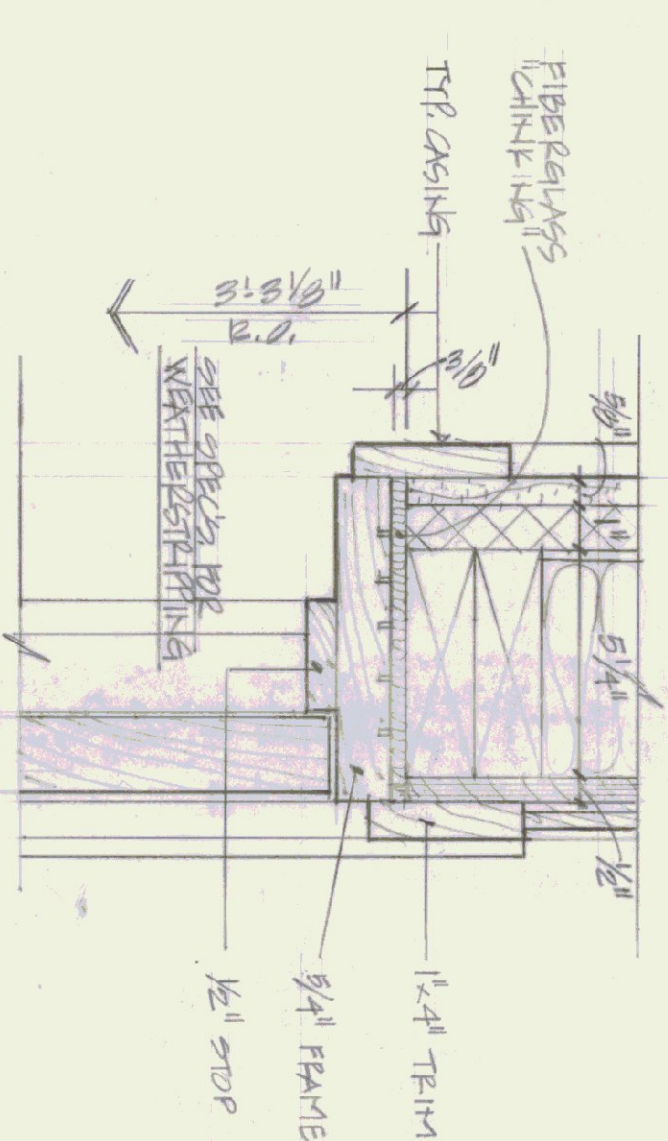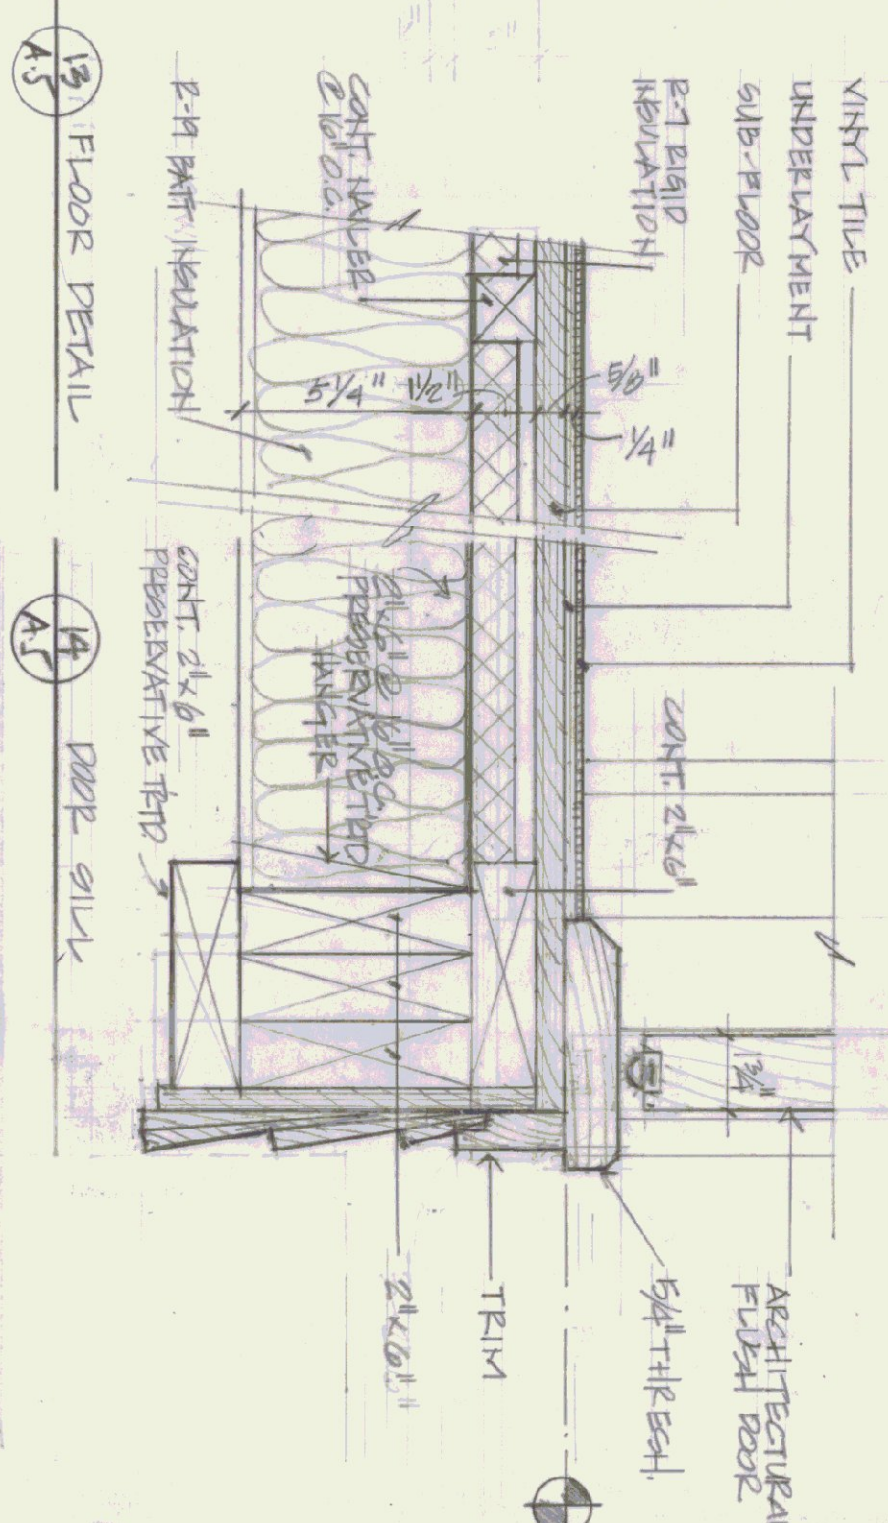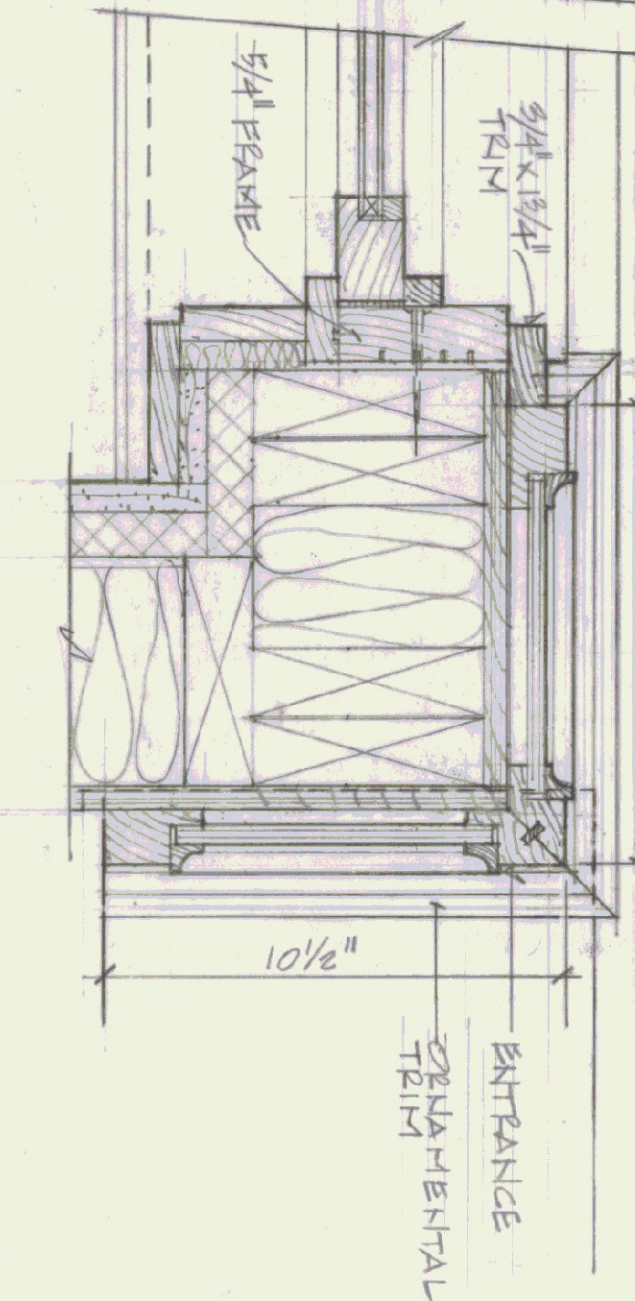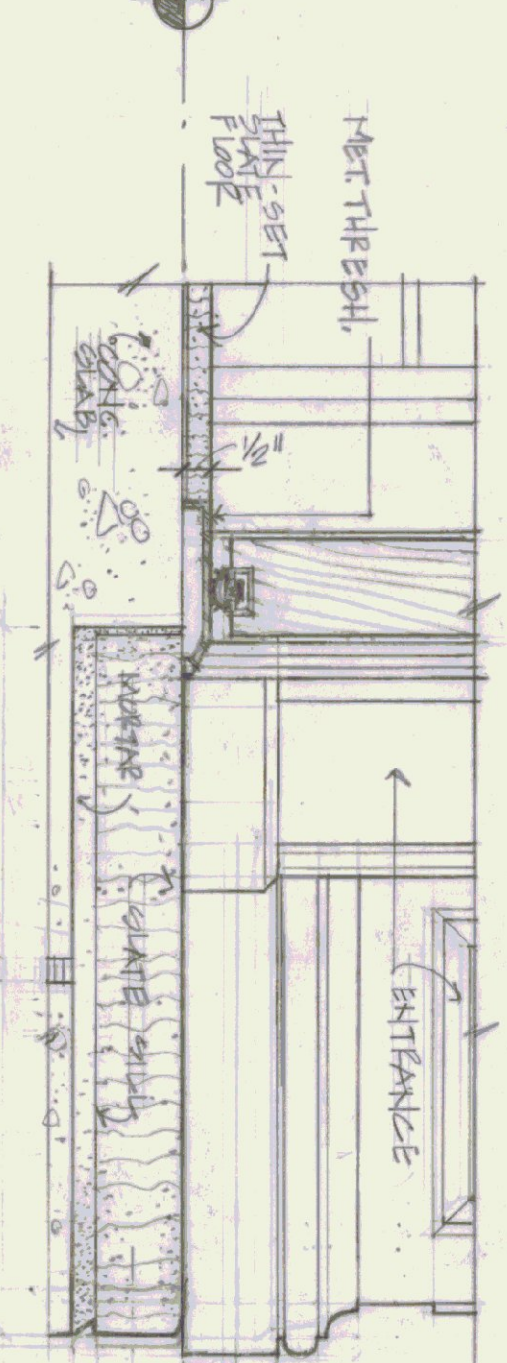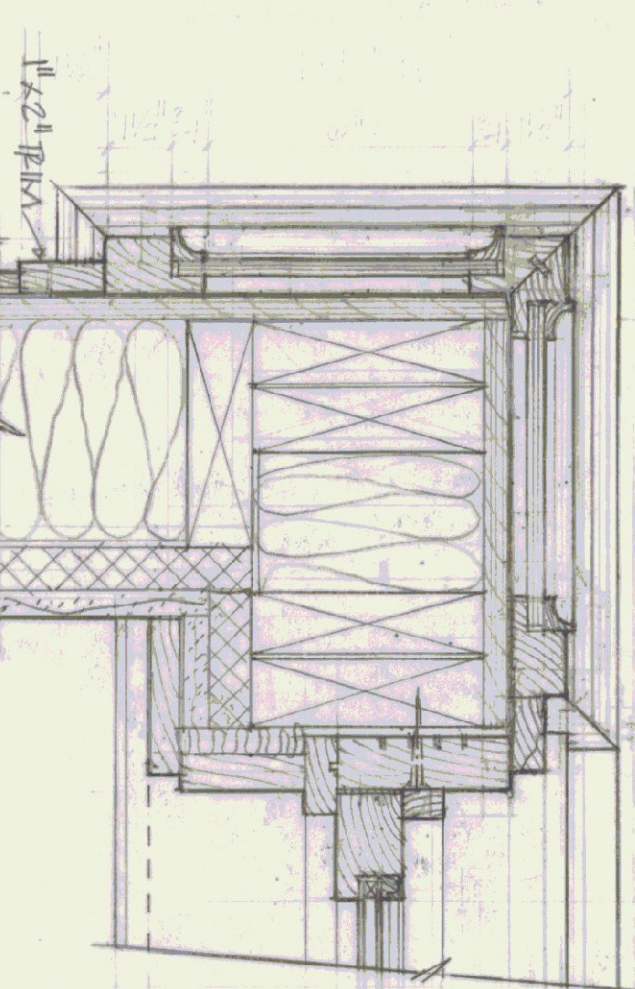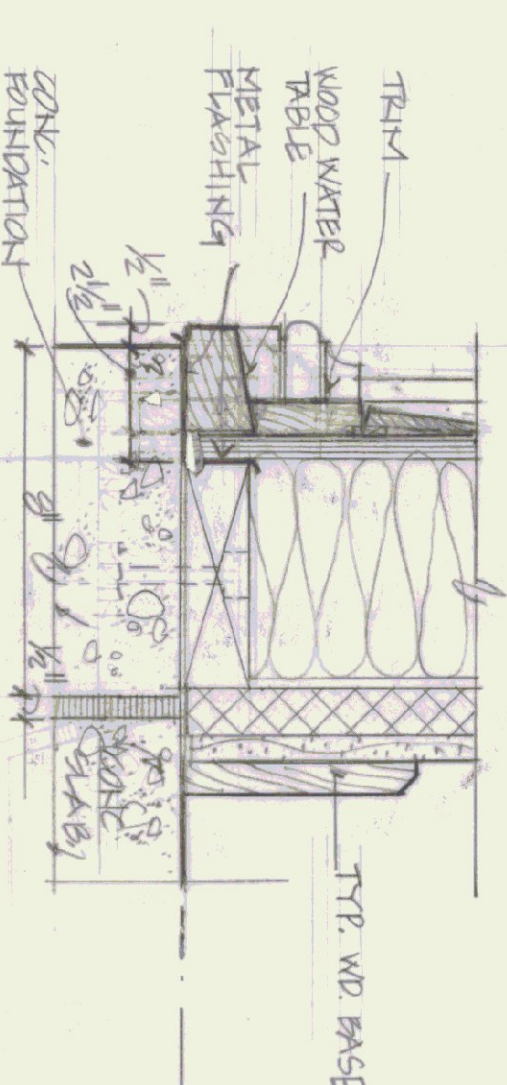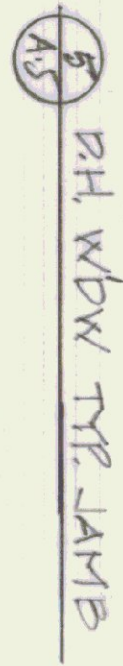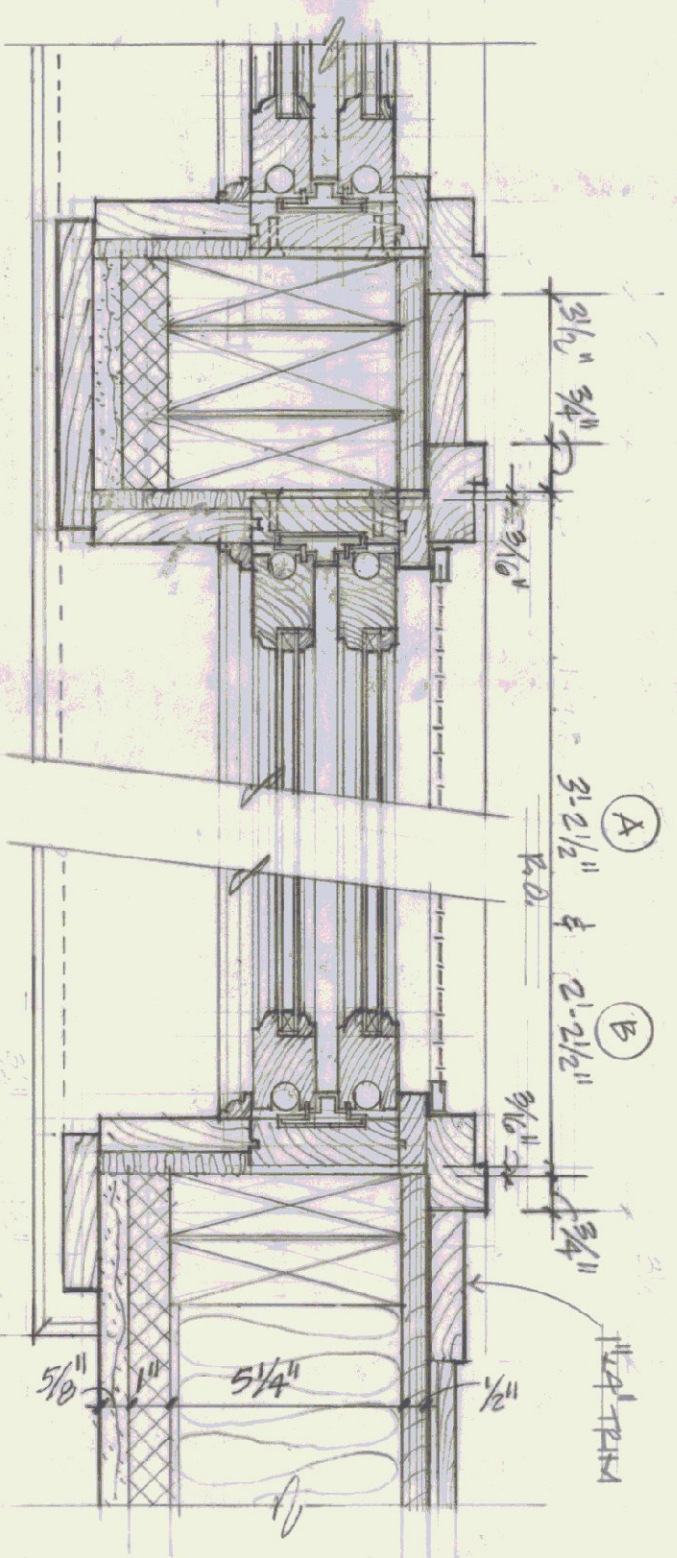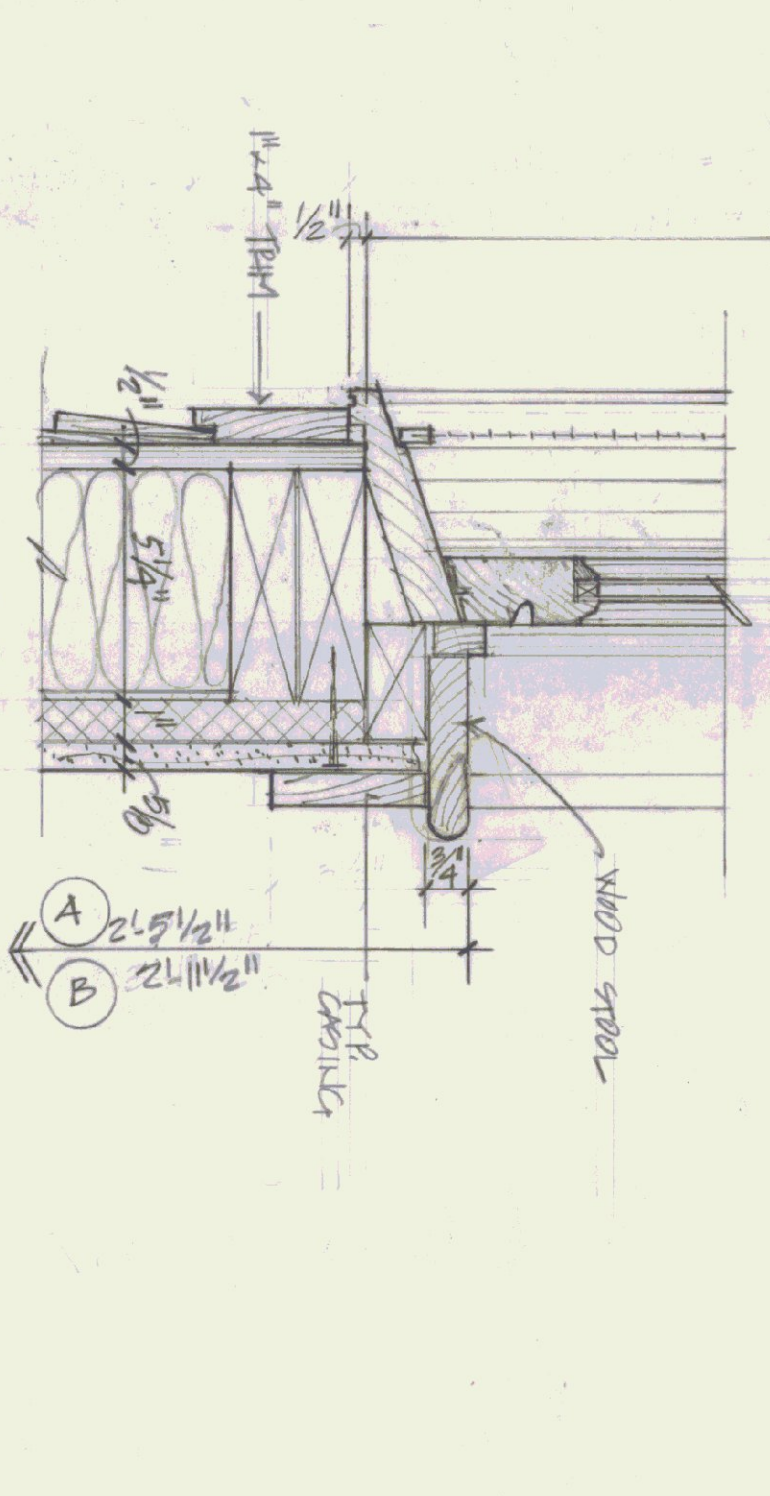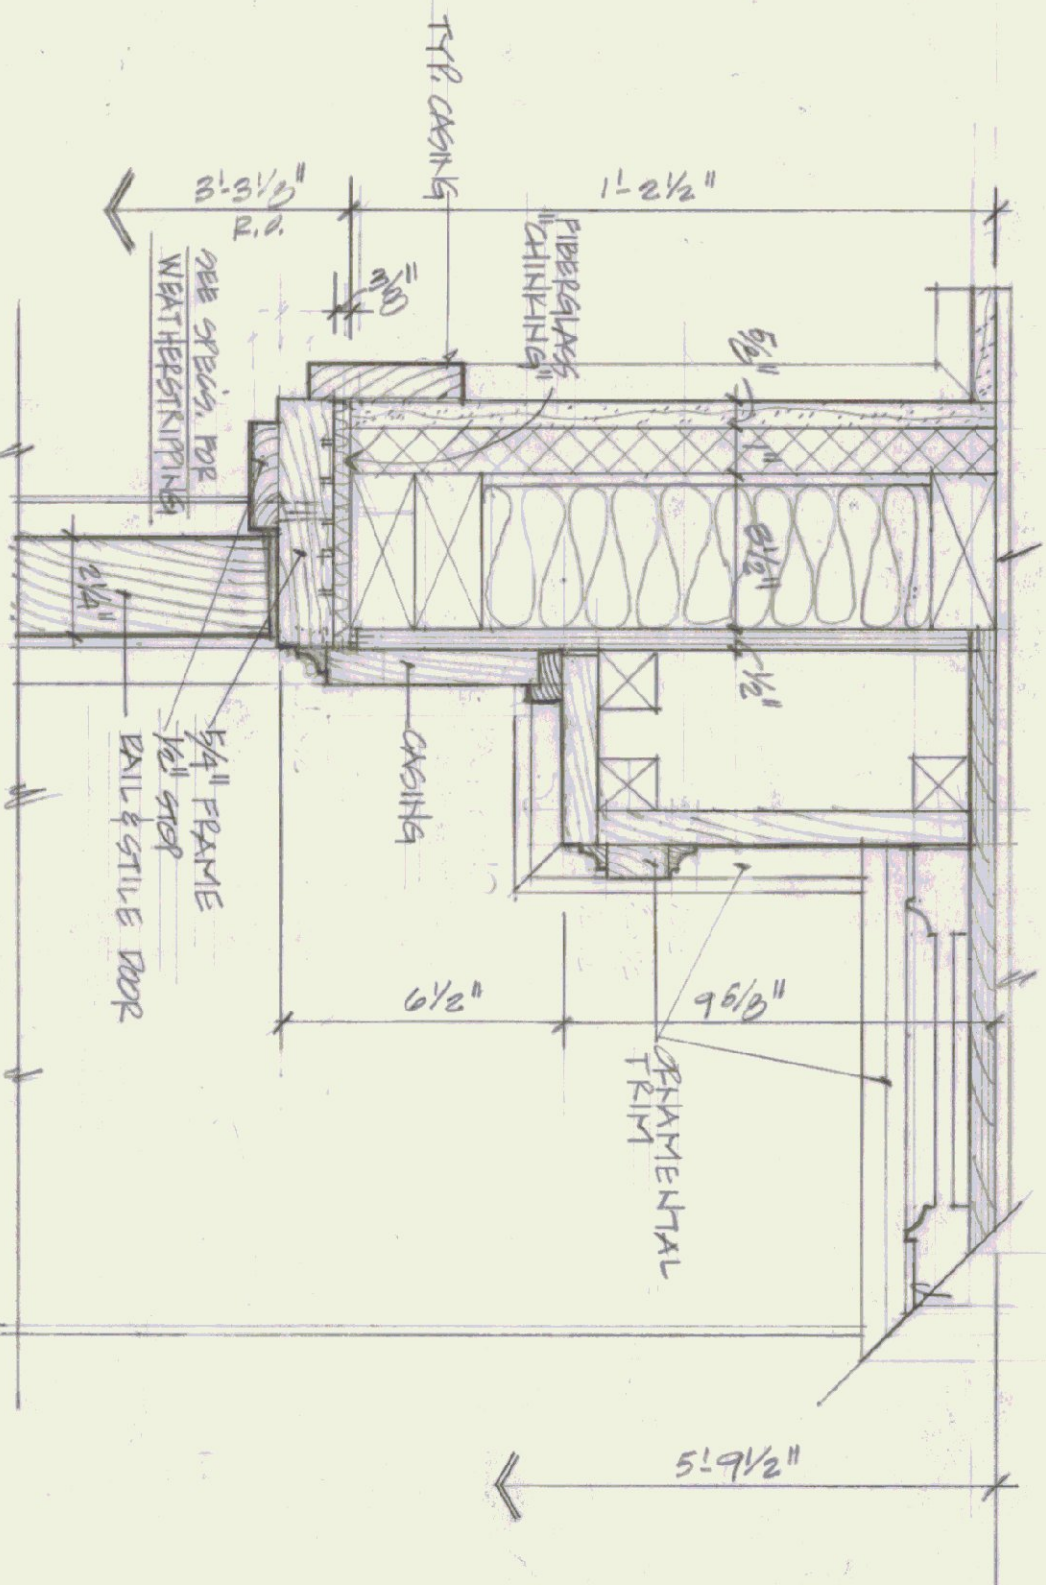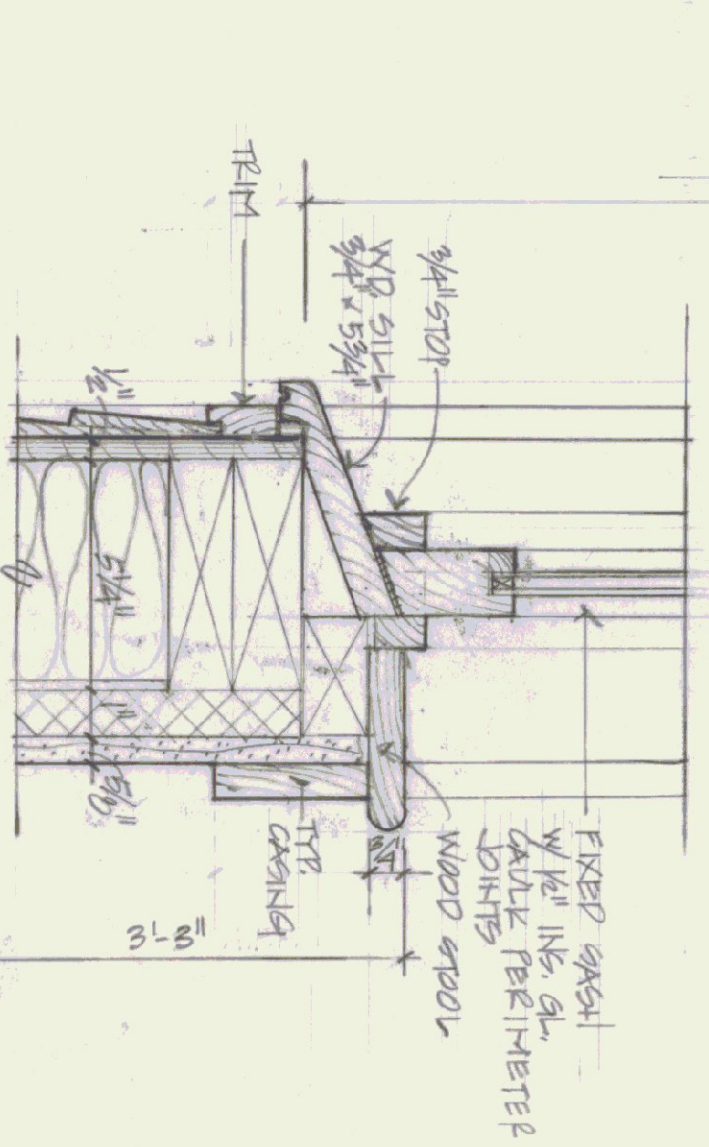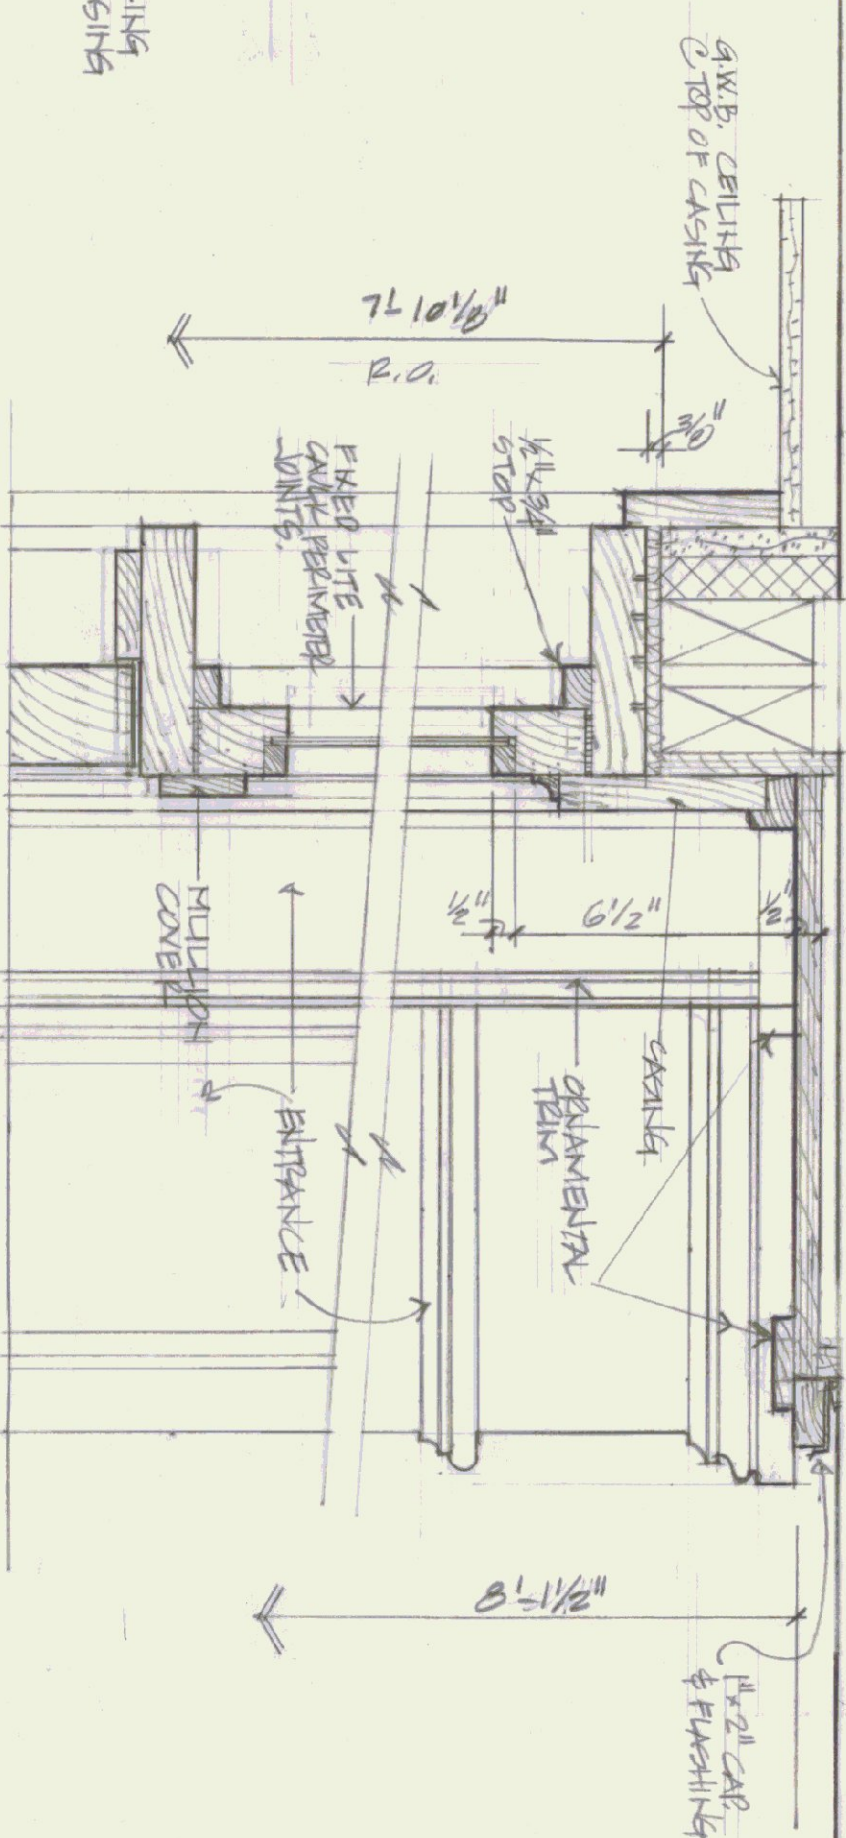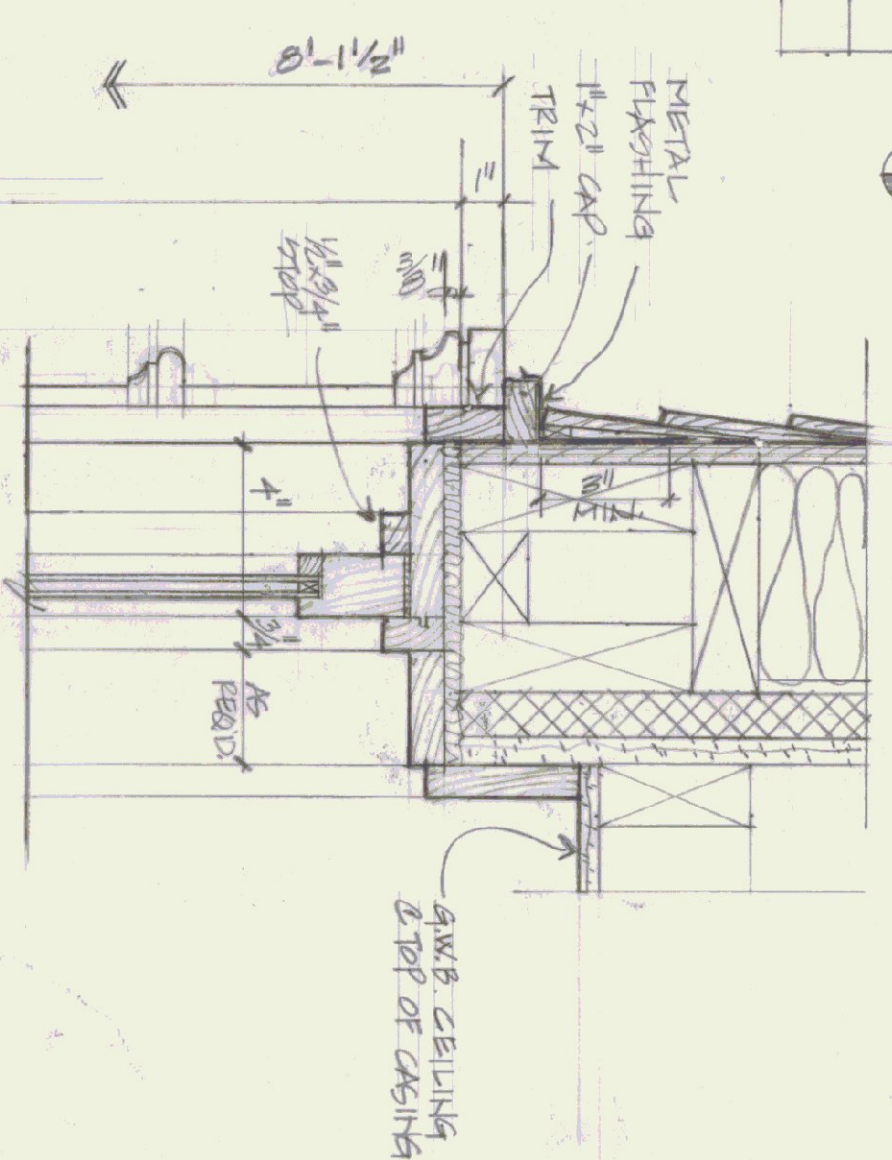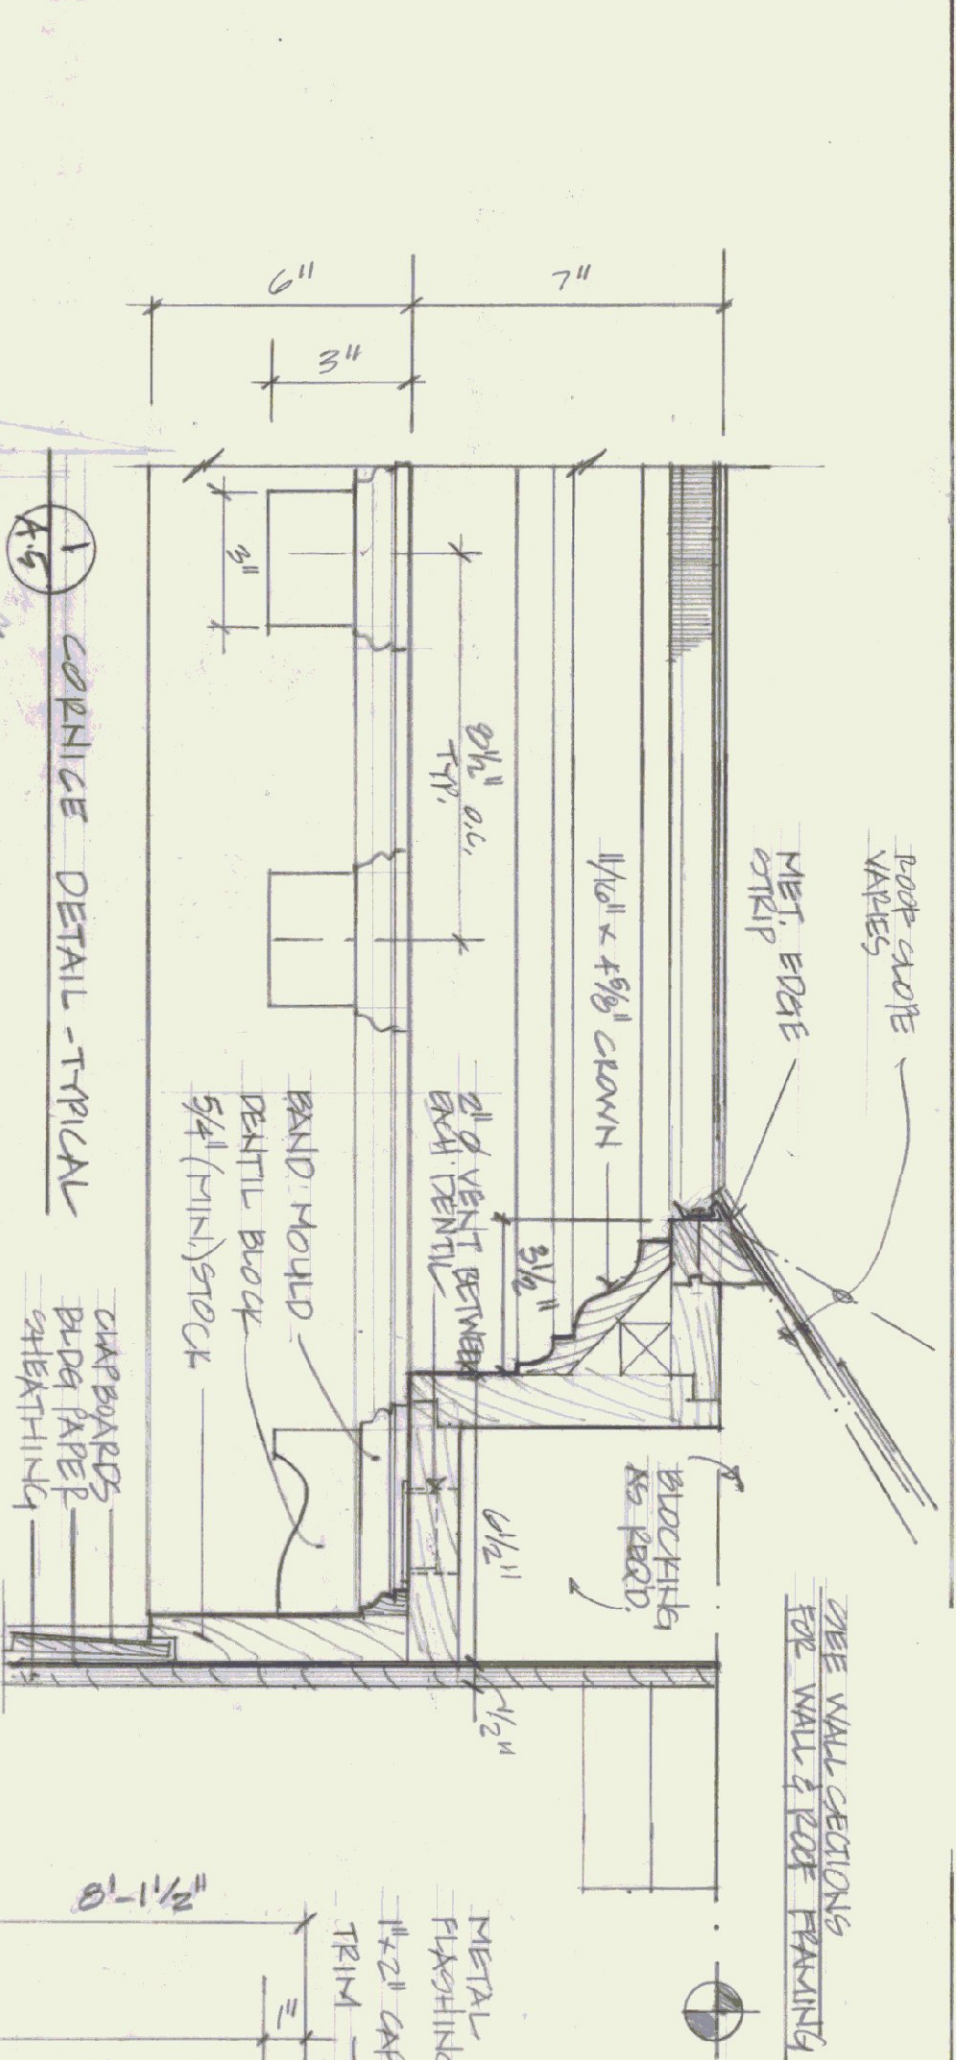

STATE OF VERMONT	
DIVISION OF STATE BUILDINGS	
AGENCY OF ADMINISTRATION	
MONTEPELIER.	
VERMONT	
<u>EXTERIOR DETAILS</u>	
SPRINGFIELD STATE AIRPORT TERMINAL	
SPRINGFIELD	
VERMONT	
DATE:	SCALE:
AUG 28, 1961	3/4" = 1'-0"
DRAWN BY:	APPROVED BY:
C.W.H.S.	C.W.H.S.
REVISIONS:	DWG. NO.
	A-5
	6 OF 9

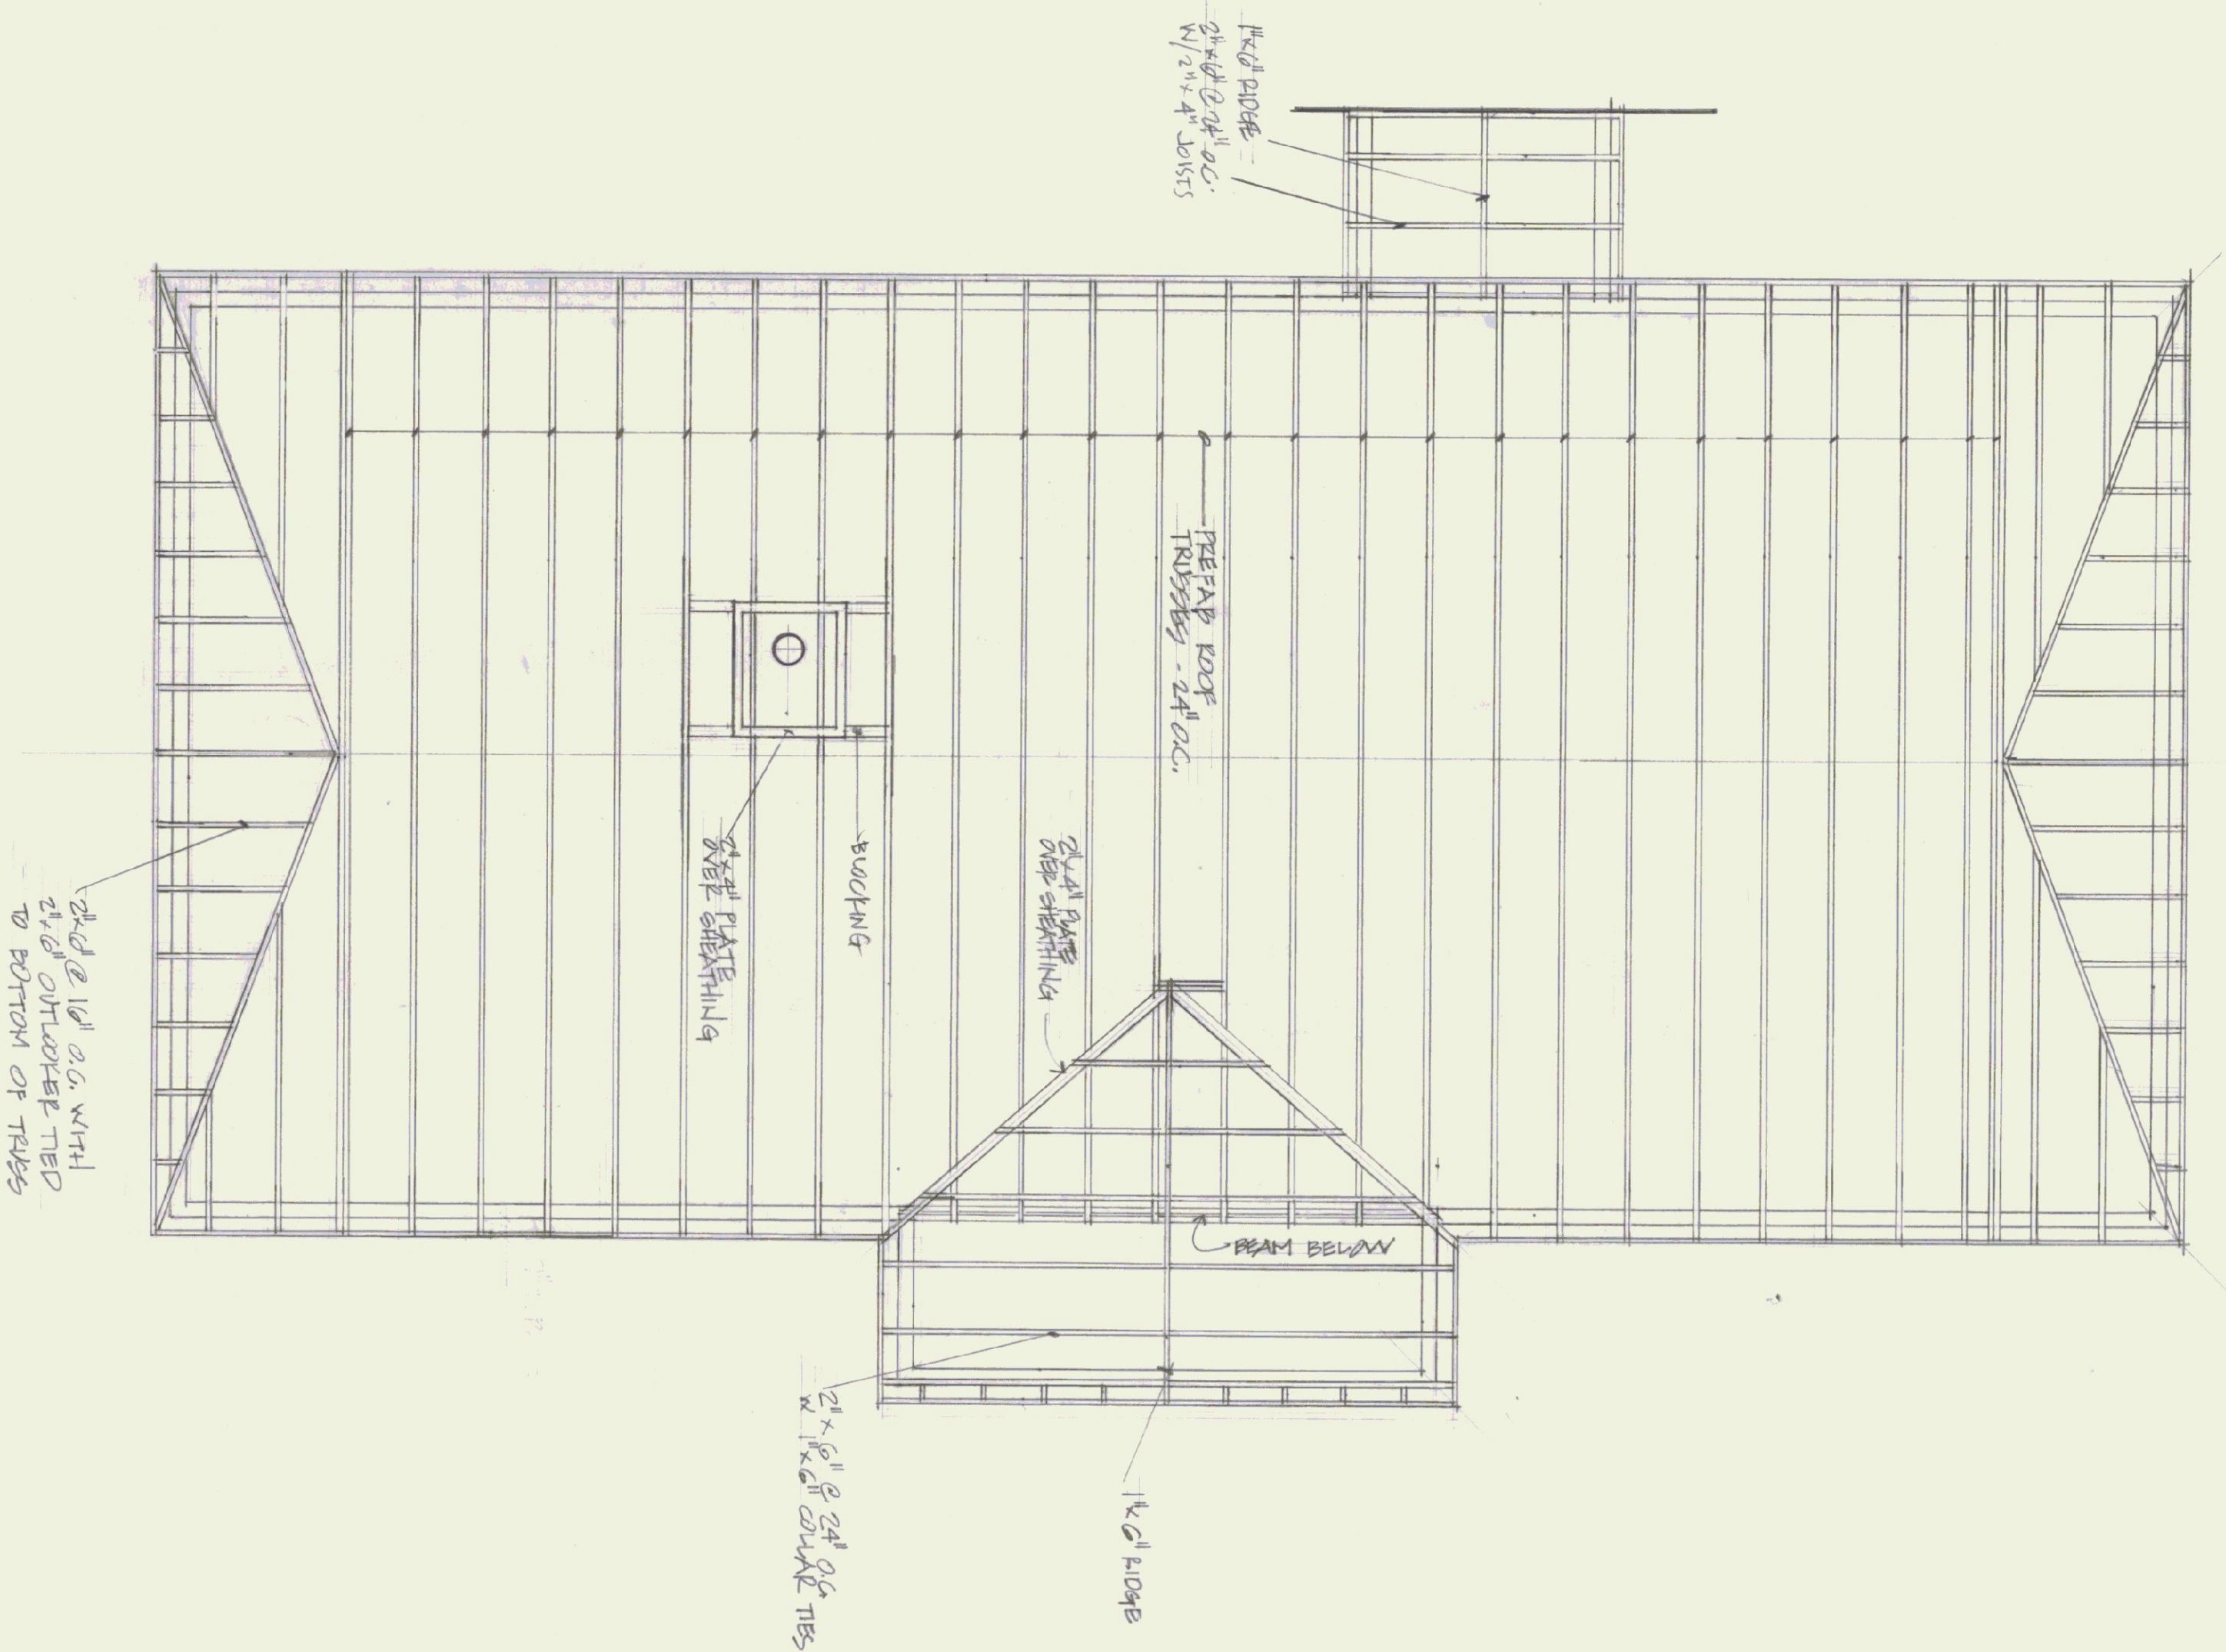

ROOF FRAMING

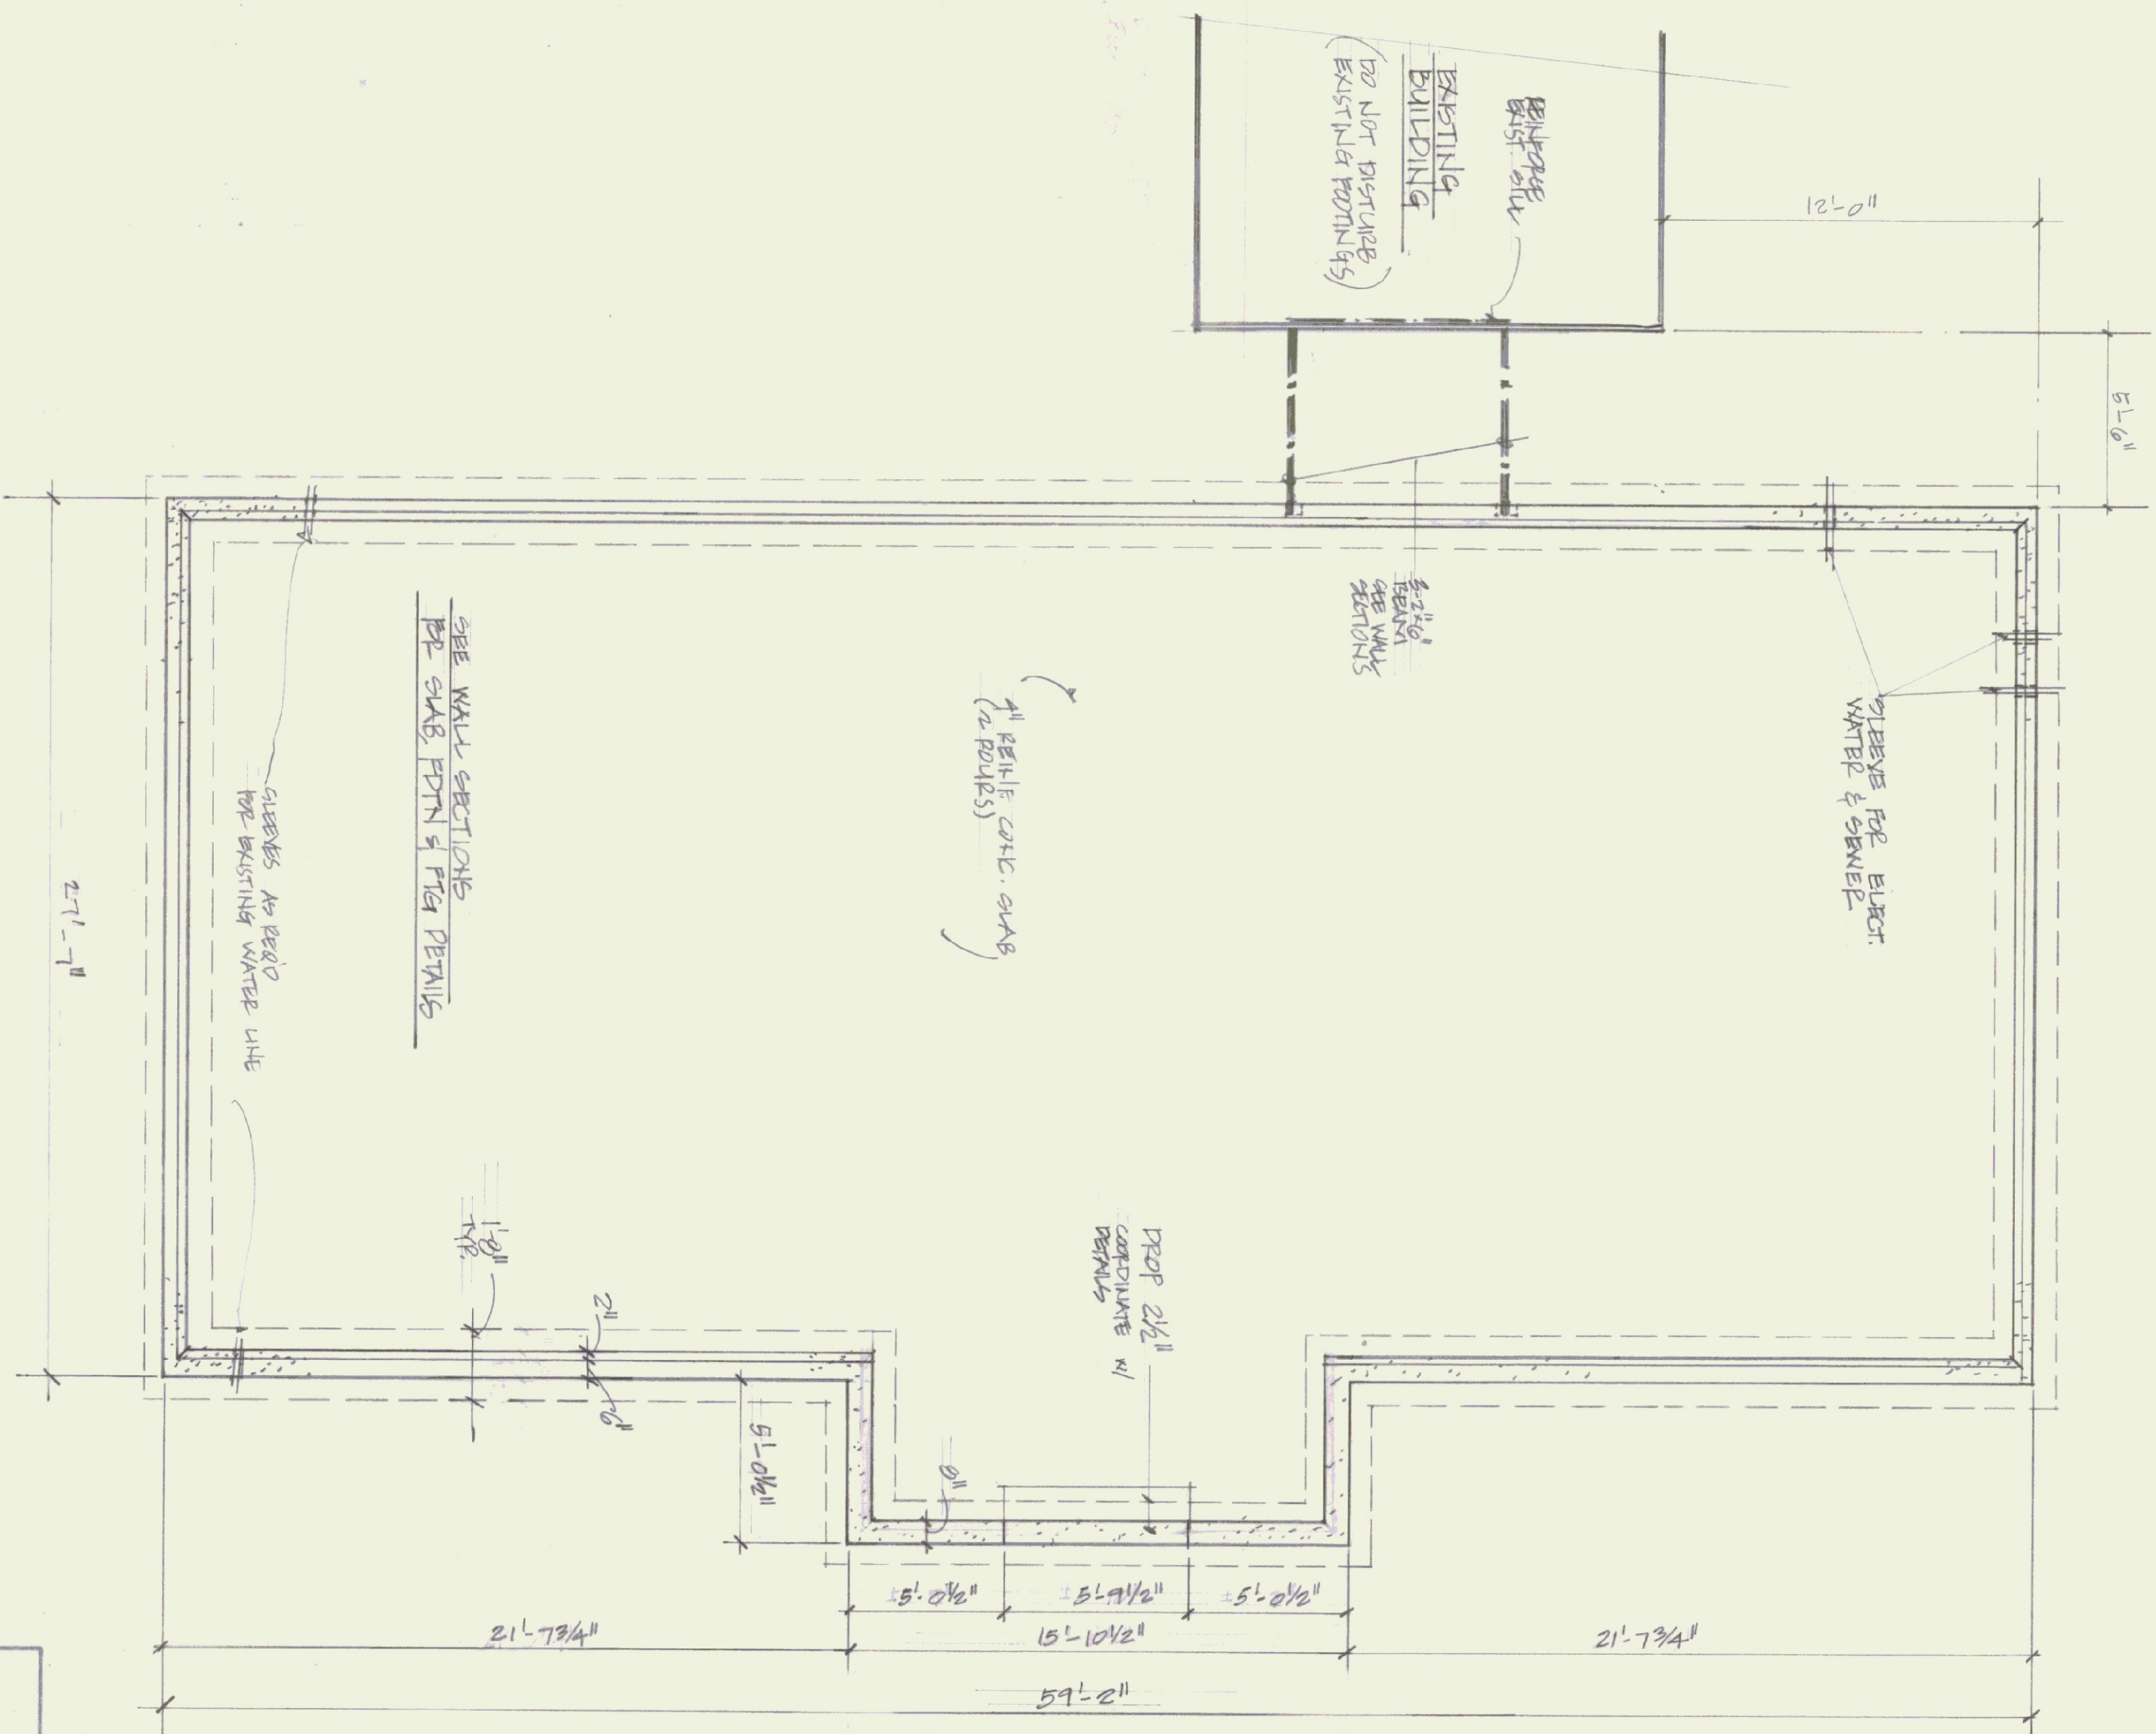


FOUNDATION PLAN





STATE OF VERMONT			
DIVISION OF STATE BUILDINGS			
AGENCY OF ADMINISTRATION			
MONTPELIER, VERMONT			
ROOF FRAMING PLAN: FOUNDATION PLAN			
SPRINGFIELD STATE AIRPORT TERMINAL			
SPRINGFIELD VERMONT			
DATE: AUG 28, 1961	SCALE: 1/4" = 1'-0"	REVISIONS:	DWG. NO. A-10
DRAWN BY: C.W.S.	APPROVED BY:		1 OF 2



PLUMBING FIXTURE SCHEDULE		
NUMBER	SYMBOL	MANUFACTURER, MODEL NUMBER
P-1, P-2		AMERICAN STANDARD COMPOUNDED WHITE-ENAMELED VITREOUS GLASS NO. 2109, 0516 (P-1), CERIT NO. 2109, 595 (P-2-THAND-ENAMELED) BATH W/ 5500 ACRYLIC SAT. FINISH (OBS. FINISH) AND COVER - NO. 3402, 018 CUREE PINT, CHINA/CAN - FINISH
P-3, P-4		SHALL BE WHITE AMERICAN STANDARD "MATION" 20 X18" FOR COMPOUNDED GLASS NO. 0561, 055, FABRICS NO. 2594, 018 ACRYLIC FINISH, C.F. P-3 AND NO. 2595, 154 (MOTION 2" 7" TO BOTTOM OF SINK (THAND-ENAMELED))
P-5		SERVISE SINK - AMERICAN STANDARD "AMERICAN" NO. 7632, 049 W/ P-1 AND 2 SERVISE SINK FINISHES, FINISHES W/ VITREOUS ENAMEL, AND P-1 AND 2
P-6		DELUXE FOUNTAIN AMERICAN STANDARD VITREOUS GLASS # 8310, 1200 W/ LEVER TYPE HANDLE
P-7		WATER HEATER - D. G. A. (FOR ELECTRICAL CONTRACTORS)
P-8		FLOOR FLOOR HOT WATER BATH W/ VITREOUS ENAMEL

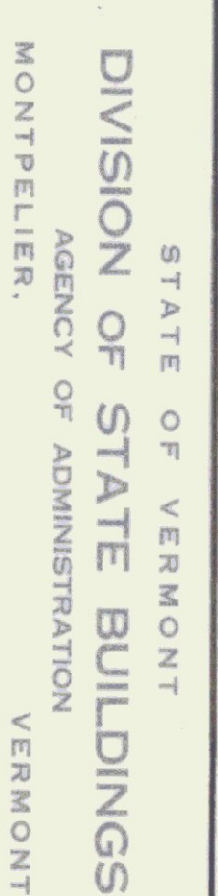



EMERGENCY LIGHTING SYSTEM SHALL BE POWERED WITH A DUAL LITE SERIES E-D 12 VOLT LEAD BATTERY UNIT. EXIT SIGNS SHALL BE DUAL-LITE DOUBLE FLARED STANDARD SIGNS WITH ENCL (JEWELL) MOUNTING, 120W KTY (CARBON), AND DOWNLIGHT. LIGHTS SHALL BE DUAL-LITE EXIT-55 WITH CHROME FINISH AND SINGLE HEAD CHROME MOUNTING PLATES. LIGHTING SYSTEM SHALL BE CAPABLE OF MAIN TAILING KINHOOR STAIRWELLS SET BY N.T.P.D.'S LIFE SAFETY CODE, AND NATIONAL ELECTRICAL CODE.

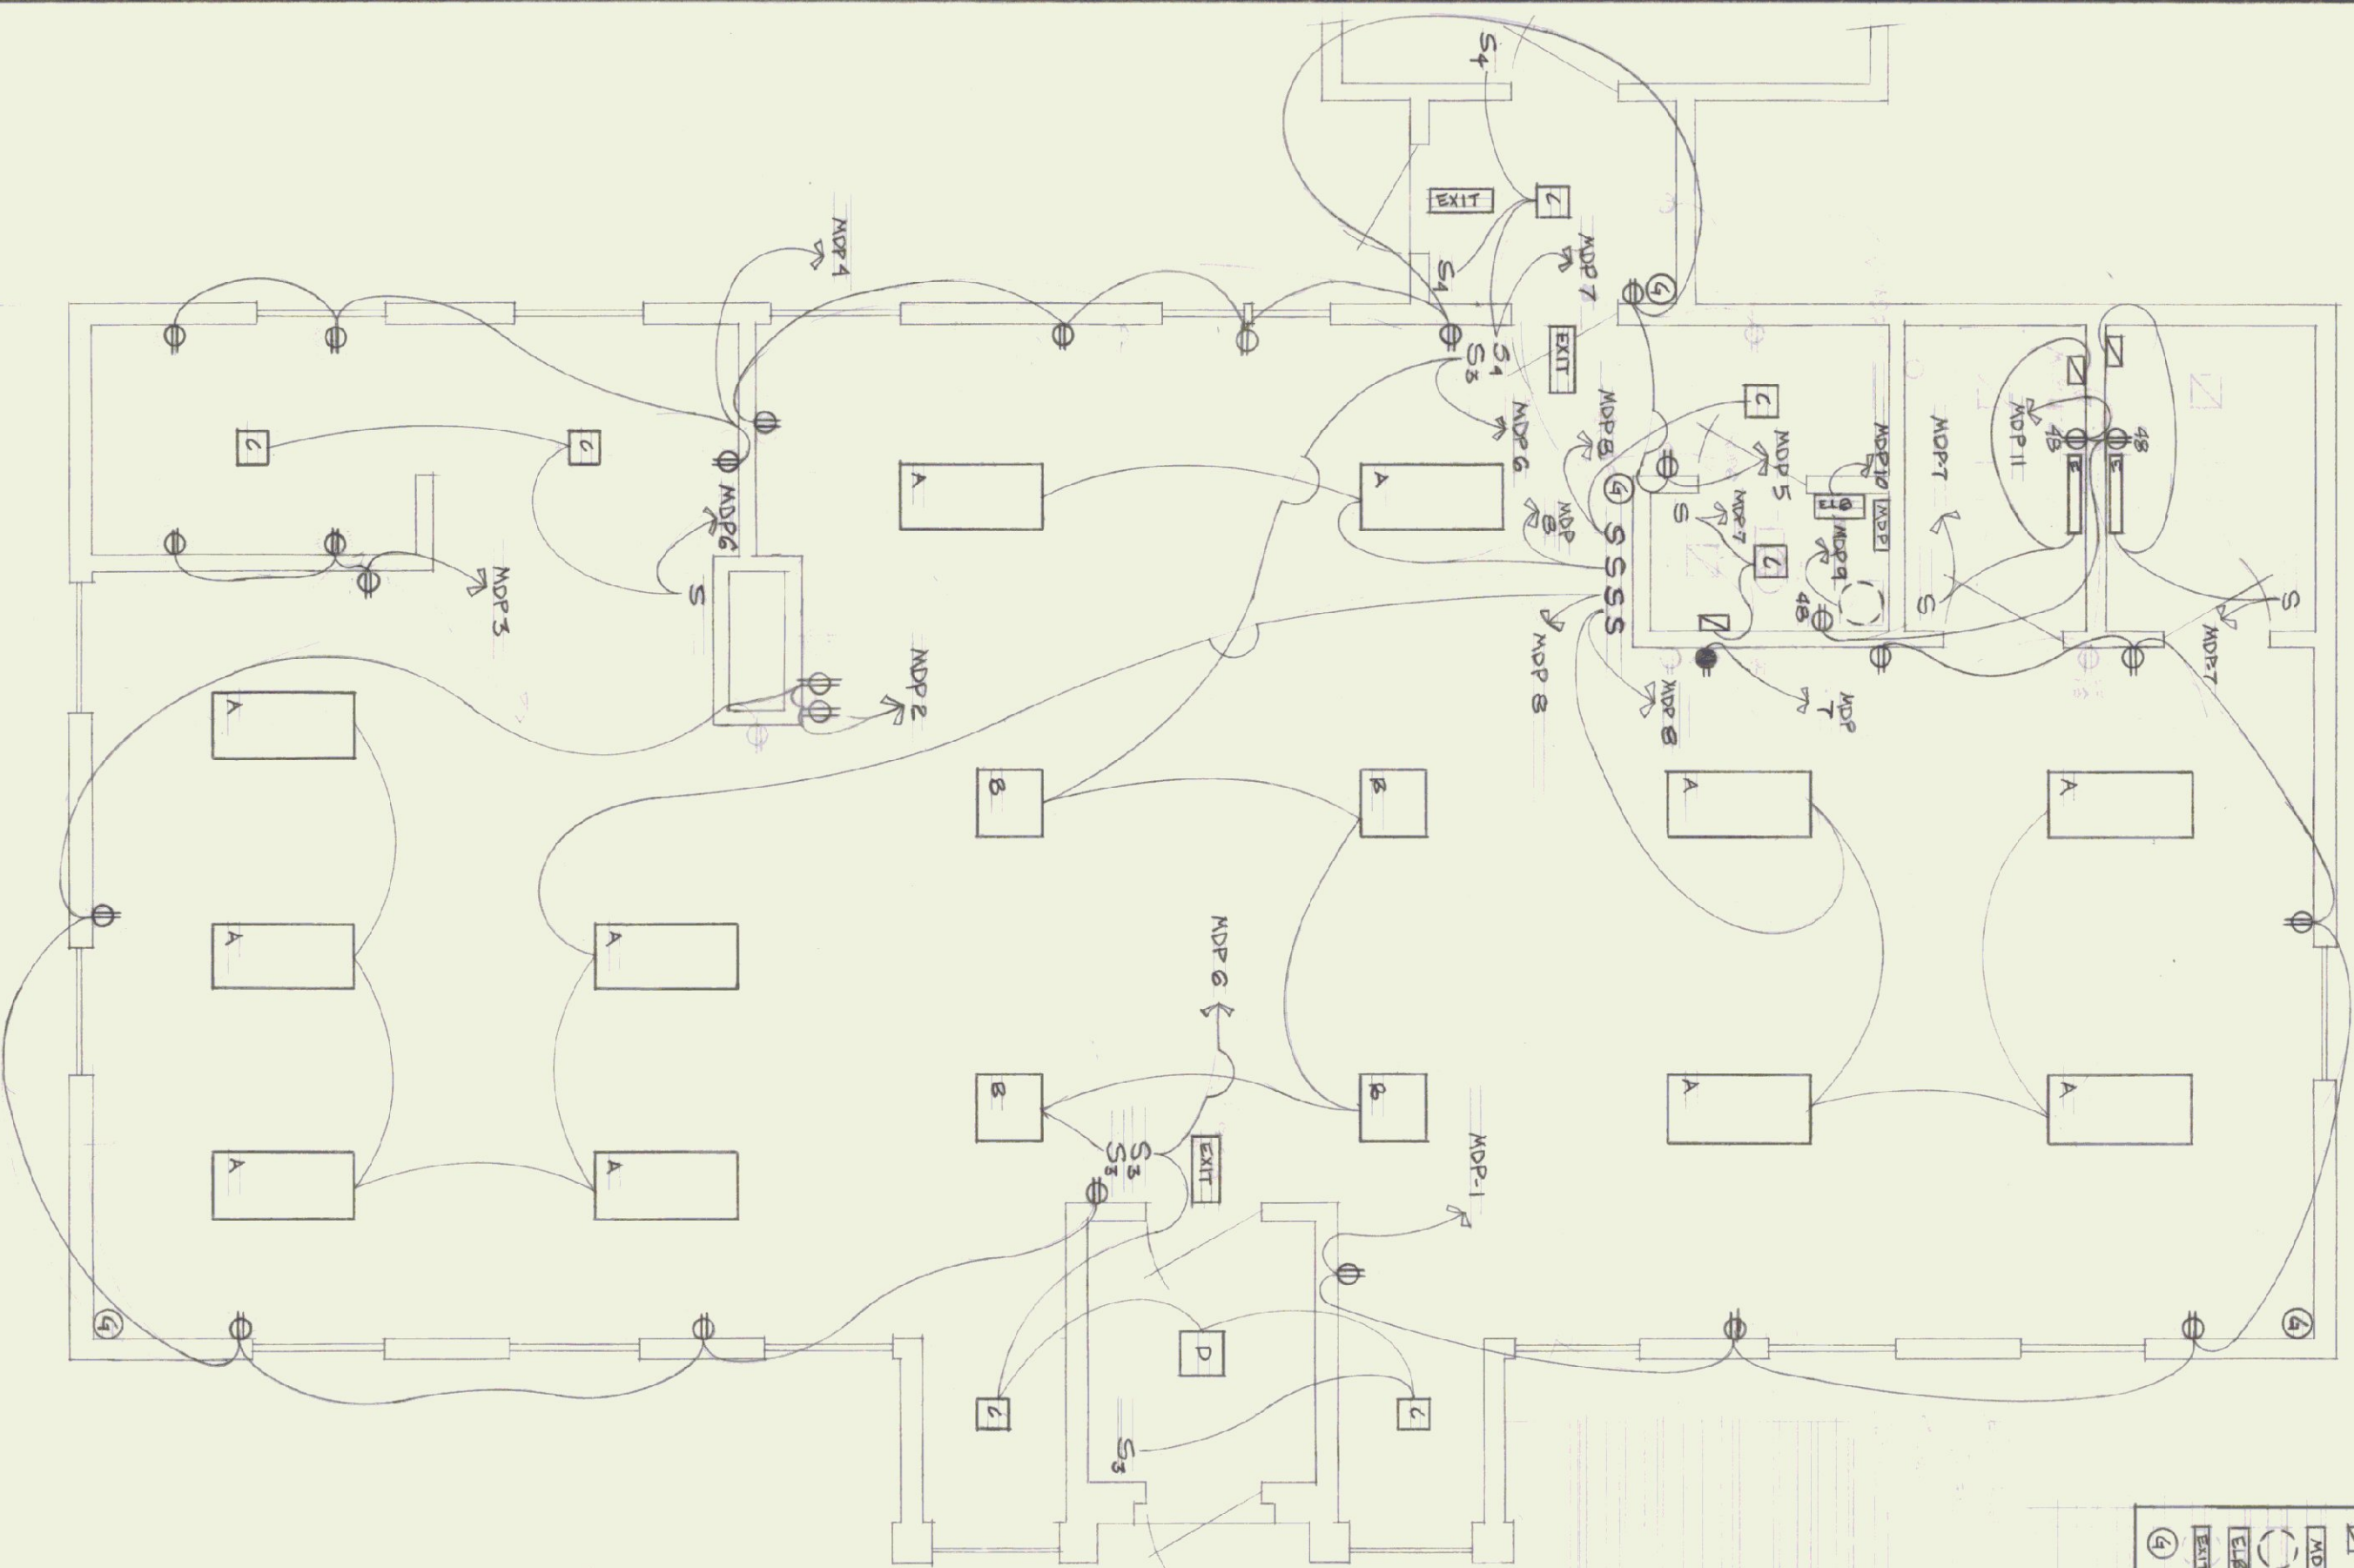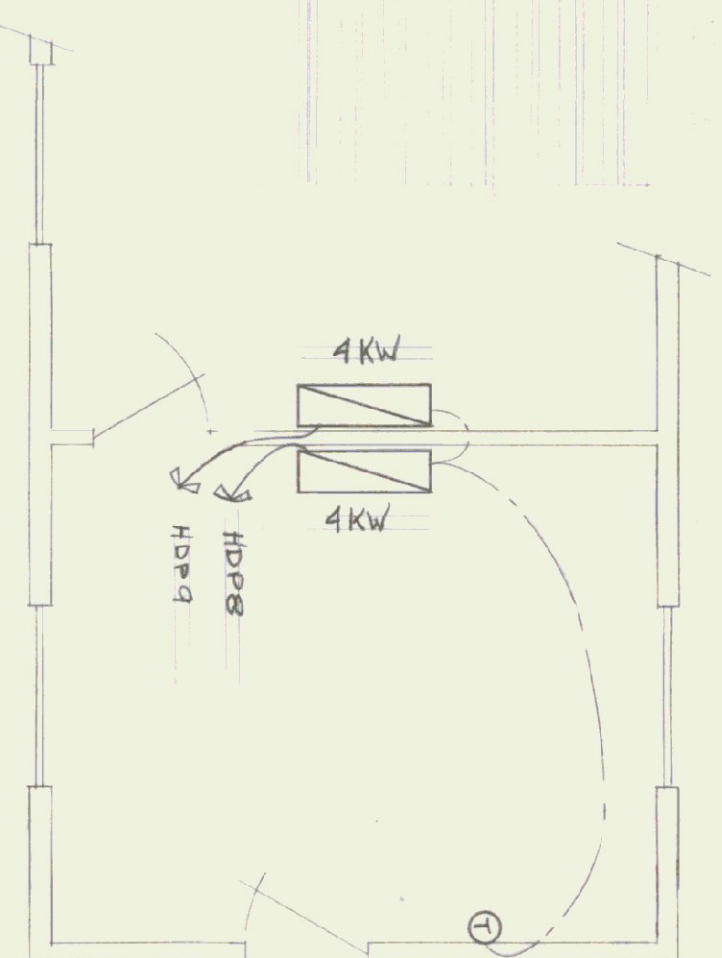
[illegible]

Main Distribution Panel - Circuit Breaker Type, Identification 240V, 100 AMP, 1" W, 3" D, 200K, 1000W 12/10/01 240V, 100 AMP, 1" W, 3" D, 200K, 1000W 12/10/01		
Circuit Number	Breaker	Remarks
1	20	RECEPTACLES - DESK AREA
2	20	RECEPTACLES - LOBBY AREA
3	20	RECEPTACLES - VENDING AREA
4	20	RECEPTACLES - MEN/WOMEN
5	20	RECEPTACLES - OFFICE AREA
6	20	LIGHTING
7	20	LIGHTING
8	20	LIGHTING
9	20	ELECTRIC HOT WATER HEATER
10	20	EMERGENCY LIGHTING
11	20	RECEPTACLES - REST ROOMS
12	20	RECEPTACLES - BUILDING PLANTS
13-17	20	EXTERIOR FOUNDATION RECEPT.
18	20	SPACES
19-22	20	SPACES

 
HEATING PLAN

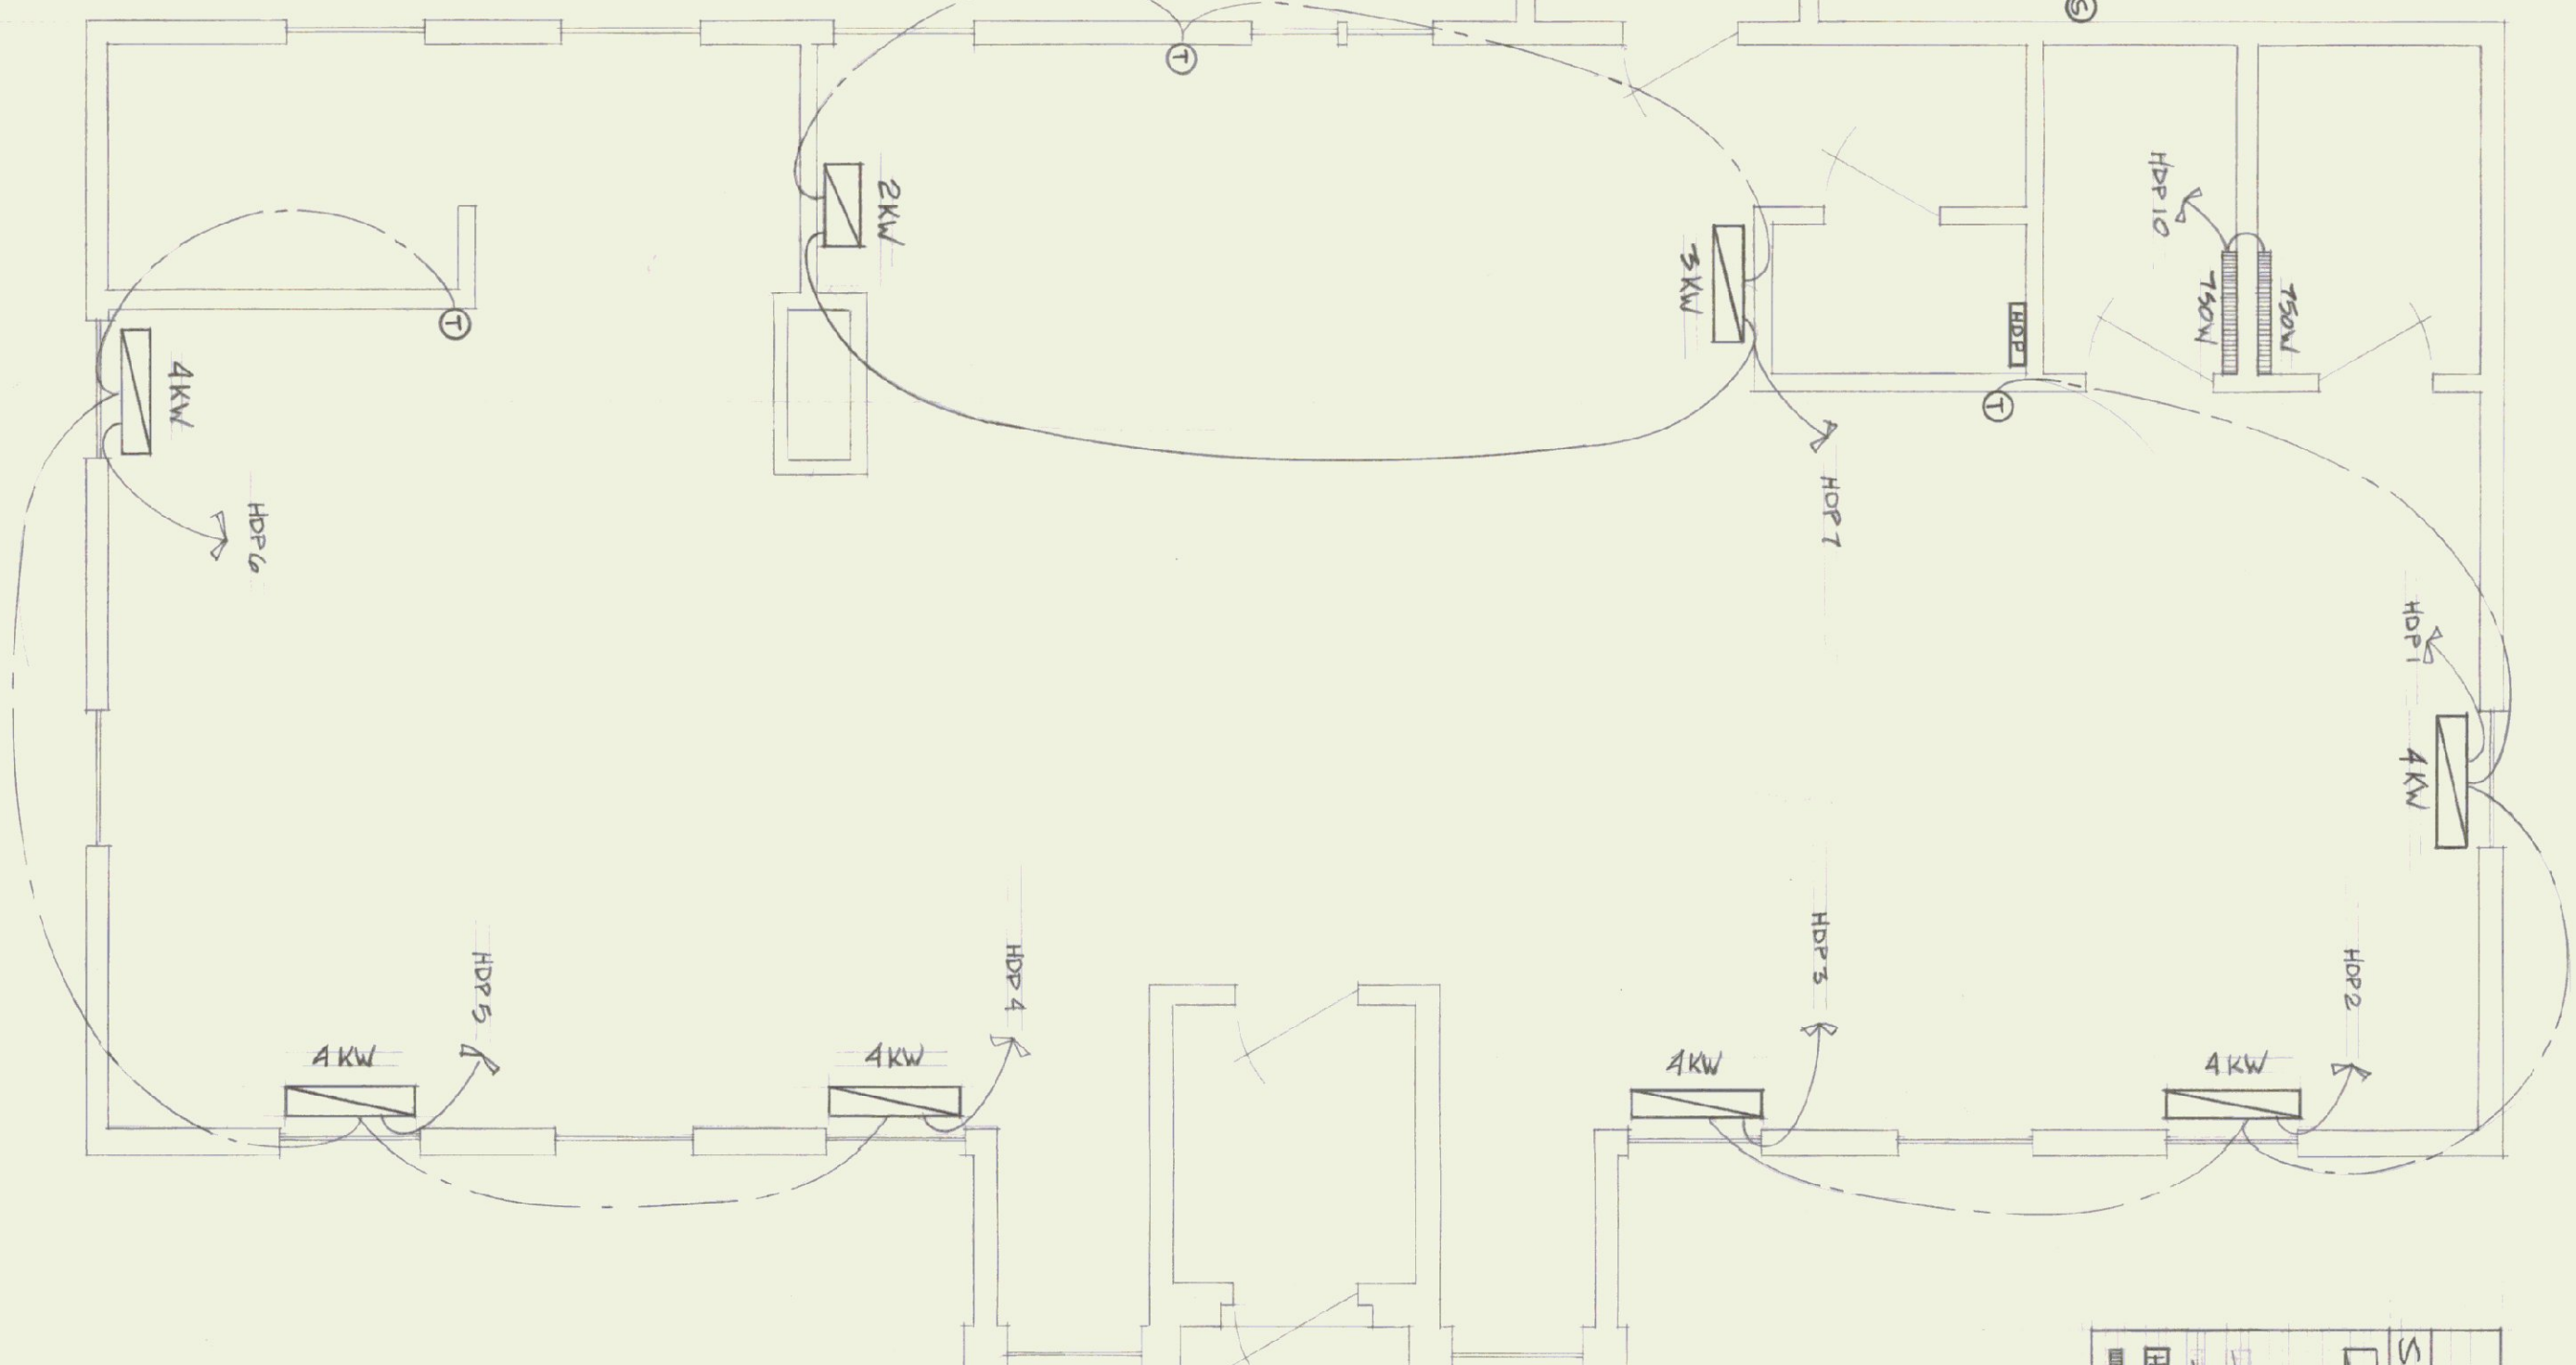

SYMBOL	DESCRIPTION	HEATING LEAD	MANUFACTURER AND MODEL NUMBER	LOCATION
	STANDARD HEAT UNIT w/ SIZE THERMOSTAT		ACE - TELEPHONEN	
①	THERMOSTAT		ACE - TELEPHONEN	
⑤	DORMER TEMP SENSOR		ACE - TELEPHONEN	
	THERMOSTAT CIRCUIT			
	HEATED FIBER			
HP2	HEATING Duct PANEL			
	Re-circulating Heat Unit			
			Chromalox BCS-411-35-2 w/ THERMOSTAT	
				48 N.F.
				51 N.F.

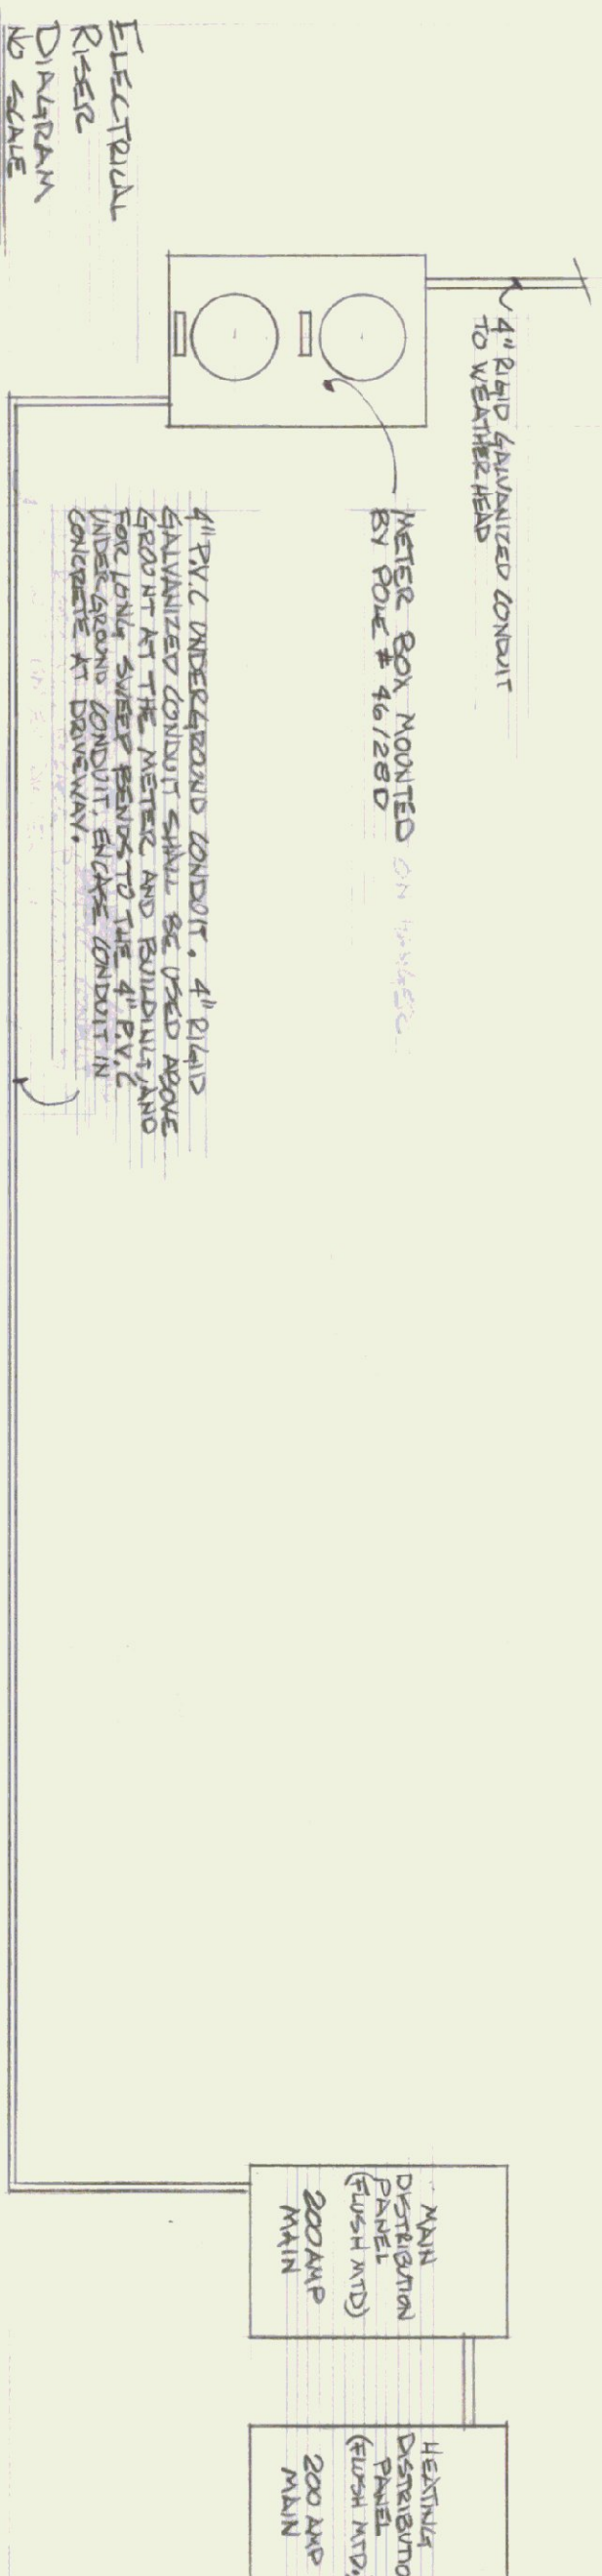


Location	Resumes	Equipment	Remarks
1-3	20	2	STORAGE HEATERS IN DISIN AREA
4-6	20	2	STORAGE HEATERS IN LOUNGE AREA
7	30	2	STORAGE HEATERS IN COINTE AREA
8-9	20	2	STORAGE HEATERS IN EXISTING BUILDING
10	20	2	RESISTANCE HEATERS IN TOILETS
11/2	20	2	SPRINKLES

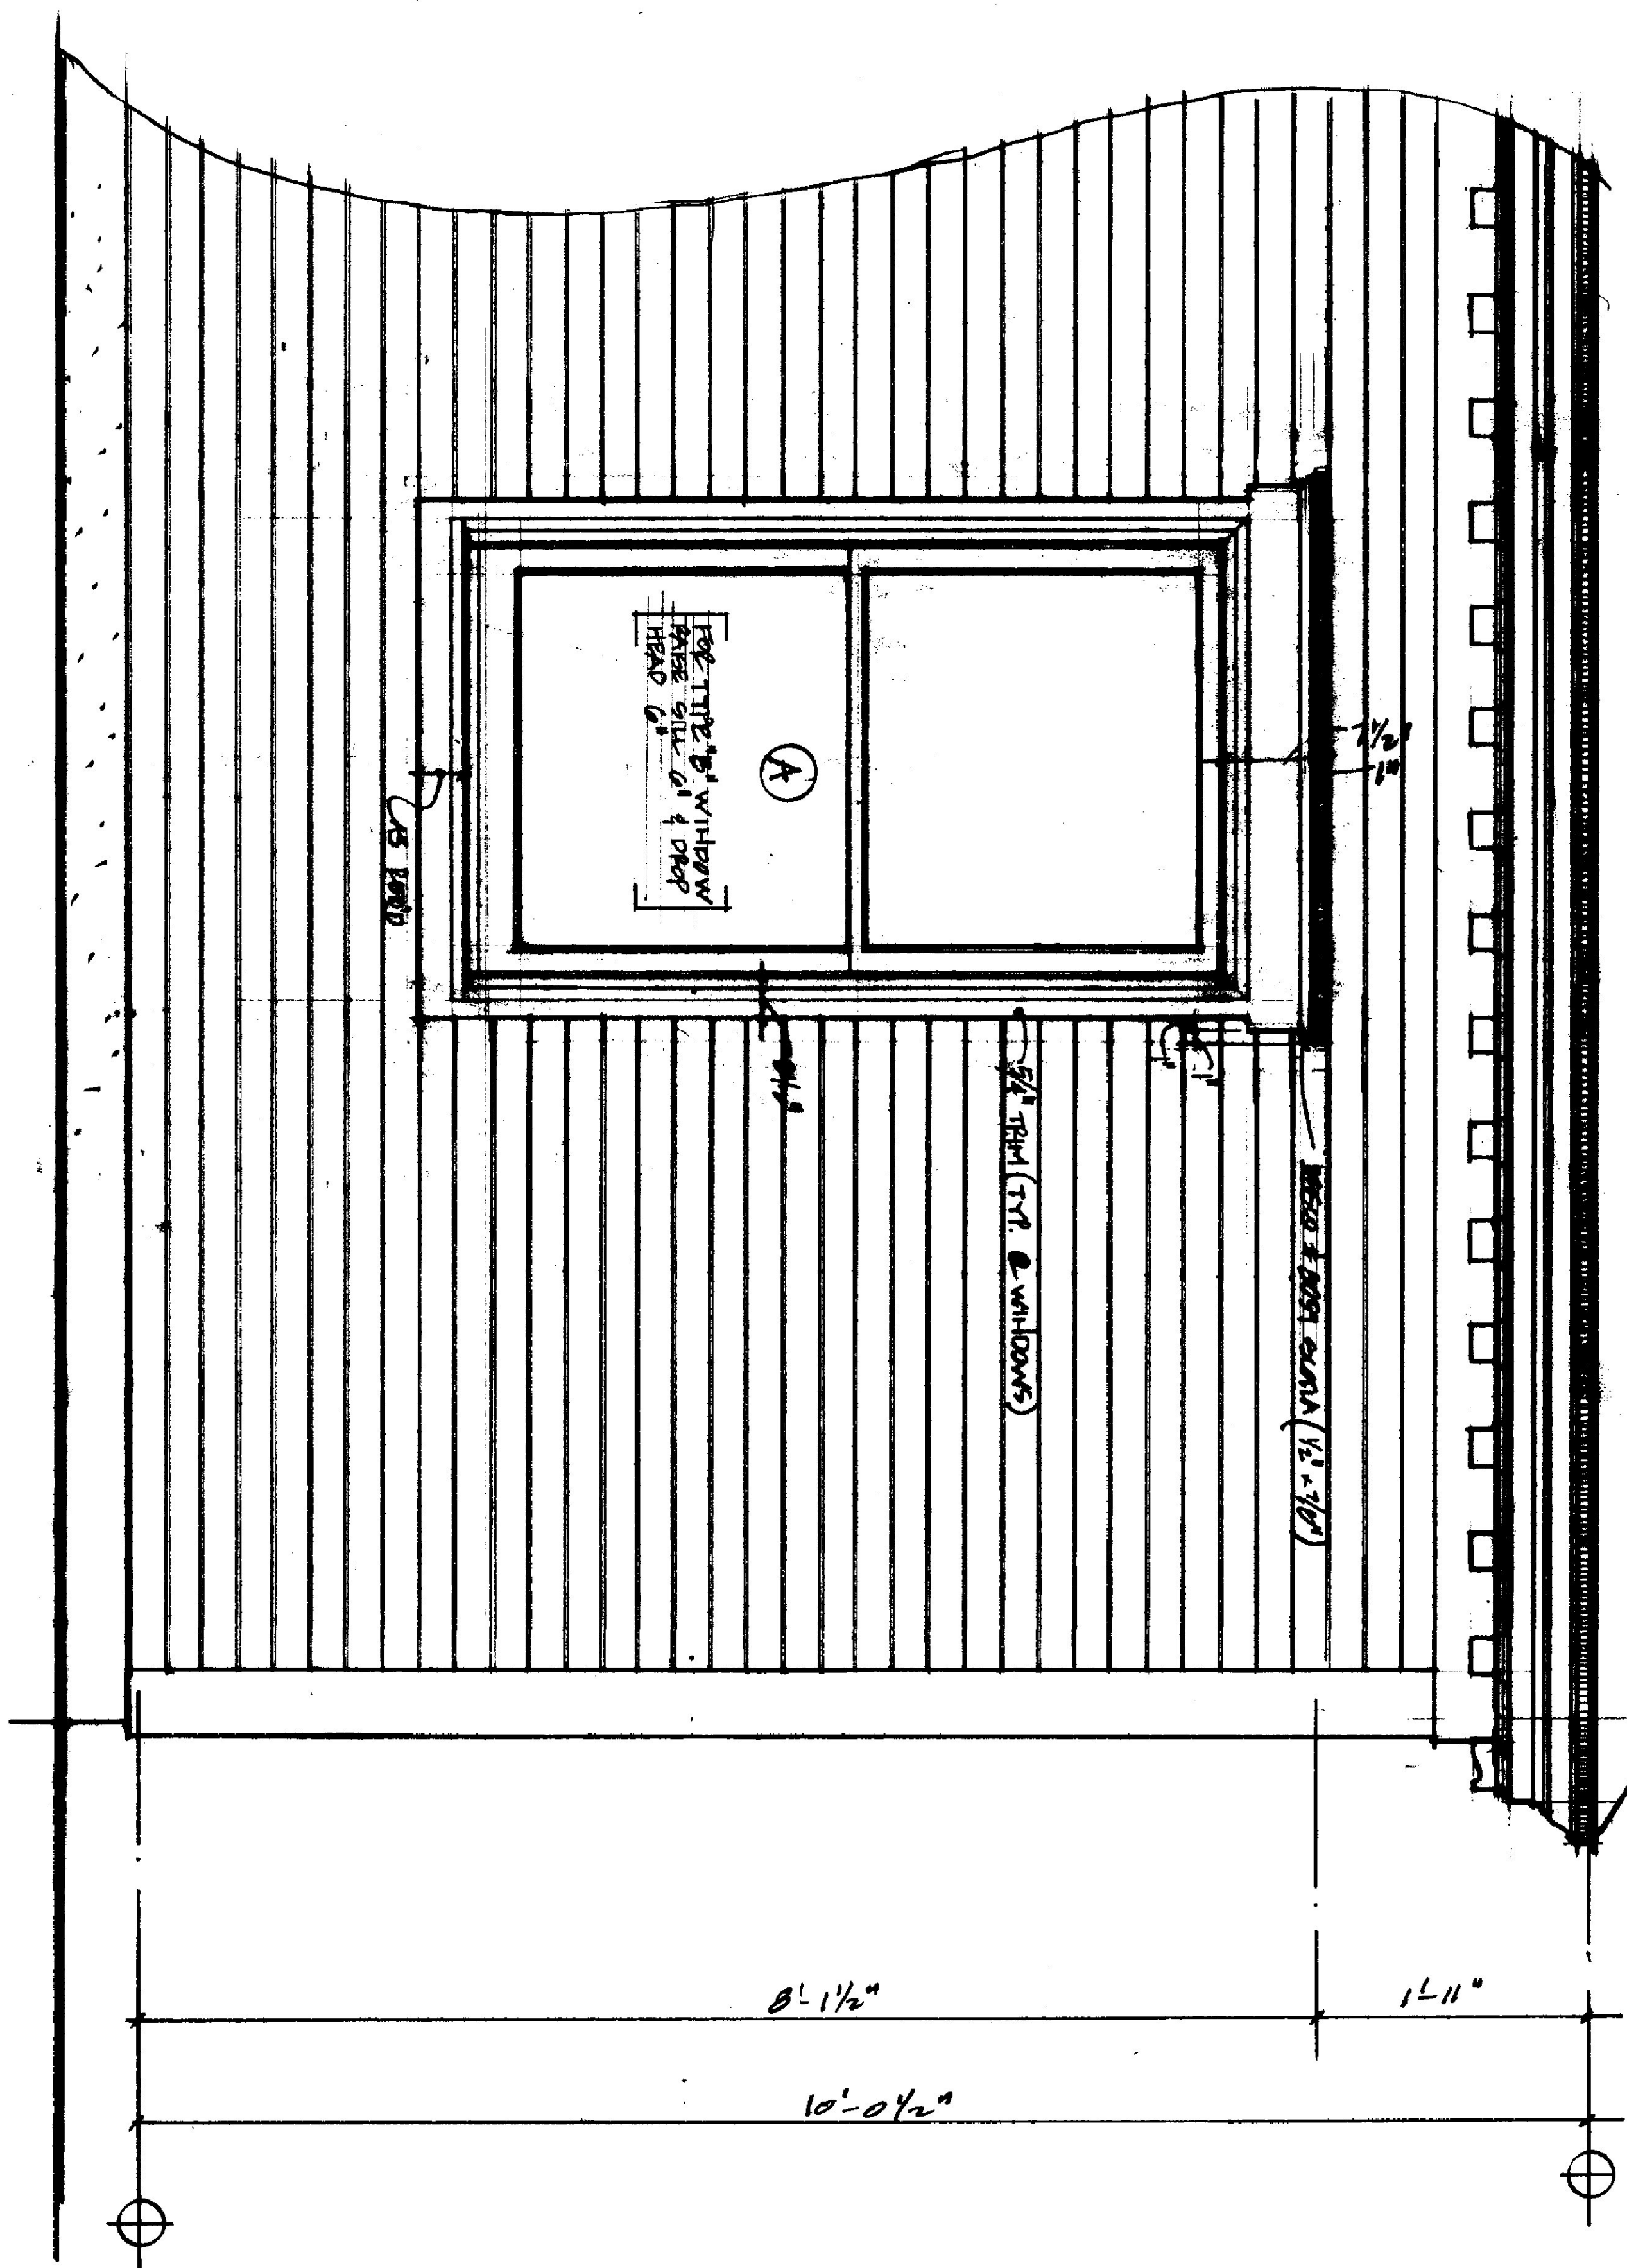

ELEVATION DETAIL 1'-1'-0"

2021-2022 2022-2023
 NEW TOWNHALL BUILDING
 10/2/21

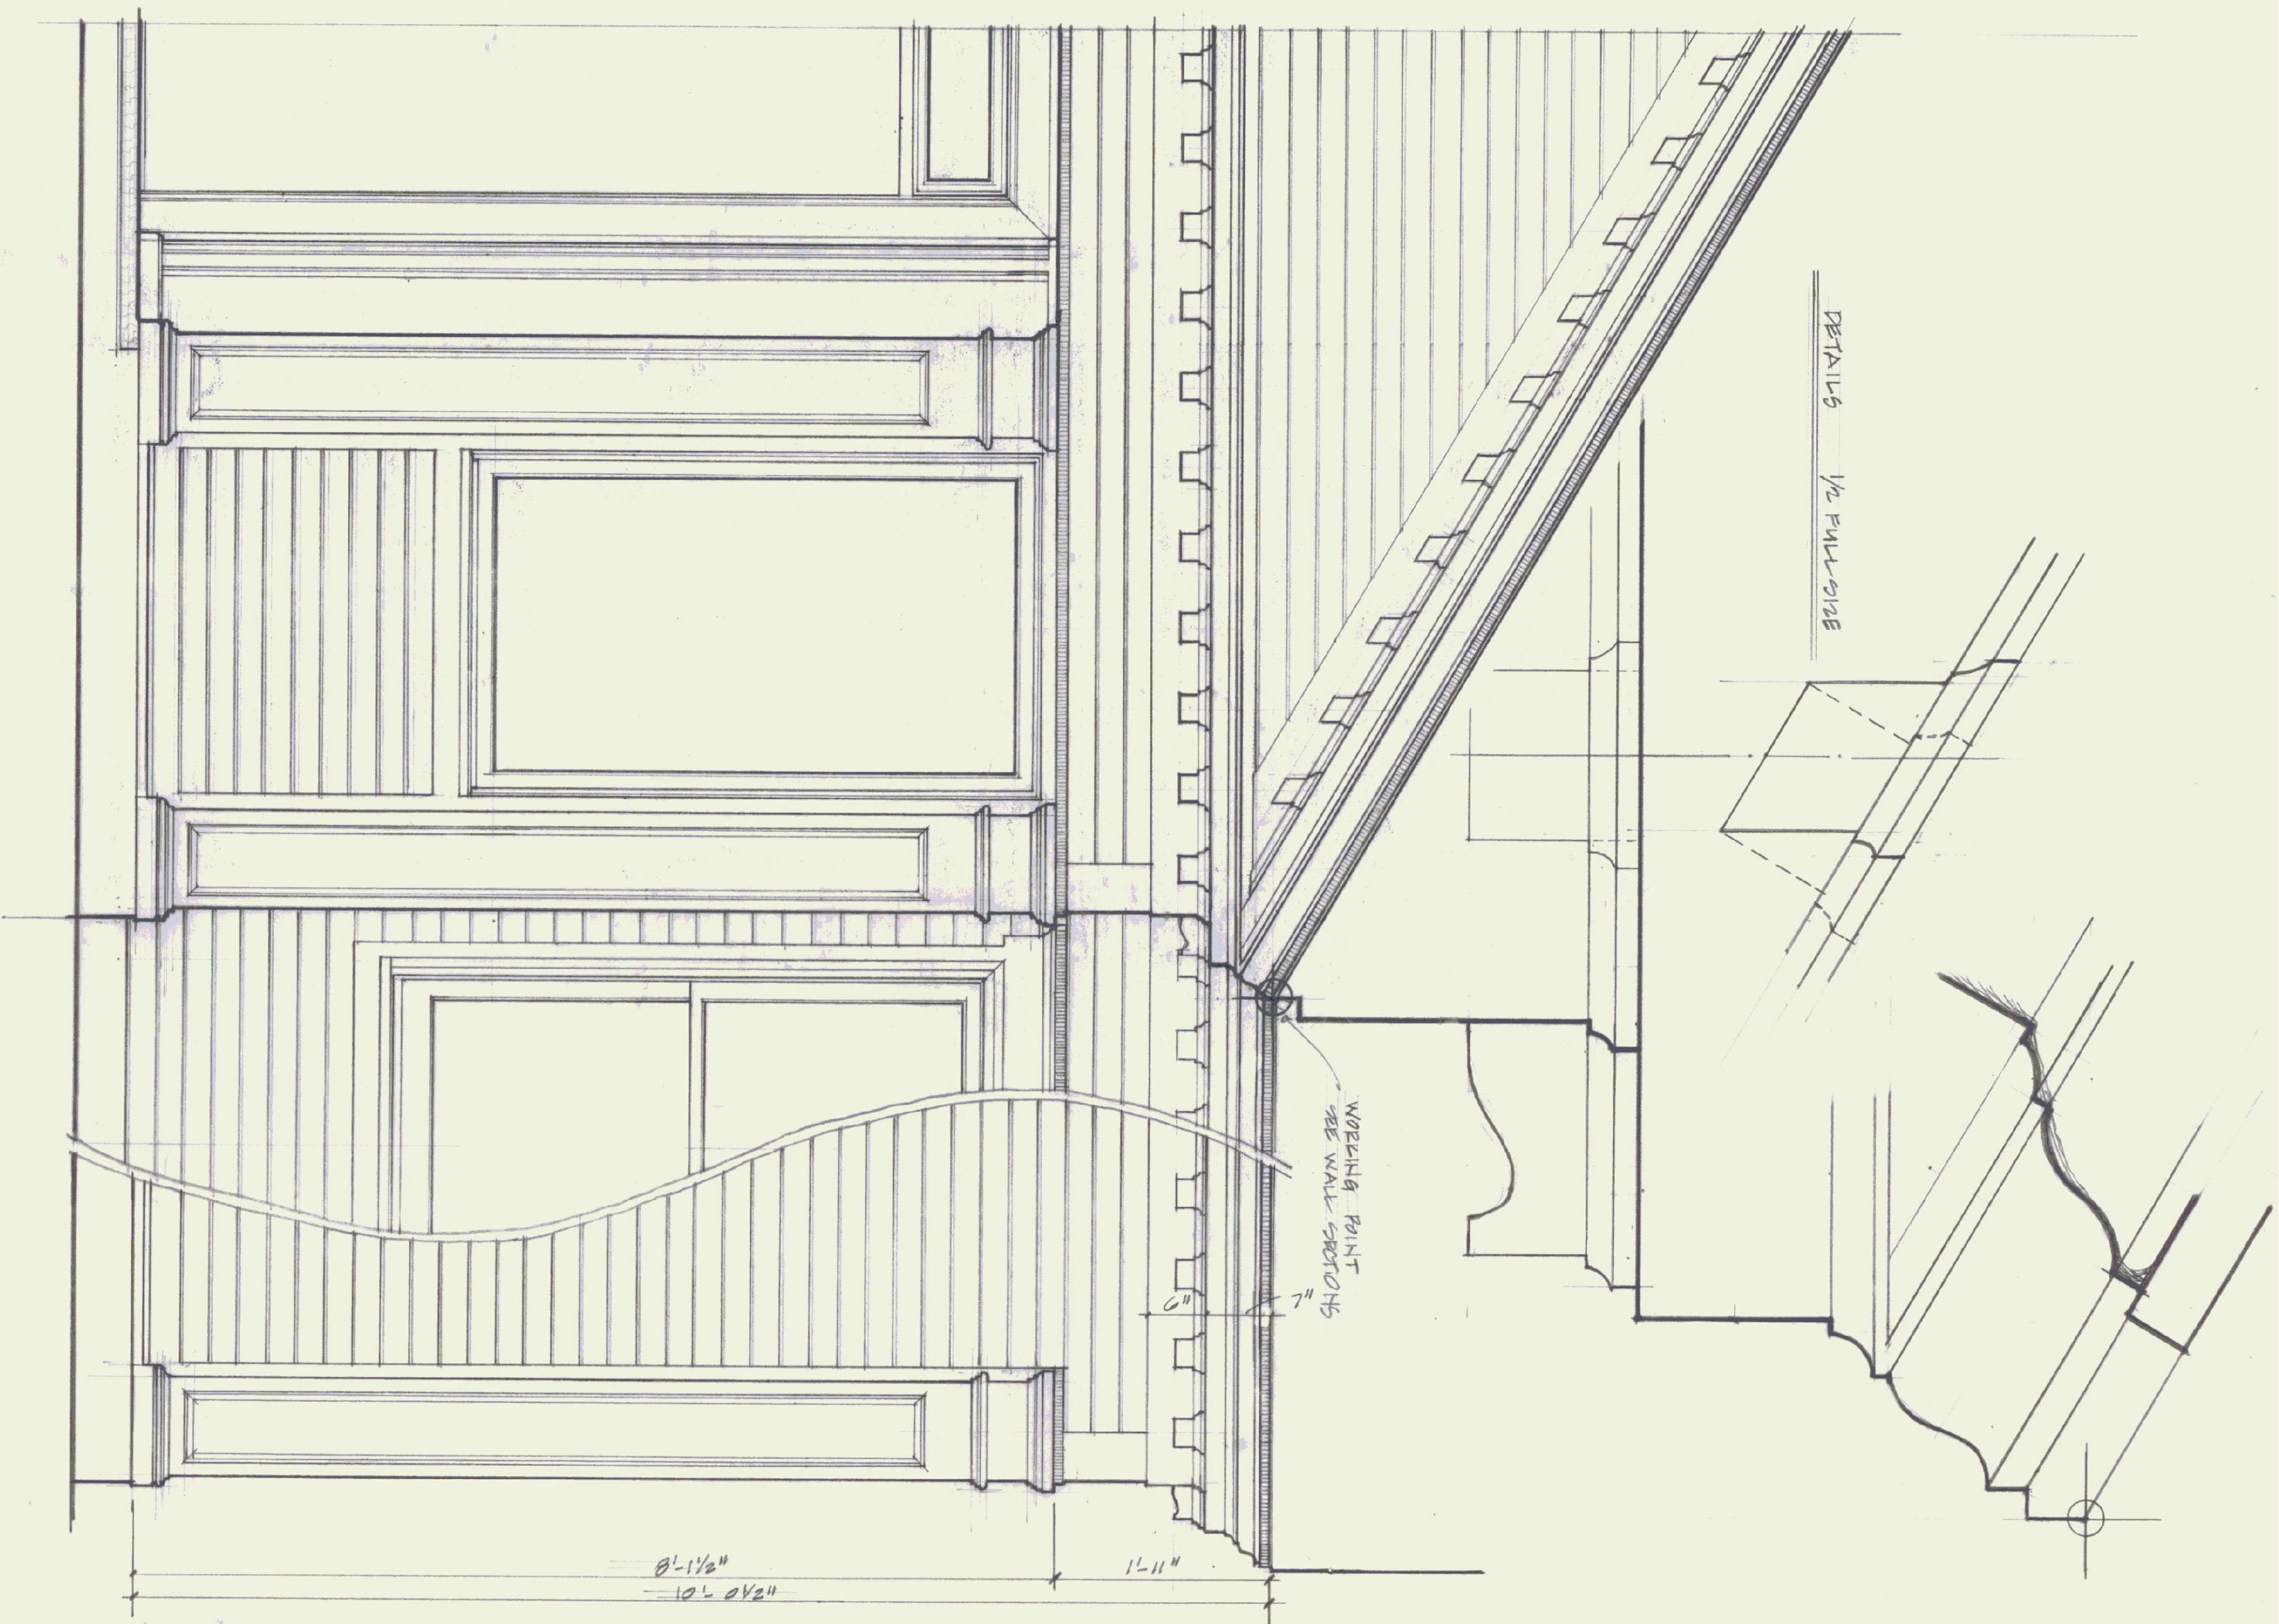


DETAILS 1/2 FULL SIZE



WORKING POINT
SEE WALL SECTIONS

ELEVATION DETAIL 1" = 1'-0"



SPRINGFIELD STATE AIRPORT
NEW TERMINAL BUILDING
P.S.B. 10/22/81

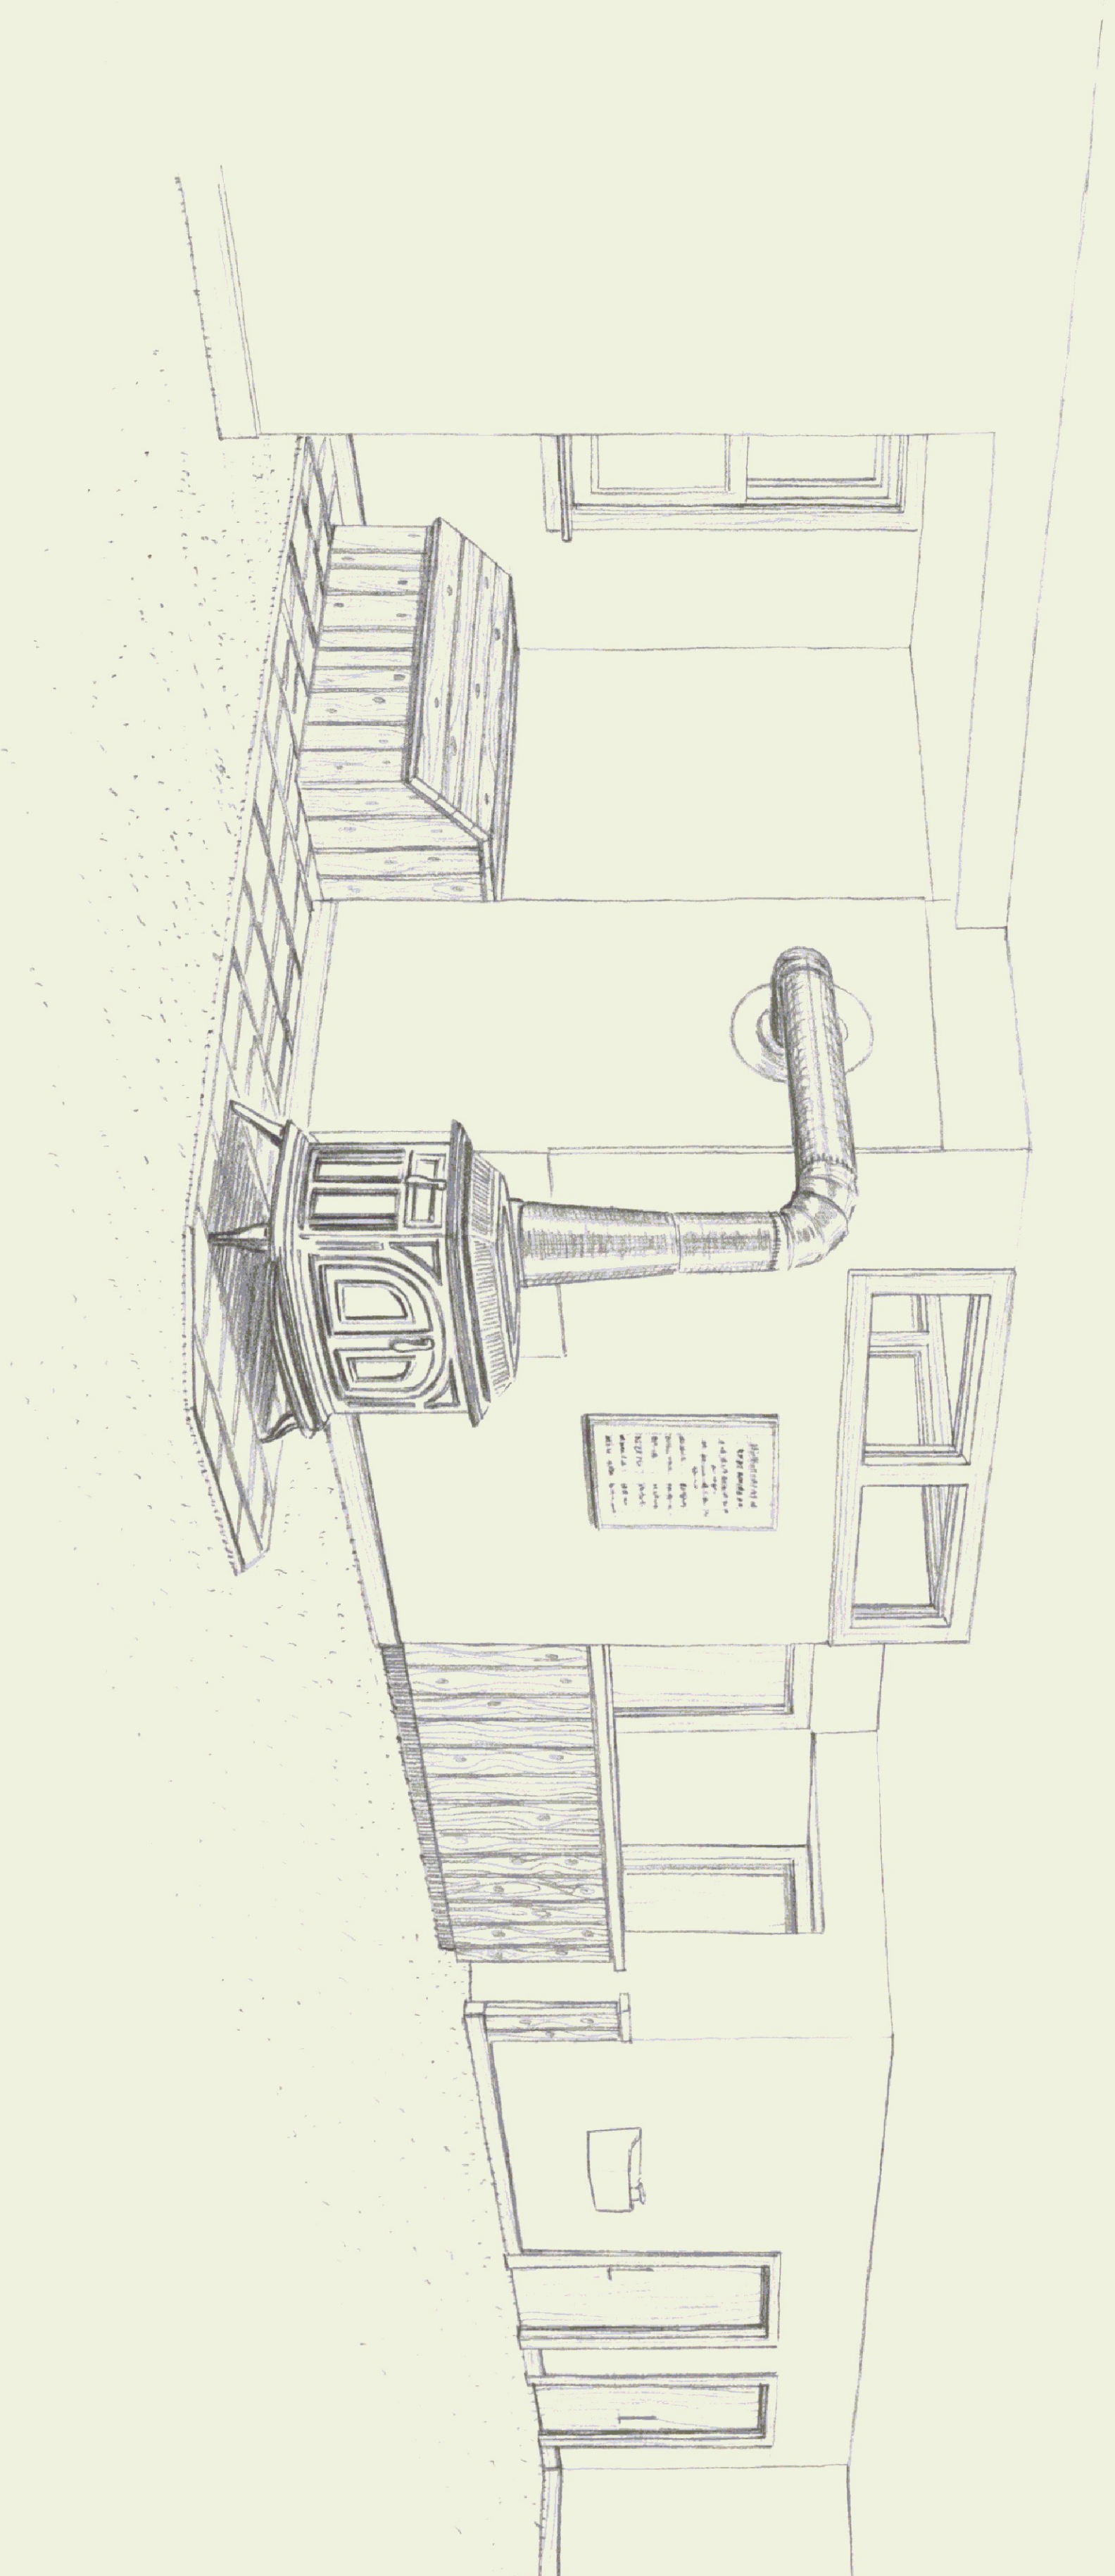

SPRINGFIELD STATE AIRPORT TERMINAL
INTERIOR PERSPECTIVE OF WOOD STOVE
DIVISION OF STATE BUILDINGS APRIL 5, 1982
A. BULLIN

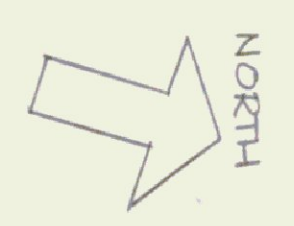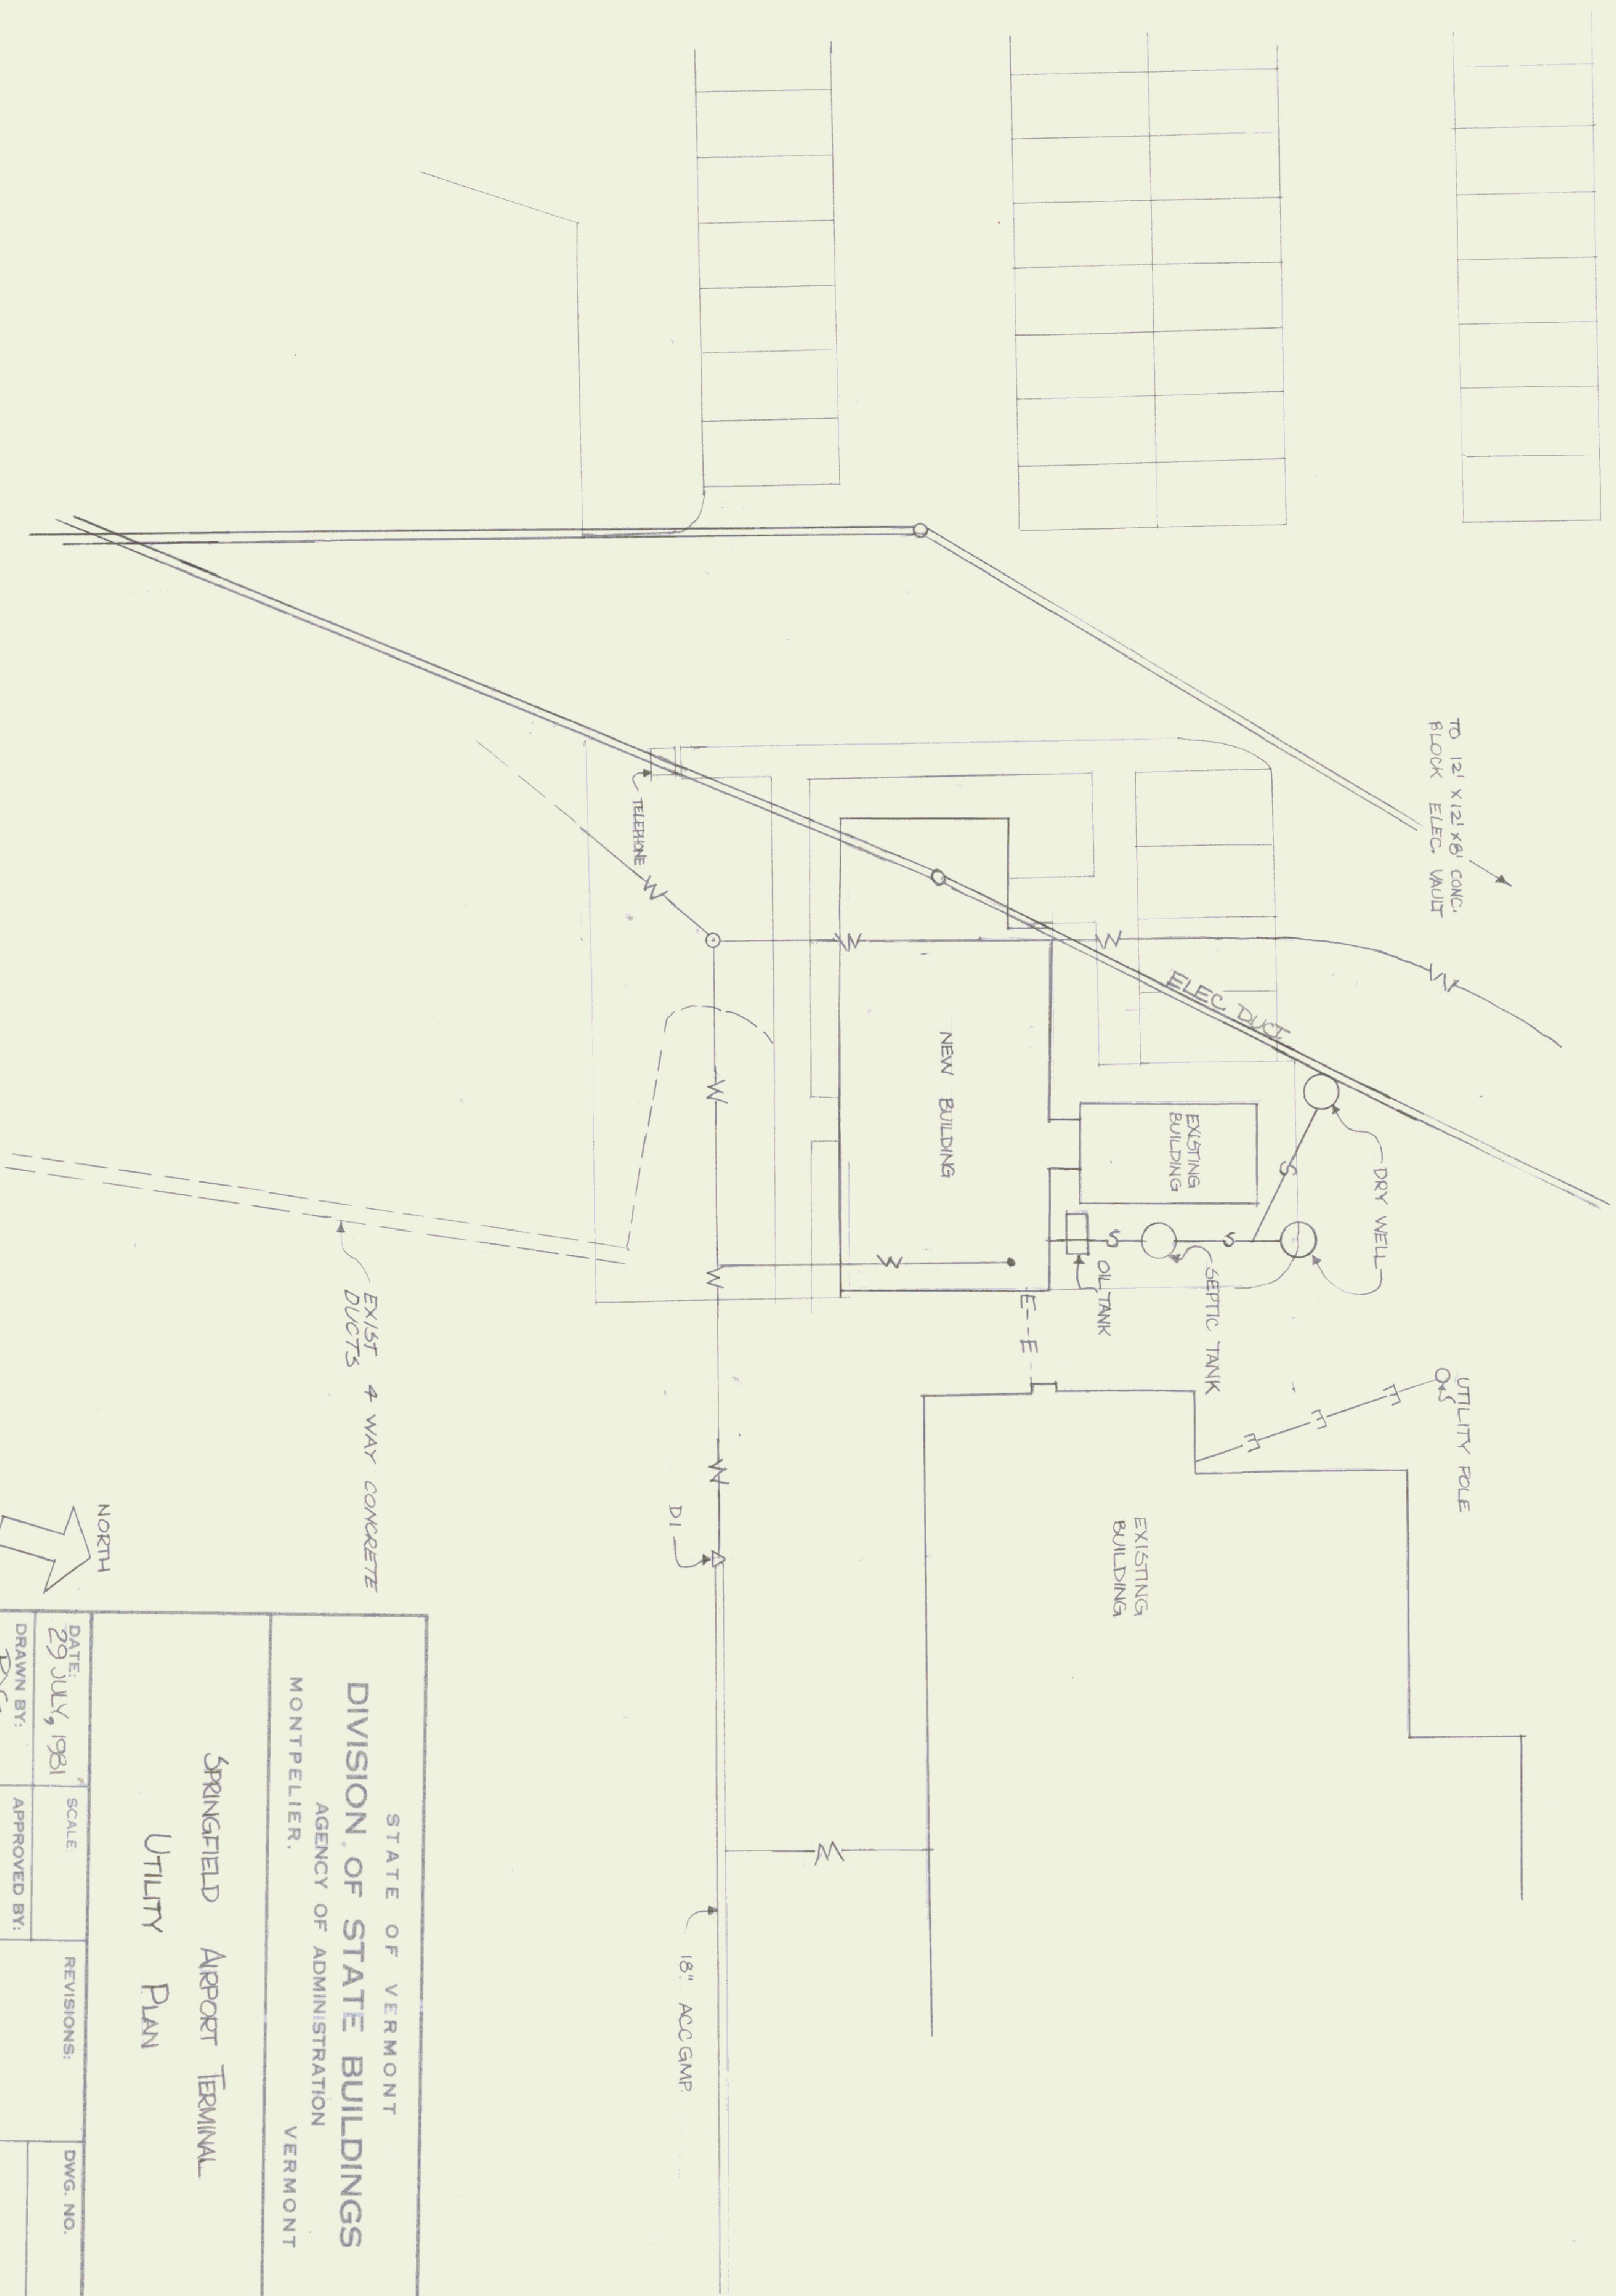


STATE OF VERMONT			
DIVISION OF STATE BUILDINGS			
AGENCY OF ADMINISTRATION			
MONTPELIER, VERMONT			
SPRINGFIELD AIRPORT TERMINAL			
UTILITY PLAN			
DATE: 29 JULY, 1981	SCALE:	REVISIONS:	DWG. NO.
DRAWN BY: RGA	APPROVED BY:		OF

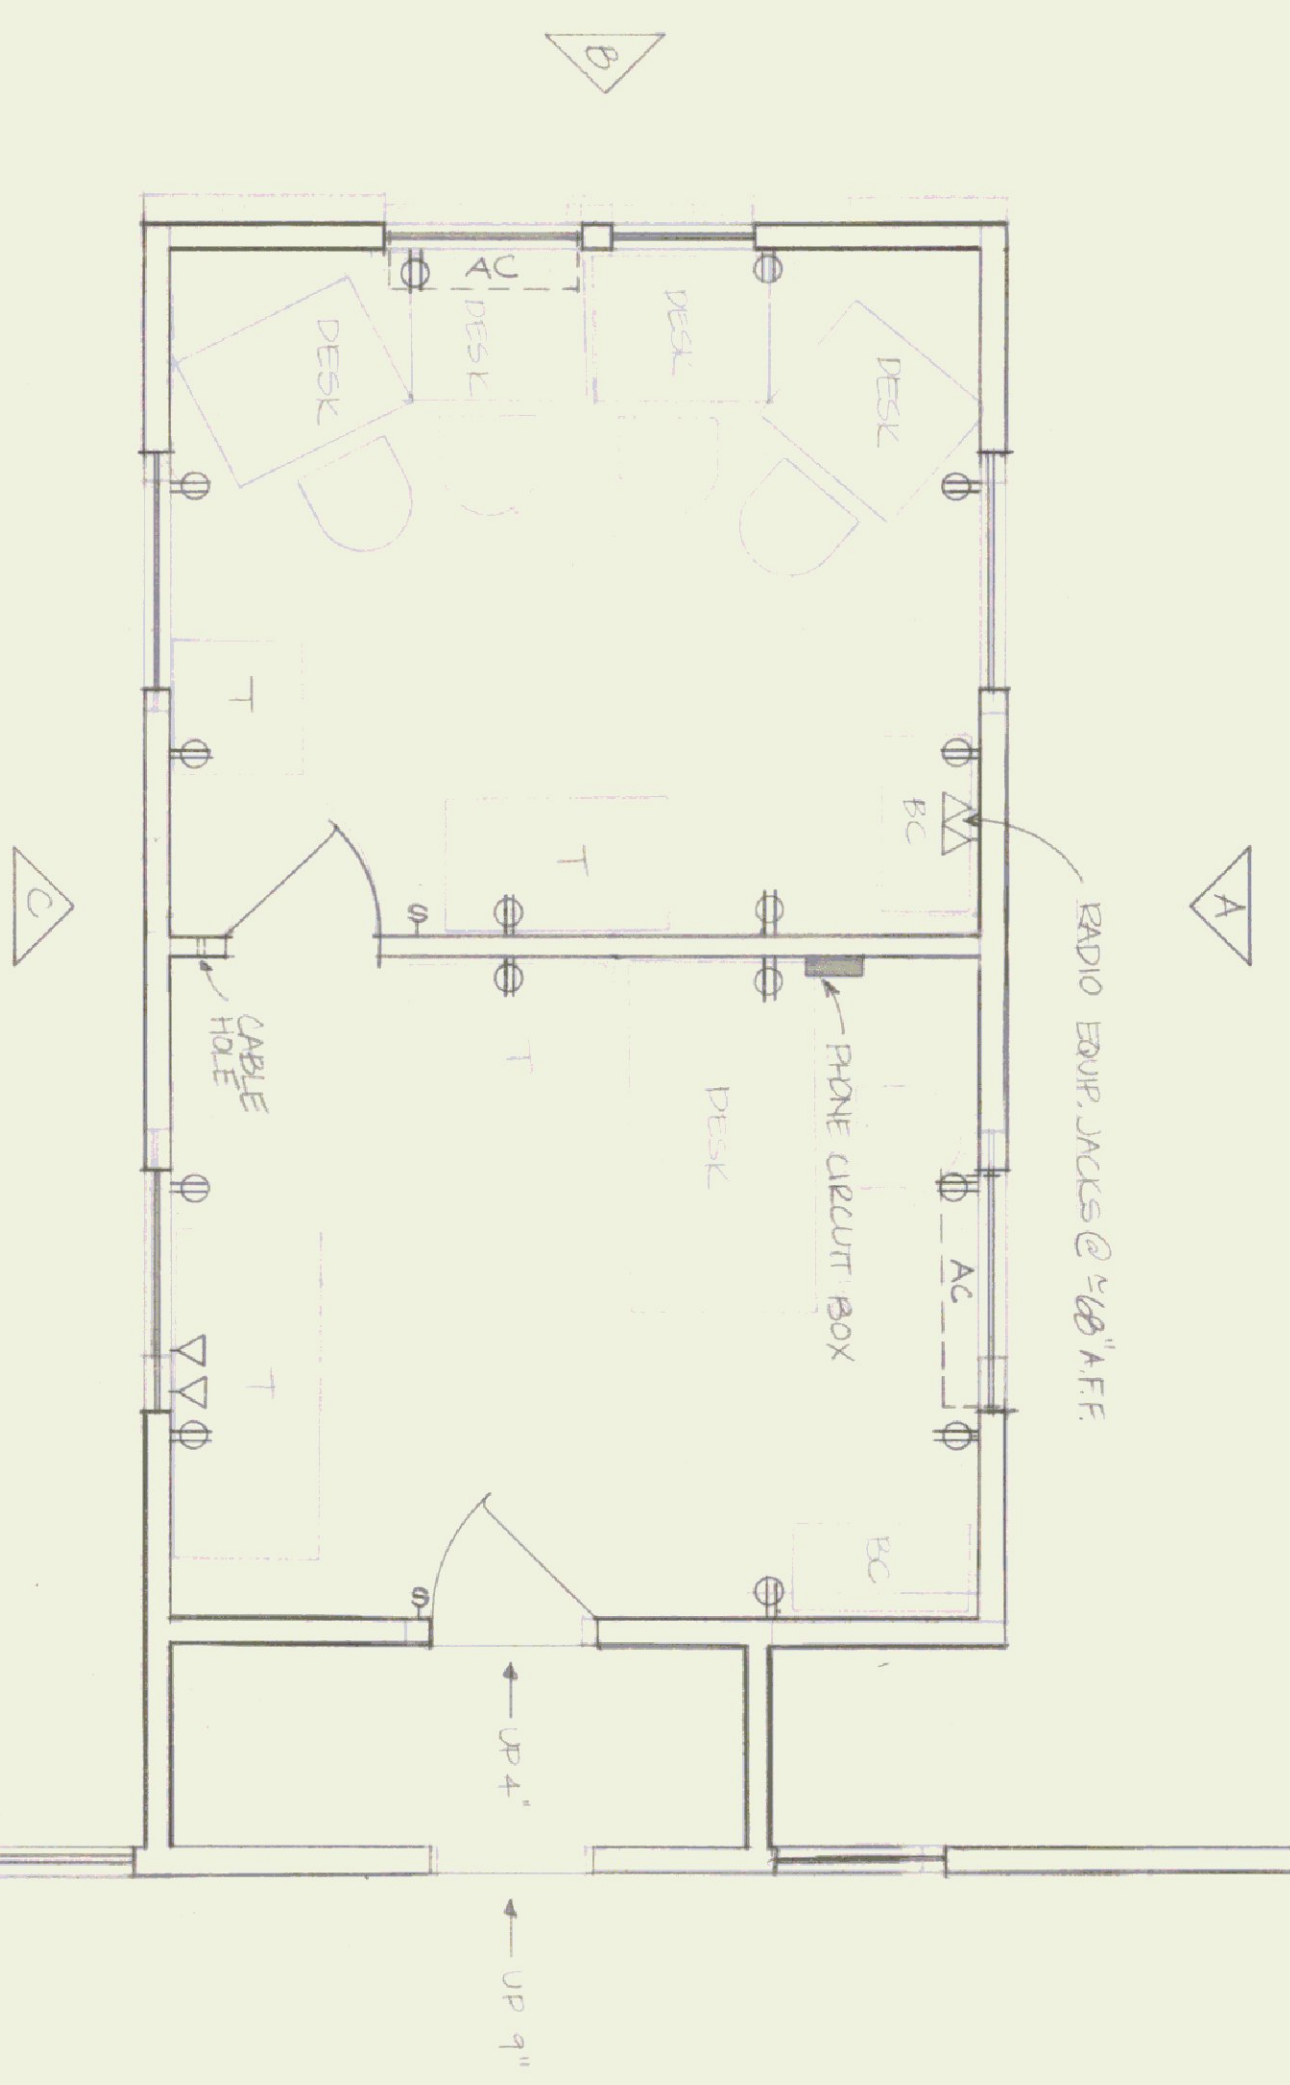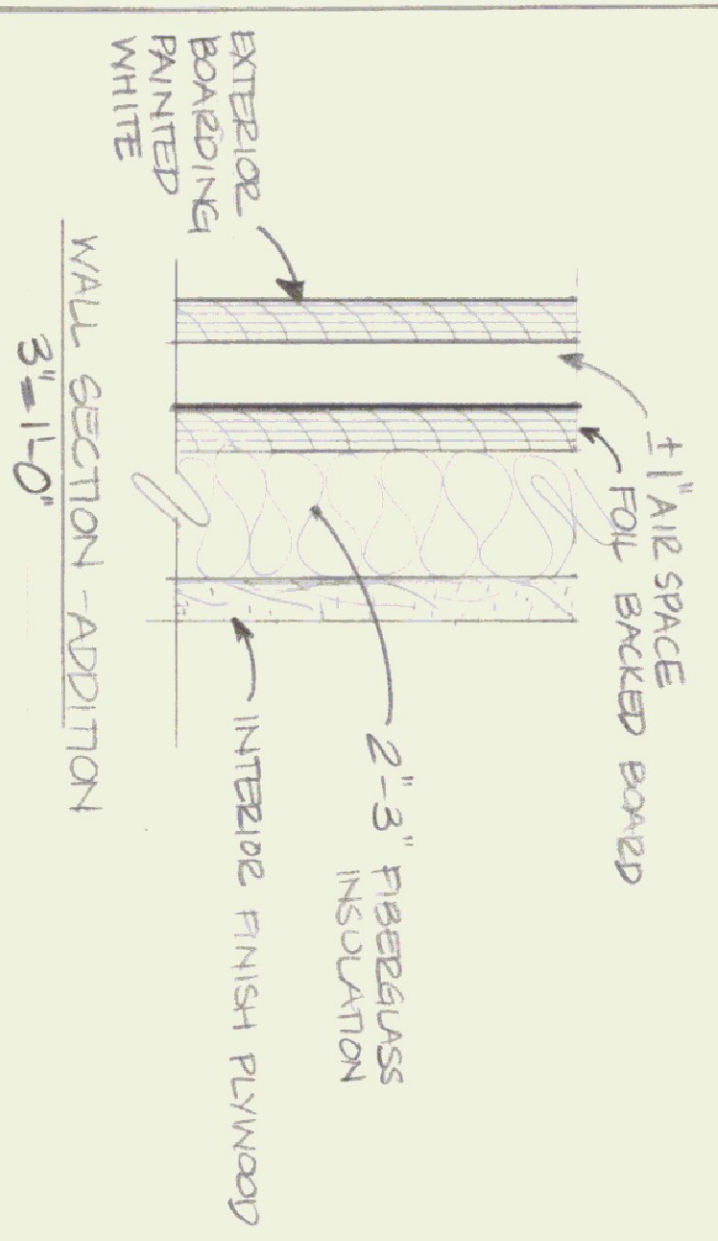



NOTES:

- 7'-8" CEILING HT. IN ADDITION
- 7'-1" " IN LINK UNIT
- 7'-11" " IN EXISTING TERMINAL
- ALL OUTLETS ARE DUPLEX TYPE, 110V, MOUNTED AT 16" A.F.F.
- CEILING INSULATION IN ADDITION IS 2" 6" FIBERGLASS
- CEILING INSULATION IN LINK UNIT IS 2" 3" FIBERGLASS

FLOOR PLAN - ADDITION AND LINK

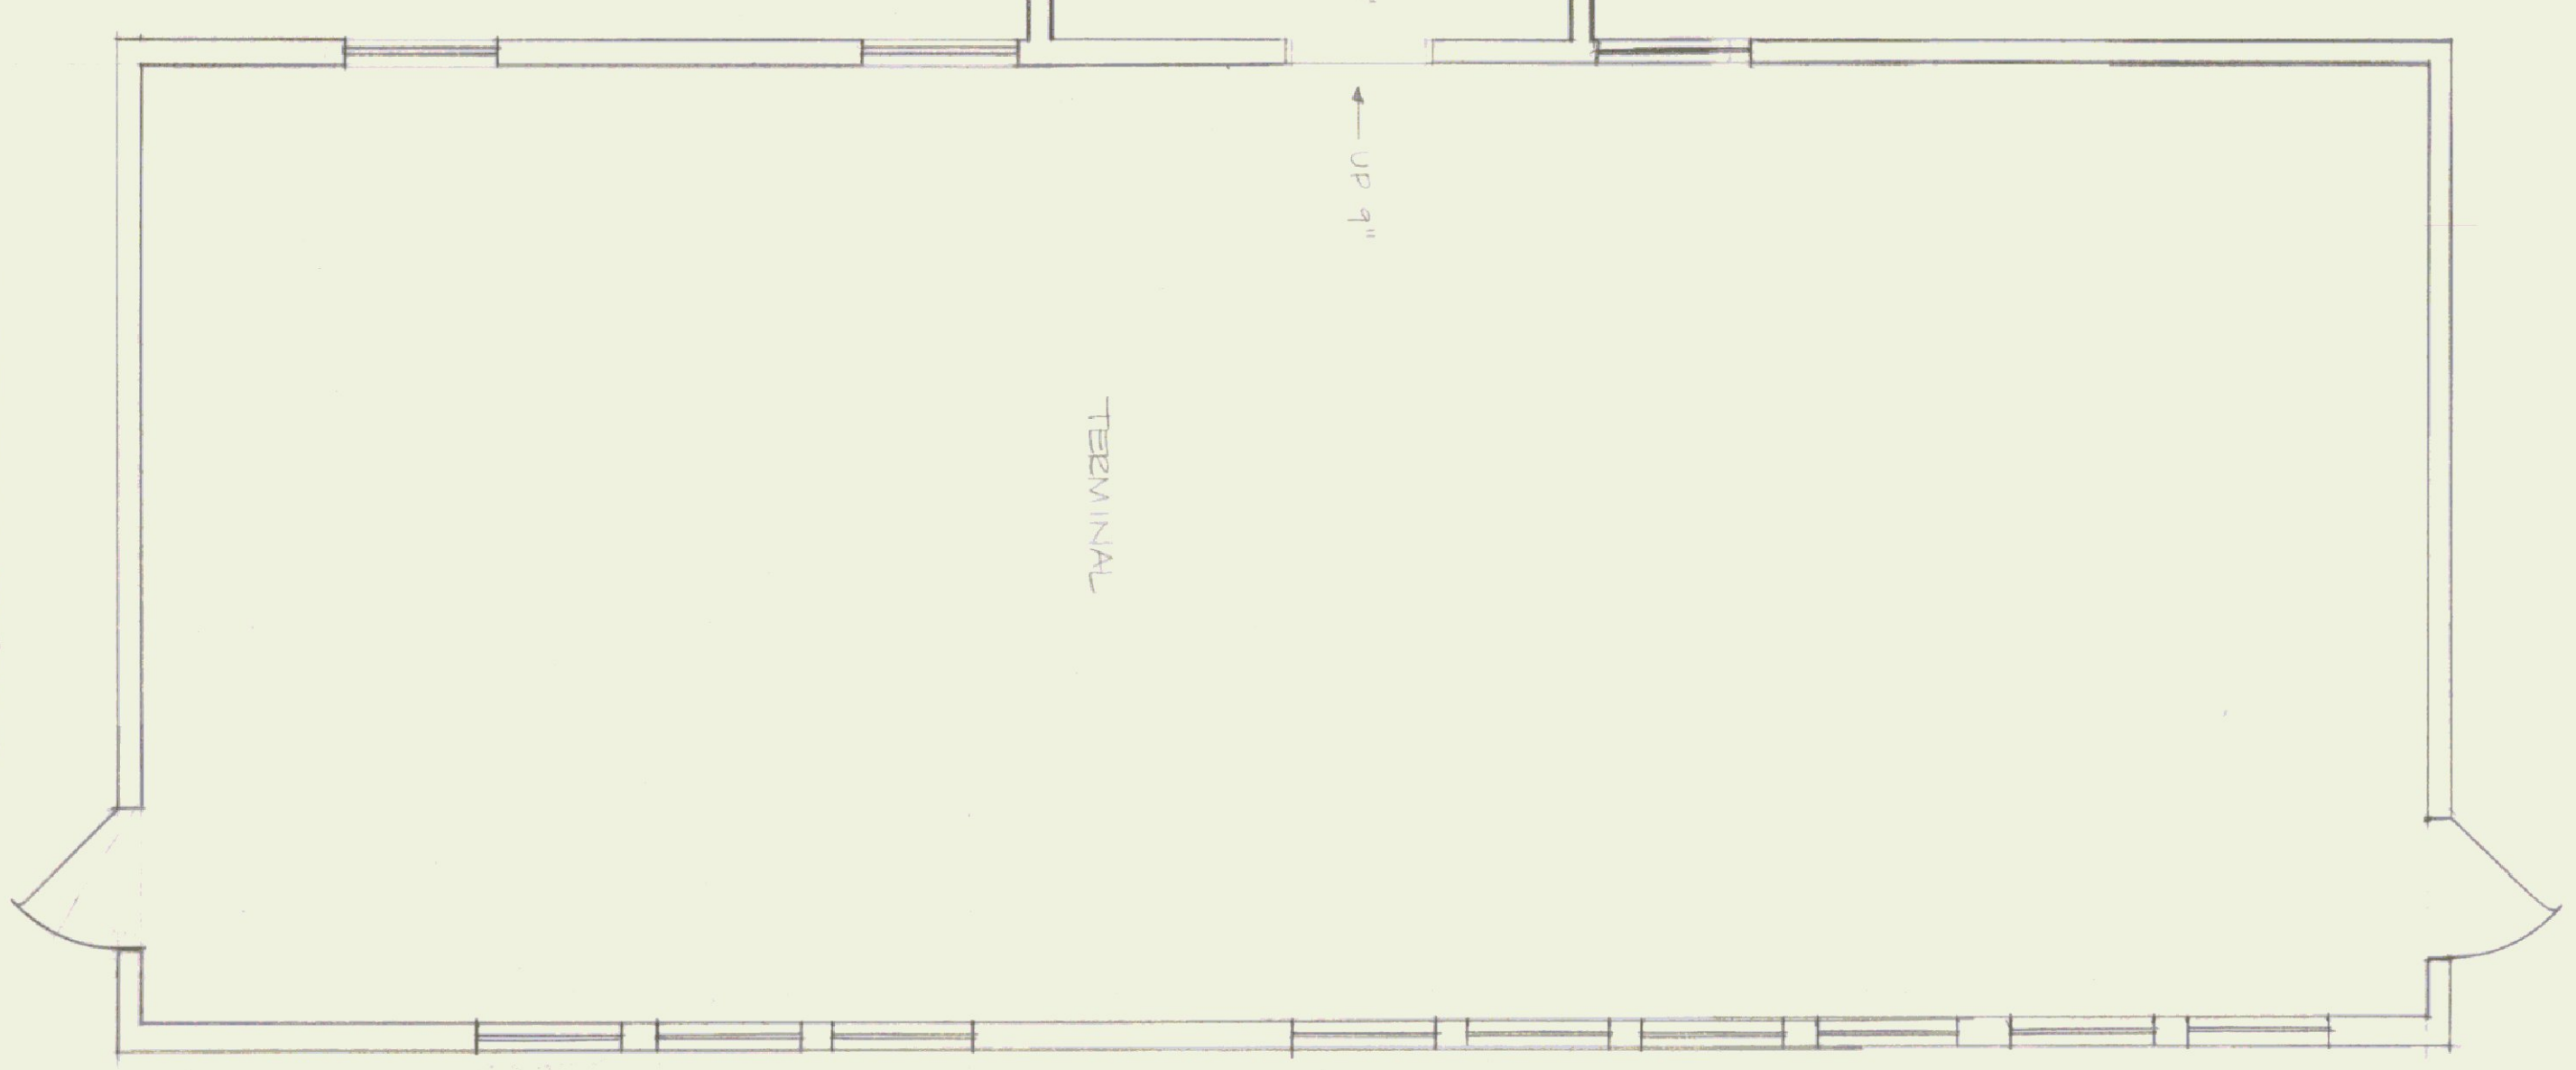

FLOOR PLAN - TERMINAL

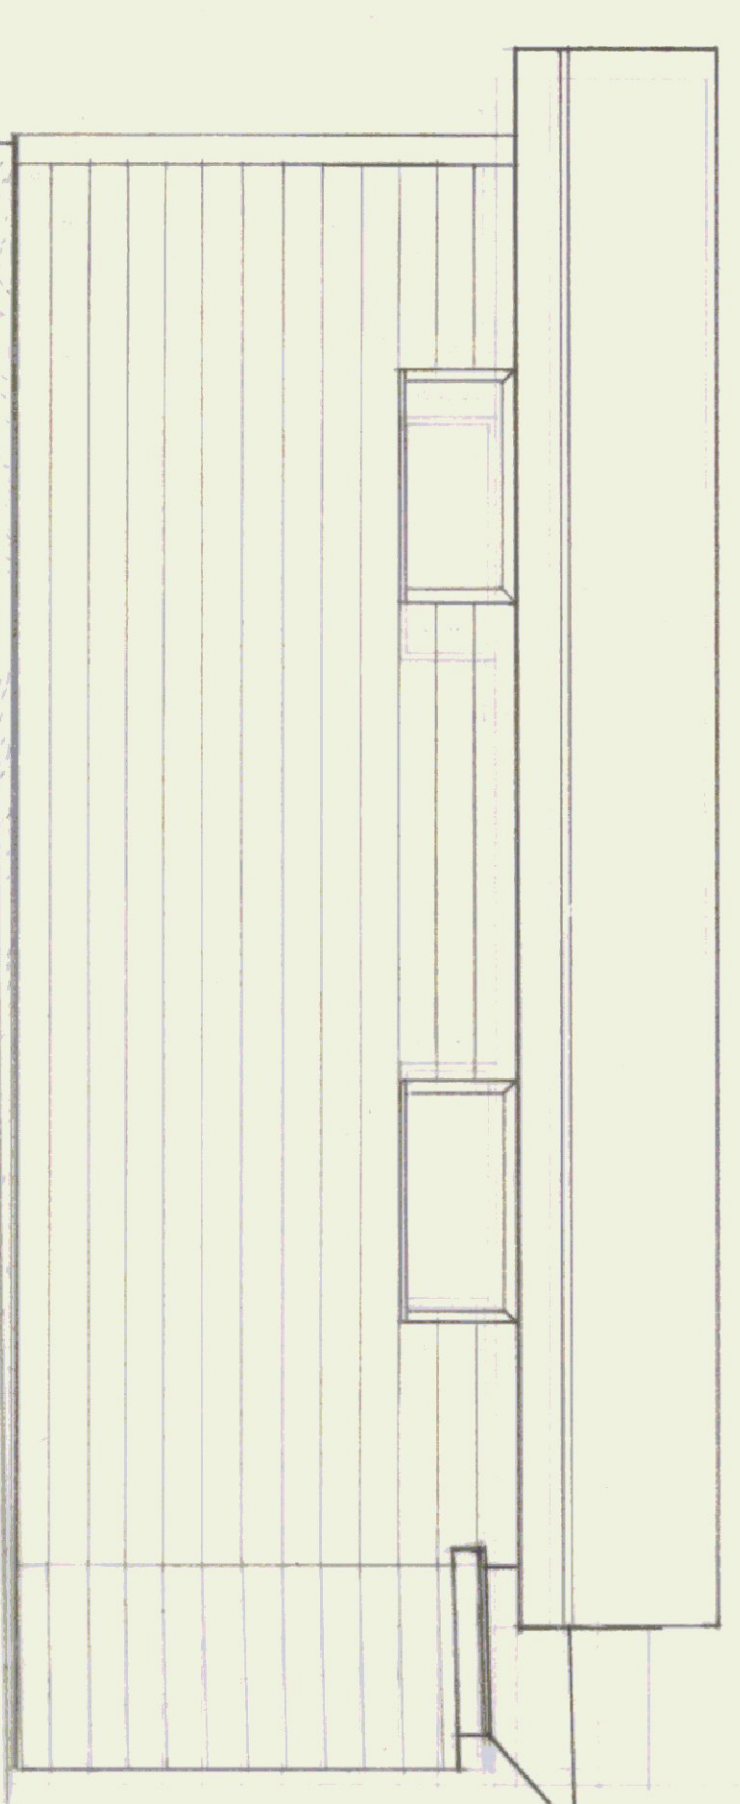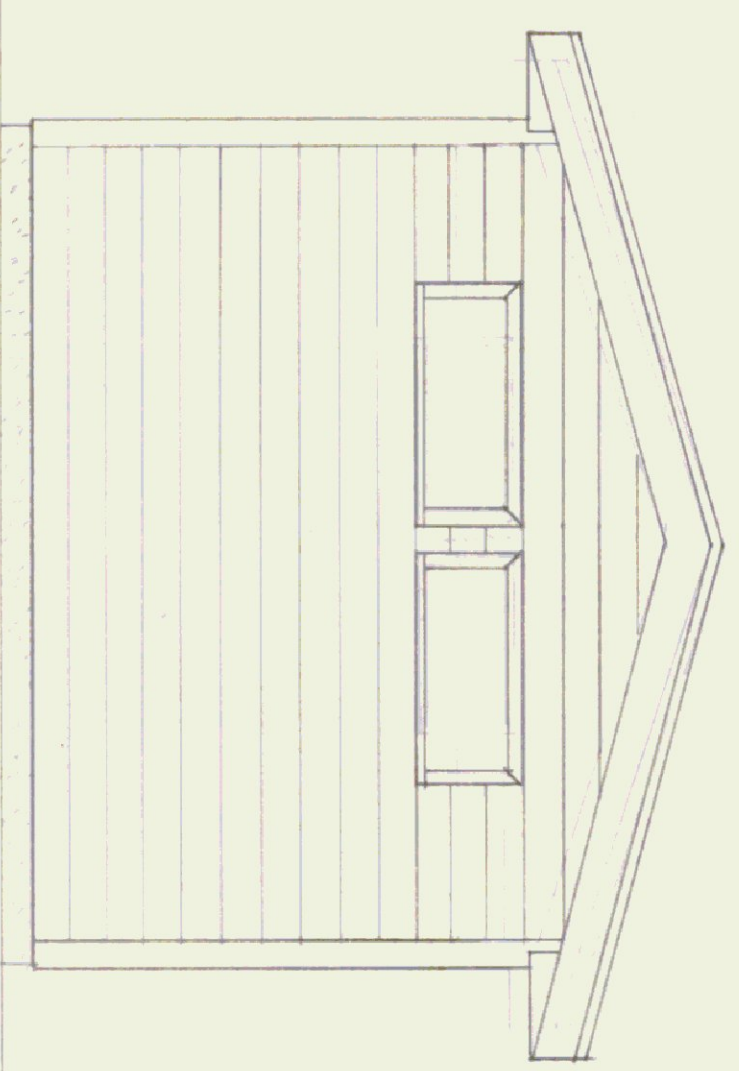

DATE:	8.13.81	SCALE:	1/4" = 1'-0"	REVISIONS:		DWG. NO.	
DRAWN BY:	HJG	APPROVED BY:				OF	

STATE OF VERMONT
DIVISION OF STATE BUILDINGS
AGENCY OF ADMINISTRATION
MONTPELIER, VERMONT

"AS-BUILT" PLAN AND ELEVATIONS
ADDITION AND LINK TO SPRINGFIELD AIRPORT
VERMONT