




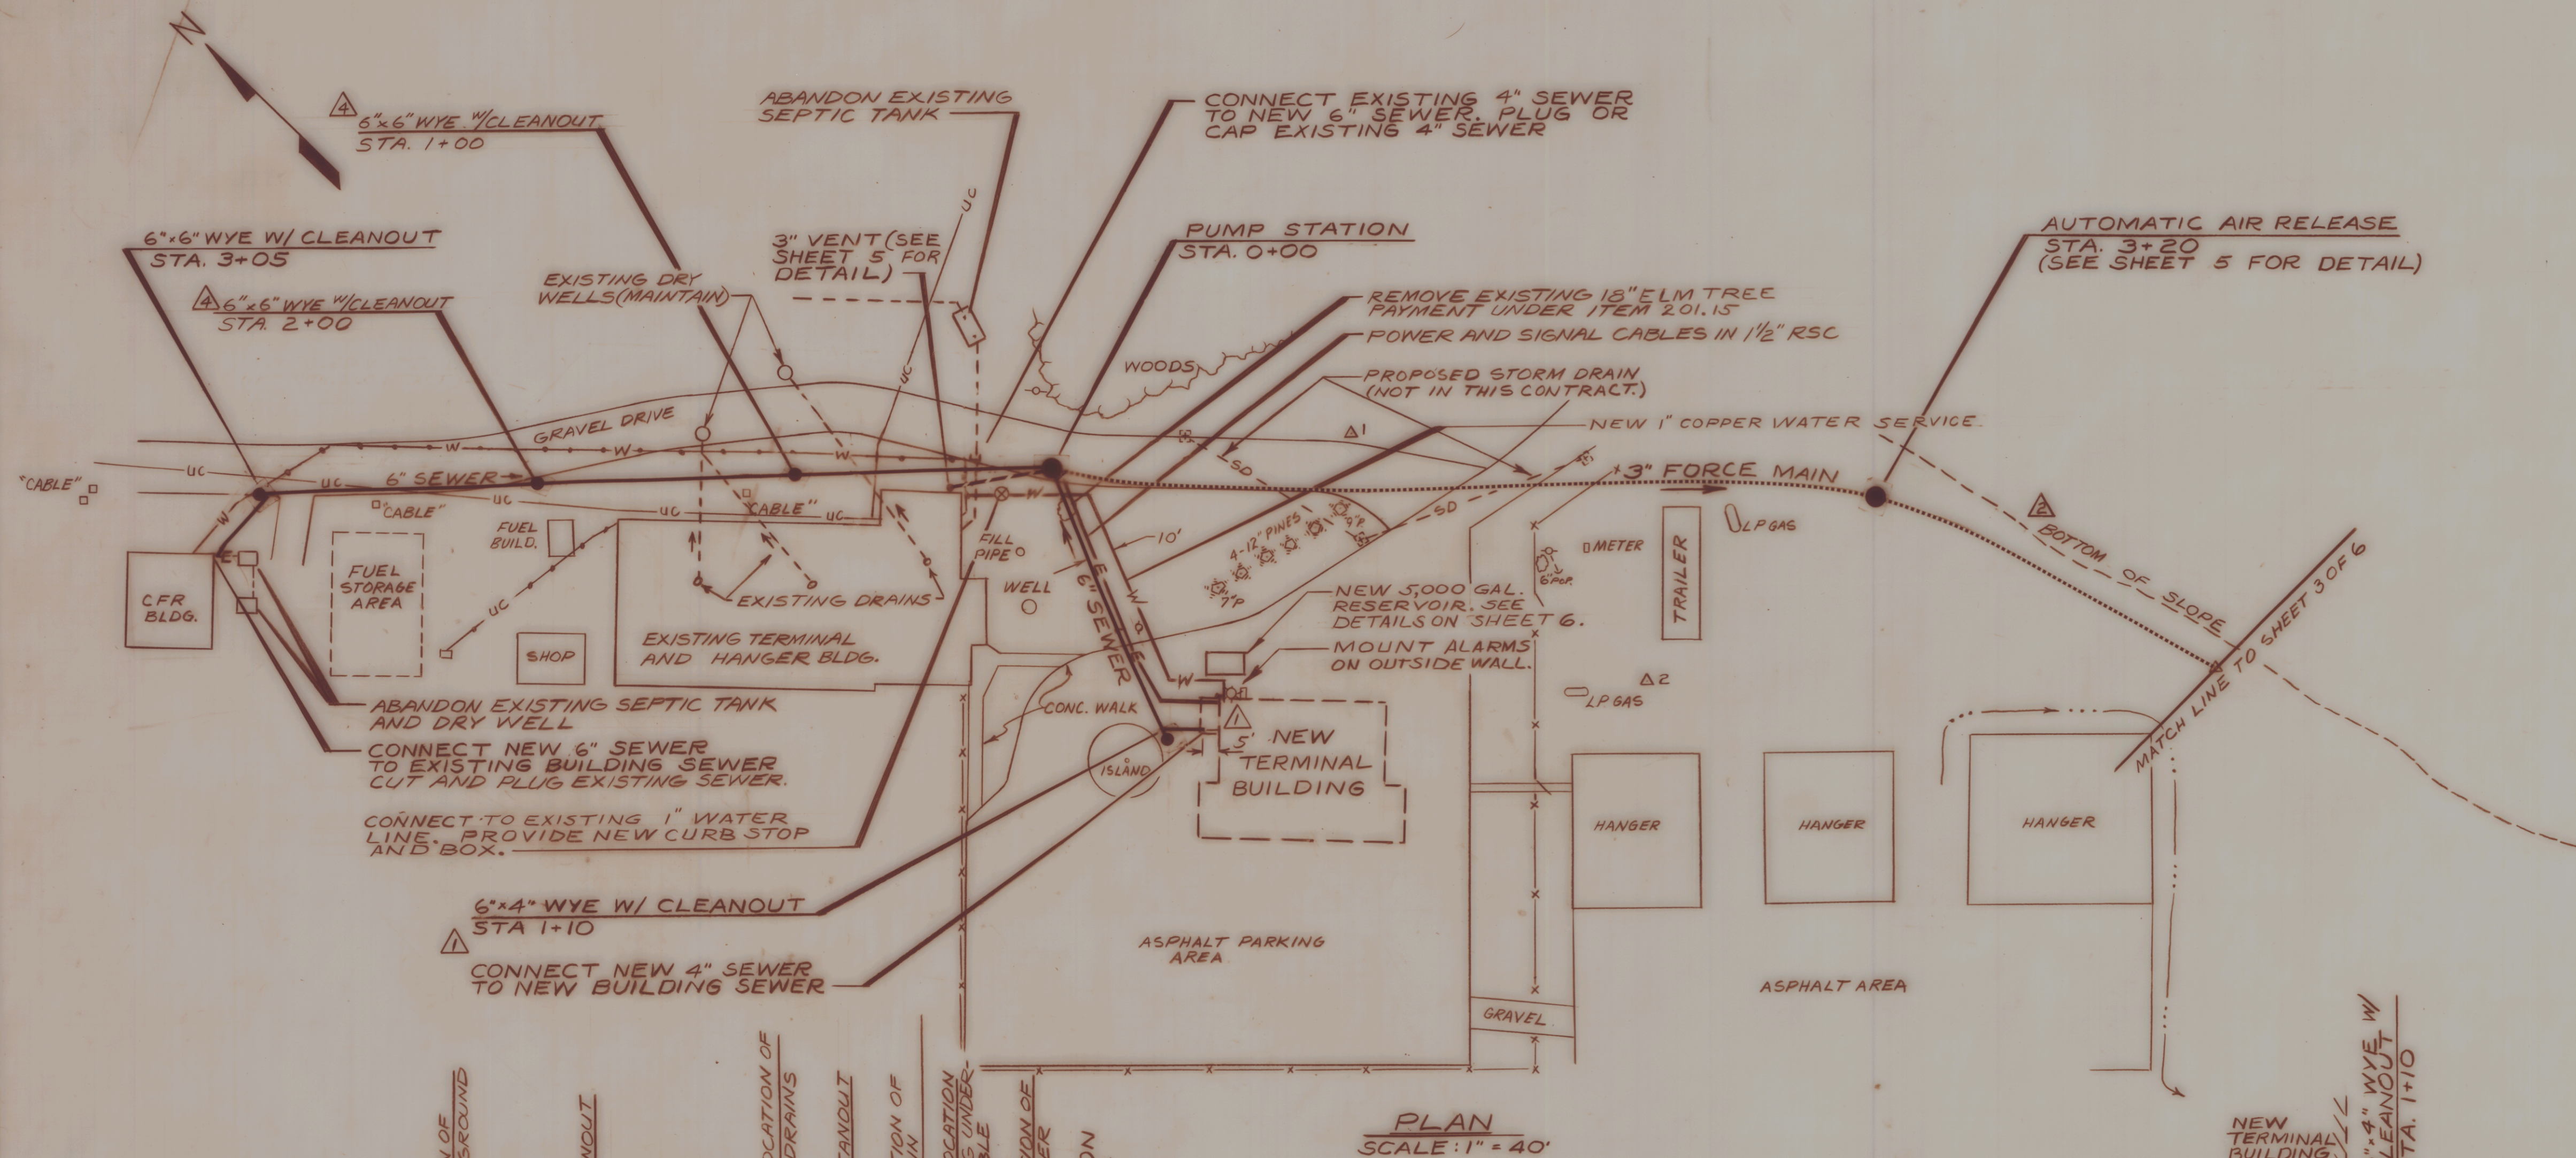

- LEGEND**
- FORCE MAIN SEWER
 - GRAVITY SEWER
 - W— EXISTING WATER LINE
 - SD— EXISTING STORM DRAIN
 - UC— UNDERGROUND CABLE

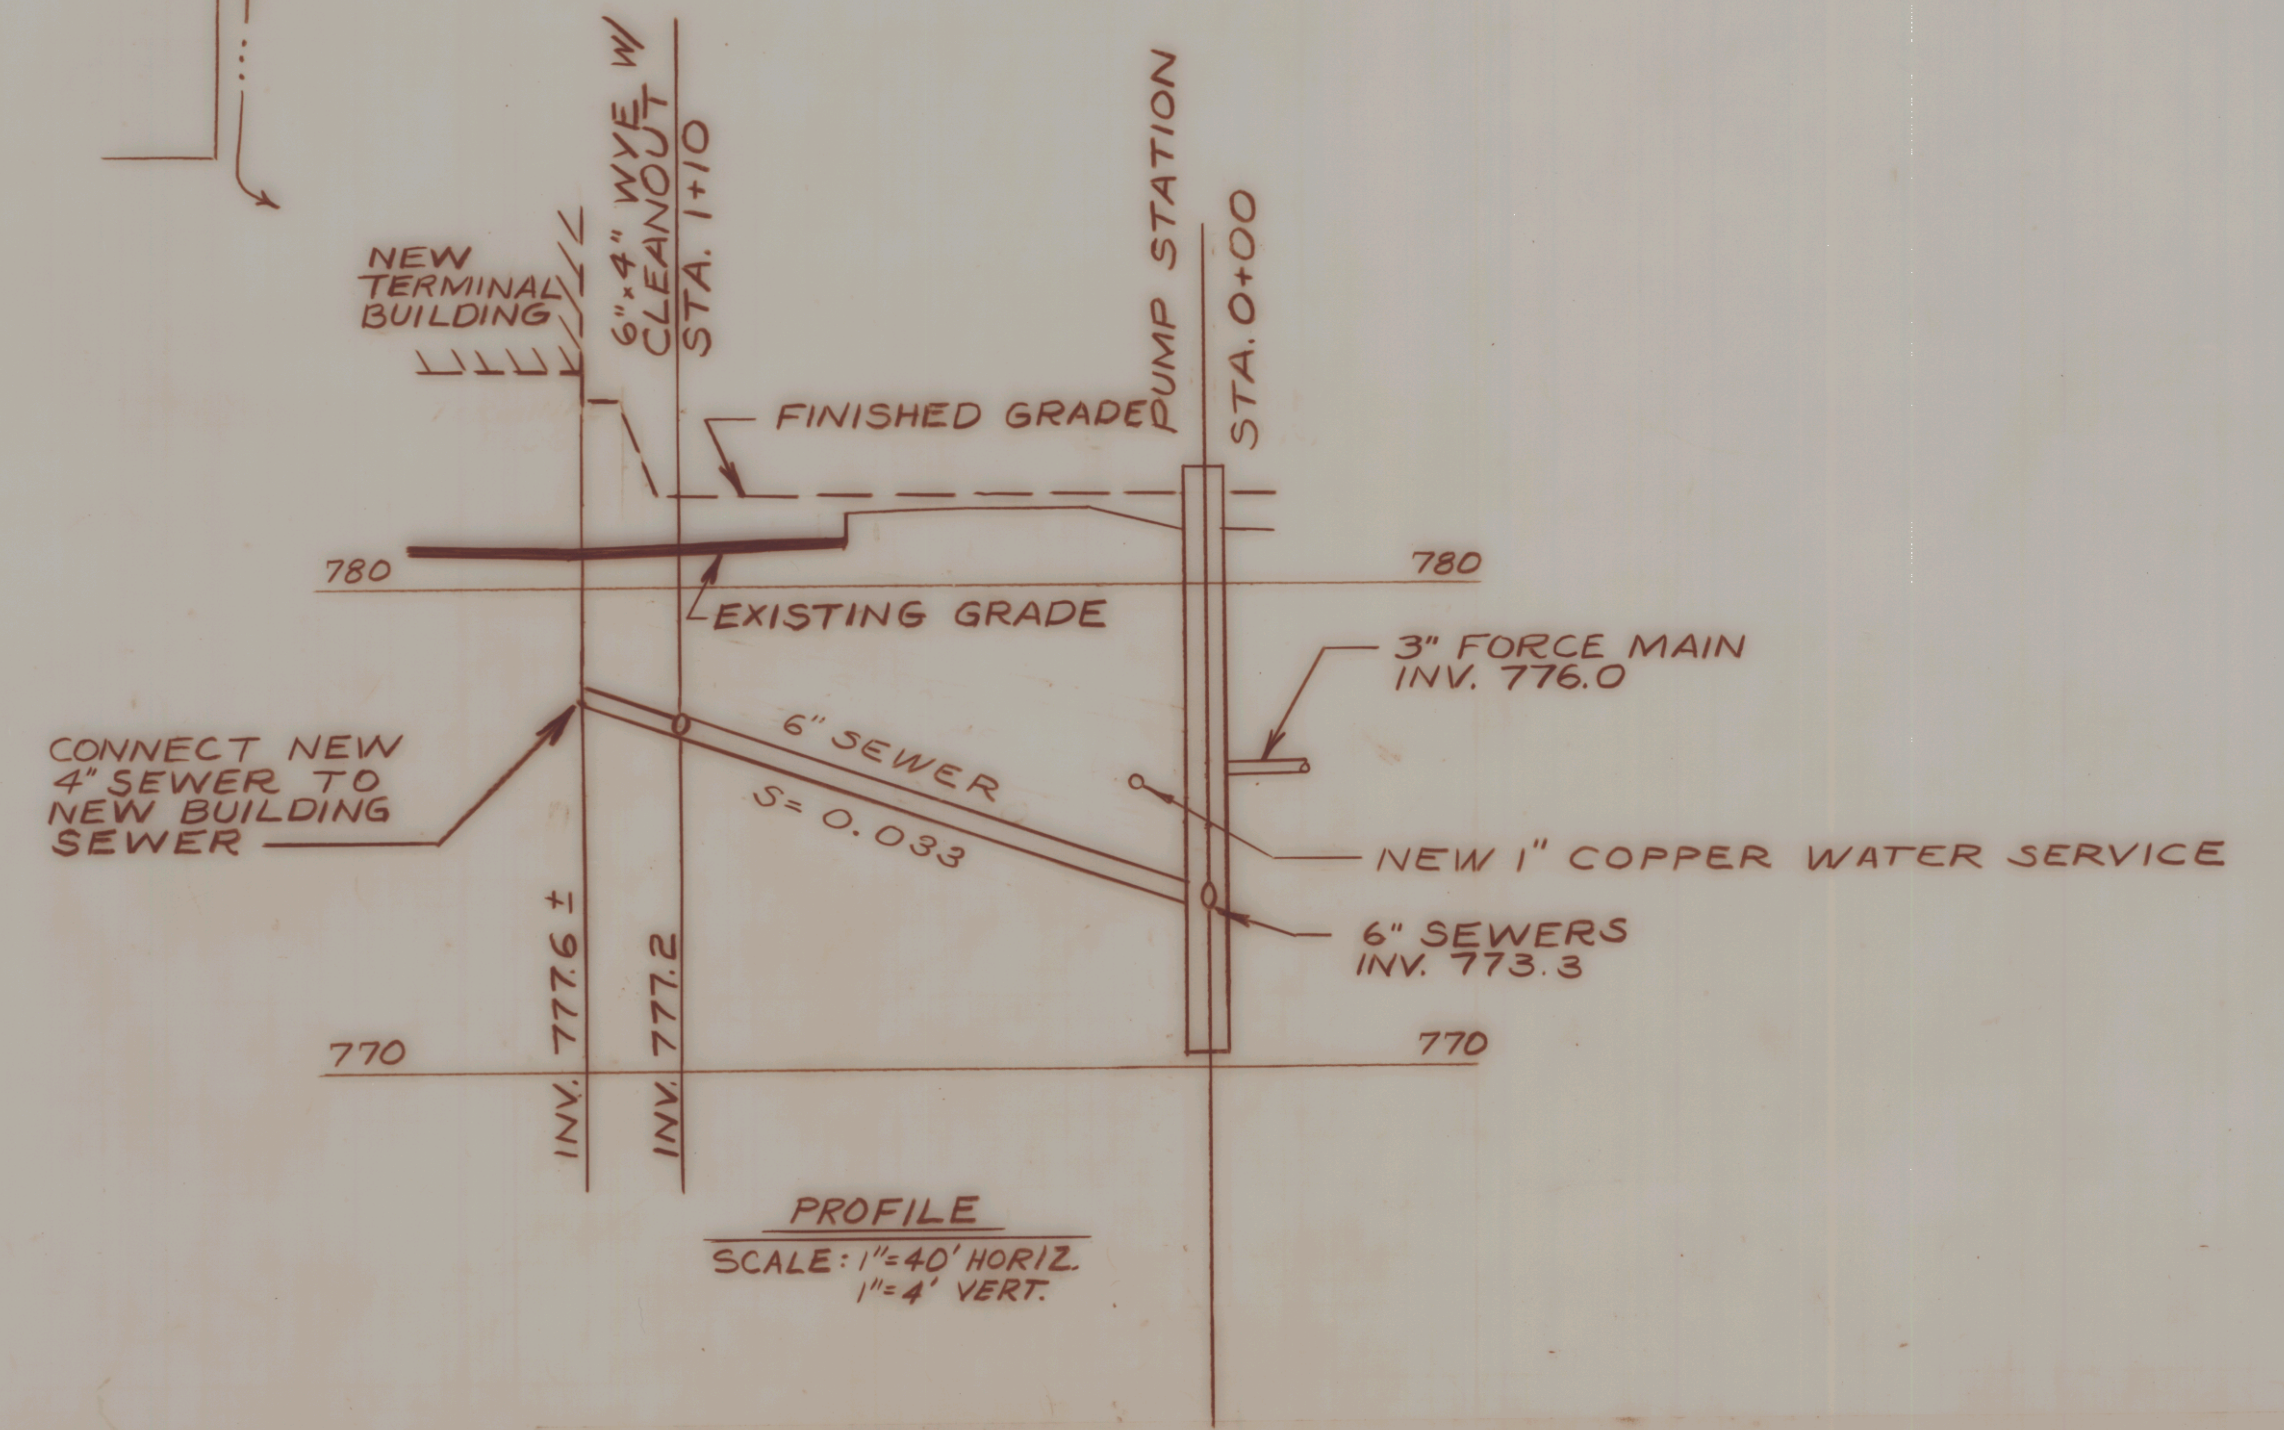

NO.	DATE	REVISIONS	BY	CK'D
1	11/1/85	ADDED CLEANOUTS	JH/ESL	
2	12/5/84	ADDED LEGEND	SJT/ESL	
3	11/21/84	REMOVED CLEANOUT	RFO/ESL	
4	10/2/84	MISCELLANEOUS REVISIONS	JH/ESL	

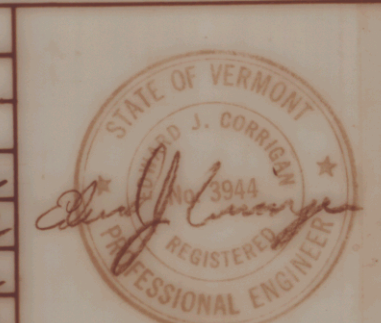

DuBois & King Inc.
 engineering planning management development

STATE OF VERMONT
 AGENCY OF TRANSPORTATION
 RUTLAND STATE AIRPORT
AIR 03-2034
 SEWER
 PLAN AND PROFILE

DRAWN BY	ECS/AFO	DATE	6/21/84
CHECKED BY	JH/ESL	PROJ. NO.	45803
PROJ. ENG.	ESL	DRAW. NO.	5354
SHEET 2 OF 6			