
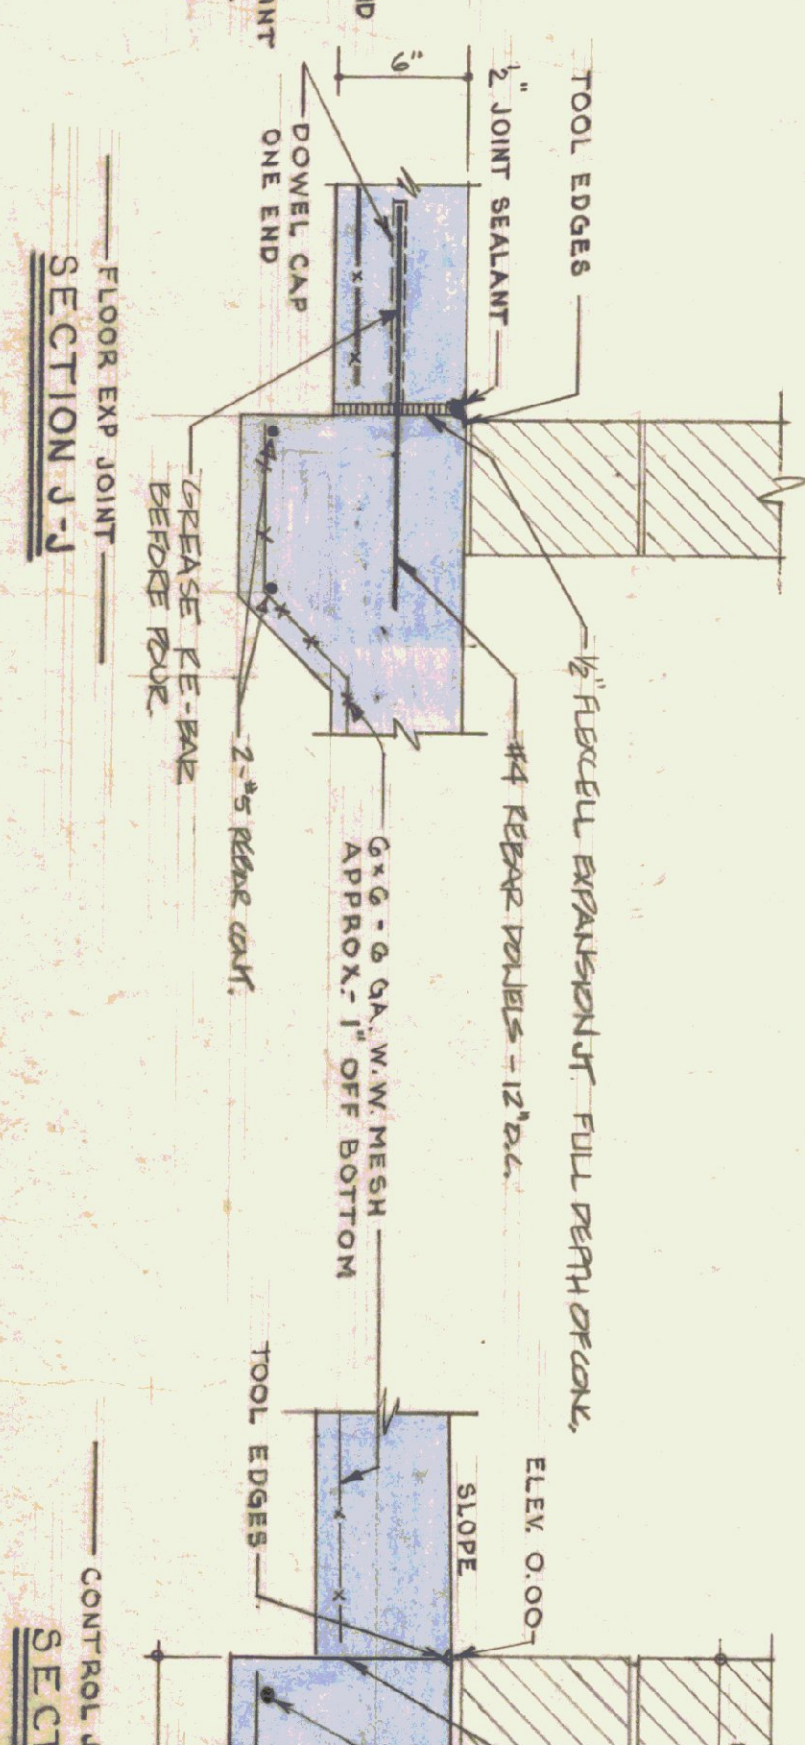
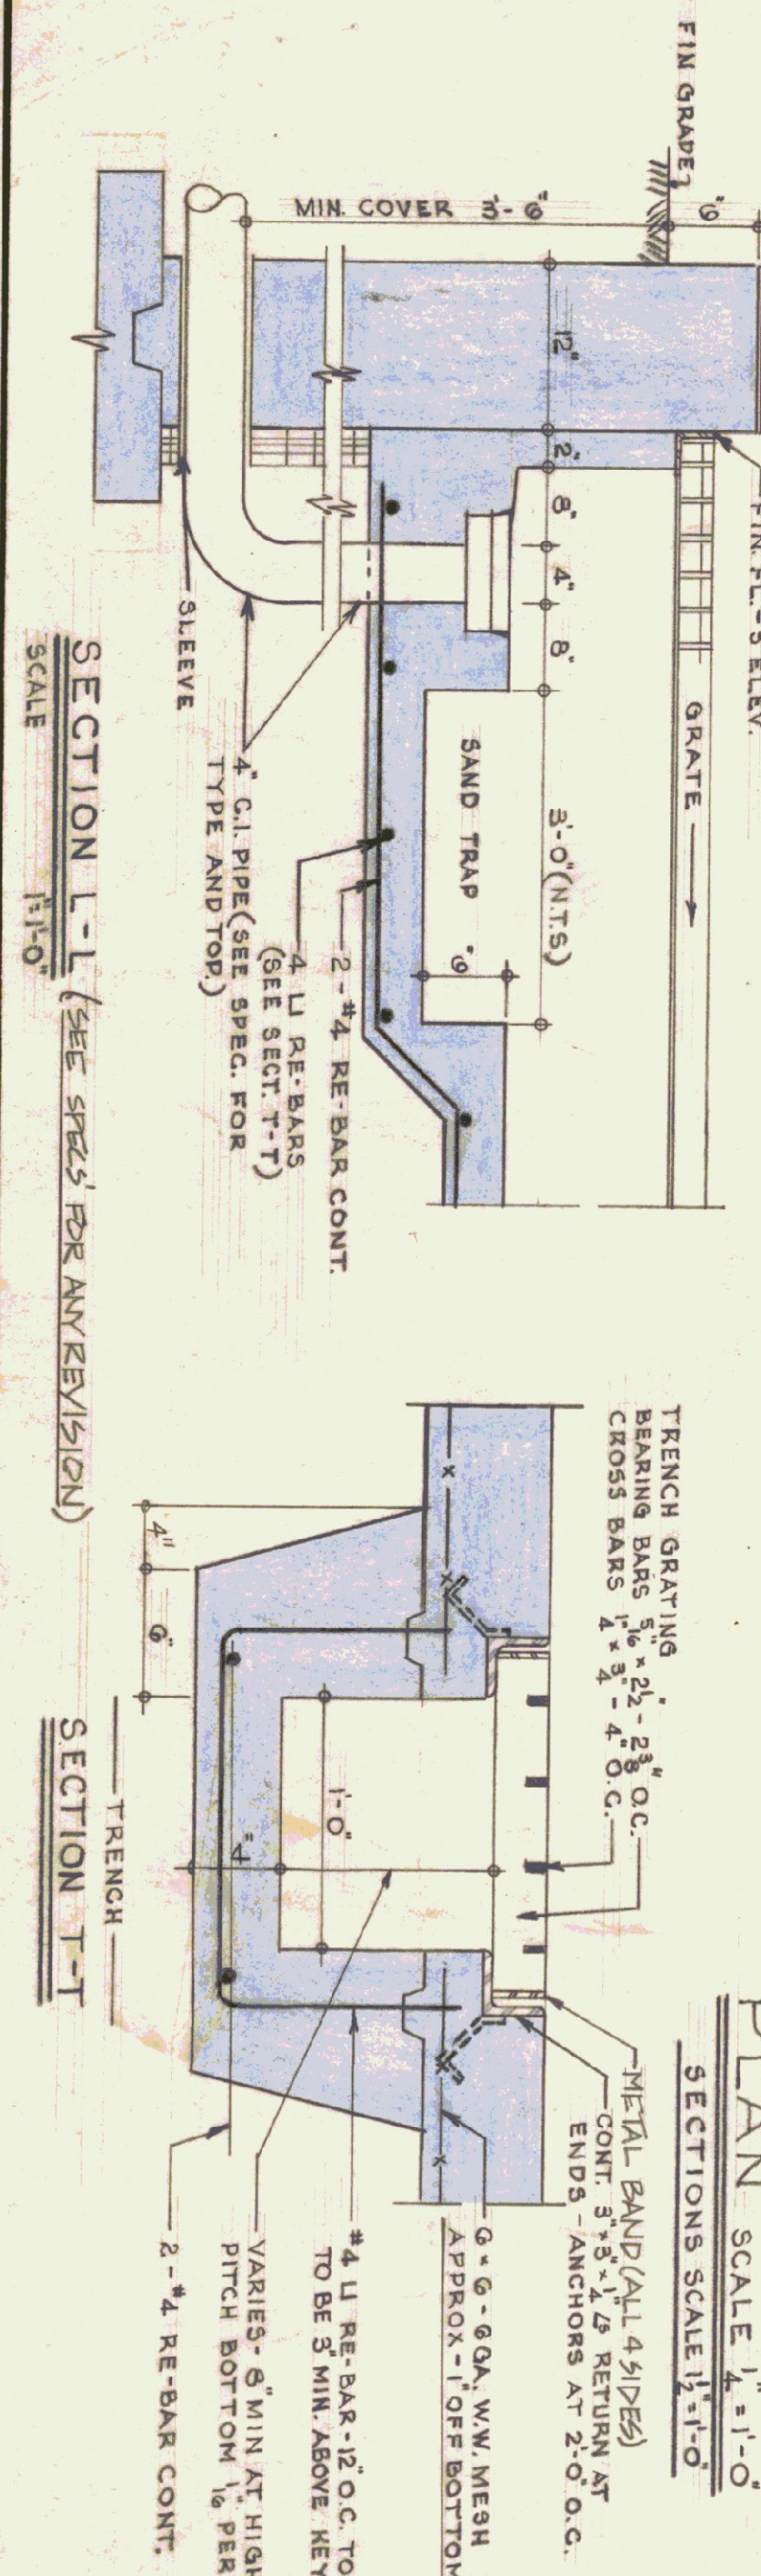
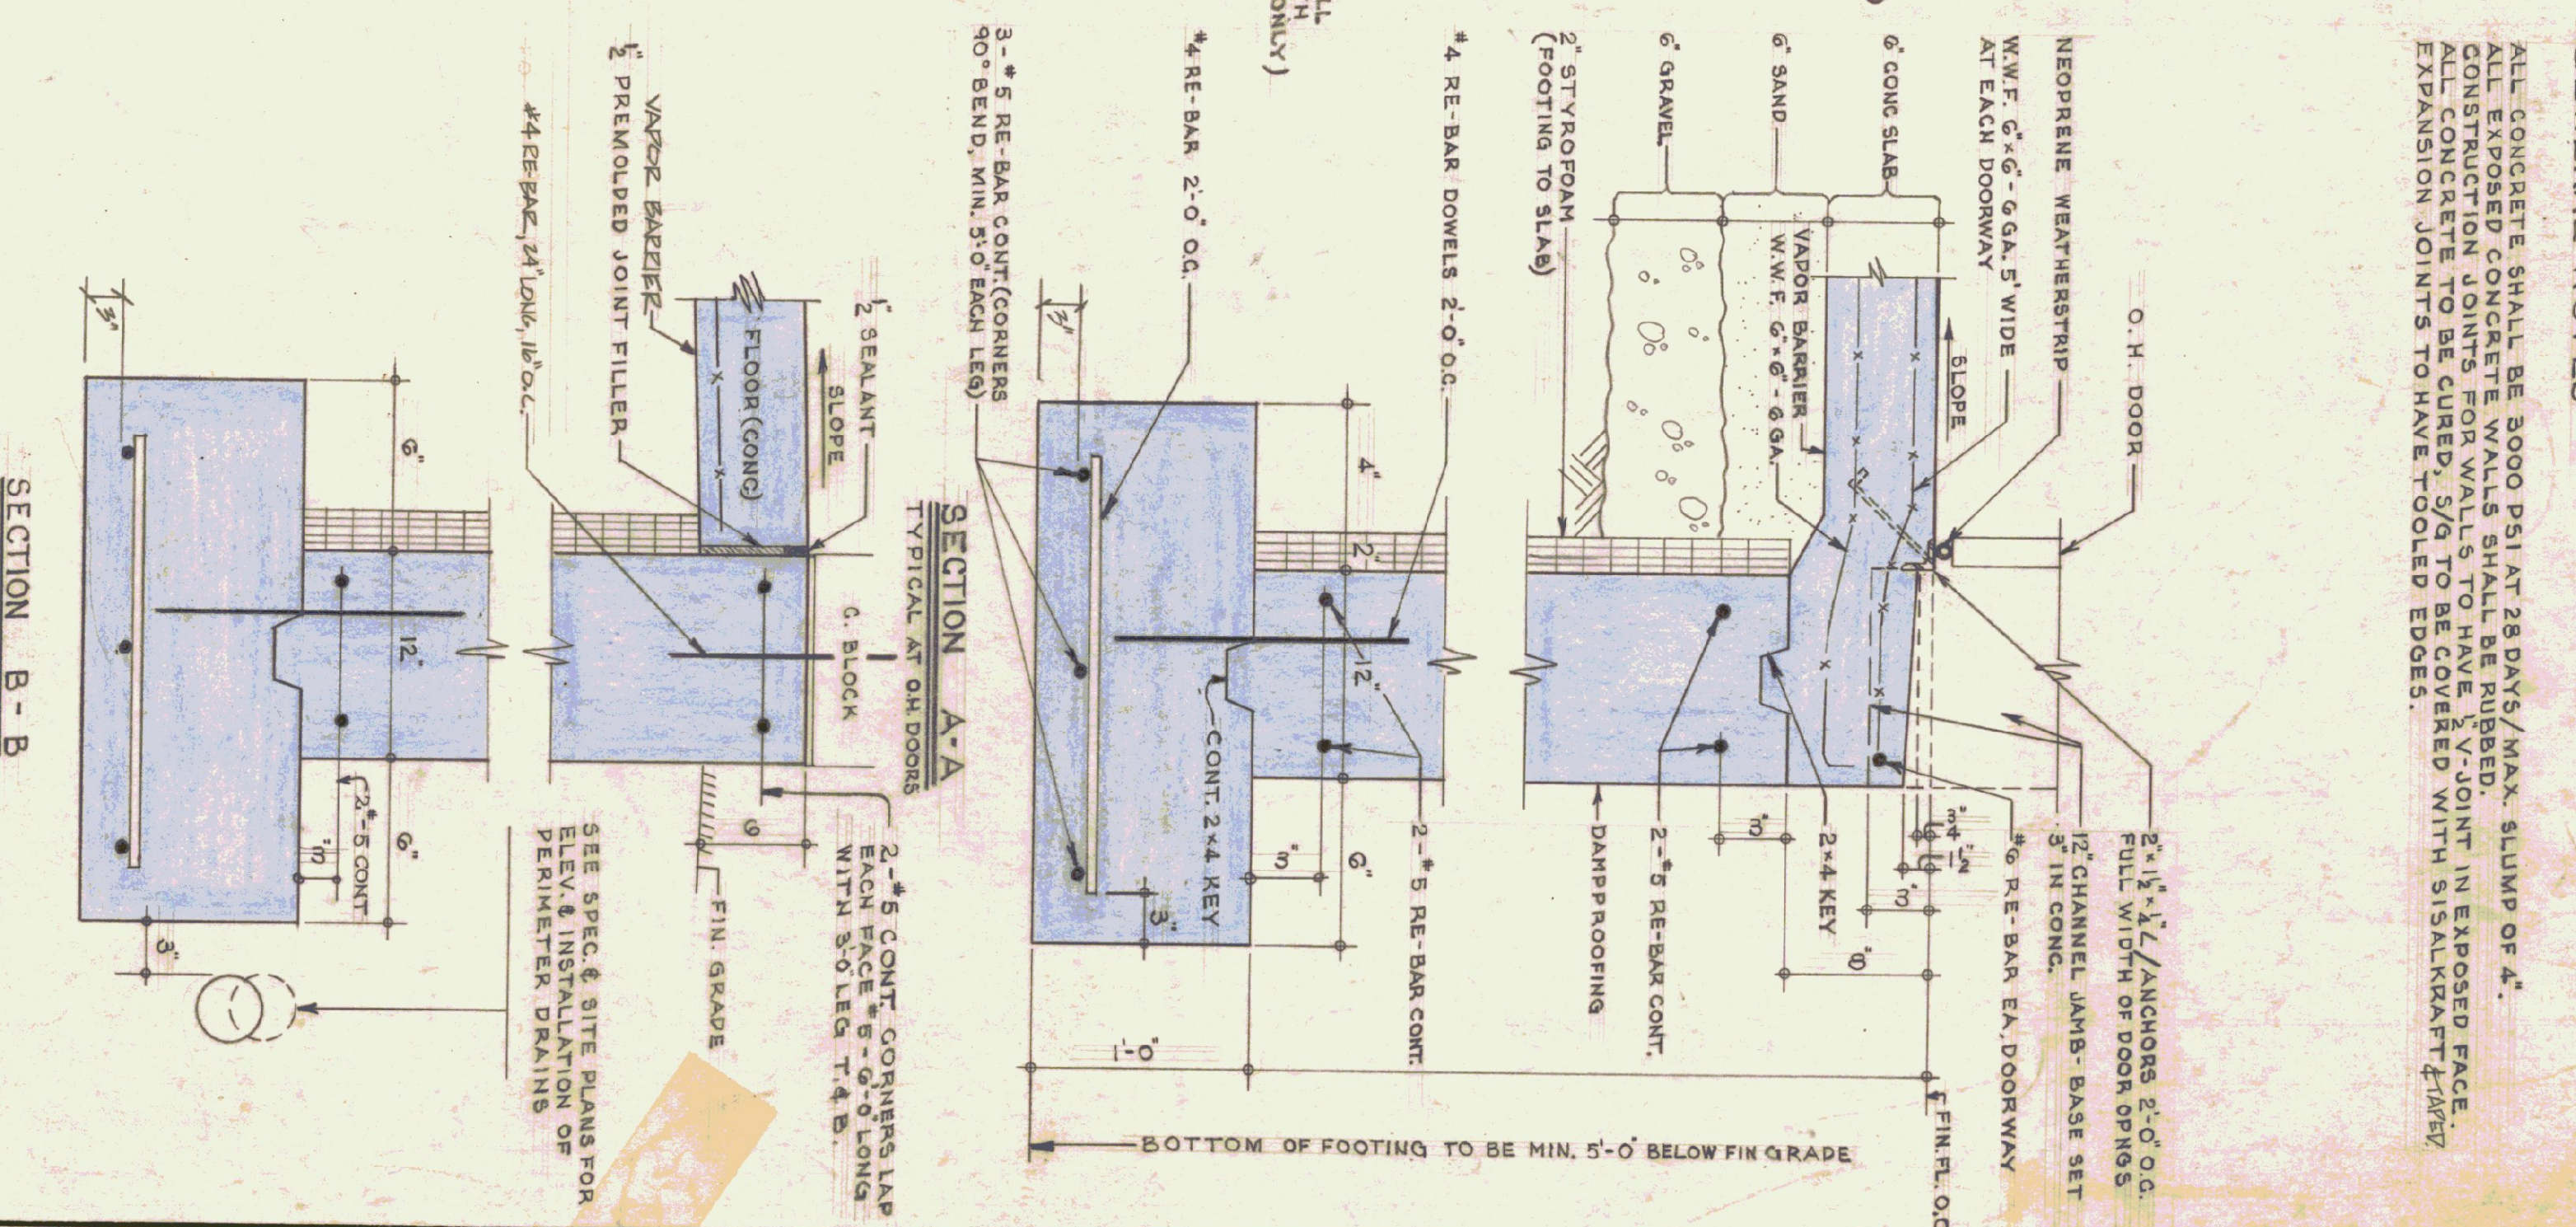


GENERAL NOTES

ALL CONCRETE SHALL BE 3000 PSI AT 28 DAYS/MAX. SLUMP OF 4".
ALL EXPOSED CONCRETE WALLS SHALL BE REINFORCED WITH 2" X 12" JOINTS IN EXPOSED FACE.
ALL CONCRETE TO BE CURED 5/8" TO BE COVERED WITH SIALKRAFT 4105/57.
EXPANSION JOINTS TO HAVE TOoled EDGES.

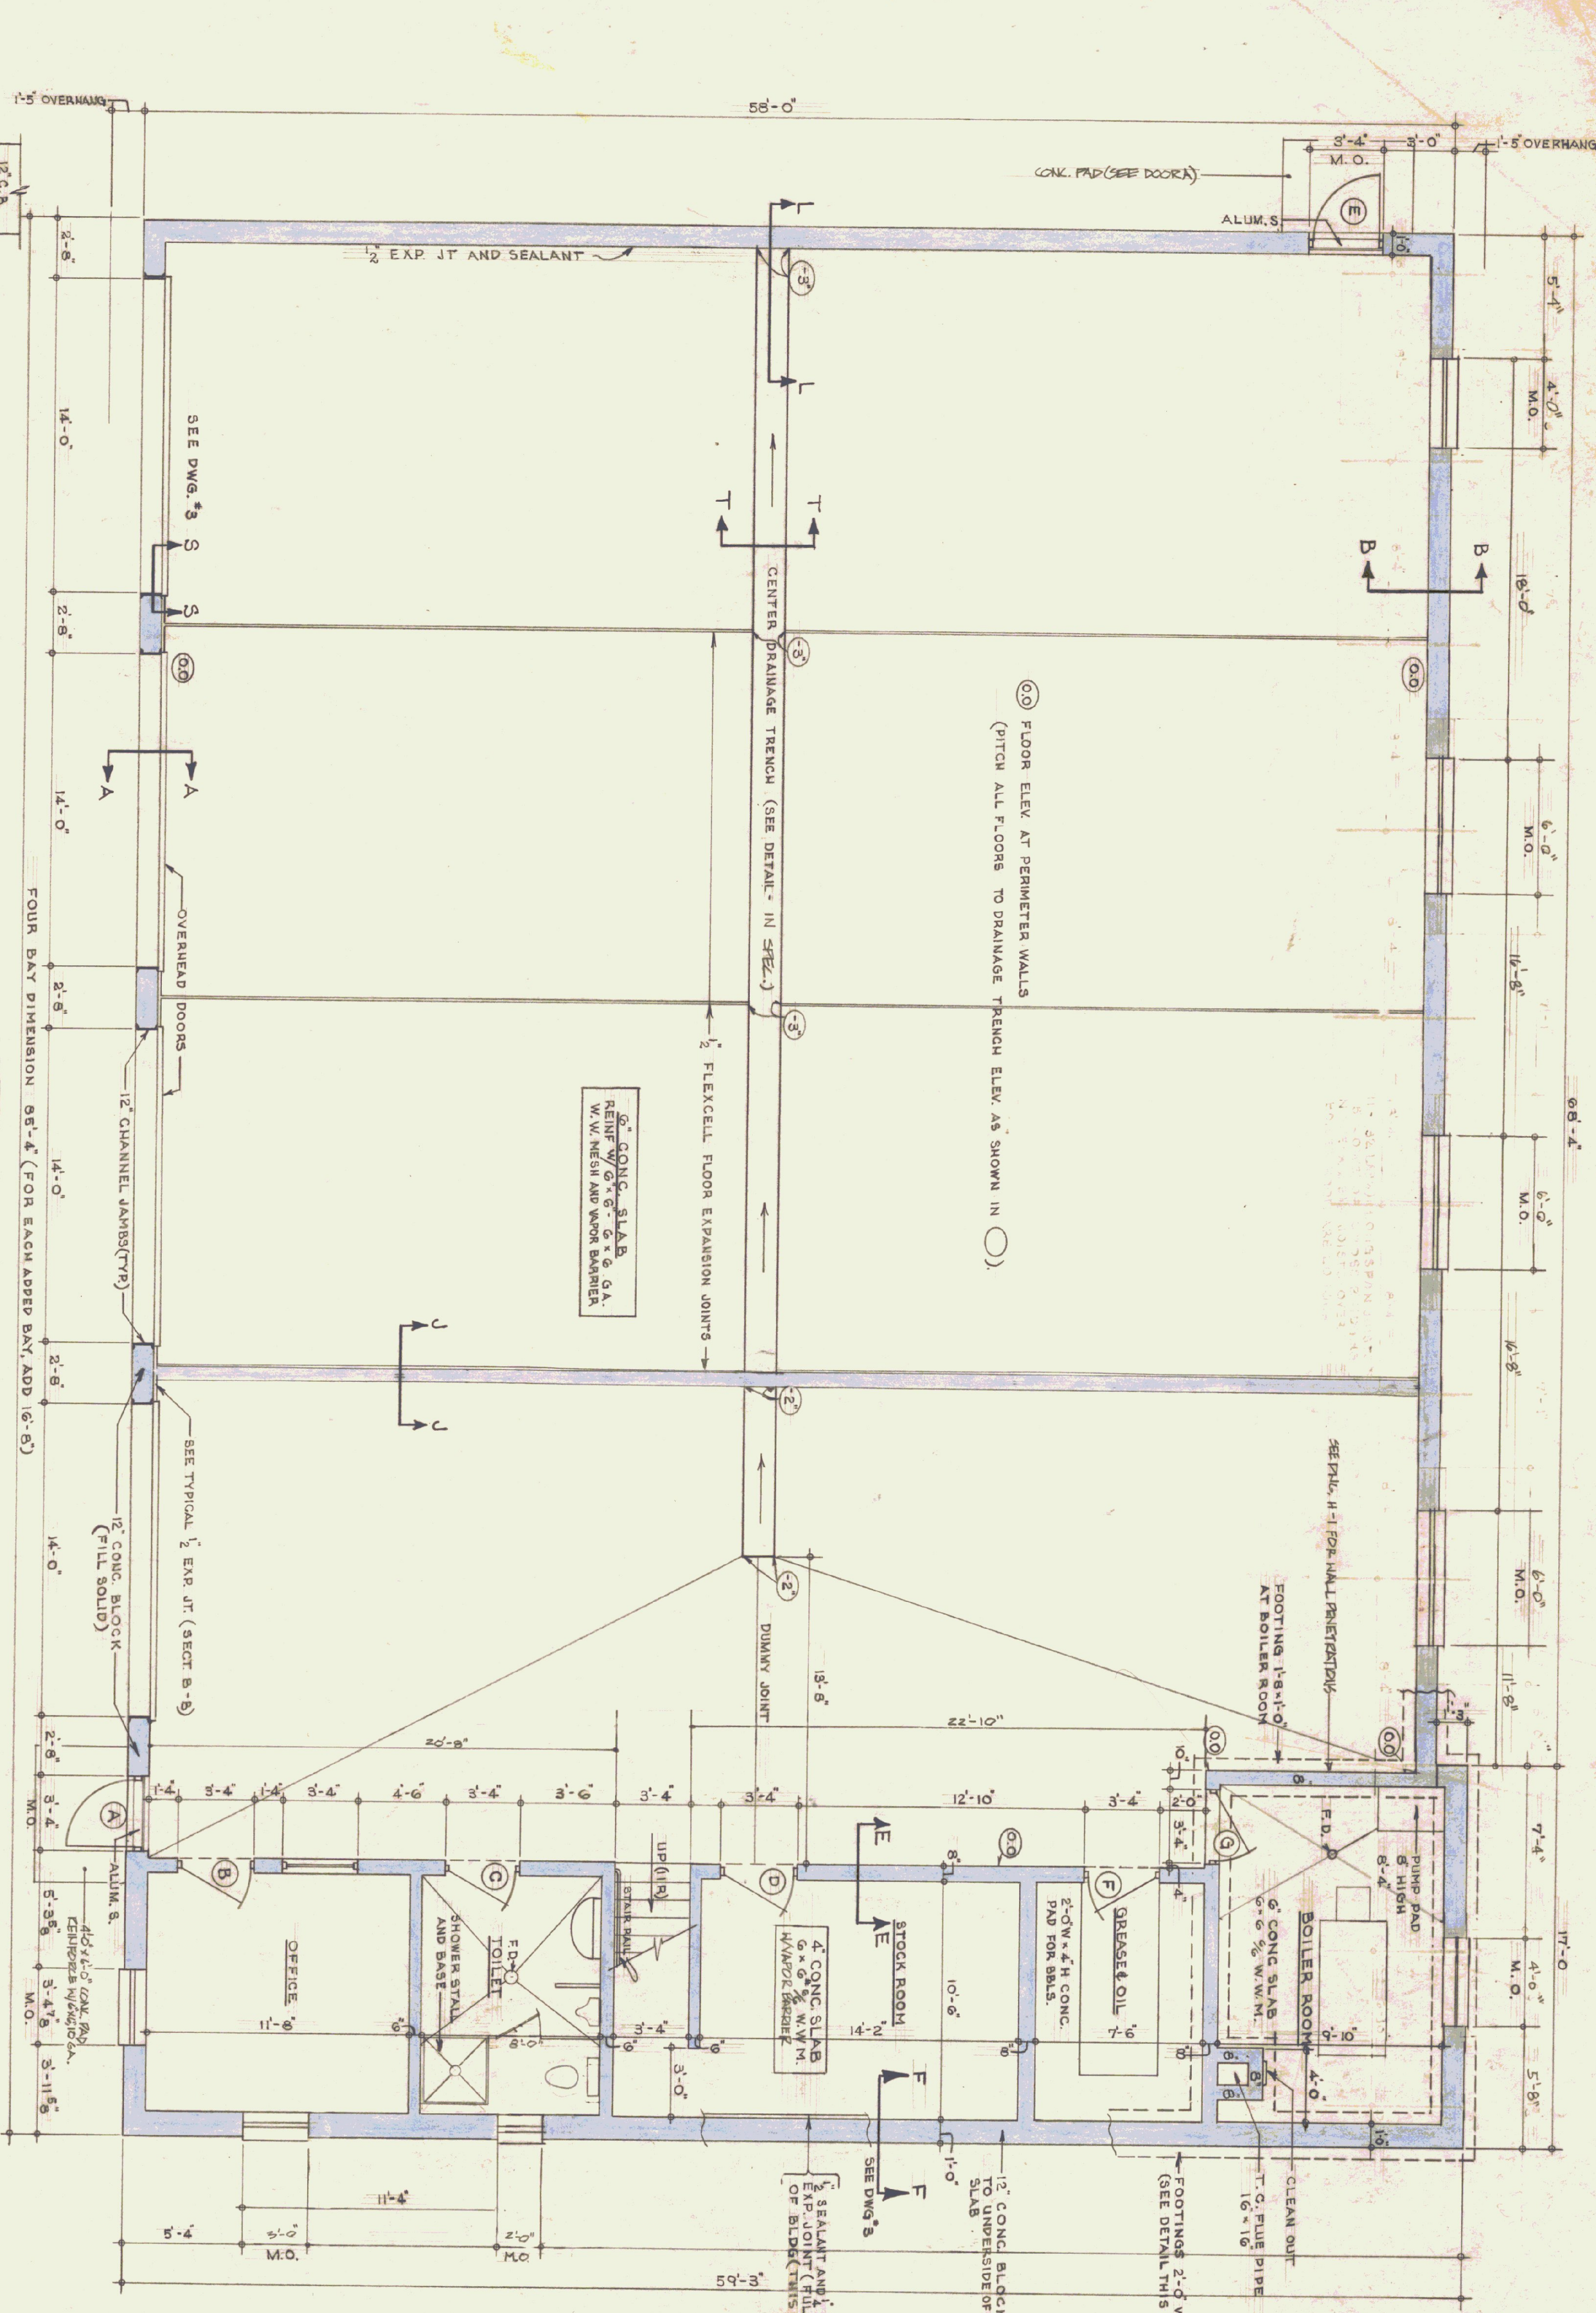

STATE OF VERMONT
DIVISION OF STATE BUILDINGS
AGENCY OF ADMINISTRATION
VERMONT

Standard Four Bay Highway Garage Bldg.
FLOOR PLAN & FOUNDATION DETAILS


SCALE: As noted

REVISIONS	DATE	BY	REVISION
1	10-18-74	DESIGNED BY: [Signature]	
2		DRAWN BY: [Signature]	
3		APPROVED BY: [Signature]	
4		STUDIO SEEN INC.	


DWG. NO. A1

GENERAL NOTES


FINISH GRADE SHALL BE MIN. OF 6" BELOW FINISH FLOOR - AT BLDG OR RIGHT, LEFT & REAR ELEVATIONS, TO BE SLOPED AWAY FROM BLDG AND GRADED IN A WORKMAN LIKE TO PROHIBIT WATER POCKETS OR EXCESSIVE WASHING ALL EXPOSED CONCRETE SHALL BE RUBBED TO 4" BELOW FINISH GRADE. BUILD UNDER CONSTRUCTION JOINTS SHALL HAVE A V-GROOVE TO 4" BELOW FIN. GRADE. CAULK ALL JOINTS BETWEEN WORKMAN AND WOOD OR METAL.

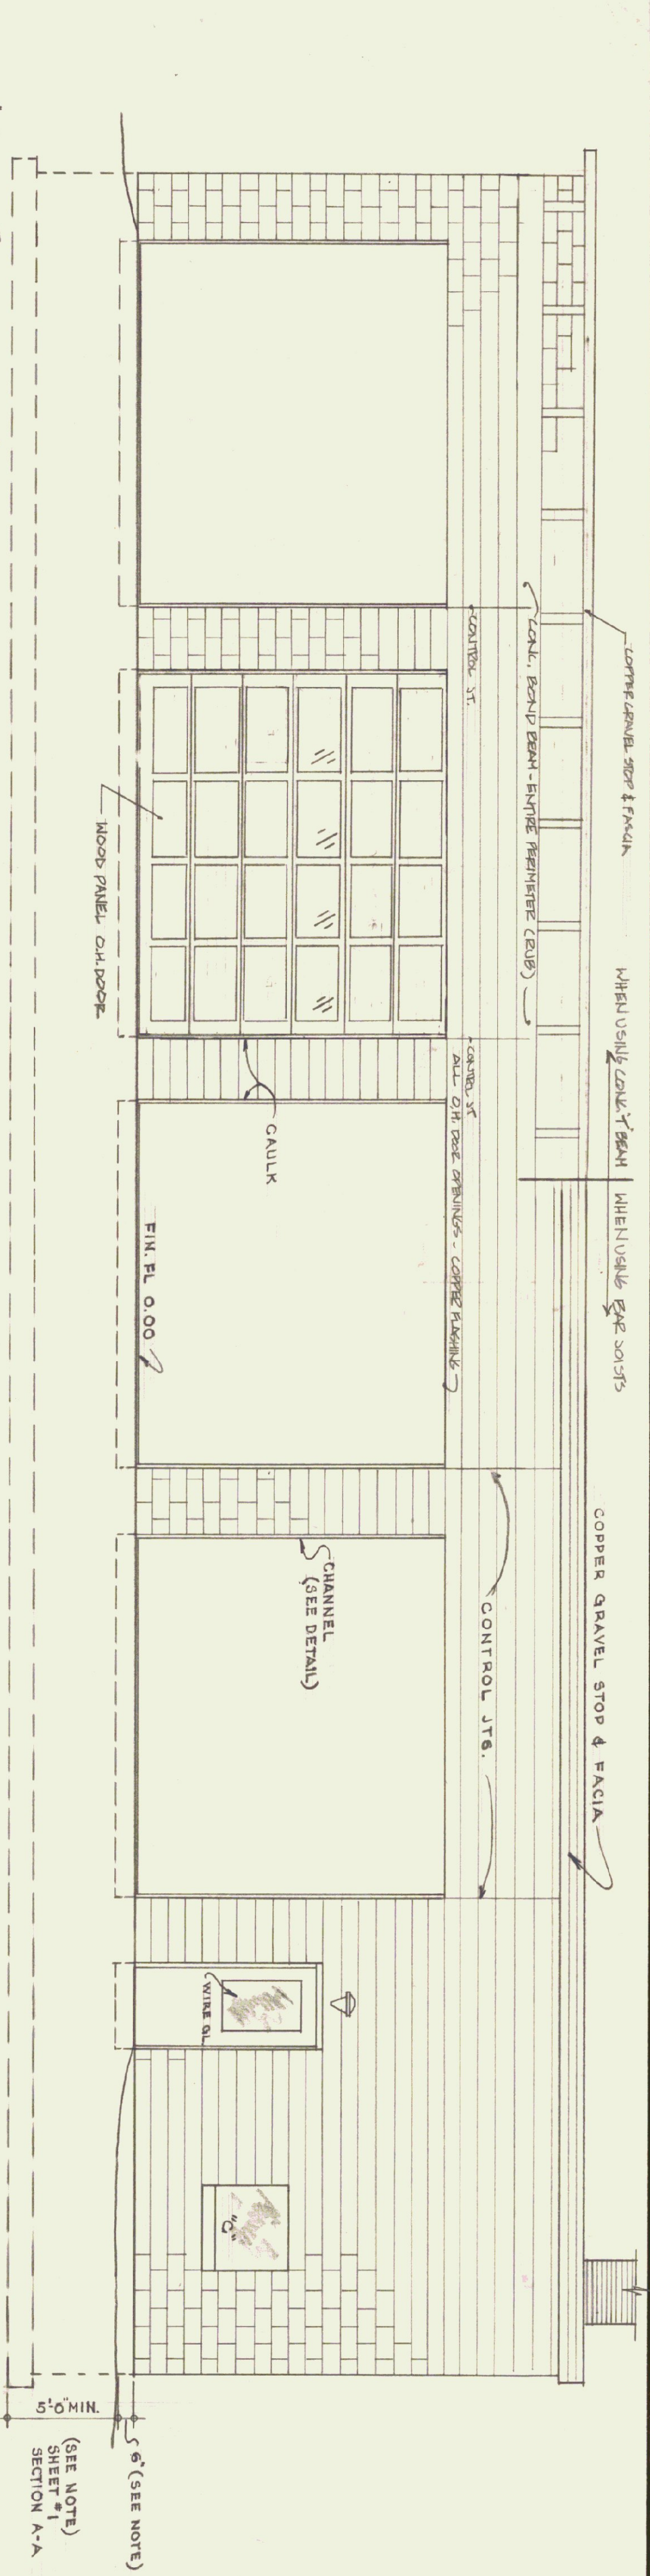


FRONT ELEVATION

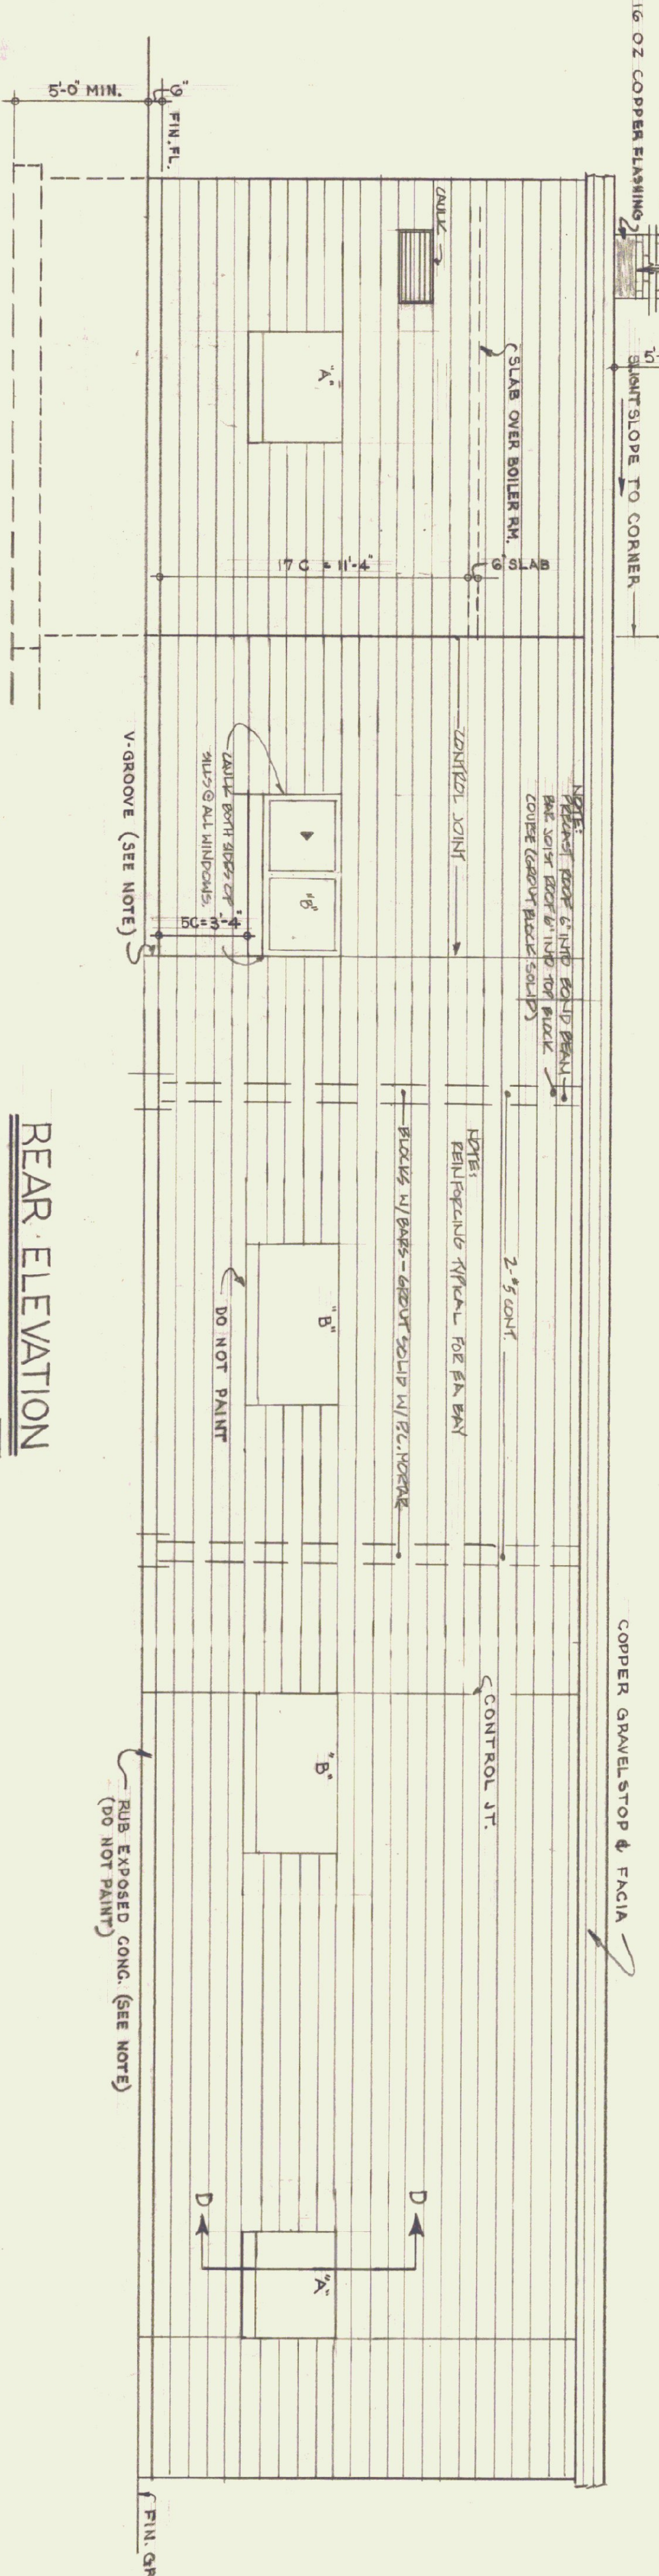


REAR ELEVATION

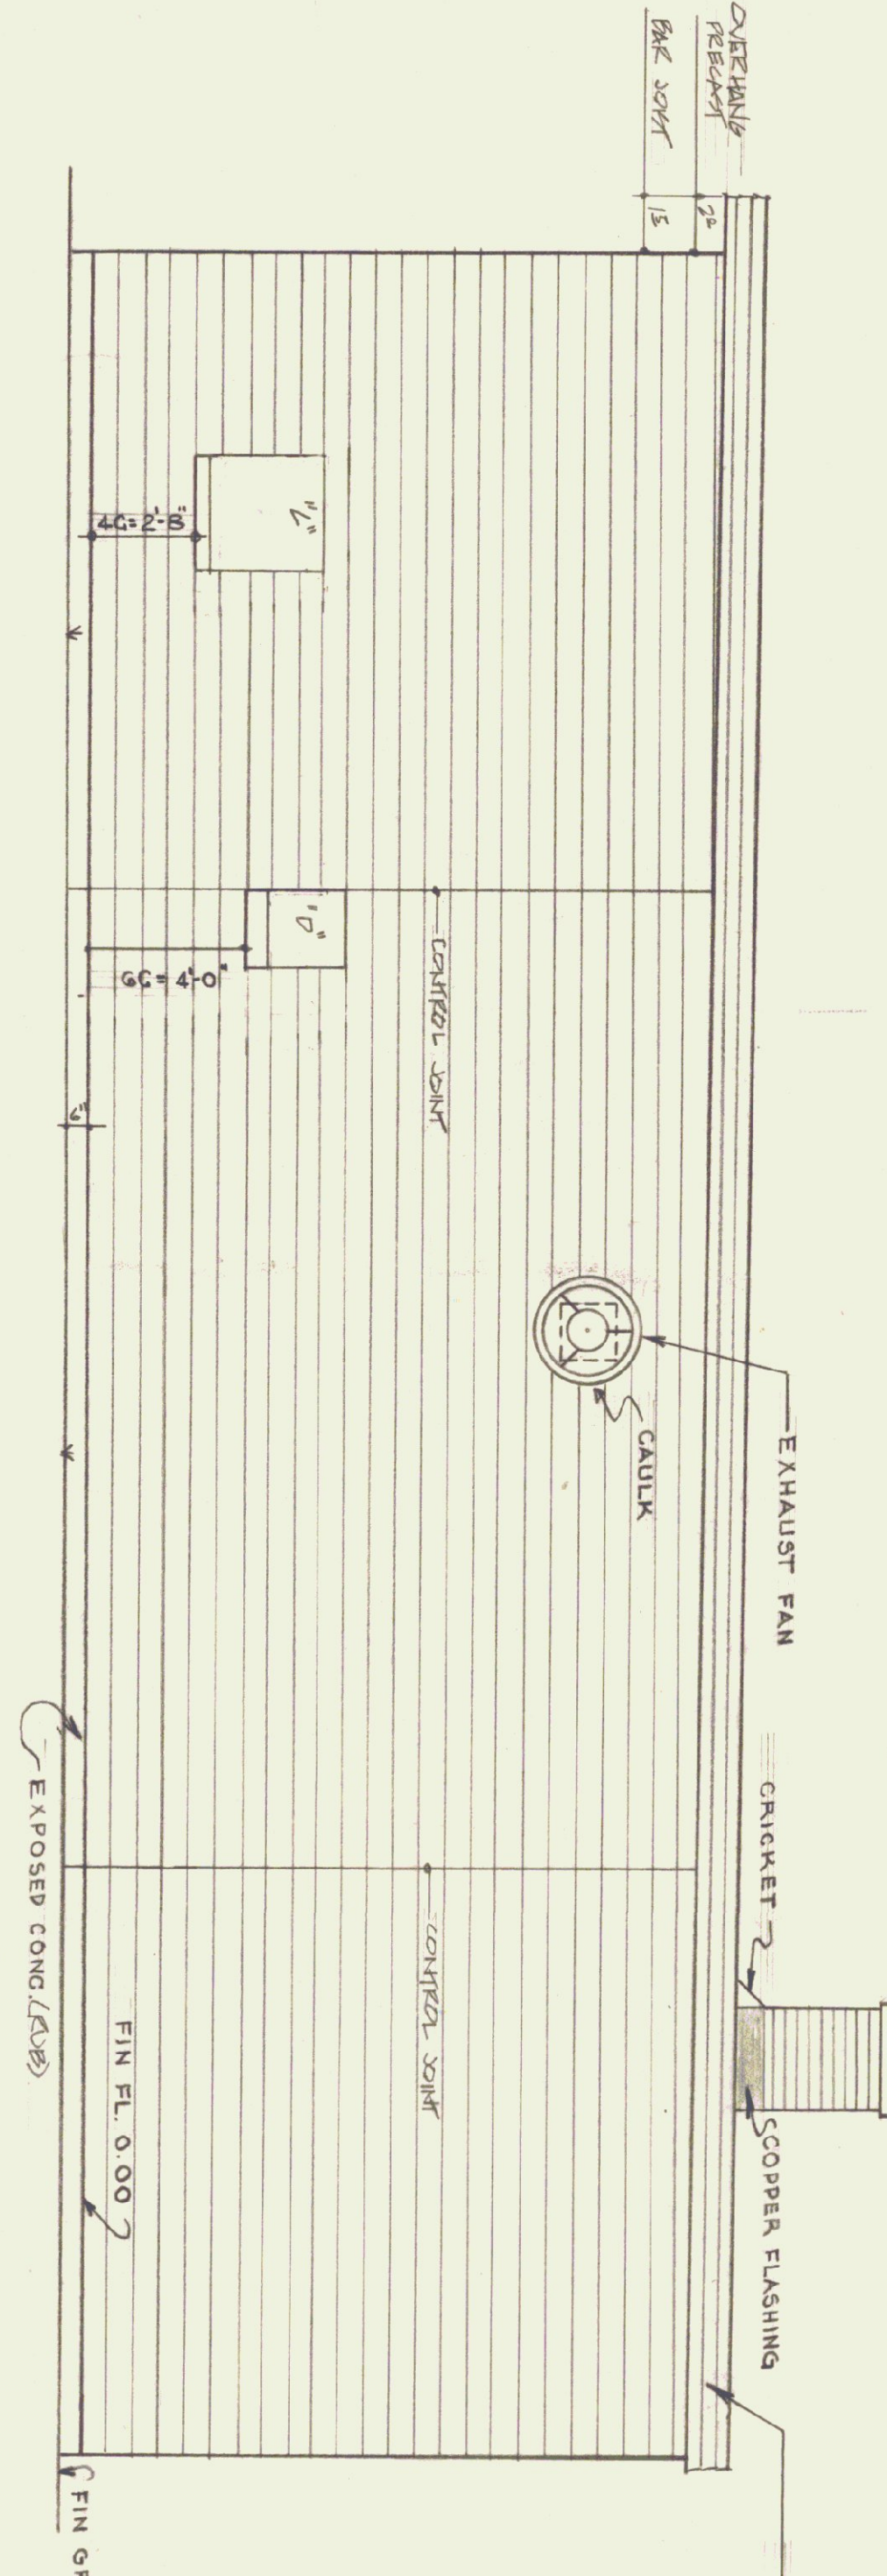


RIGHT END ELEVATION

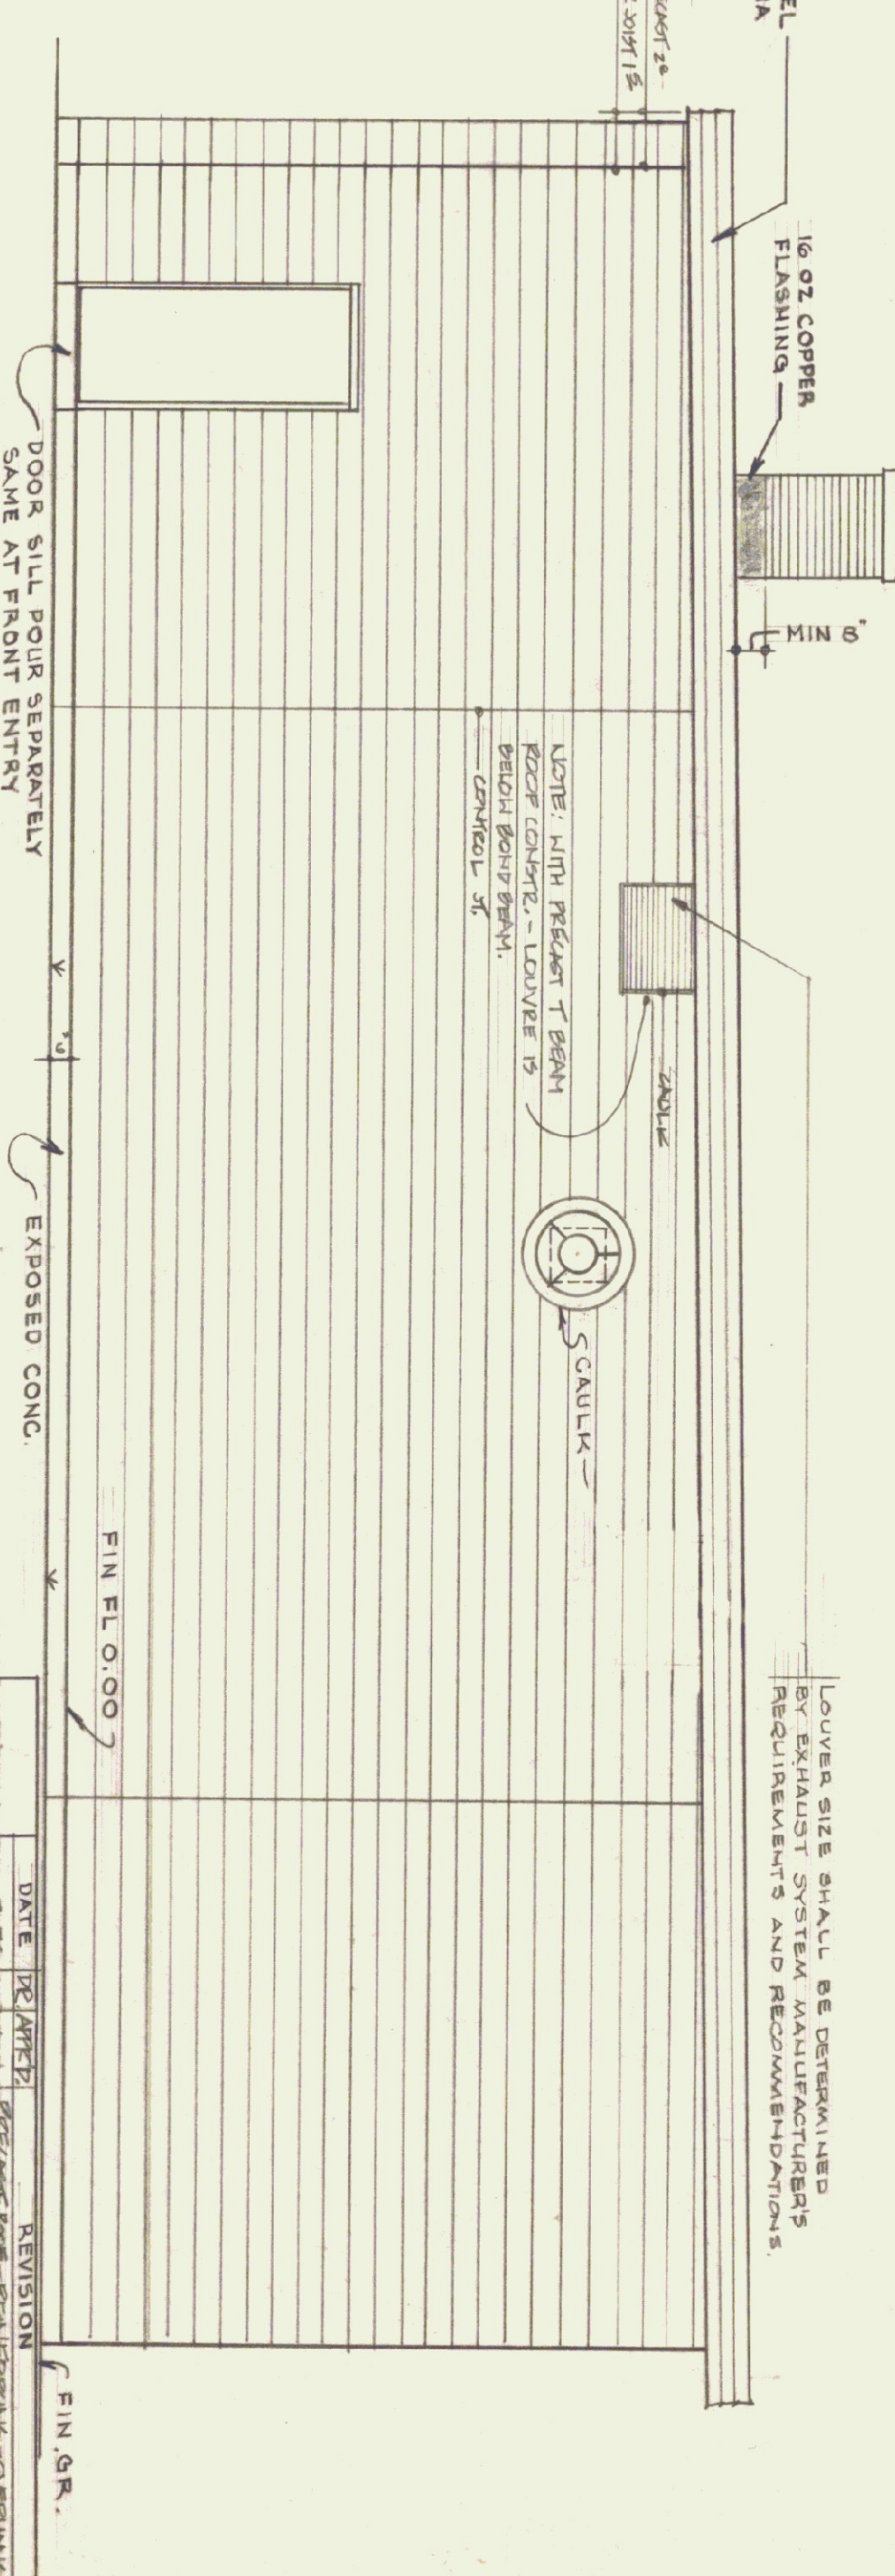

LEFT END ELEVATION

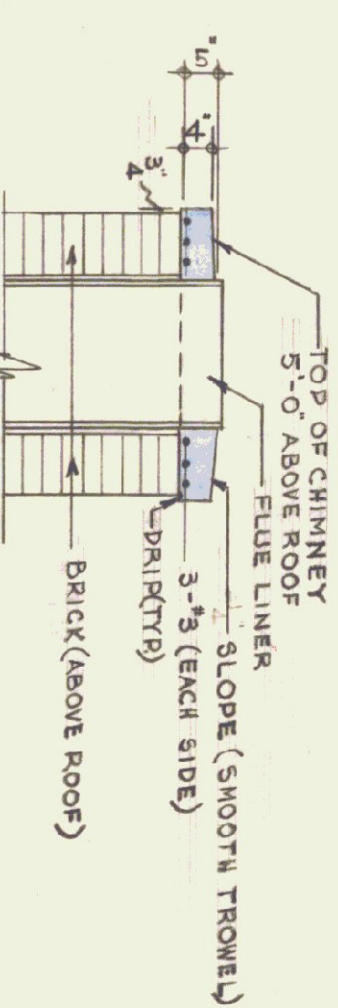

CHIMNEY CAP DETAIL

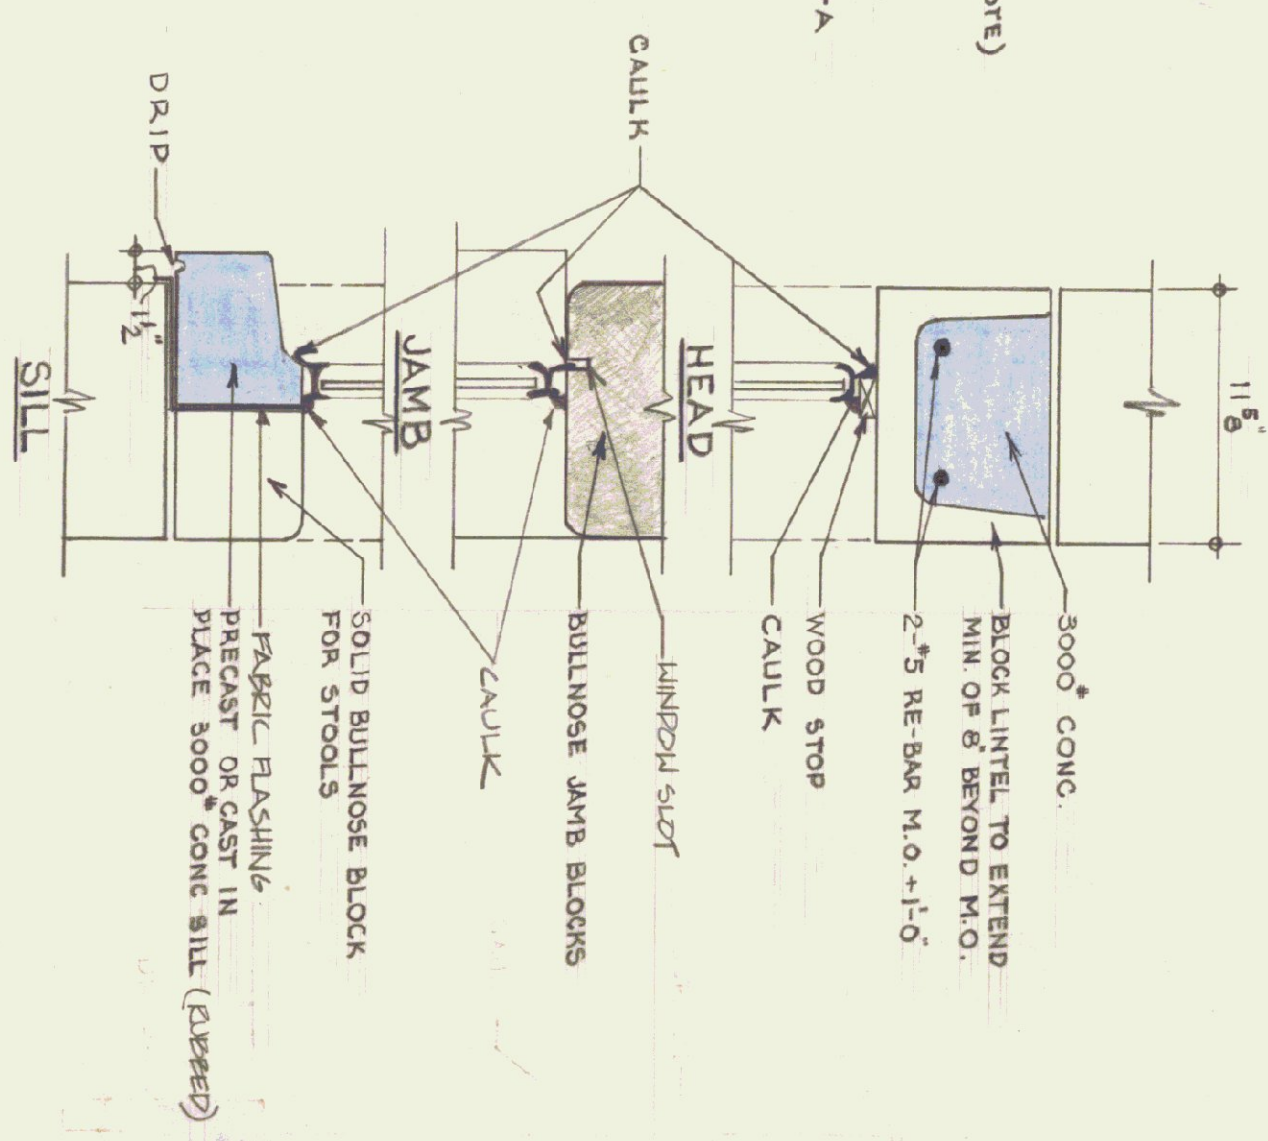

SECTION D-D
SUBMIT SHOP DRAWINGS
AT ALL 'A', 'C' & 'D' WINDOWS
FOR WINDOW INSTALLATION.

SECTION SCALE 1/2" = 1'-0"

REVISIONS	DATE	BY	REVISION
1	7-5-76	JK	REVISIONS - CORRECTIONS

STATE OF VERMONT
DIVISION OF STATE BUILDINGS
AGENCY OF ADMINISTRATION
MONTPELIER, VERMONT

Standard Four Bay Highway Garage Bldg.
ELEVATIONS

SCALE: As Noted

DATE: 10-18-74	DESIGNED BY: [Signature]	DWG. NO. A2
DRAWN BY: [Signature]	APPROVED BY: [Signature]	OF [Blank]
STUDIO DESIGN INC.		

Floor plan of the Dutch House. The plan shows a large central hall with a fireplace, a kitchen, a dining room, and a living room. The plan is labeled "DUTCH HOUSE" and "DUTCH DOOR".

1" Ø PIPE
HANDRAIL
D. FOUNTAIN

1" V. DUMPTY
JOINT

26" x 36"
WIRE
GLASS

1" POL
PLATE
GLASS

1" C.B.

DO NOT SCALE

1
2
3
840
84

— BULLNOSE BLOCK —

- BULLNOSE BLOCH

Diagram illustrating the construction of a sill plate using a solid bulldozer block for the sill.

The diagram shows two cross-sections of a foundation wall and sill plate assembly.

Left Section:

- PRECAST OR CAST IN PLACE SILL:** Indicated by a blue hatched area.
- SOLID BULLDOSE BLOCK FOR SILL:** Indicated by a white area below the sill.
- DIP:** Indicated by a small gap or notch at the bottom left corner of the sill plate.

Right Section:

- SOLID BULLDOSE BLOCK FOR SILL:** Indicated by a white area below the sill.

1 SEALANT & 2 PREMOLDED

FIN. GR. →

(THRU "B" WINDOWS)

(THRU OVERHEAD DOOR AREA)

CAULK ALL JOINTS BETWEEN MASONRY AND DISSIMILAR MATERIALS IN A WORKMAN LIKE MANNER, E.I. METAL WINDOW FRAMES.
ALL EXTERIOR DOORS SHALL HAVE NON REMOVABLE PIN HINGES
ROOF DESIGN LOAD: $LL = 50^{\#}/SQ. FT.$

NOTES: - DOORS & FRAMES TO BE HOLLOW METAL.
ALL GLASS SHALL BE 1" POL. BK. GLASS (EXCEPT AS NOTED).
FOR FRAME DETAILS SEE BELOW.
EXT. DOORS TO HAVE ALUM. SADDLES.
DOORS TO BE WEATHERSTRIPPED. ALL SIDES.

DOORS TO BE WEATHERSTRIPPED. ALL SIDES

SILICONE RUBBER
SEALANT - BOTH FACES



12 CONCRETE BLOCK
SHOWN (OTHER WALLS
SIMILAR) — RAPID CONTROL
JOINT

TYPICAL
BLOCK EXP. JOINT _____
SECTION 5-5-ABOVE DOOR

SECTION 5-5-ABOVE DOOR

JAMB *KL*
TYP. INT. DOOR DETAILS

TYP. INT. DOG

(5) THE ANCHOR

EXTERIOR DOOR DETAILS FOR HOLLOW MET. FRAMES

HOLLOW MET. FRAMES

STATE OF VERMONT
DIVISION OF STATE BUILDINGS
AGENCY OF ADMINISTRATION
MONTPELIER, VERMONT

MONTPELIER, VERMONT


Standard Highway Garage Building SELECTED DETAILS

SCALE: 1 1/2" = 1'-0" or as noted


DATE:	DESIGNED BY
-------	-------------

10-18-74	A3
----------	----

10-18-74	A3
----------	----

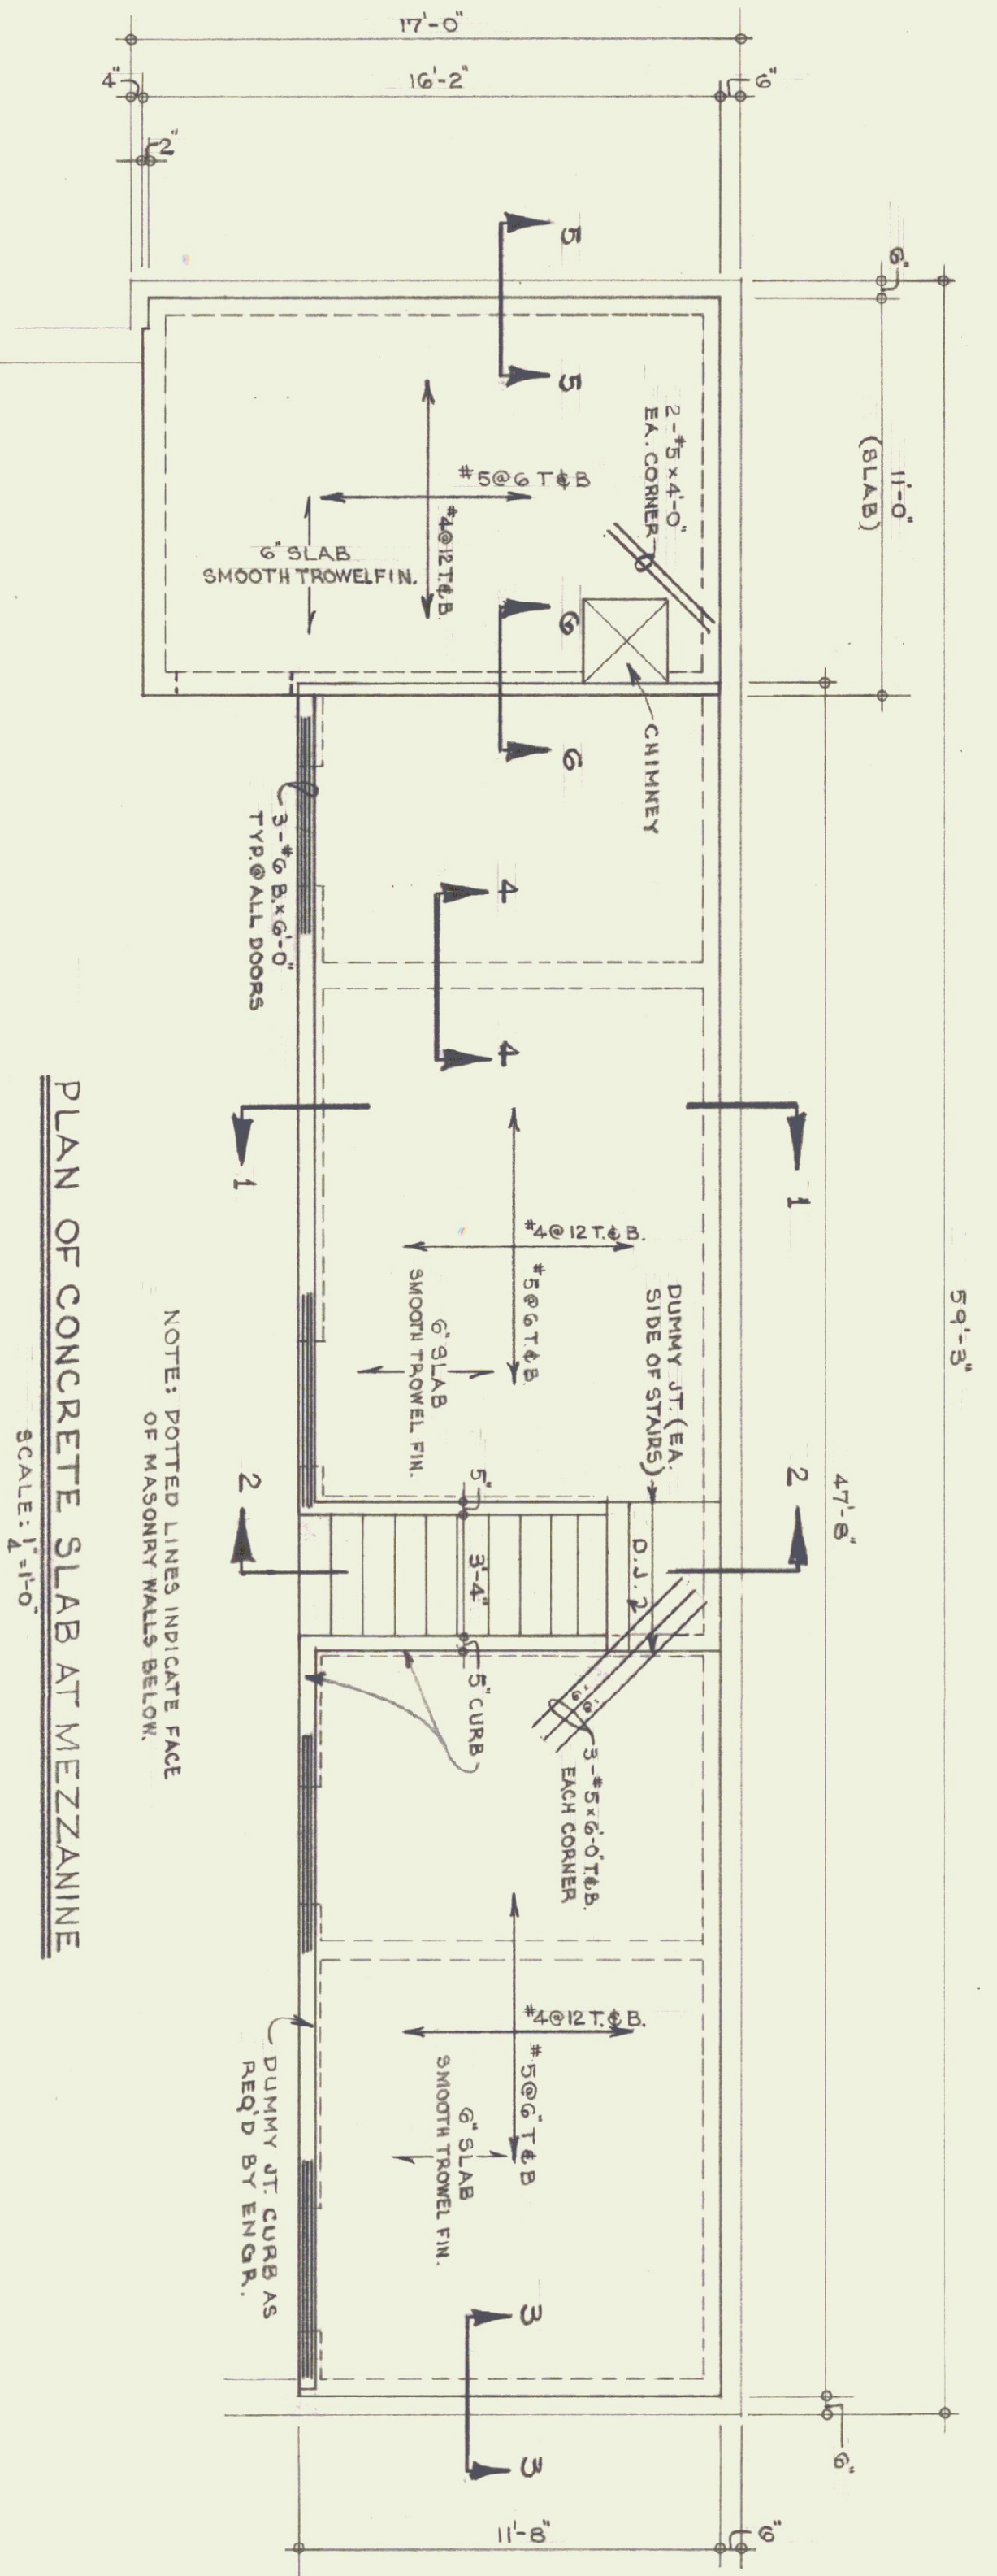


PLAN OF CONCRETE SLAB AT MEZZANINE
SCALE: 1/8" = 1'-0"

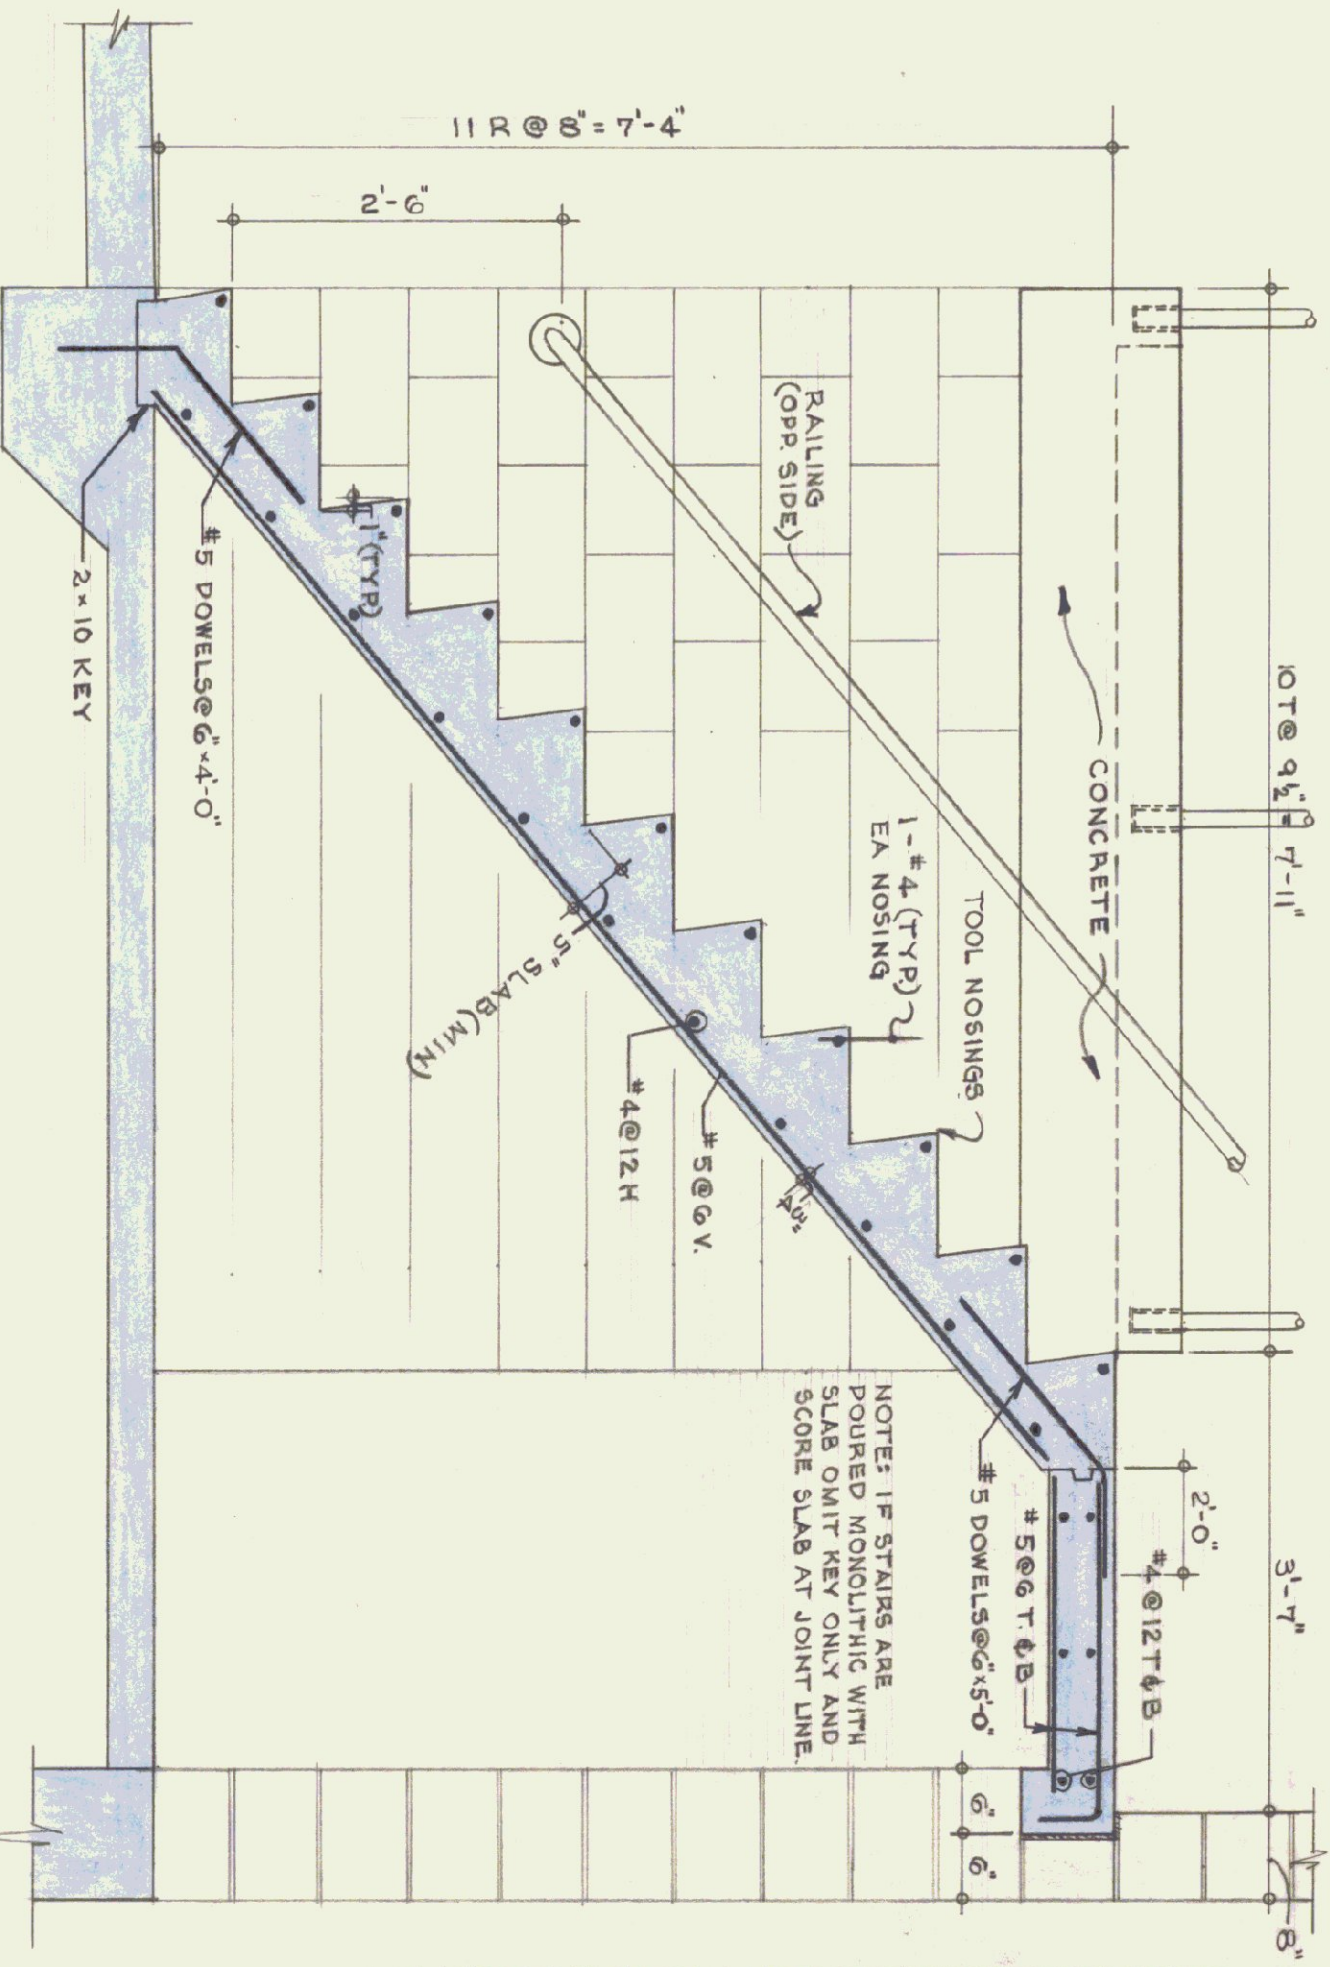


GENERAL NOTES

1. CONCRETE - 3000 PSI @ 28 DAYS, MAXIMUM SLUMP 4".
2. ALL EXPOSED CONCRETE TO BE RUBBED AND CURED.
3. ALL EXPOSED SLABS & CONCRETE STEPS TO BE COVERED & PROTECTED FOR DURATION OF JOB UNTIL ACCEPTANCE.
4. EXPOSED CURB CORNERS TO BE CHAMFERED.
5. DAYS @ 70° F. RE-SHORE AFTER STRIPPING - 14 DAYS.
6. PROTECT MASONRY FROM CONCRETE - SLAB DIPPING.
7. REINFORCING STEEL TO BE LAPPED 40 DIA.
8. ALL STEPS ARE TO BE PLACED ON SLAB PVC PLASTIC.
9. ELECTRICAL CONDUIT TO BE LAYED ABOVE BOTTOM FACE OF STEEL.
10. ONE SECTION OF RAILINGS EACH SIDE OF STAIRS TO BE REMOVABLE.
11. INTO SLEEVES. POSTS TO BE LEADED.
12. ALL CONCRETE SLABS SHALL BE SMOOTH TROWELED.
13. CONCRETE STAIR TREADS SHALL HAVE INTEGRAL ABRASIVE HARDENER.

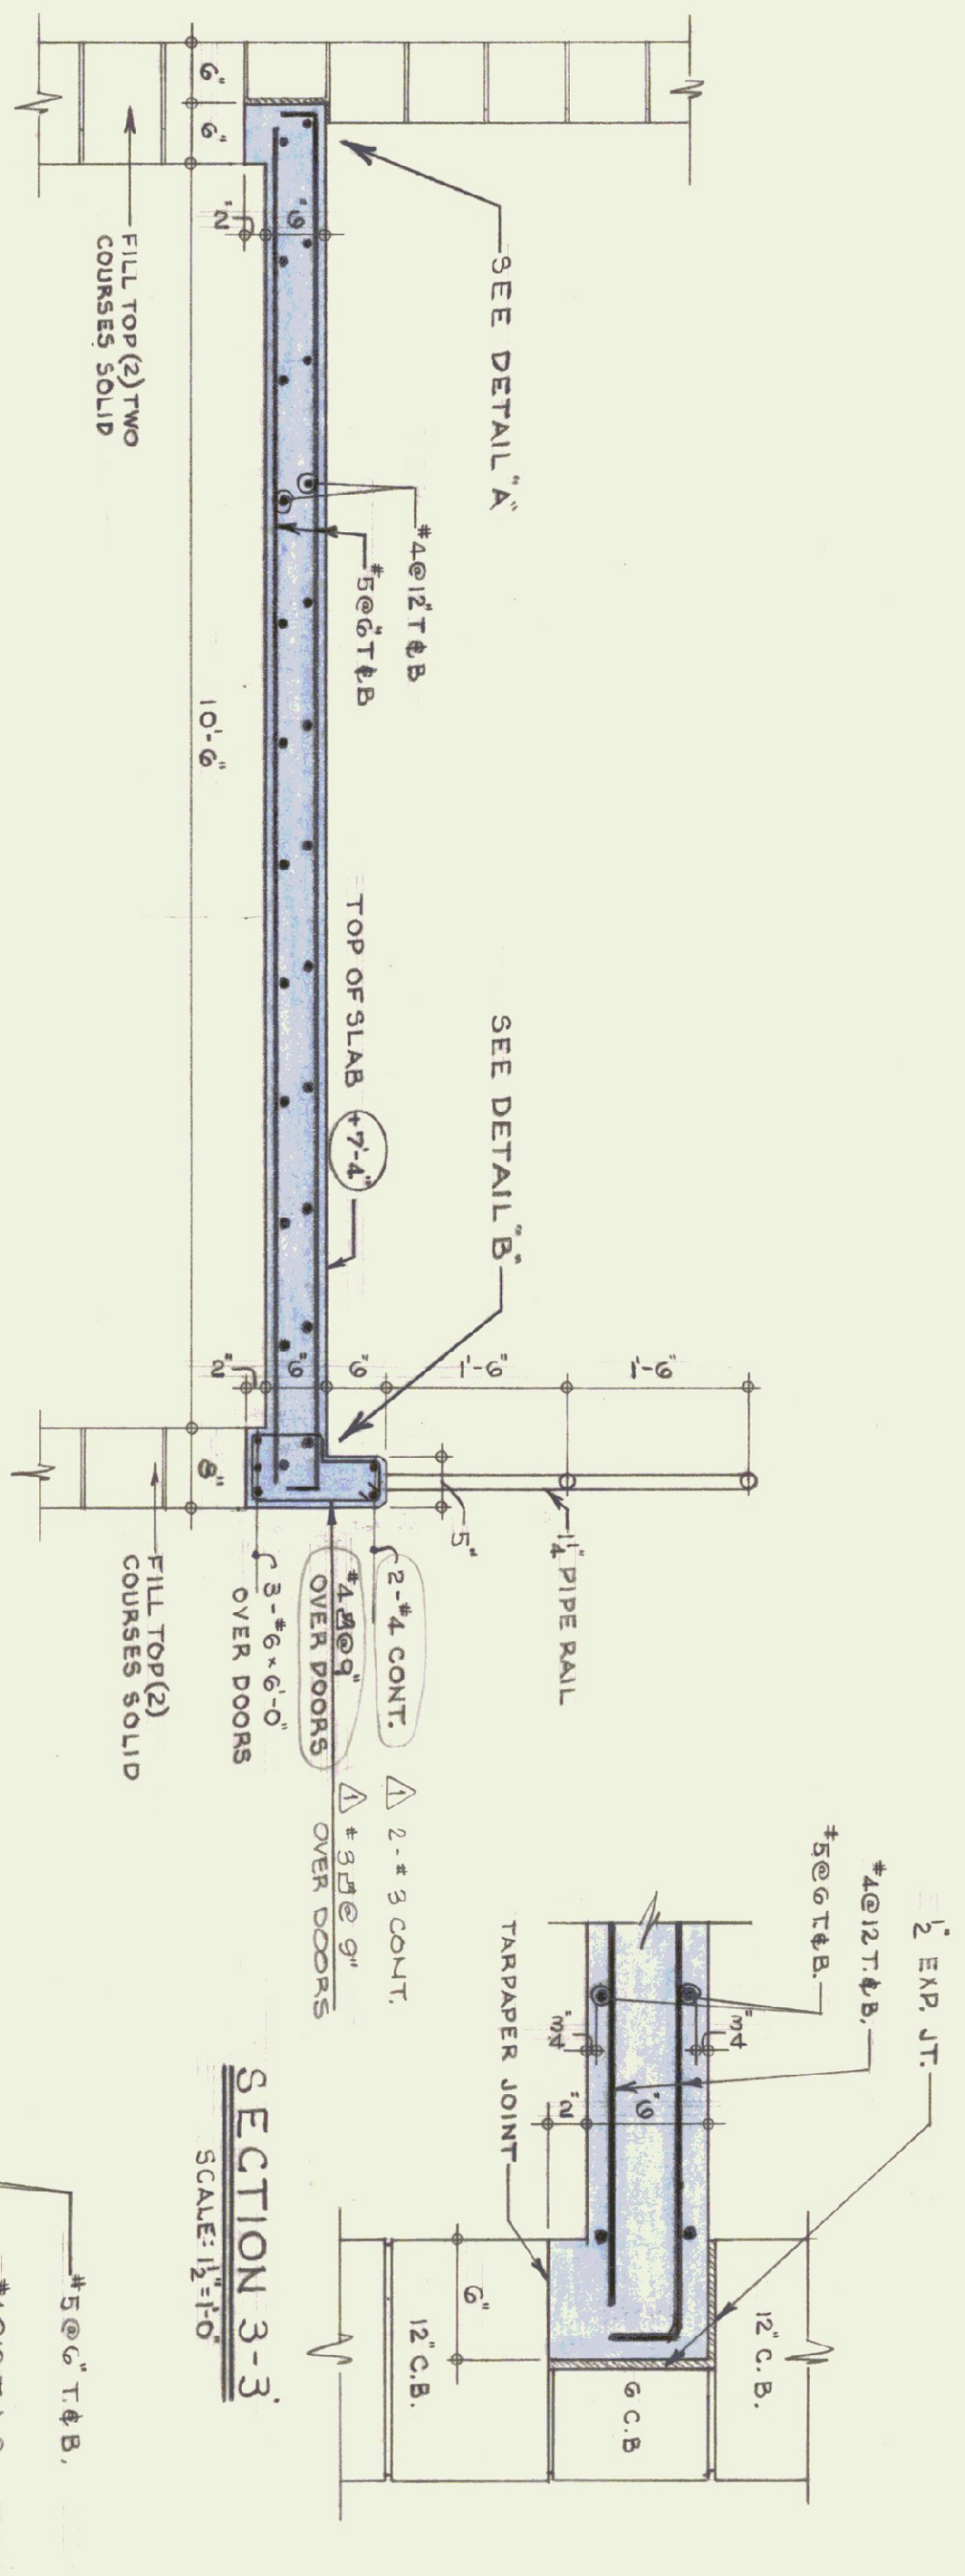


SECTION 1-1
SCALE: 3/4" = 1'-0"

SECTION 3-3
SCALE: 1/2" = 1'-0"

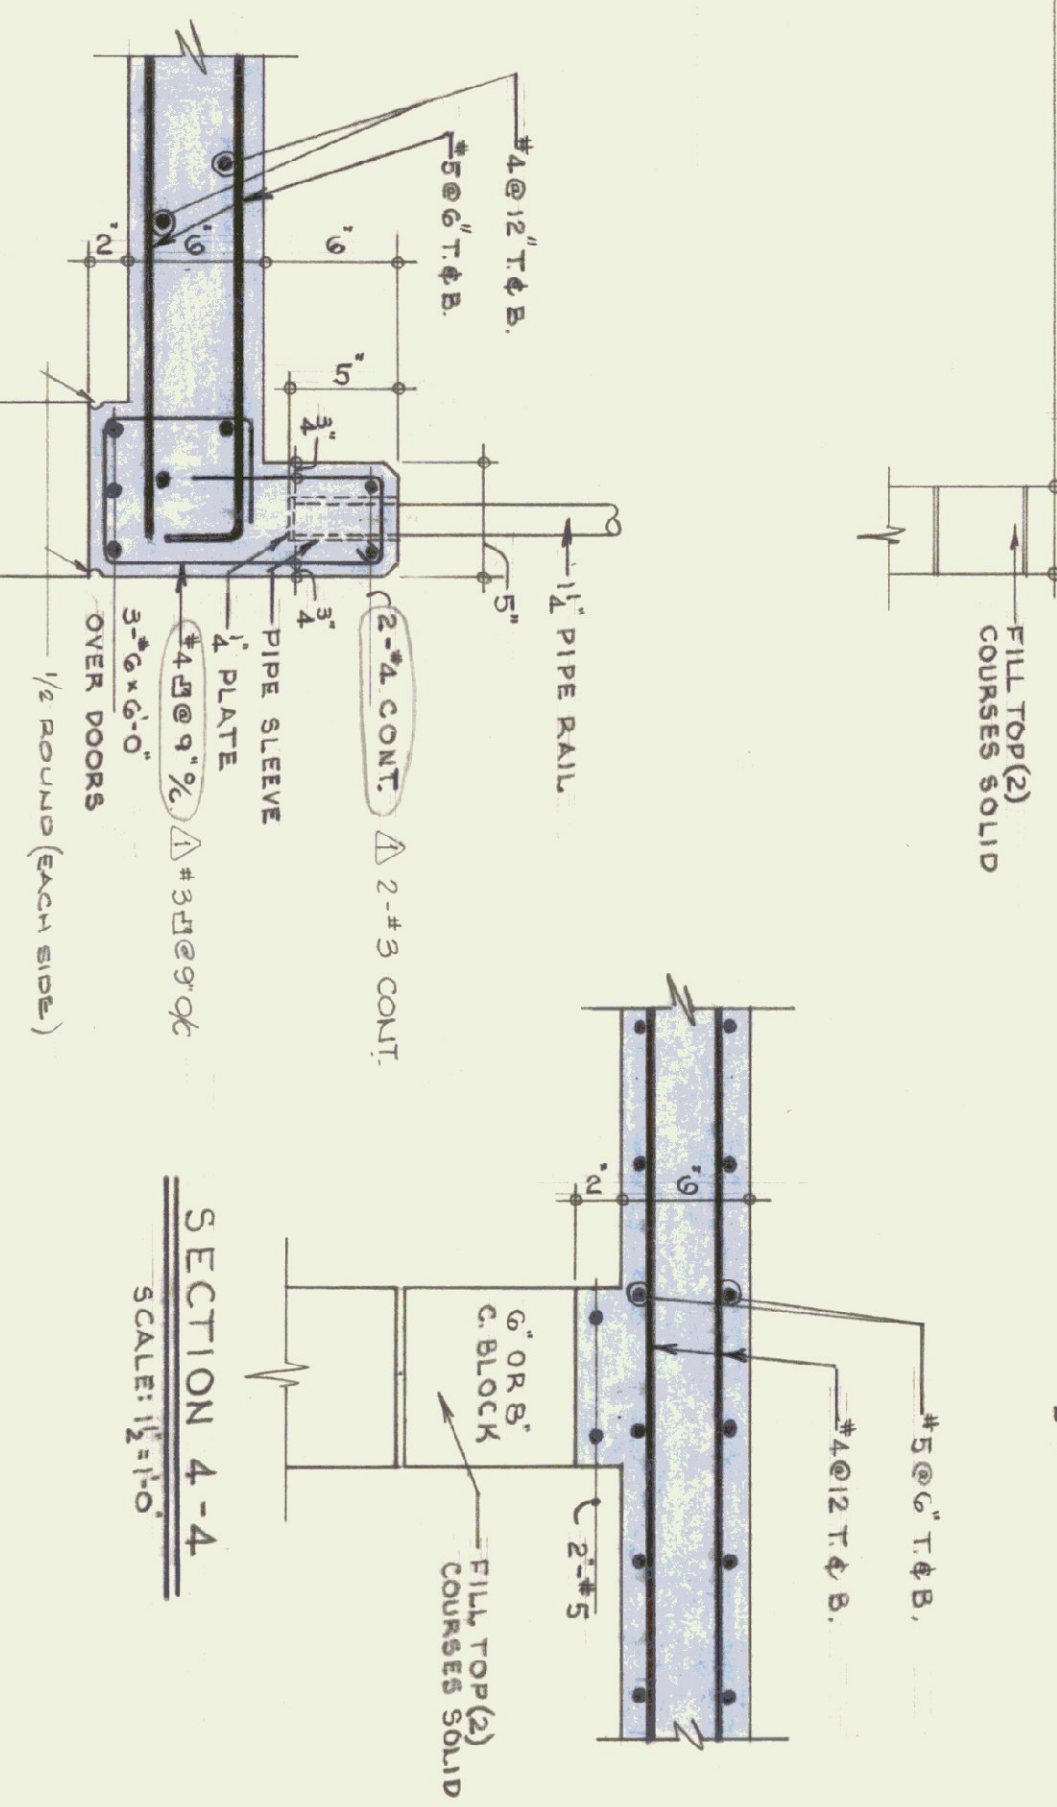


SECTION 4-4
SCALE: 1/2" = 1'-0"


SECTION 5-5
SCALE: 1/2" = 1'-0"

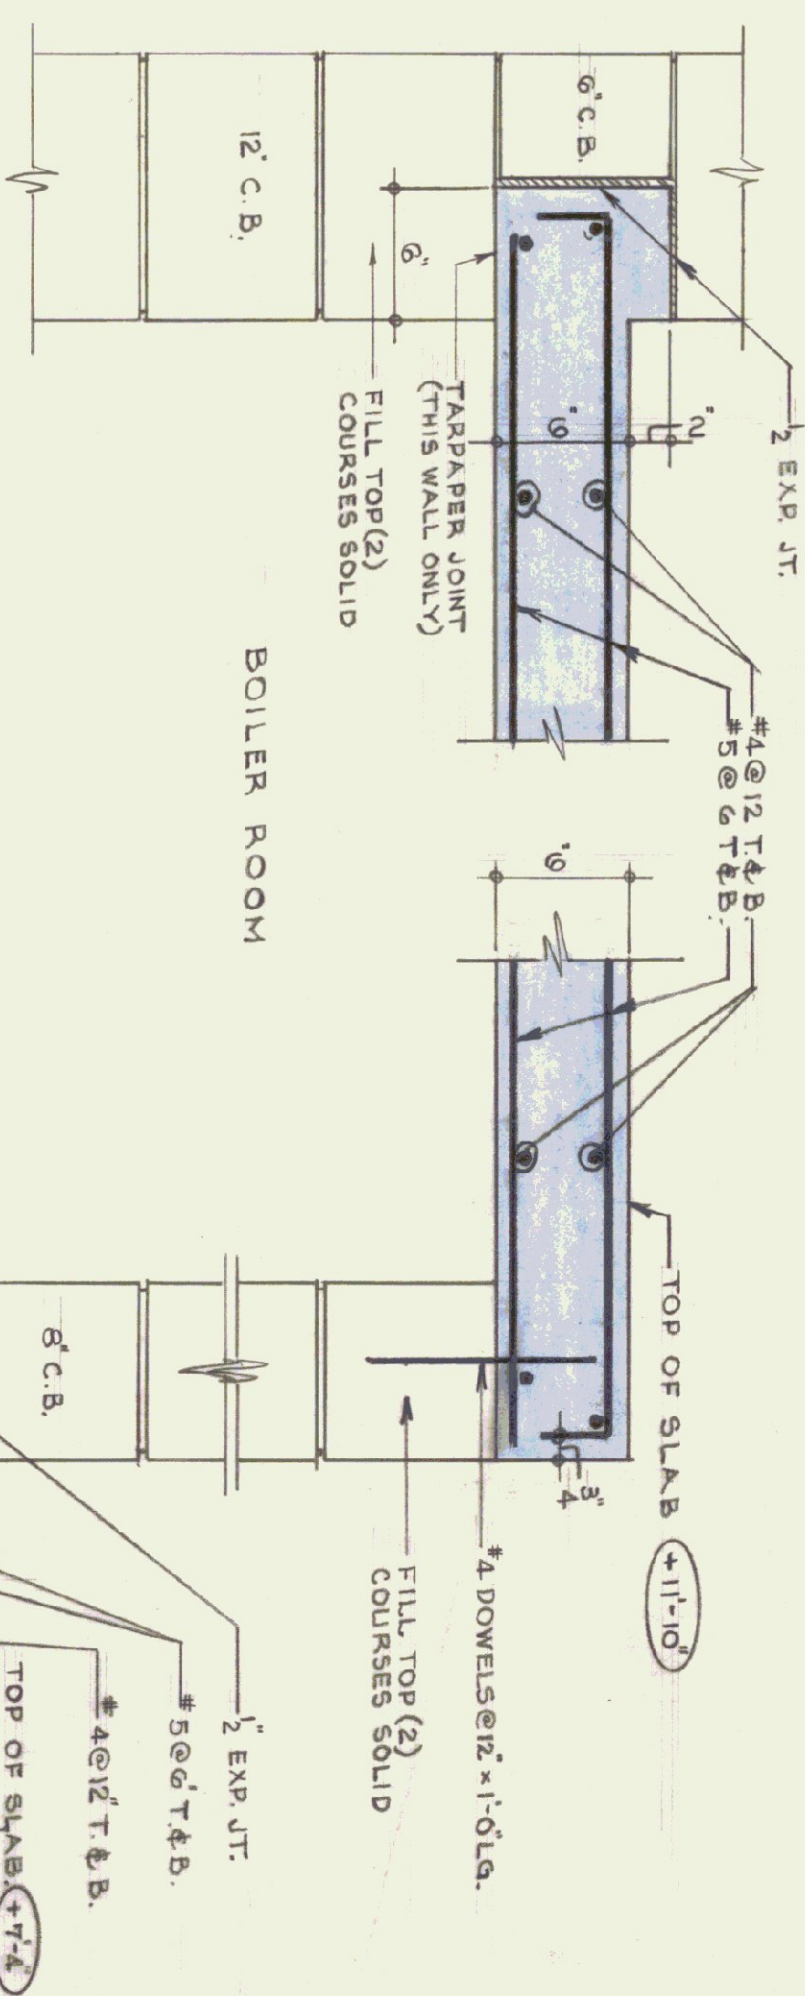


SECTION 6-6
SCALE: 1/2" = 1'-0"

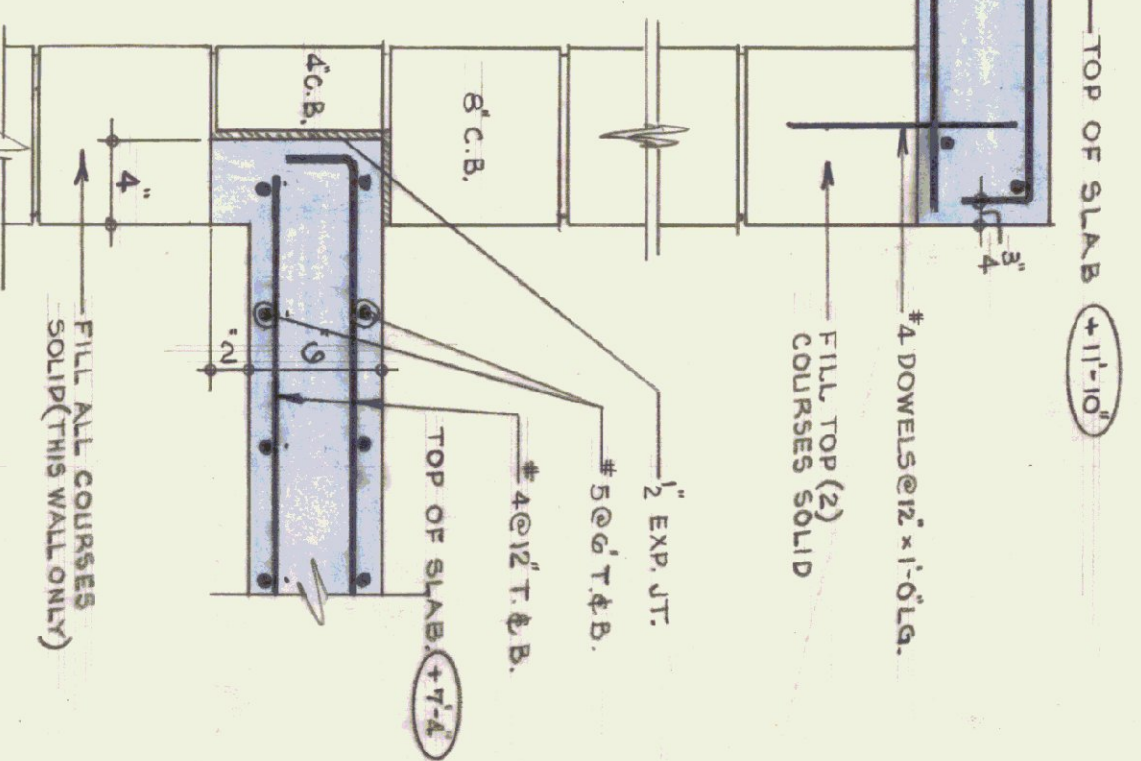

DETAIL 'A'
SCALE: 1/2" = 1'-0"

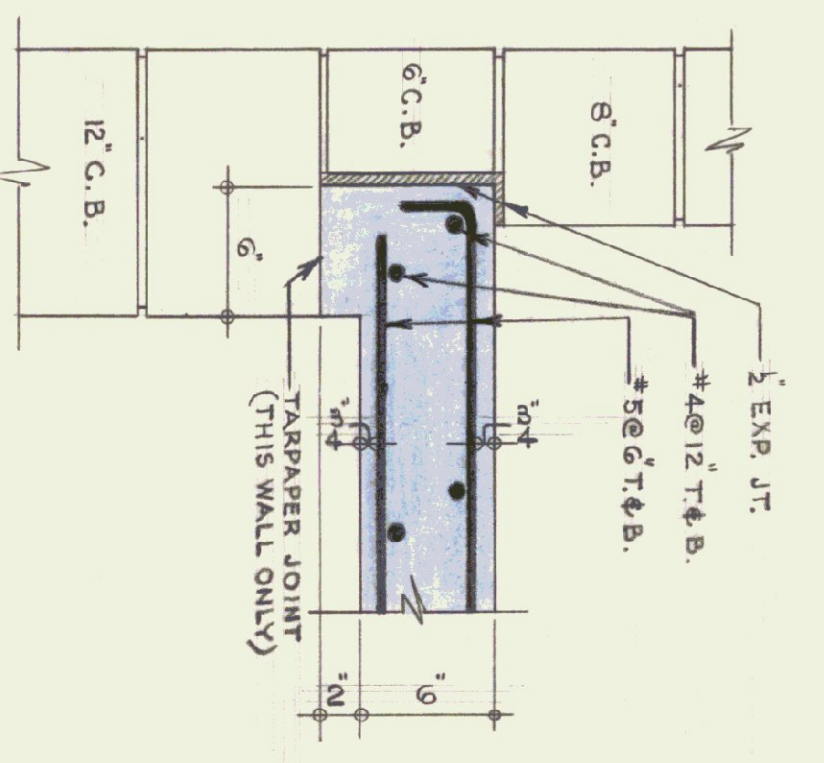

DETAIL 'B'
SCALE: 1/2" = 1'-0"

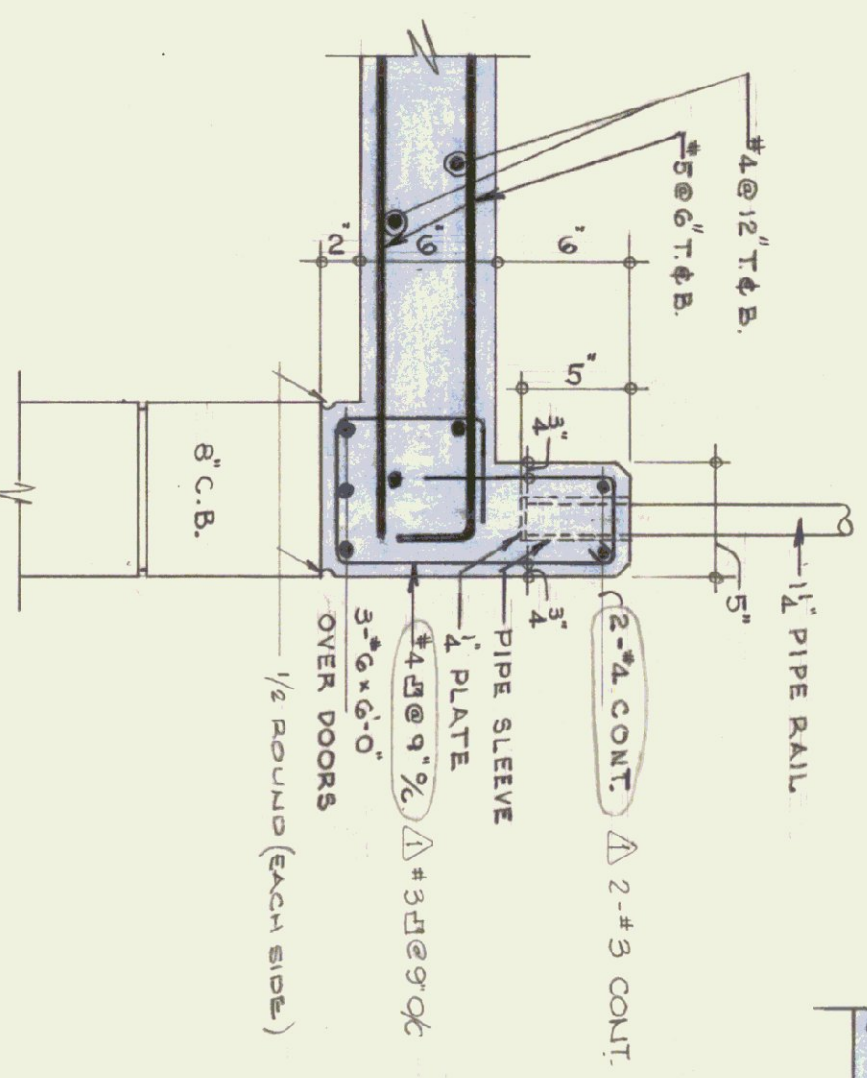


NO	BY	DATE	REVISION
A	TJB	8/4/75	REIN. # 5 CURB DETAILS


STATE OF VERMONT
DIVISION OF STATE BUILDINGS
AGENCY OF ADMINISTRATION
MONTPELIER.
VERMONT

Standard Highway Garage Building
DETAILS OF MEZZANINE, BOILER
ROOM SLABS AND CONC. STAIRWAY
SCALE: As noted


DATE: 10-18-74	DESIGNED BY: T.J.S.	DWG. NO. A4
DRAWN BY: STUDIO SEVEN INC.	APPROVED BY: J.S.F.	4 OF 4

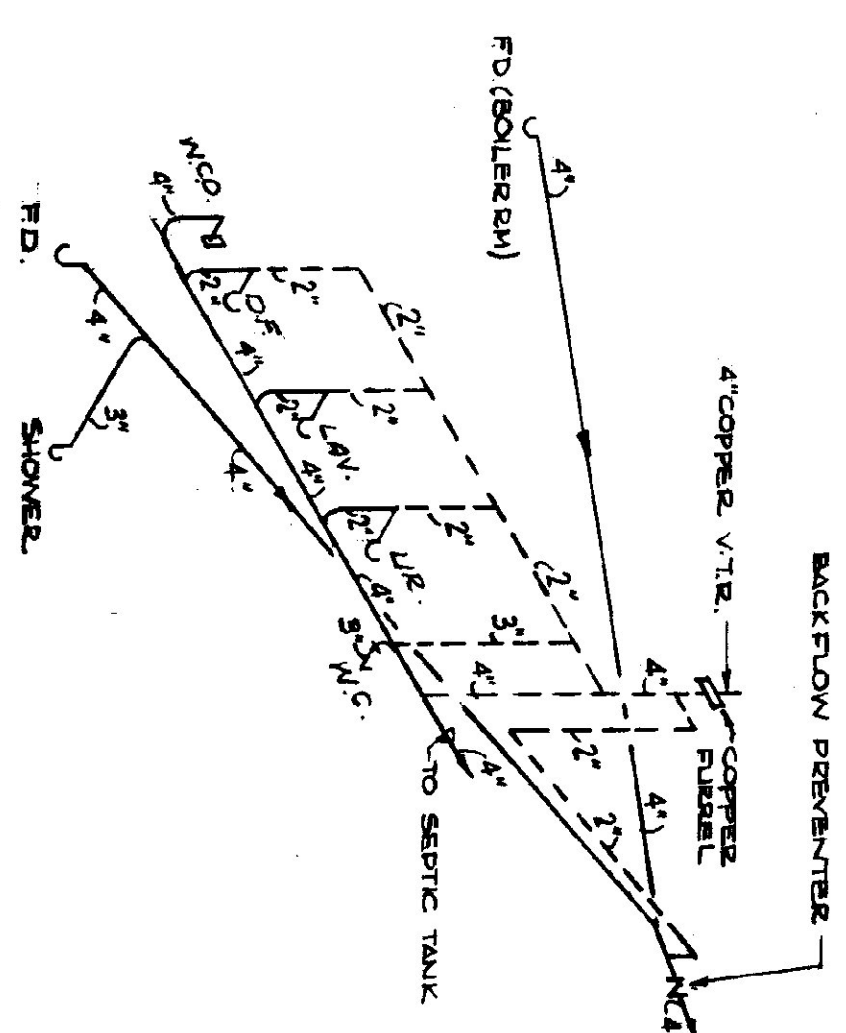


SEE DRAWING H-2 FOR SCHEDULE & GENERAL NOTES

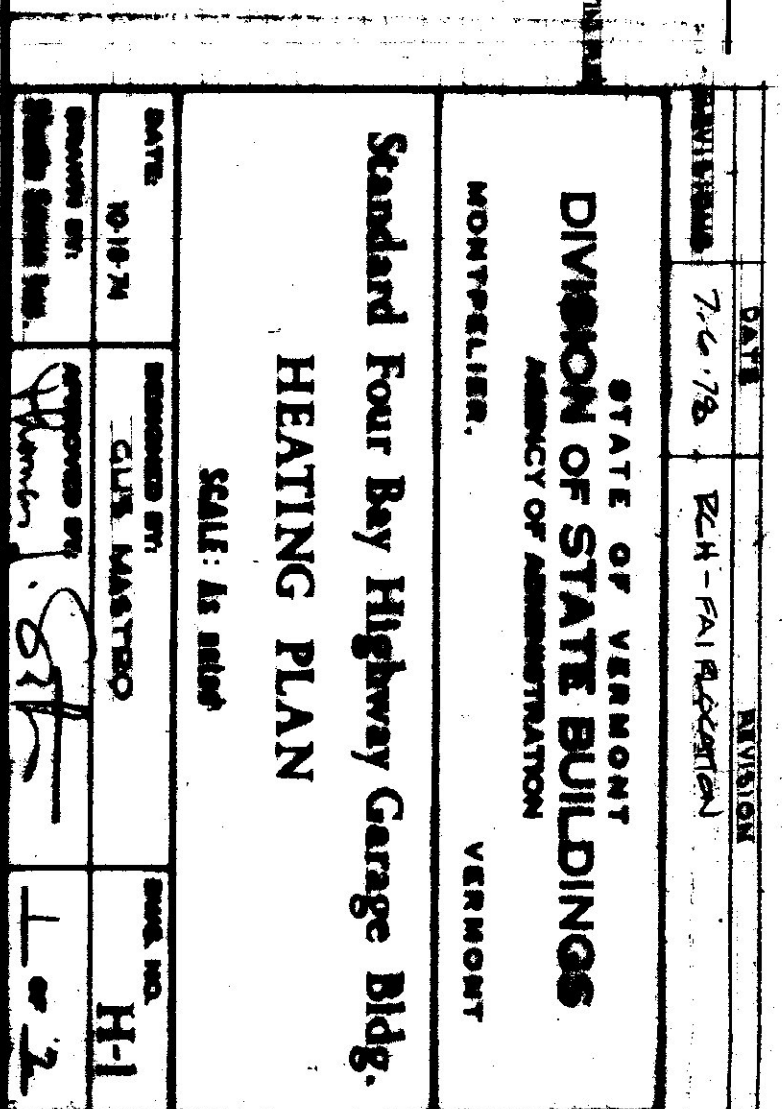




GARAGE PAINTBENCH
DETAILS AND LOCATION
SEE DWG. 5

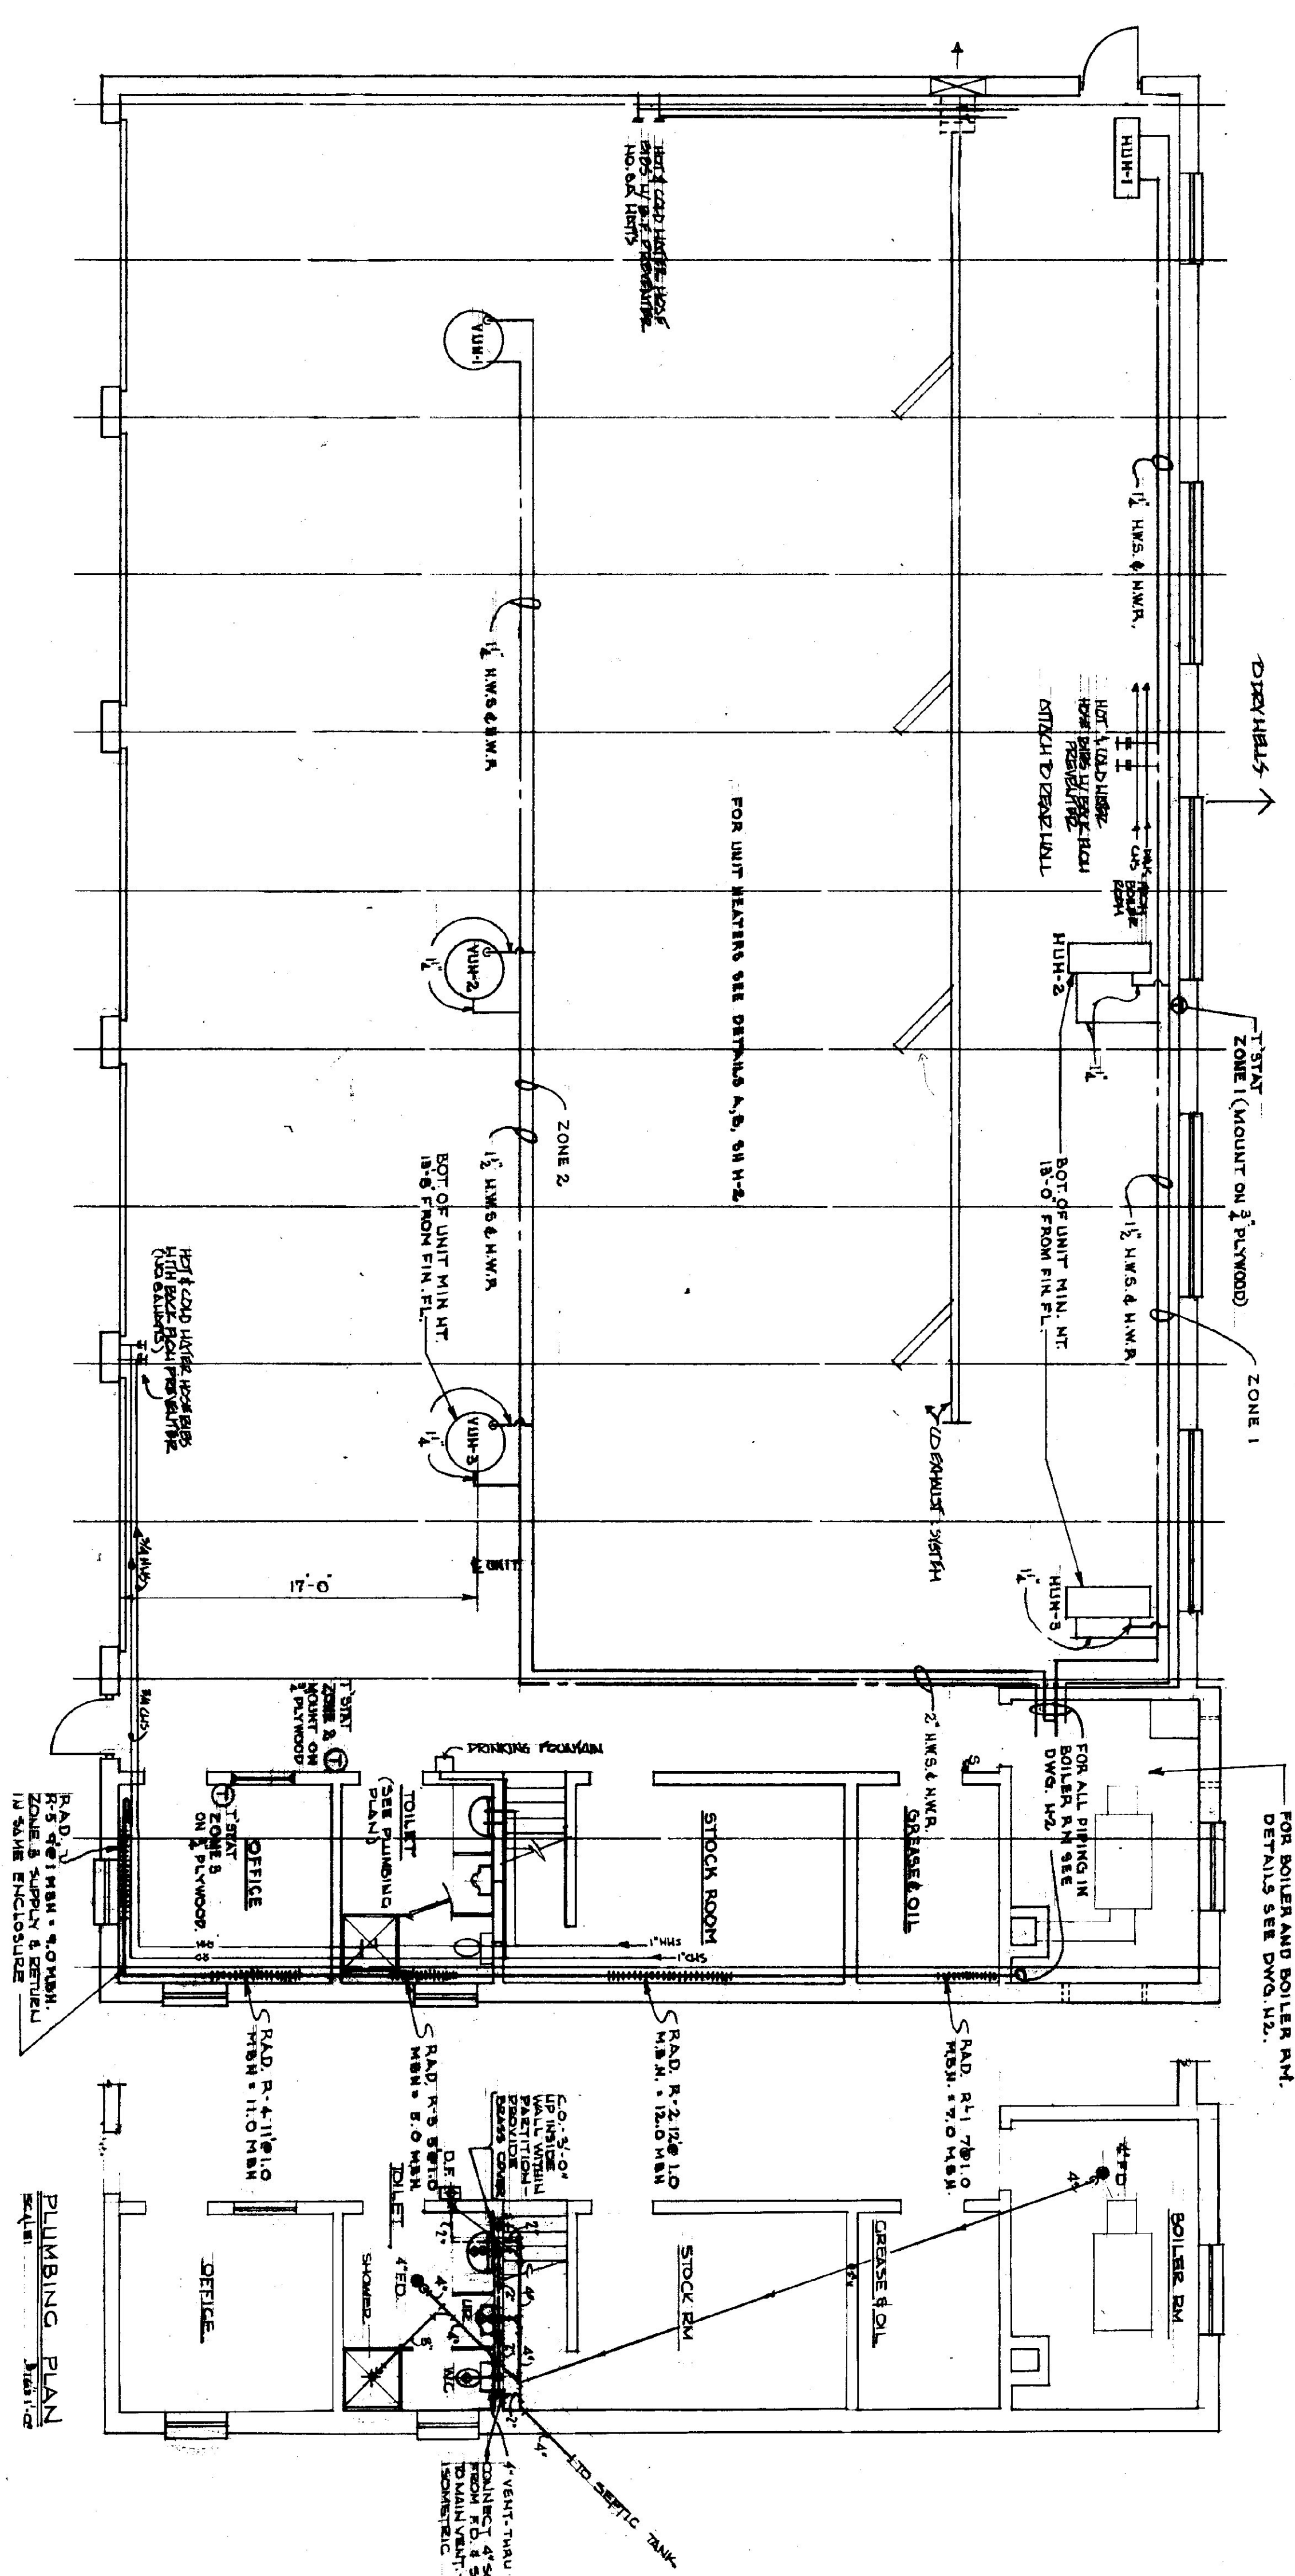

PLUMBING PLAN
SCALE: 1/8" = 1'-0"

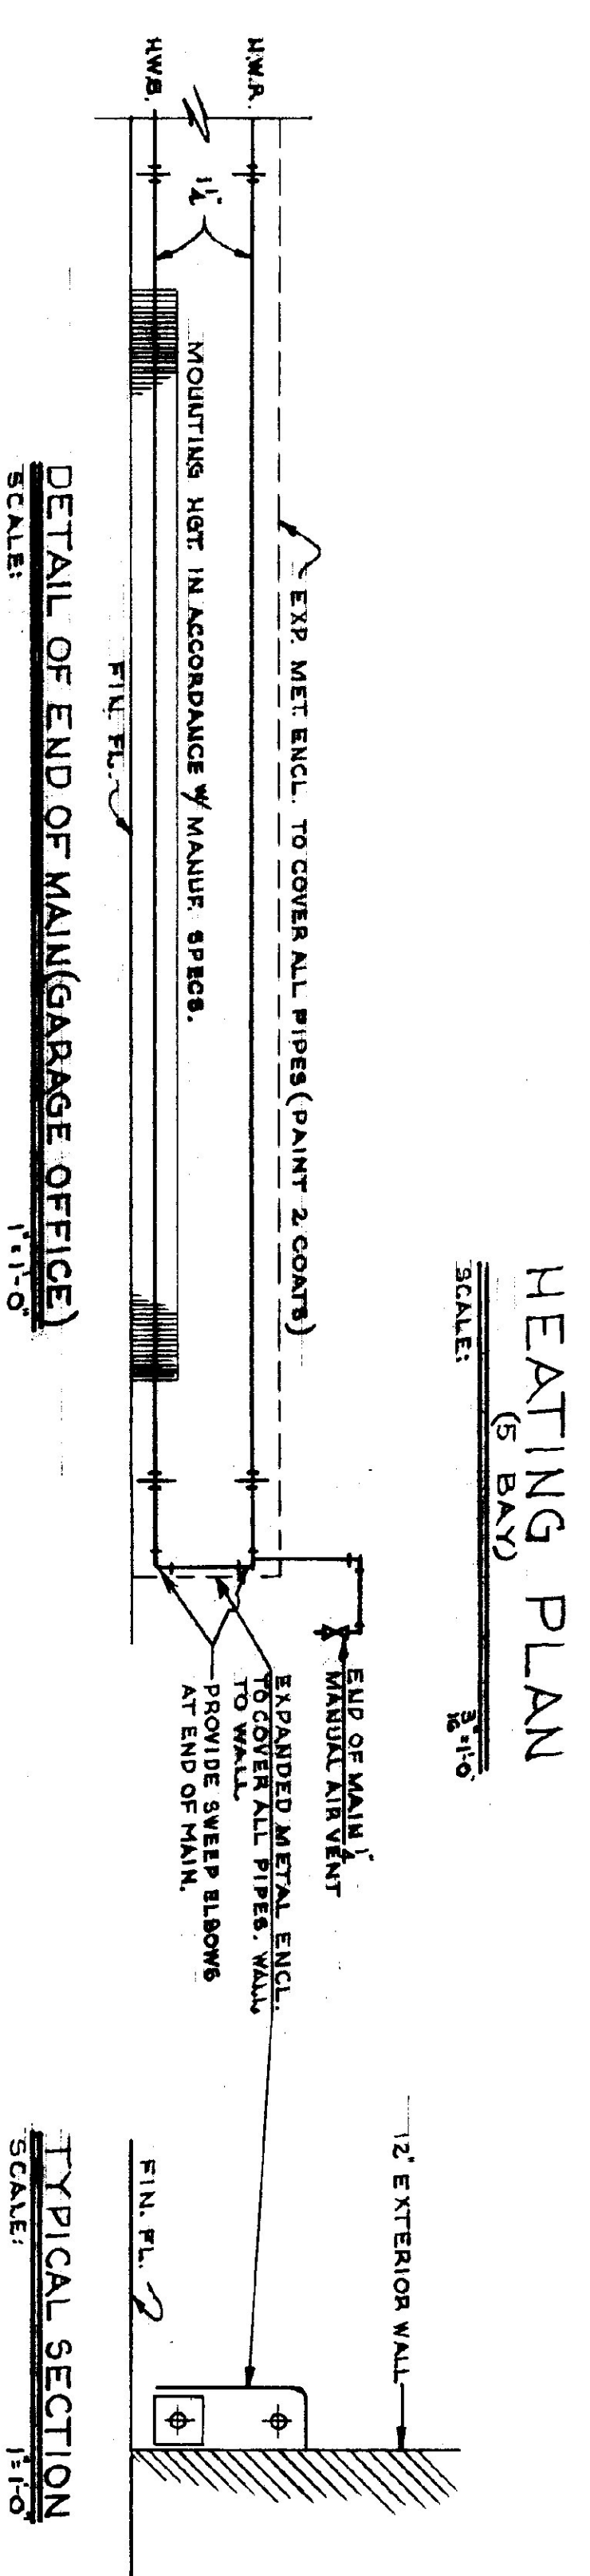

TYPICAL SECTION
SCALE: 1/4" = 1'-0"

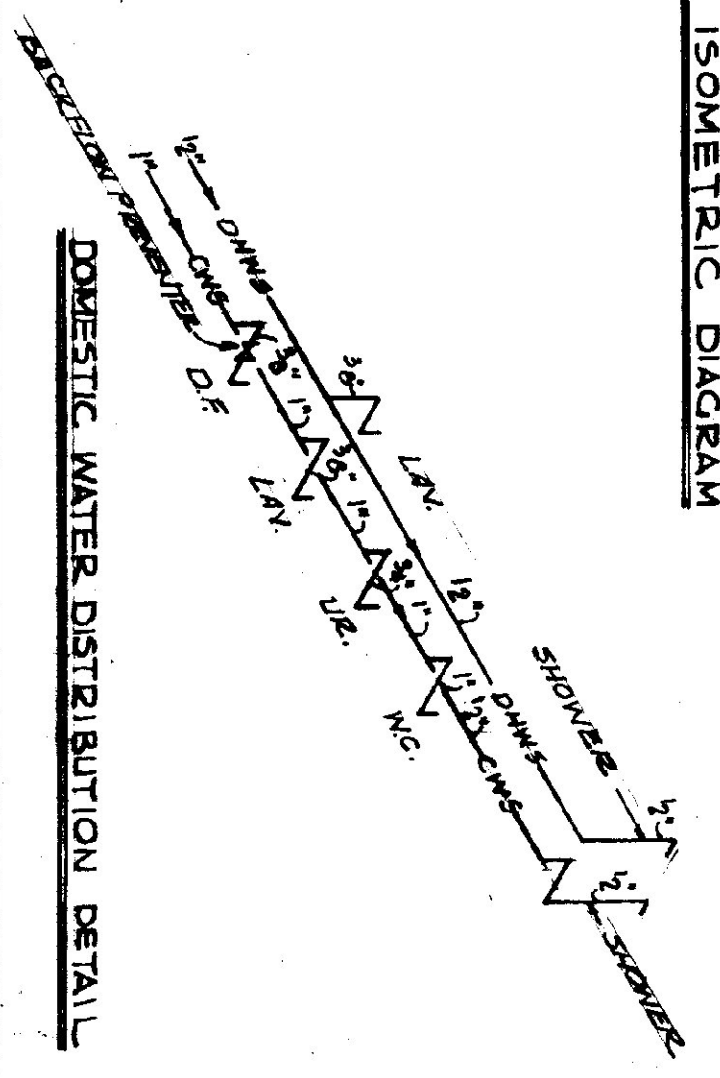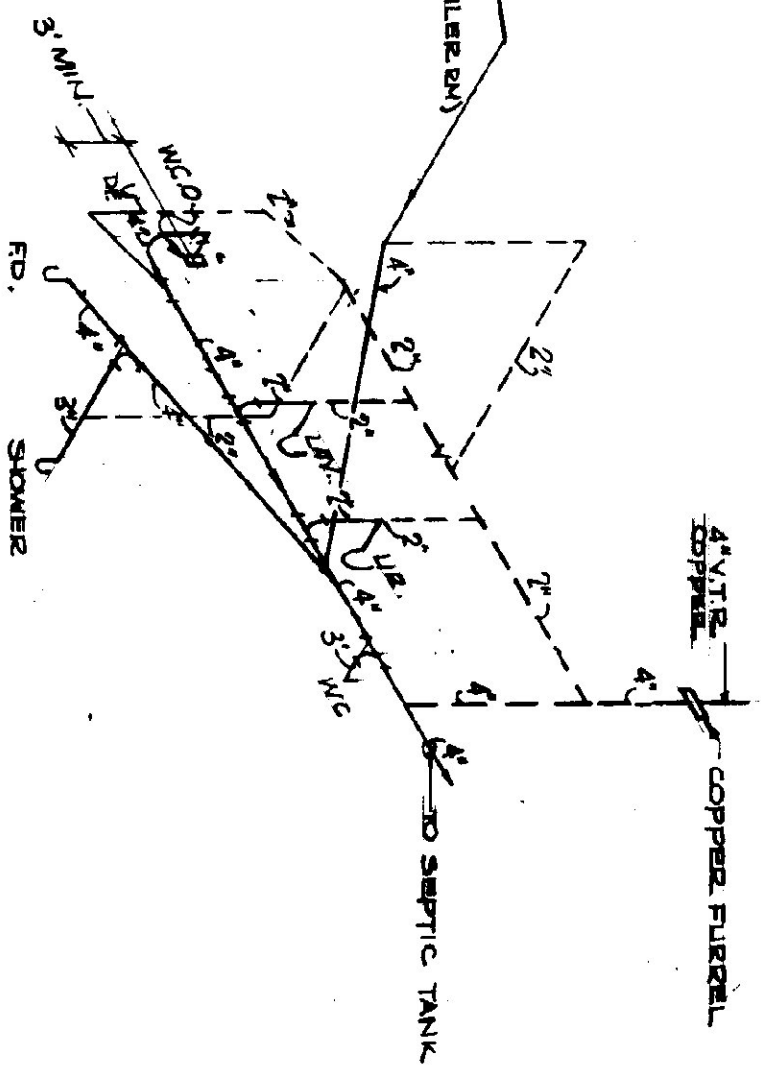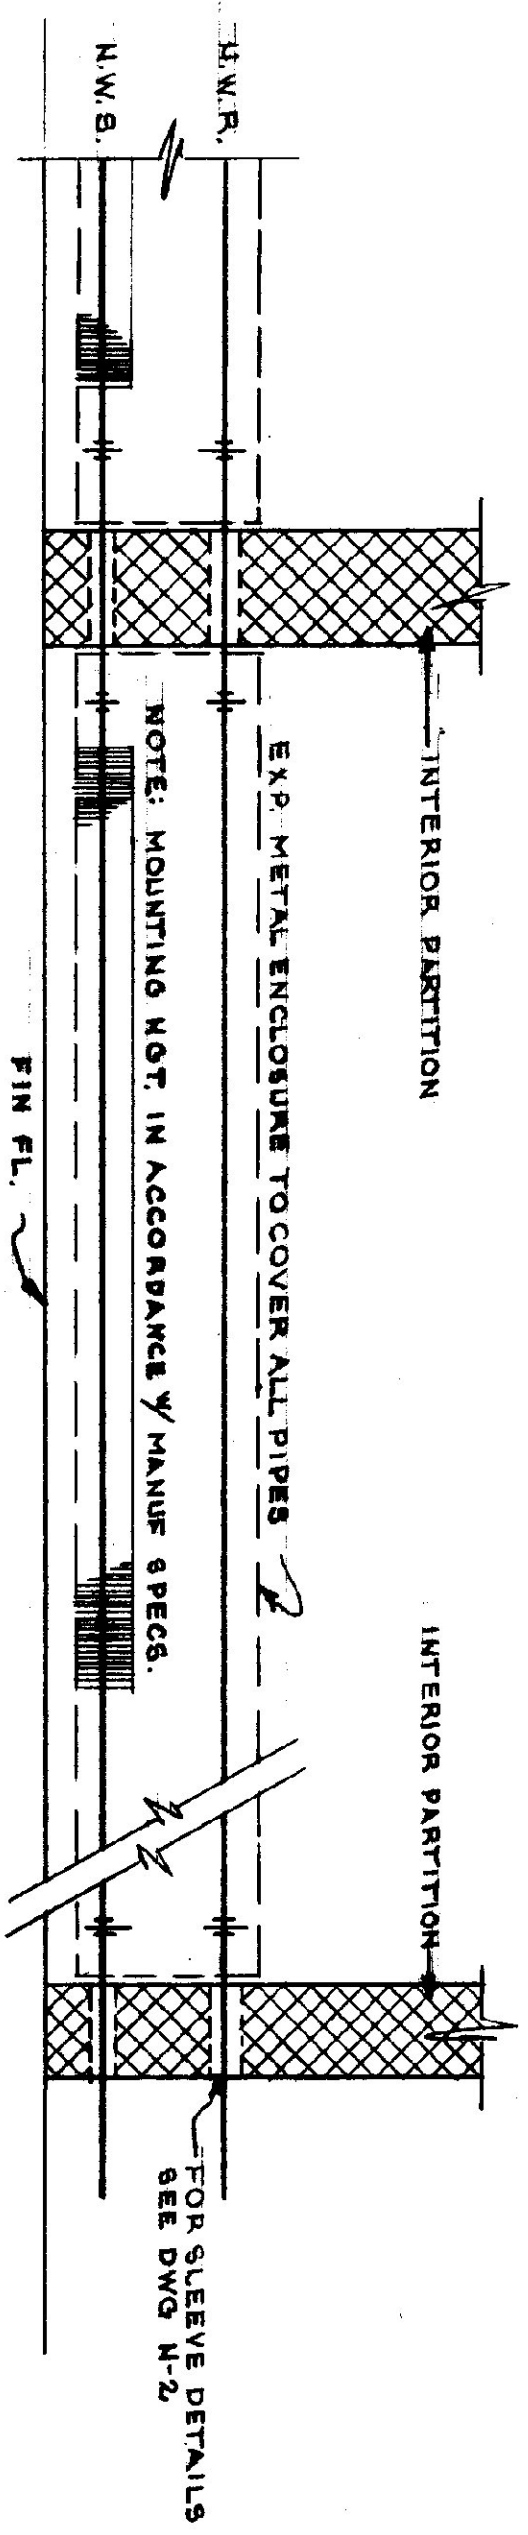

- LEGEND
- H.W.S. ---
 - H.W.R. ---
 - BURNER SAFETY SWITCH (GAS) & GAS VALVE
 - T STATE
 - PIPE SUPPLY TO BOTTOM & RETURN TO TOP
 - H.U.H.
 - GATE VALVE
 - CHECK VALVE
 - BALANCING COCK
 - FLOW CONTROL VALVE
 - UNION
 - FUSIBLE LEVER-WRITIC VALVE
 - STRAINED
 - PRV - ALL BRONZE
 - BACK FROM REPAIRS




SEE DRAWING H-2 FOR SCHEDULES & GENERAL NOTES

DATE	DESIGNED BY	CHECKED BY	DATE
10-18-74	C.W. MASTERS	W.D. MASTERS	11-1-74
DESIGNED BY	C.W. MASTERS	CHECKED BY	W.D. MASTERS
STUDIO ARCH INC.	101 E. 1st St.	101 E. 1st St.	101 E. 1st St.



STATE OF VERMONT
DIVISION OF STATE BUILDINGS
AGENCY OF ADMINISTRATION
MONTPELIER, VERMONT

Standard Five Bay Highway Garage Bldg.
HEATING PLAN

SCALE: AS SHOWN

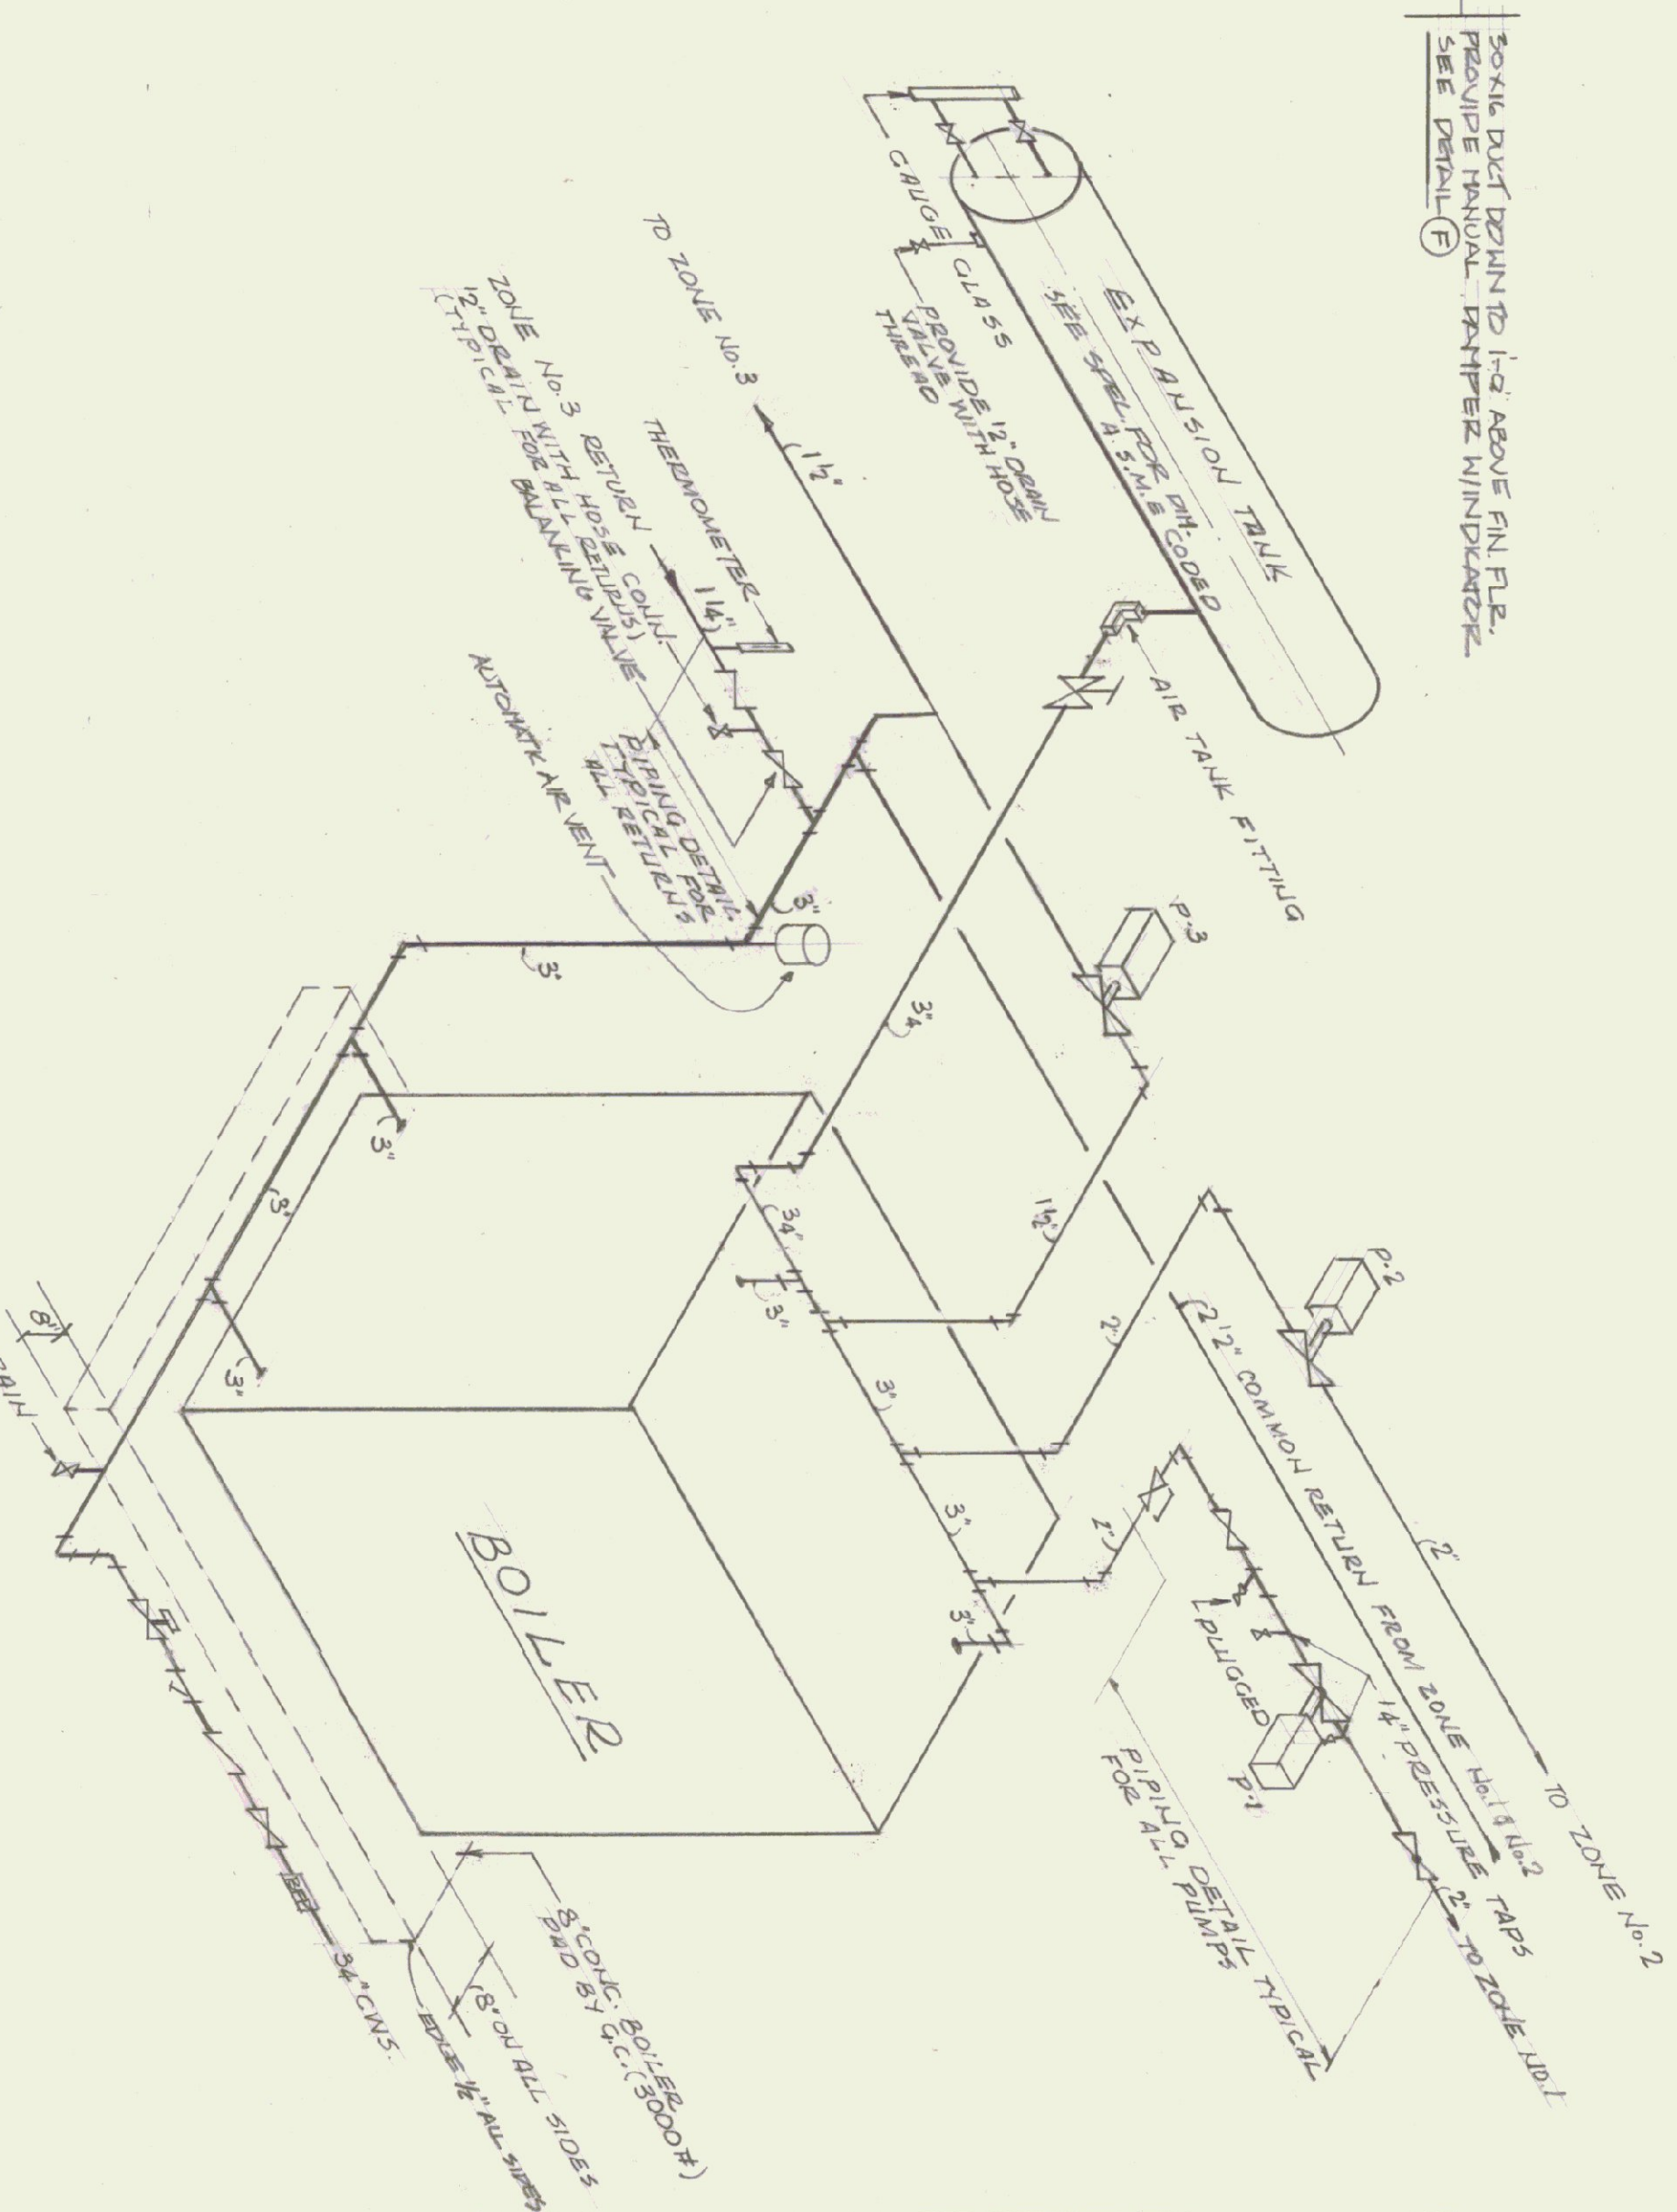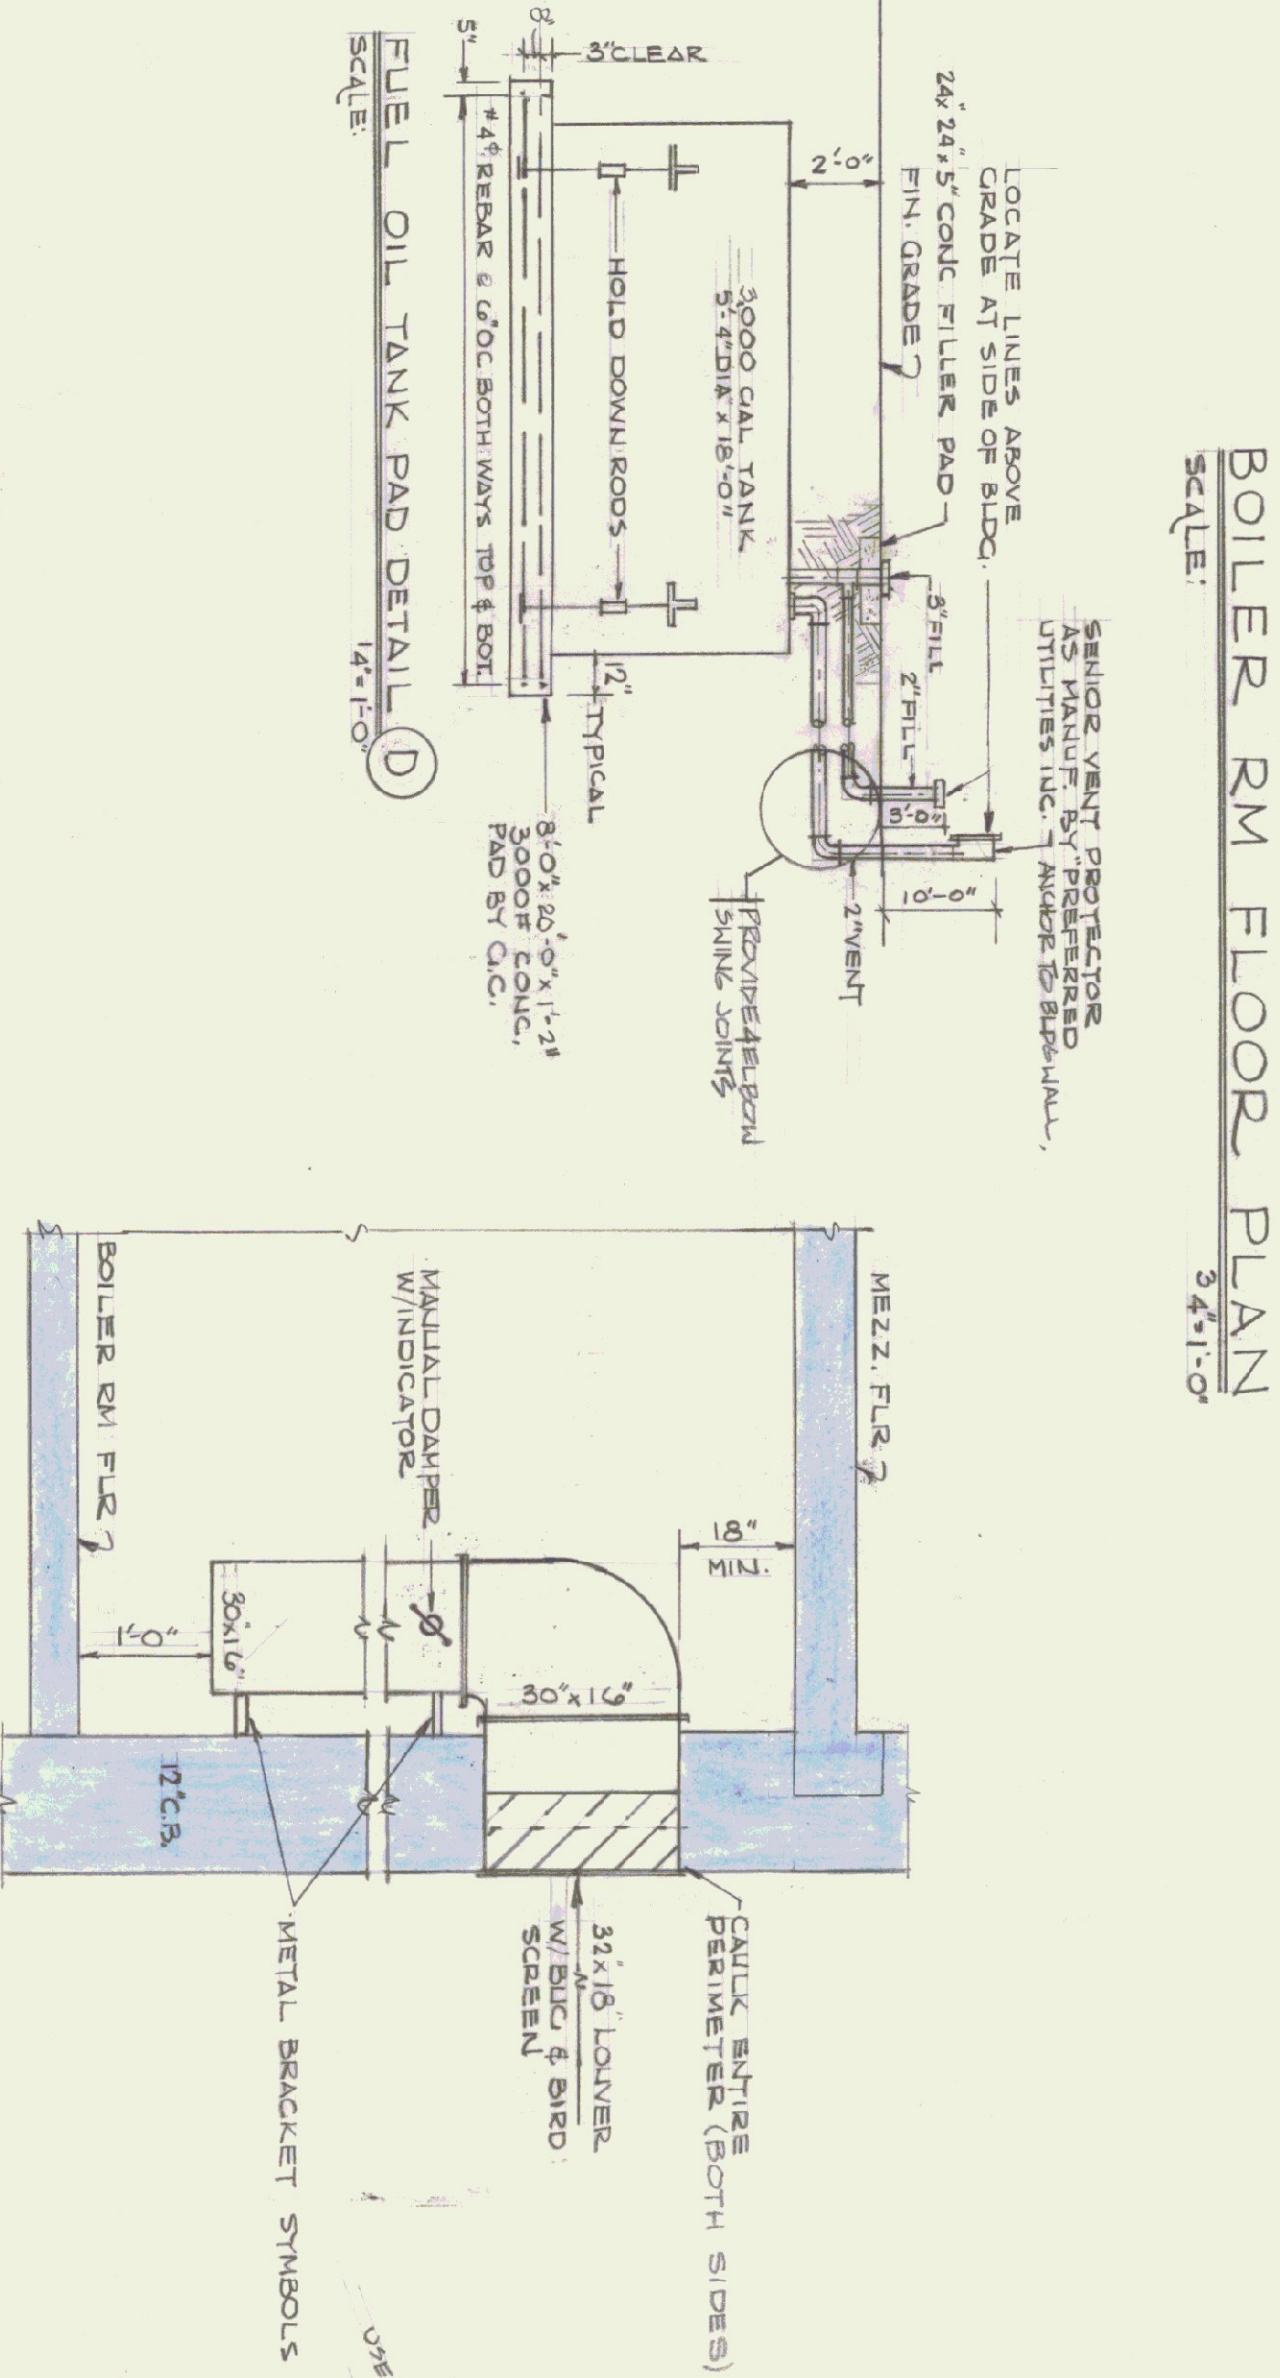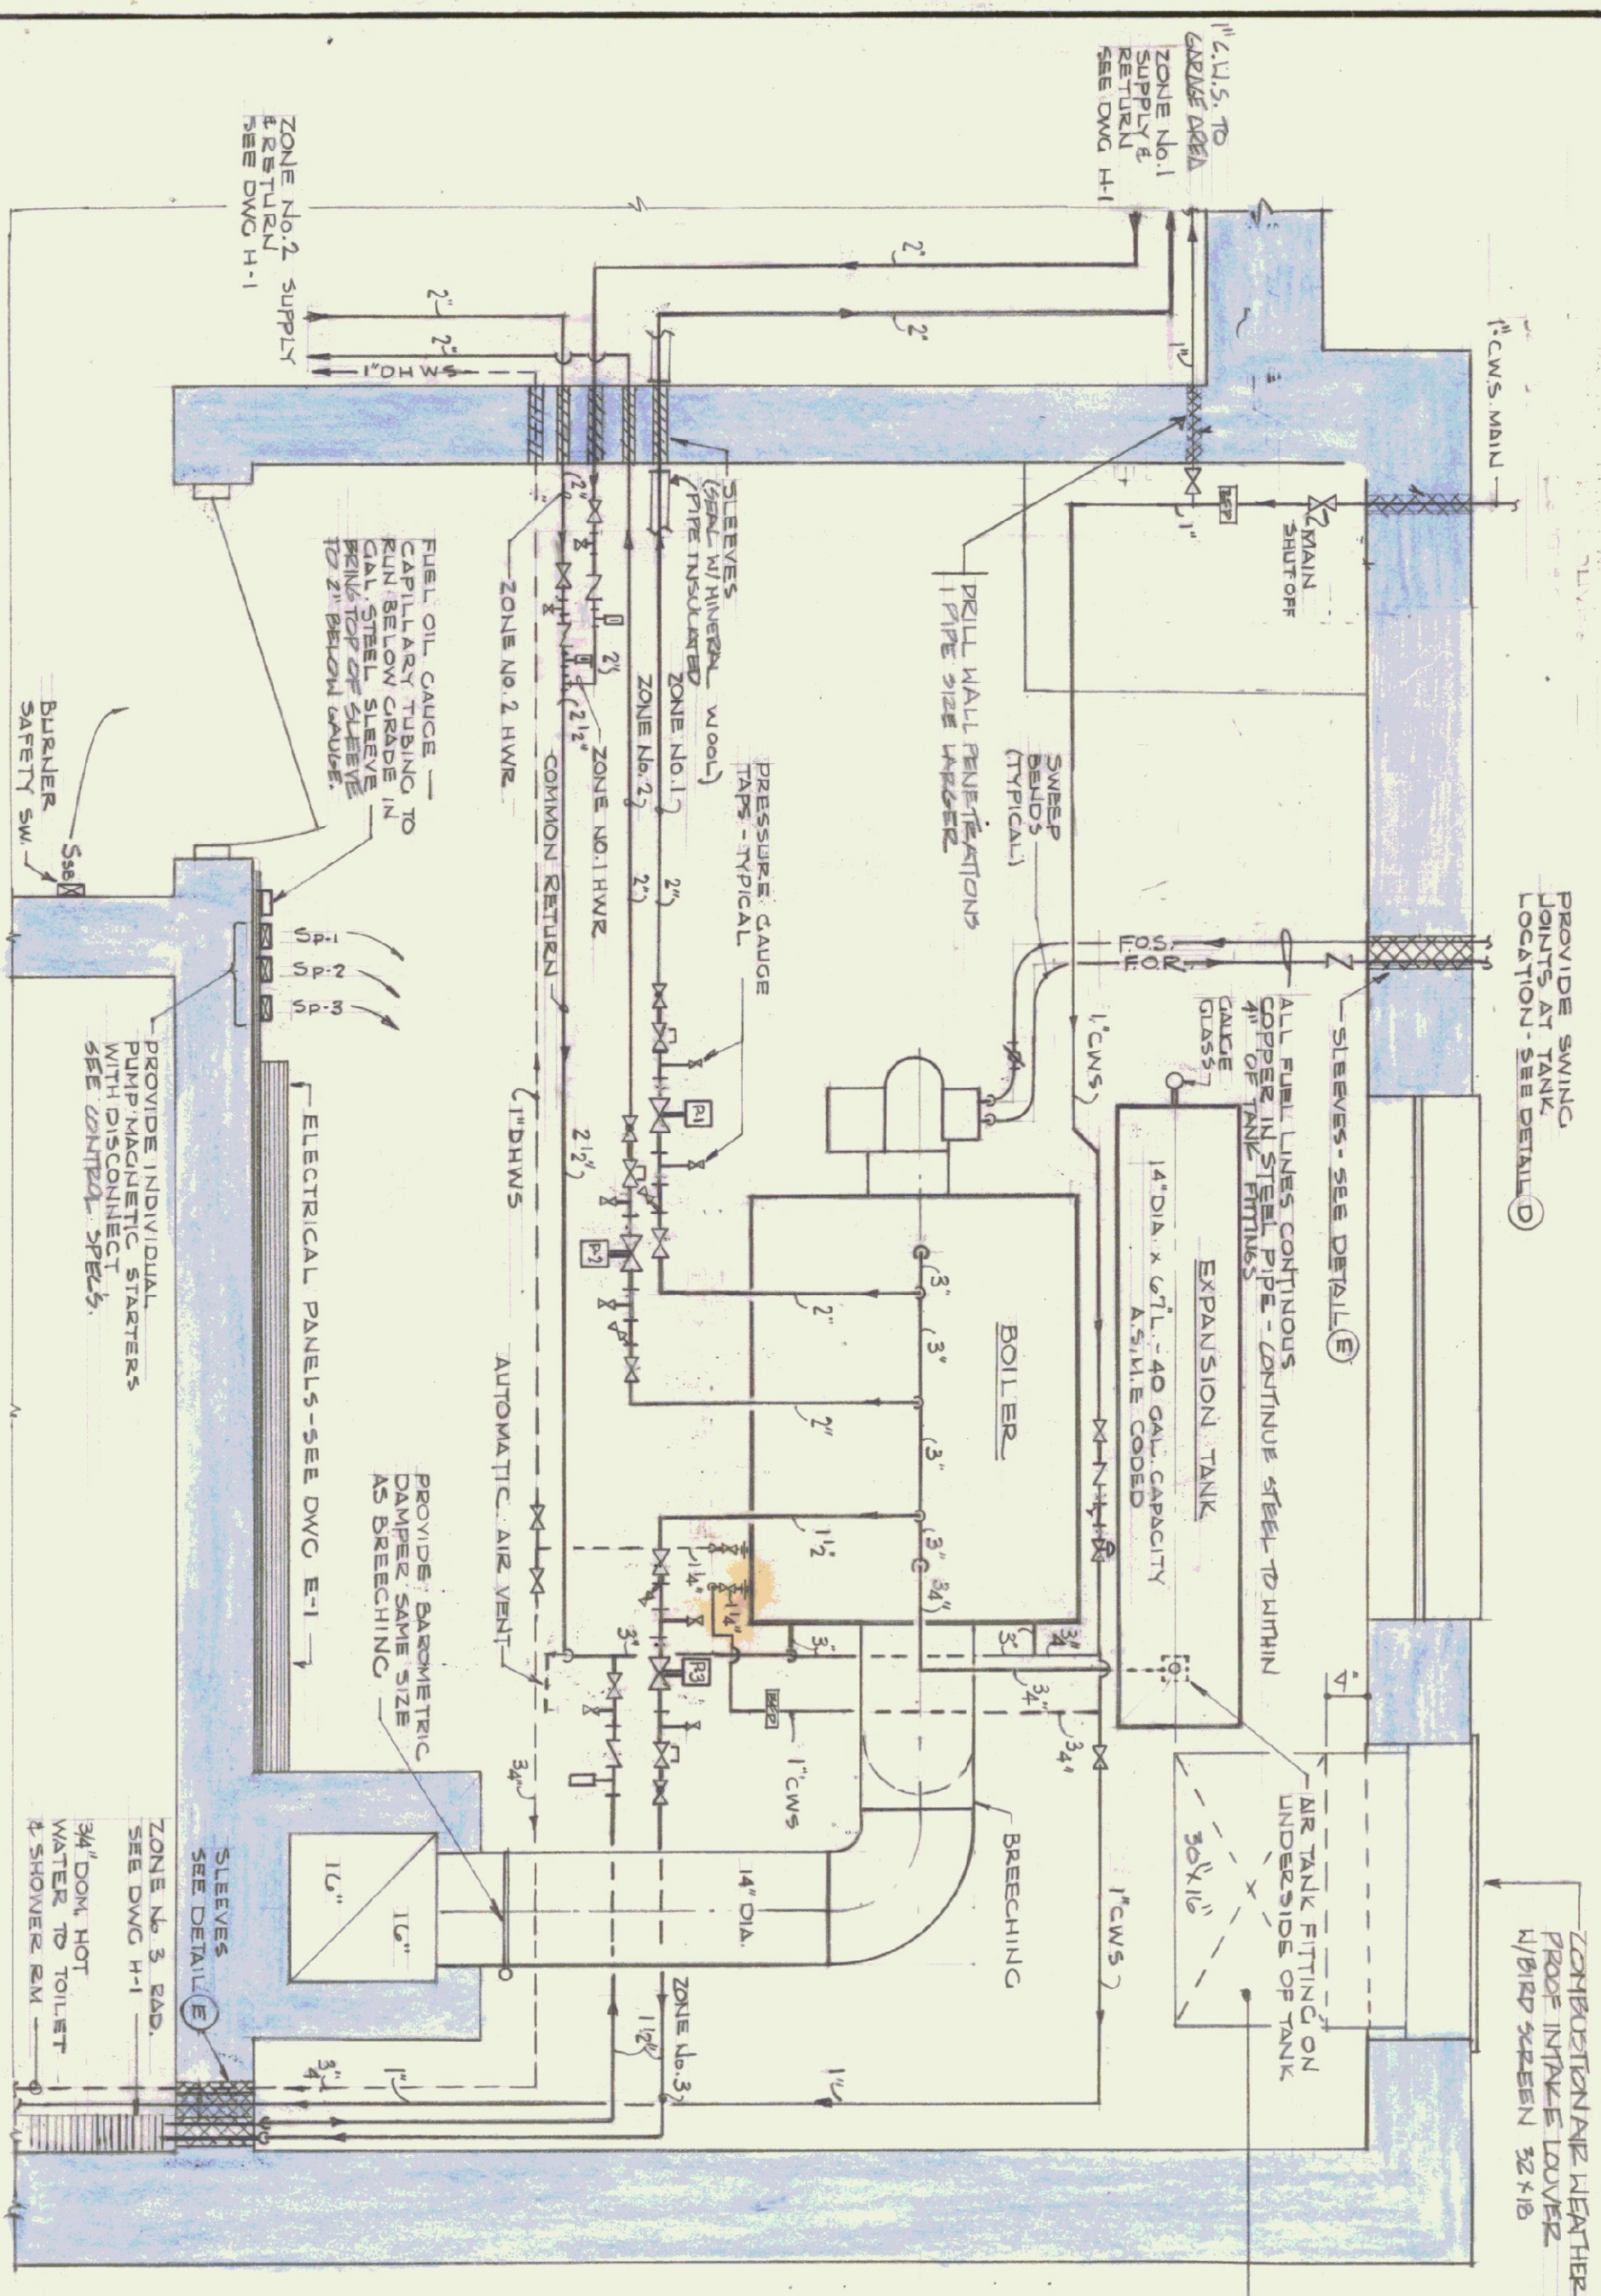

HEATING EQUIPMENT SCHEDULE (RATINGS @ 130° F.W.T. W/20° DIFFERENTIAL)									
MARK	TYPE	MANUFACT.	MODEL	M.B.H.	H.P.	DISCHARGE	R.P.M.	C.F.M.	REMARKS
H#H 1/2	UNIT HEATER	MOHME	HS-55	100	1/4	HORIZ.	1075	2090	WITH NOISE REDUCED GOOD ADJUSTABLE W/20° DIFF. UNIT
V#H 1/2	UNIT HEATER	MOHME	V-810	145	1/4	VERTICAL	1075	3550	
P-1	IN-LINE	BELL & GOSSETT	60-2A4	40 GPM	3/4	5 1/4" IMP.	1725	25 HD	
P-2	IN-LINE	BELL & GOSSETT	60-2A4	40 GPM	3/4	5 1/4" IMP.	1725	25 HD	
P-3	IN-LINE	BELL & GOSSETT	60-12A	25 GPM	1/2	5 1/4" IMP.	1725	25 HD	
P-4D	STERLING SH-15 VERTICAL	STERLING	S-144	102					1 1/4" IPS, STERLING TYPE 40 P.S.I. PER FT.

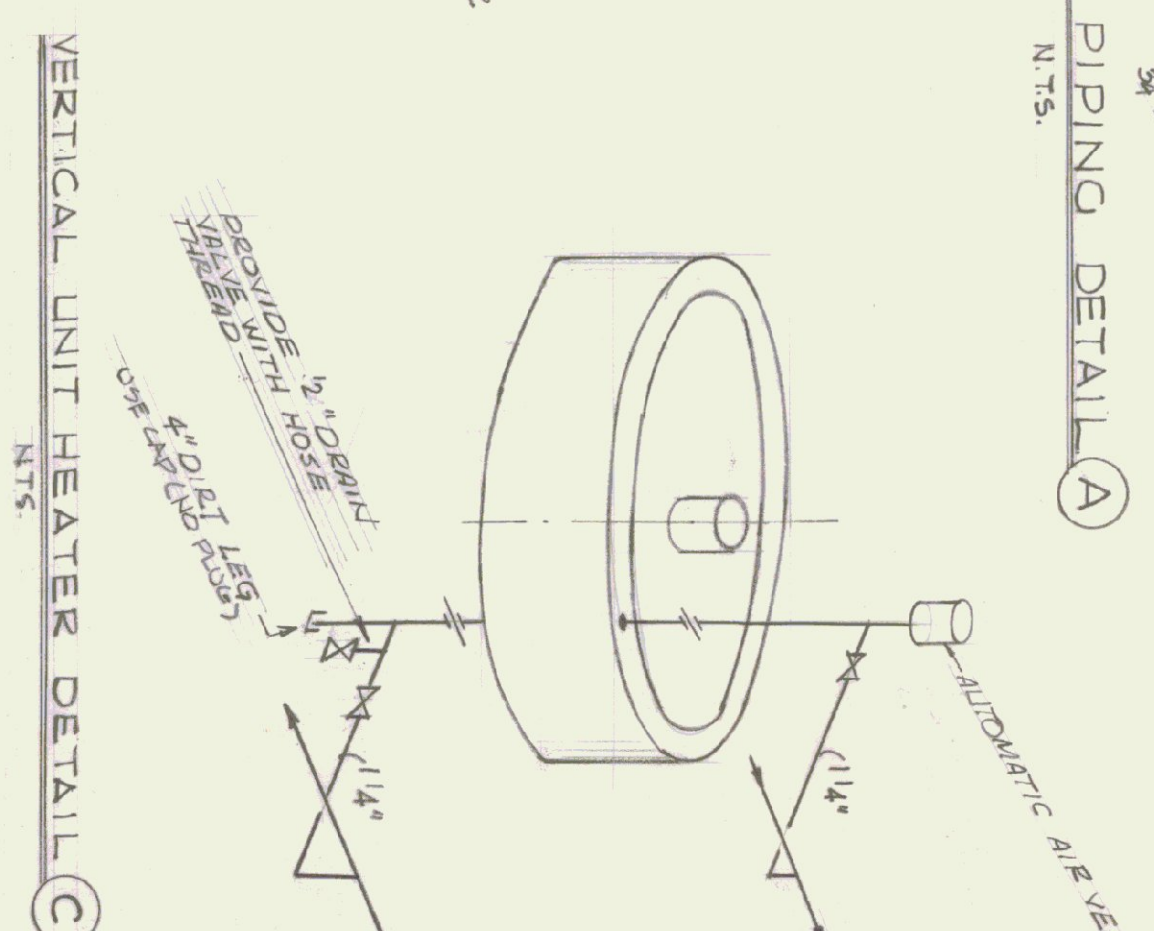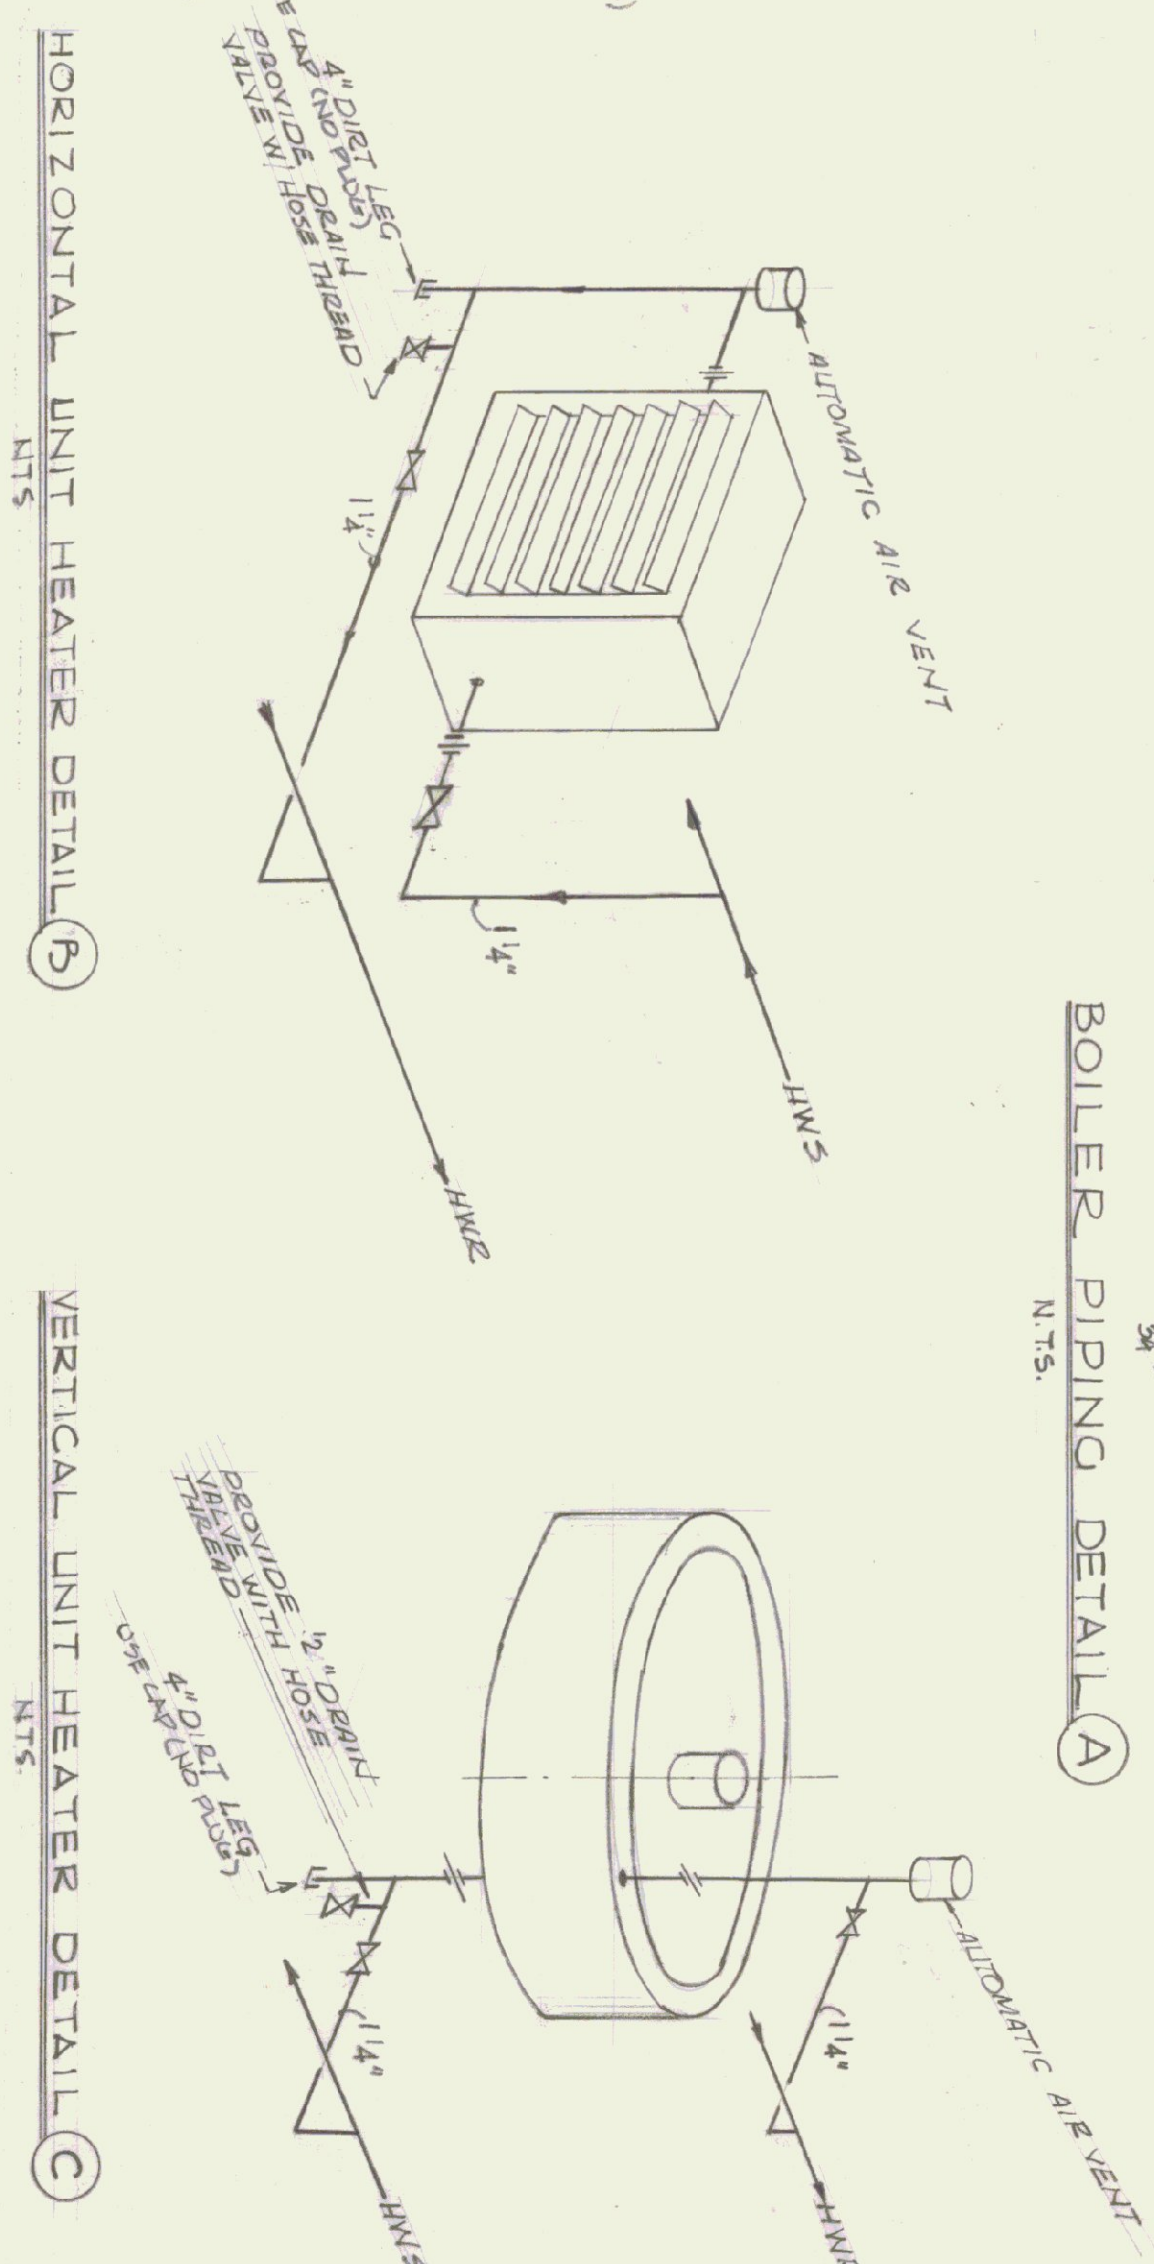

- # GENERAL NOTES
1. CONTRACTOR SHALL SUBMIT DATA & CUTS OF EQUIPMENT FOR APPROVAL PRIOR TO ORDERING MATERIAL.
 2. ALL PIPING IS SCHEMATIC; CONTRACTOR SHALL CO-ORDINATE HIS WORK WITH OTHER TRADES.
 3. MOTORS ON ALL NEW UNIT HEATERS SHALL BE TOTALLY ENCLOSED FRAME CONSTRUCTION WITH PERMANENT OVERLOAD PROTECTION & BUILT-IN THERMAL OVERLOAD PROTECTION.
 4. HEATING CONTRACTOR SHALL PROVIDE SERVICE SWITCH AT EACH UNIT HEATER.
 5. SEE SITE PLAN FOR LOCATION OF BURIED OIL TANK.

5. ALL WATER SUPPLY PIPING ABOVE FLOOR SLAB ELEVATION SHALL BE INSULATED. INSULATION SHALL BE PAINTED.
7. ALL HEATING PIPING IN THE BOILER RM, MAIN BUILDING, & THRU SLEEVES SHALL BE INSULATED AND THE INSULATION PAINTED.
8. EACH CIRCULATING PUMP SHALL HAVE BUILT-IN THERMAL OVERLOAD PROTECTION.
9. EACH UH SHALL HAVE AN AQUASTAT CONTROL TO PREVENT THE FAN FROM OPERATING BELOW A PREDETERMINED MIN TEMP. TO PREVENT COLD SURFACES FROM FORMING ICE. THE SURFACES SHALL SWITCH FANS AND CIRC. PUMPS OFF WHEN HEAT DEMAND IS SATISFIED.
10. ALL PUMPS SHALL BE RATED TO OPERATE ON 120/240V/1PH/3W UNLESS OTHERWISE SPECIFIED OR INDICATED.
11. PROVIDE ONE OIL BURNER SAFETY SWITCH OUTSIDE OF BOILER RM DOOR AND ANOTHER AT MAIN ENTRANCE OF BUILDING AT HAD POOL.
12. BOILER RM FINISHED FLOOR TO BE SAME ELEV. AS MAIN FINISHED FLOOR BUT SHALL BE PITCHED TOWARD DRAIN.
13. CONCRETE BOILER PAD SHALL BE LEVEL. (BT O.C.)

- HEATING CONTRACTOR SHALL SET SLUICES AND HANGER SUPPORTS IN BOLLETS IN CONCRETE ROOF SLAB BEFORE POURING OF SLAB. NO OPENINGS THRU CONCRETE ROOF SLAB ALLOWED.

DATE		DESIGNED BY:		DWG. NO.	
10-18-74		C. J. MASTRO		H 2	
DRAWN BY:		APPROVED BY:			
J. C. SEVER, INC.		J. C. SEVER, INC.		2 OF 2	

SMITH CRAFT "TECH" 30. TEC. 2-405 DREDAUN
(MOUNT ON BOTTOM OF JOISTS)

TRANSFER SWITCH

DISCONNECT (FUSED) FOR WELL PUMP
PROVIDE CONDUIT & WIRING TO
DISTRIBUTION PANEL.

- ① 100 AMP WELDER OUTLET
- ALLOW FOR TELEPHONE SLEEVE THRU EXTERIOR WALL
- COORDINATE WITH LOCAL TELEPHONE CO.

ALL WALL OUTLETS OF OFFICE & ROOM SPACES SHALL BE AT LEAST 36" OFF FLOOR. (IN BOLTER RM. KEEP OUTLETS MIN 3'-0" ABOVE PL.

S_{3B} BURNER SAFETY SWITCH - MOUNT 6'-0" ABOVE FIN. FL.

ALL ELECTRICAL CONDUIT FOR OFFICE, TOILET, TOOL RM AND GEAR RM, CEILINGS SHALL BE CONCEALED IN THE CONCRETE MEZZANIN SLAB.

ALL WALL RECEPTACLES AND CONDUIT BELOW BOTTOM OF BAR JOISTS SHALL BE CONCEALED, EXCEPT TO U.H. HOODS


POWER PANEL SCHEDULE	
CIRCUIT BREAKER TYPE	NBS WESTINGHOUSE 120/240V 1" SW
PANEL #	400 AMP MAIN DISCONNECT - 10,000 ICR BREAKERS 30 POLES
LOCATION	INDUSTRIAL

CIRC.	100	6	EQUIPMENT SURVIVED	10	REPAIRS
P-1	100	6	EQUIPMENT NOT FOUND		
P-2	100	5	MISSING SUBJECTS		
P-3	100	2	do		LFP BRK.
P-4	20	1	TOLY & ANNE ECH. SUBJECT		
P-5	20	1	MISS. EVIDENCE		
P-6	20	1	SHOP LIGHTING		
P-7	20	1	do		LFP BRK.
P-8	20	1	SHOP RECEPTIONAL (ROOM)		
P-9	20	1	do (ROOM)		
P-10	20	1	do		
P-11	20	1	HID-BAY RECEIVING JERRY		
P-12	20	1	SHOP RECEIVING AREA		LFP BRK.
P-13	20	1	CIRC. PUMP ROOM "2"		
P-14	20	1	SPARE		
P-15	20	1	do		
P-16	20	1	do		

EMERGENCY DUTY PANEL SCHEDULE

PANEL NO.	CIRCUIT BREAKER TYPE	VOLTS	AMPS	FUSE	REMARKS
PANEL 100	1" 3 WIRE	100 AMP	N/A	N/A	

CLASS.	NO.	EQUIPMENT	STATUS	REMARKS
1	40	AIR COMPRESSOR	1	
2	20	BURNER	1	
3	20	WELL PUMP	1	
4	20	GAS PUMP		
5	20	OFFICE LIGHTING		
6	1	HEAT. LIGHTING		
7	10	SHOP LIGHT (CHINA) 100		
8	20	BOILER ROOM LIGHTING		
9	1	BOILER ROOM HEATER		
10	20	HEAT. L.T.B.		
11	20	CIRC. PUMP ROOM		
12	10	CIRC. PUMP ROOM		
13	20	OFFICE REFRIGERATOR		
14	20	STOVE		
15	1			

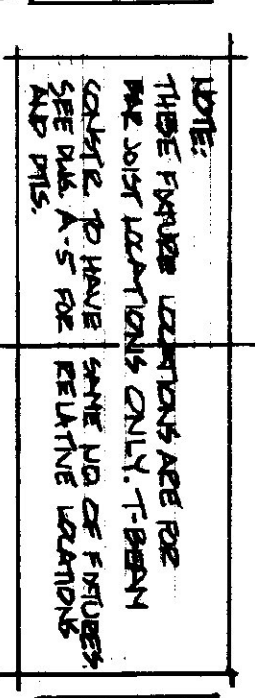

SCALE: 1/2" = 1'-0"

SCALE: 1 x 1 -

STATE OF VERMONT
DIVISION OF STATE BUILDINGS
AGENCY OF ADMINISTRATION
MONTPELIER, VERMONT


Standard Four Bay Highway Garage Bldg.
ELECTRICAL PLAN

DATE: Aug. 2018

DATE 10-10-74	RECEIVED BY SUN MASTED.	FILE NO. E-1
ISSUED BY 	RECEIVED BY 	

GENERAL NOTES

- SMITHCRAFT 'TECH' 30-TEC. 2-405 (MOUNT ON BOTTOM OF JOISTS)
- WESTINGHOUSE 1-TUBE RS STRIP 5 STIMOR (MOUNT BETWEEN JOISTS)
- SMITHCRAFT DOMINAIRE 6-DMA-2-40 (SURFACE MOUNT TO CEILING)
- THERMOSTAT - CONNECT TO CIRCUIT 12 AND TO SUB-PANEL CIRCUIT 4. MOUNT ON PLYWOOD 5'-6" OFF FLOOR (SEE H-1)
- 50 AMP WELDER OUTLET
- ALLOW FOR TELEPHONE SLEEVE THRU EXTERIOR WALL COORDINATE WITH LOCAL TELEPHONE CO.
- ALL WALL OUTLETS OF OFFICE & ROOM SPACES SHALL BE AT LEAST 36" OFF FLOOR (IN BOILER RM. KEEP OUTLETS MIN. 3'-0" ABOVE FL.)
- 50 AMP BURNER SAFETY SWITCH - MOUNT 6'-0" ABOVE FIN. FL.
- ALL ELECTRICAL CONDUIT FOR OFFICE TOILET, TOOL RM. AND GREASE RM. CEILING SHALL BE CONCEALED IN THE CONCRETE MEZZANINE SLAB.
- ALL WALL RECEPTACLES AND CONDUIT BELOW BOTTOM OF BAR JOISTS SHALL BE CONCEALED.

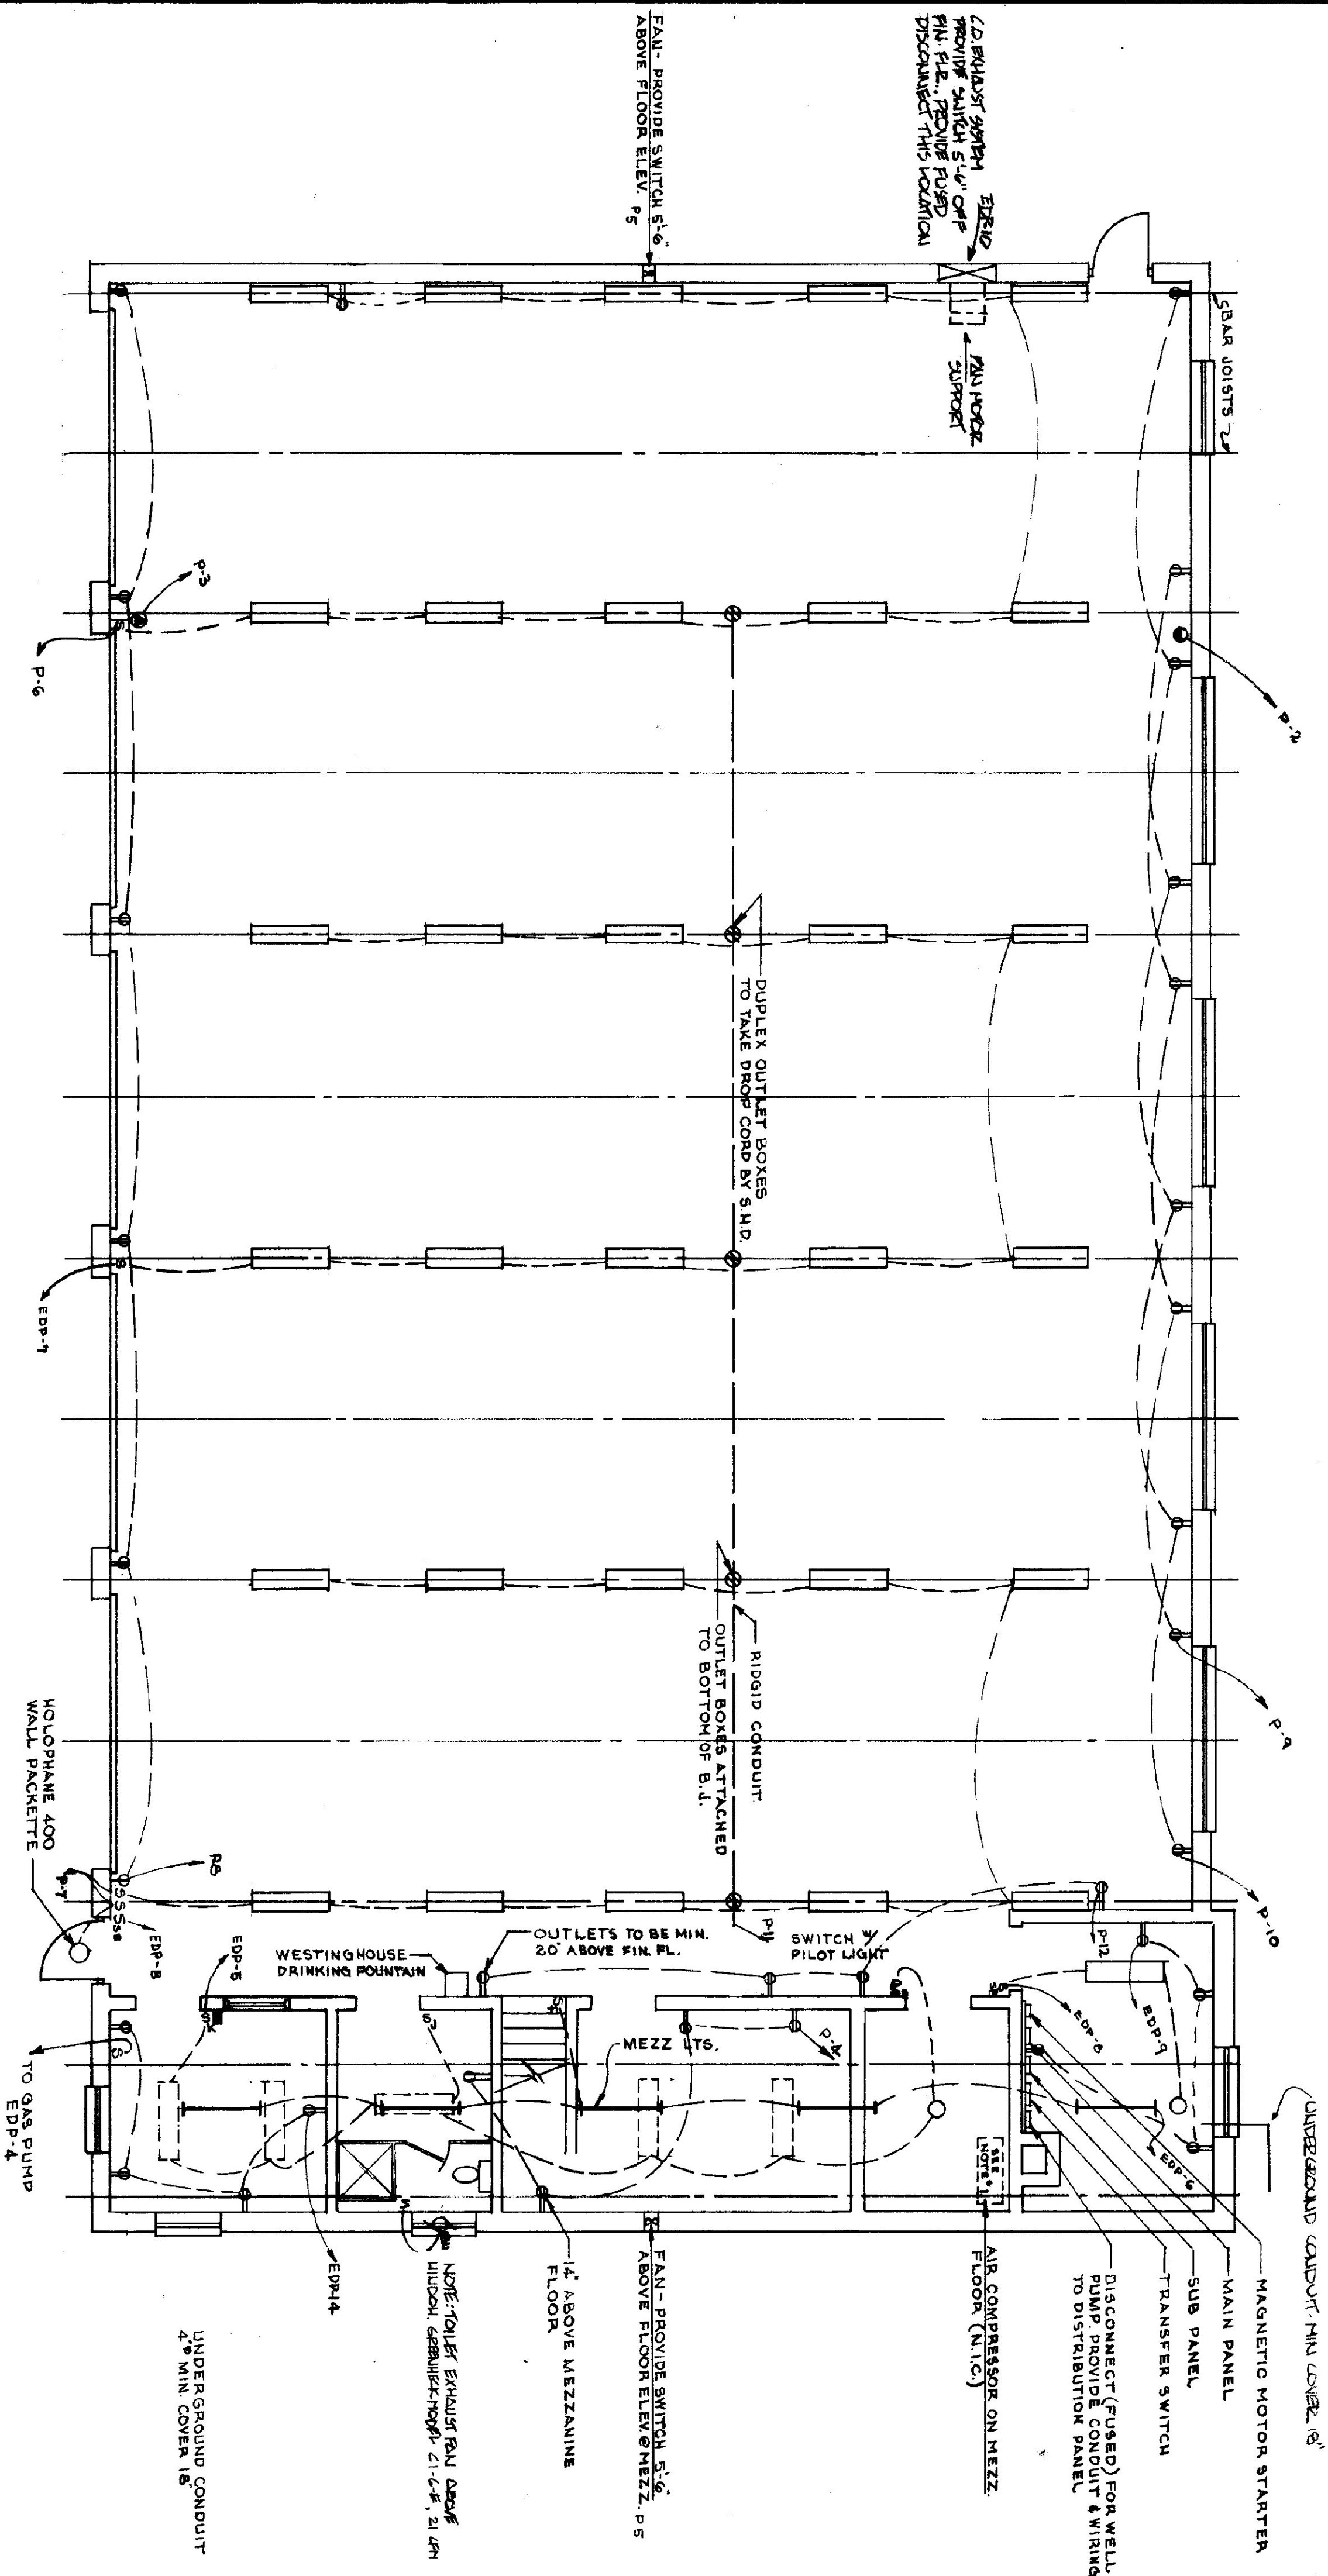

ELECTRICAL PLAN
(5 DAY)
SCALE: 1/8"=1'-0"

POWER PANEL SCHEDULE					EMERGENCY DISTRIBUTION PANEL SCHEDULE				
CIRC.	AMP.	BREAKER TYPE	STYLE NO.	REMARKS	CIRC.	AMP.	BREAKER TYPE	REMARKS	
PANEL P-1	3W 400 AMP	MAIN DISCONNECT	10,000 TOR BRK 30(COULDS)		PANEL EDP	80 POLE MIN. 120/240 15 WIRE 100 AMP MAIN DISCONNECT			
P-1	100	2	EMERGENCY DIST. PANEL		P-1	40	2	AIR COMPRESSOR	
P-2	50	2	WELDING RECEPTACLE		P-2	20	1	BURNER	1
P-3	20	2	do		P-3	20	2	WELL PUMP	1
P-4	20	1	TOILET & STOR. RM. RECEPT.		P-4	20	1	GAS PUMP	
P-5	20	1	BLOC. EXHAUST		P-5	20	1	OFFICE LIGHTING	
P-6	20	1	SHOP LIGHTING		P-6	20	1	MEZZ LIGHTING	
P-7	20	1	do		P-7	20	1	SHOP LIGHTING (MIDDLE BAY)	
P-8	20	1	SHOP RECEPTACLES (FRT)		P-8	20	1	BOILER ROOM LIGHTING	
P-9	20	1	SHOP RECEPTS (REAR)		P-9	20	1	BOILER ROOM RECEPTS	
P-10	20	1	do		P-10	20	2	VEHICULAR ENH. FAN	2
P-11	20	1	MID BAY RECEPT. 150TS.		P-11	20	1	HUN. 1, 2, 3,	
P-12	20	1	SHOP RECEPTS		P-12	20	1	CIRC. PUMP ZONE 1	3
P-13	20	1	CIRC. PUMP (ZONE 2)	2	P-13	20	1	CIRC. PUMP ZONE 3	2
P-14 to 16	20	1	SPARES		P-14	20	1	OFFICE RECEPTACLES	
P-17 to 19	30	2	SPARES		P-17	15	17	SPARES	
P-20 to 24	20	1	SPARES						

REVISIONS

NO.	DATE	REVISION
1	10-18-74	REVISION

STATE OF VERMONT
DIVISION OF STATE BUILDINGS
AGENCY OF ADMINISTRATION
MONTPELIER, VERMONT

Standard Five Bay Highway Garage Bldg.
ELECTRICAL PLAN

SCALE: 1/8"=1'-0"

DESIGNED BY: [Signature]
CHECKED BY: [Signature]
DATE: 10-18-74
DRAWN BY: [Signature]
DATE: 10-18-74

FIG. NO. E-1