



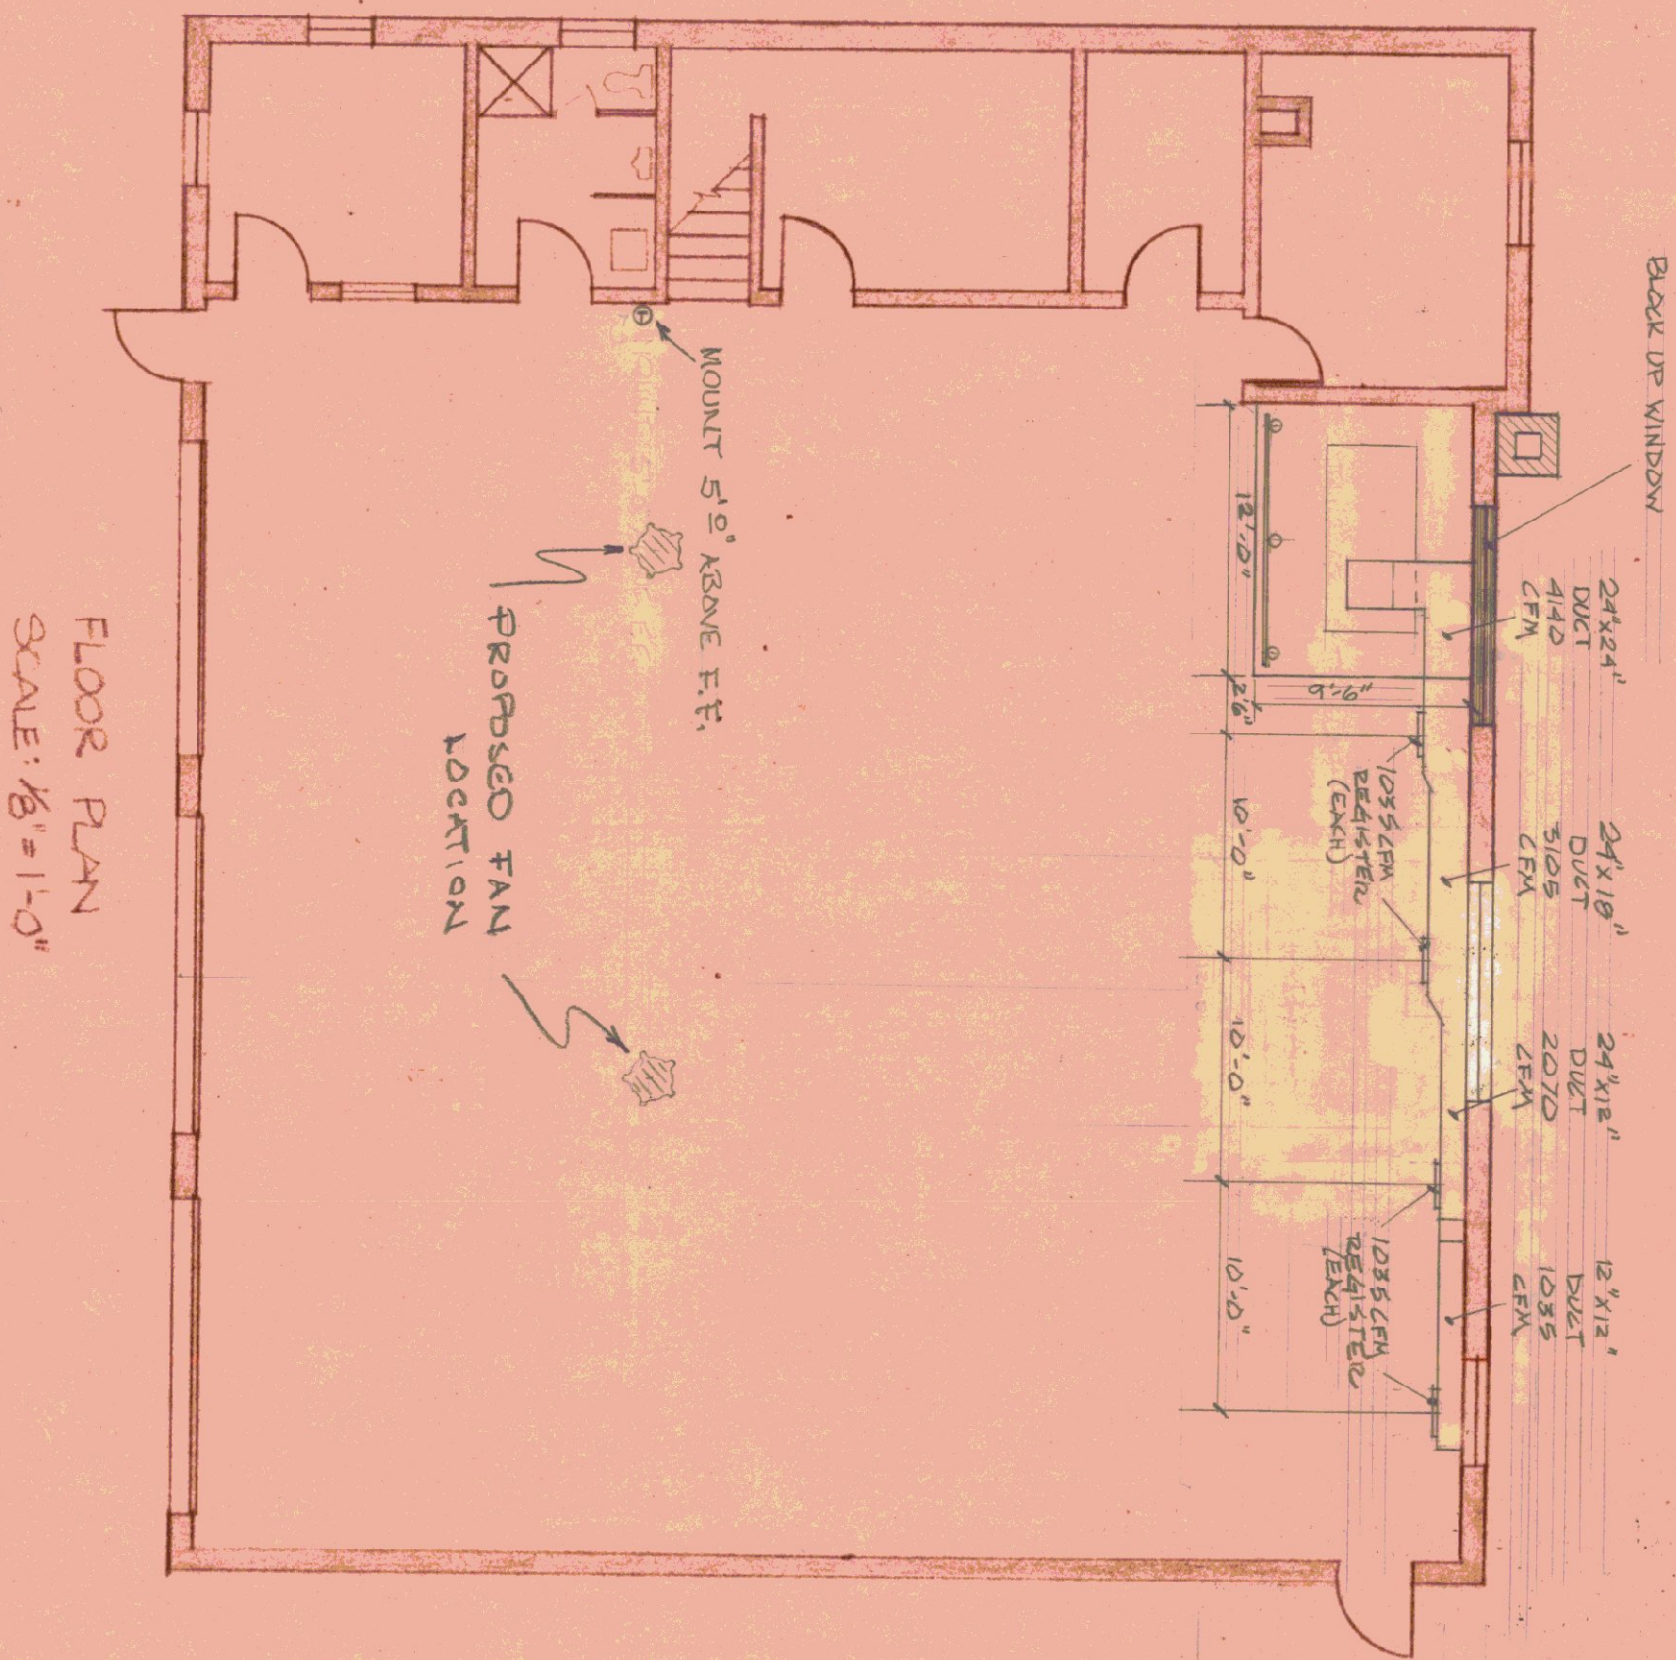

FLOOR PLAN
SCALE: 1/8" = 1'-0"

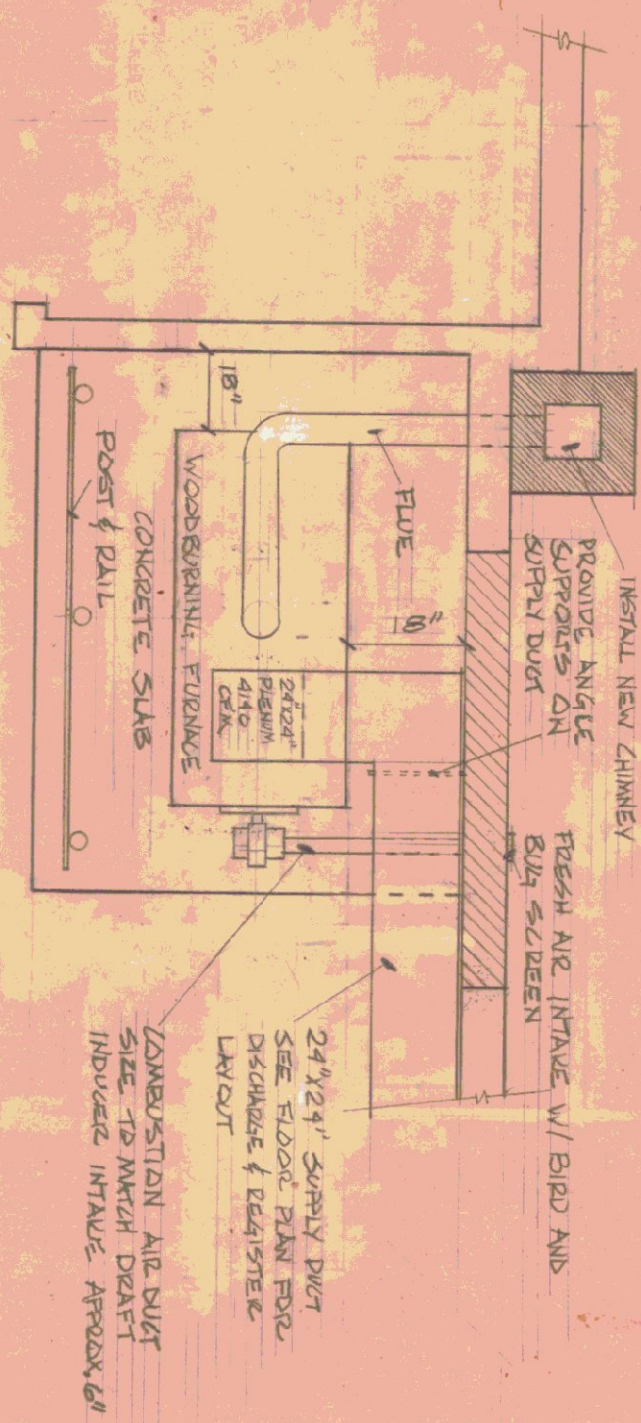

NOTE: FOR ADDITIONAL
DETAILS SEE SHEET 2.

STATE OF VERMONT			
DIVISION OF STATE BUILDINGS			
AGENCY OF ADMINISTRATION			
MONTPELIER, VERMONT			
WOODBURNING FURNACE INSTALLATION			
MILKING, VERMONT			
DATE: 7-21-80	SCALE: AS NOTED	REVISIONS: 10-17-80 RM 10-23-80 RM	DWG. NO. 1 OF 3
DRAWN BY: JCF/RAT	APPROVED BY: JMM/MS		