

NEW REGIONAL EMERGENCY
OPERATING CENTER

DEPARTMENT OF PUBLIC SAFETY
CIVIL DEFENSE DIVISION

DUMMERSTON, VERMONT
CHARLES A. BRISTOW, COMM.

DEPARTMENT OF STATE BUILDINGS
JOHN J. ZAMPIERI, COMM.

ARCHITECTS:



GORDON G. WOODS ASSOC. ARCHITECTS, BURLINGTON VERMONT

MECHANICAL ELECTRICAL ENGINEERS:

RICHARD D KIMBALL CO. READING MASSACHUSETTS

STRUCTURAL ENGINEERS:

KNIGHT CONSULTING ENGINEERS INC. WILLISTON, VERMONT

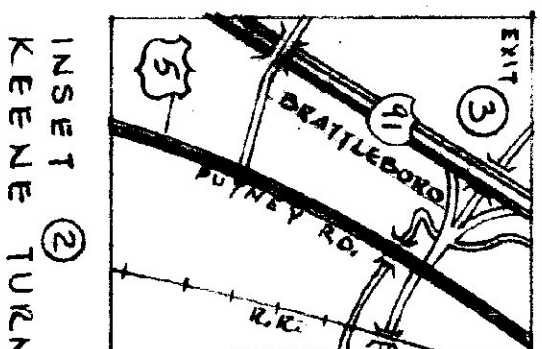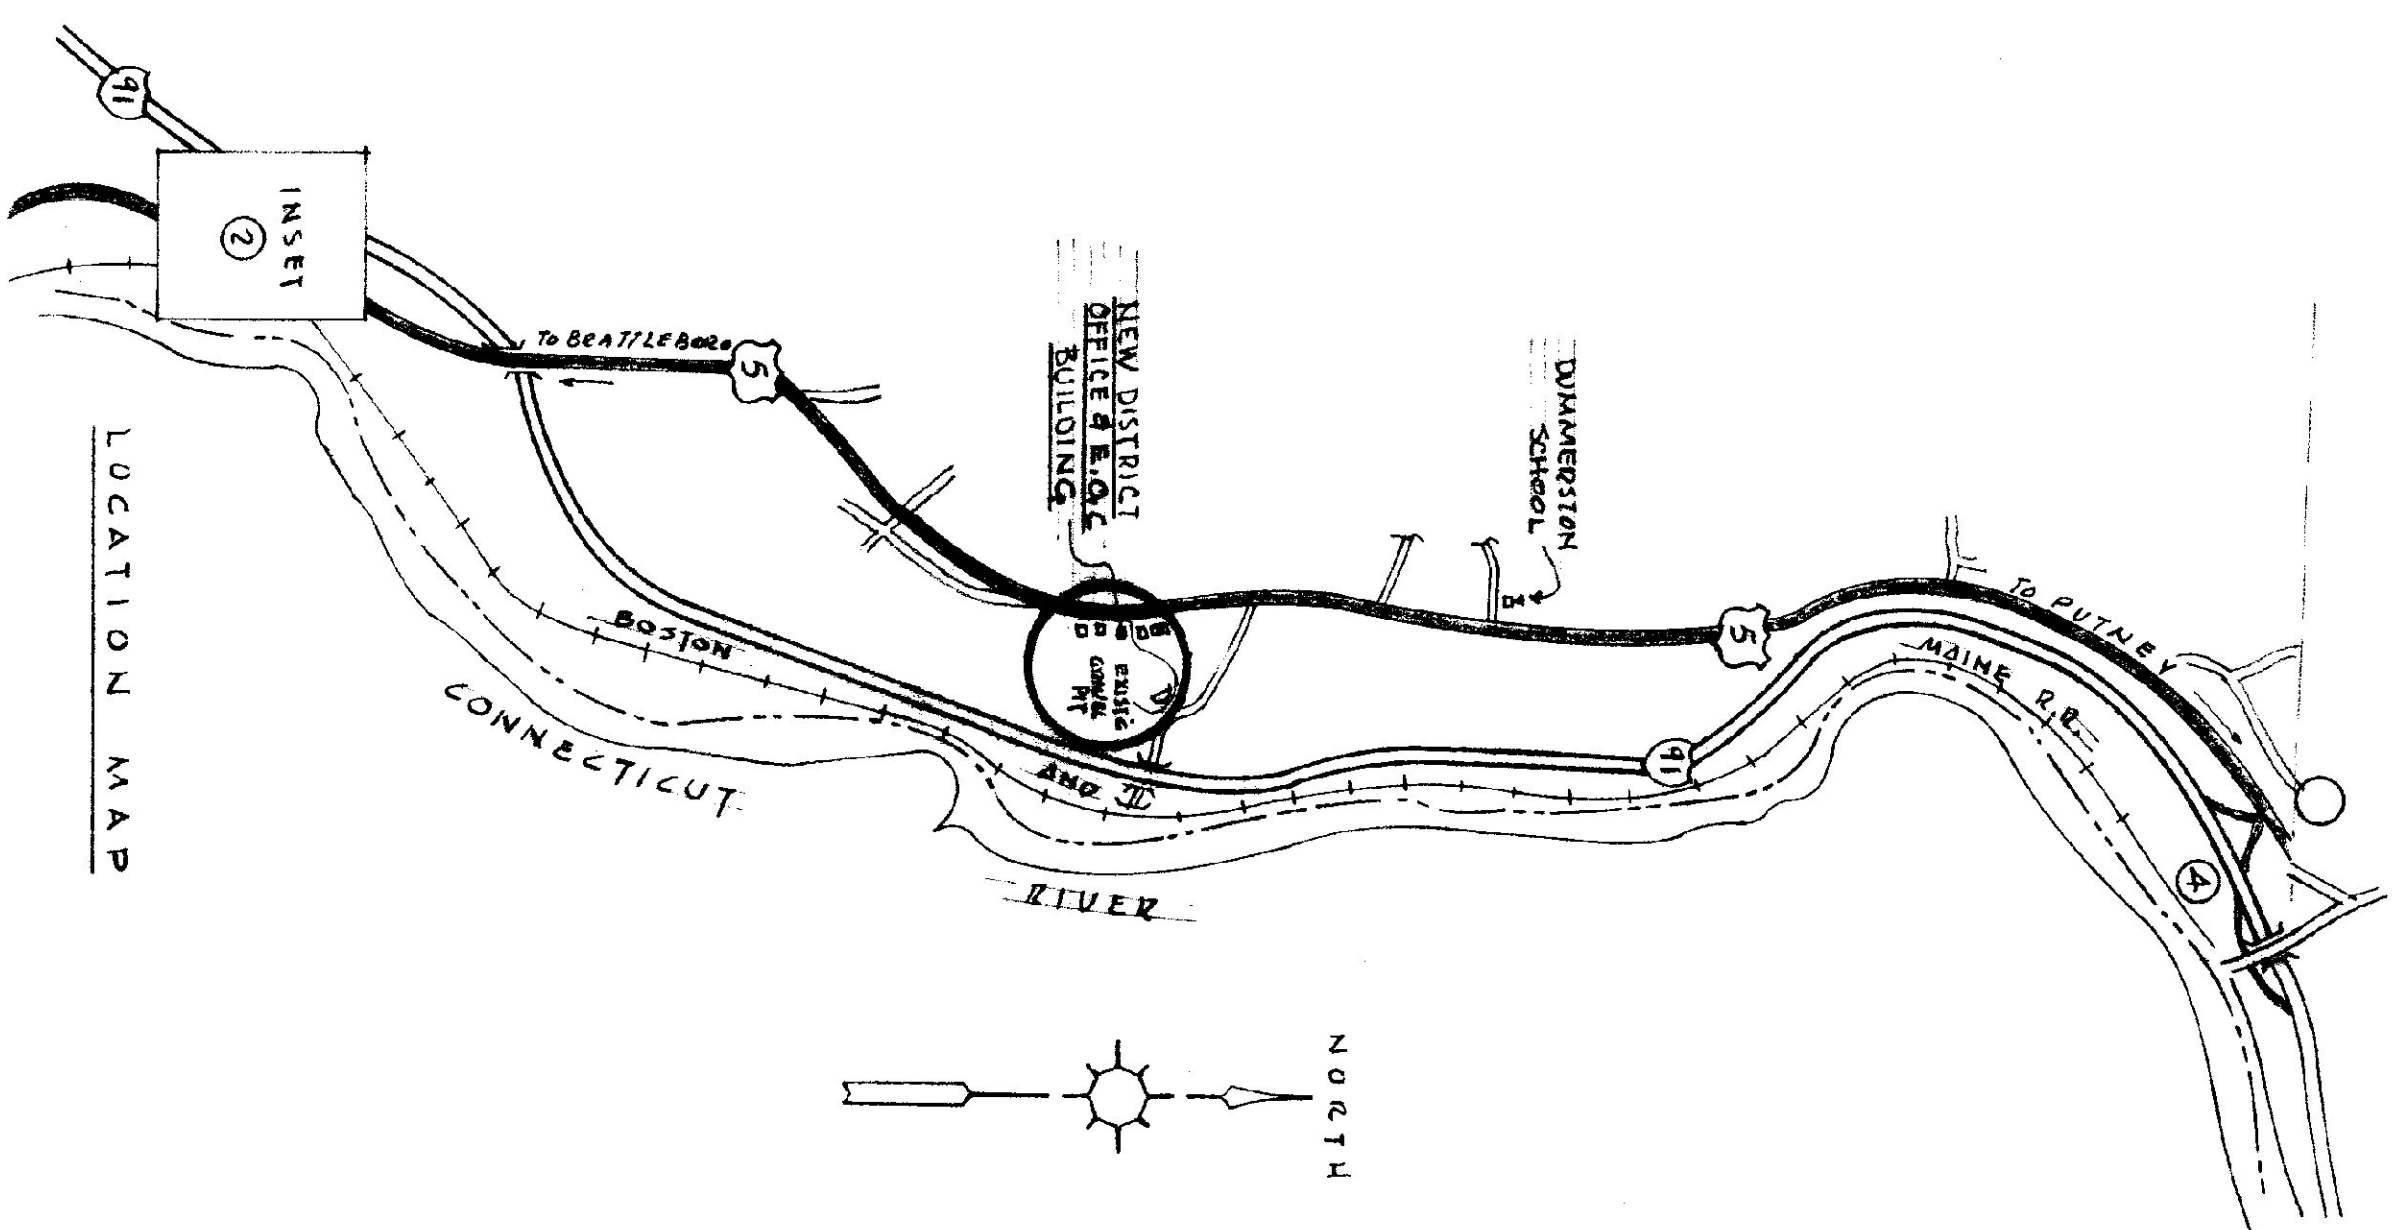

REGIONAL EMERGENCY OPERATING CENTER
STATE OF VERMONT - STATE BUILDINGS DEPT.
CIVIL DEFENSE DIV. DUMMERSTON, VERMONT
GORDON G. WOODS ASSOC. ARCHITECTS, BURLINGTON, VERMONT

REVISIONS	BY

DESIGNED BY	SM/JSW/SW
CHECKED	
DATE	MAR. 27/1985
SCALE	NONE
JOB NO.	4420
SHEET	6
CS	Ed.C.

ARCHITECTURAL DRAWINGS

- CS. COVER SHEET - EMERGENCY OPERATING CENTER
R-1 REFERENCE SHEET - E.O.C.
SITE PLANS - SEE SP1 & SP2
- A-1 LOWER LEVEL - EMERGENCY OPERATING CENTER
A-2 SECTIONS & DETAILS - E.O.C.
- G-1 LOWER LEVEL - EMERGENCY OPERATING CENTER - CEILING LAYOUT
- M-1 LOWER LEVEL - EMERGENCY OPERATING CENTER - MASTER PLAN

STRUCTURAL

STRUCTURAL PLANS - SEE AGENCY OF TRANSPORTATION DRAWINGS


MECHANICAL & ELECTRICAL

- P-1 LOWER LEVEL - EMERGENCY OPERATING CENTER - PLUMBING
P-2 LOWER LEVEL - EMERGENCY OPERATING CENTER - WIRE DIAGRAM
- HVAC - 1 LOWER LEVEL - EMERGENCY OPERATING CENTER - HEATING
HVAC - 2 LOWER LEVEL - EMERGENCY OPERATING CENTER - DETAILS
- E-1 LOWER LEVEL - EMERGENCY OPERATING CENTER - ELECTRIC
E-2 LOWER LEVEL - EMERGENCY OPERATING CENTER - POWER
L-1 LOWER LEVEL - EMERGENCY OPERATING CENTER - LIGHTING

ABBREVIATIONS


A.F.F.	ABOVE FINISH FLOOR	SH.T.	SHEET
ALT.	ALTERNATE	SPEC. INSTR.	SPECIAL INSTRUCTION
BIT. CONC.	BITUMINOUS CONCRETE	STL.	STEEL
CHT.	CEILING HEIGHT	STOR.	STORAGE
CHAN.	CHANNEL	TEMP.	TEMPERED
C.J.	CONTROL JOINT	THK.	THICK
CLF.	CEILING	T.O.S.	TOP OF STEEL
C.M.U.	CONCRETE MASONRY UNIT	TR.	TYPICAL
CONC.	CONCRETE	UR.	URINAL
CONF.	CONFERENCE	VAR.	VARIABLES
DRAWG.	DRAWING	VAT.	VINYL ASBESTOS TILE
ELEV.	ELEVATION	VEST.	VESTIBULE
FIN.	FINISH	W.C.T.	WAINSCOT
FL.	FLOOR		
GYP.BD.	GYP.SUM BOARD	CH.B.	CHALK BOARD
H.M.	HOLLOW METAL	T.B.	TACK BOARD
H.P.	HIGH POINT	VENT.	VENTILATOR
HT.	HEIGHT	V.	VENT
JT.	JOINT	F.D.	FLOOR DRAIN
LAV.	LAVATORY		
MET.	METAL		
MAT.	MATERIAL		
O.C.	ON CENTER		
P.C.C.	PRECAST CONCRETE CURB		
R.D.	ROOF DRAIN		
REQ'D	REQUIRED		

 DRAWING SYMBOLS


	CONCRETE MASONRY UNIT		RIGID INSULATION		ROOM NUMBER
	STEEL		BATT INSULATION		SECTION LETTERS SEE SHEET NUMBER
	GYP.SUM		SEALANT		DOOR NUMBER
	ROUGH WOOD BLOCKING		ACOUSTIC PANELS		FINISHED ELEVATION
	FINISHED WOOD		CARPET		COLUMN LINE
	CONCRETE				ELEVATION NUMBER SEE SHEET NUMBER
	MORTAR & GROUT				
	GRAVEL				
	COMPACTED SOIL				

REGIONAL EMERGENCY OPERATING CENTER
STATE OF VERMONT - STATE BUILDINGS DEPT.
CIVIL DEFENSE DIV. DUMMERSTON, VERMONT
GORDON G. WOODS ASSOC., ARCHITECTS, BURLINGTON, VERMONT


LOWER LEVEL - EMERGENCY OPERATING CENTER

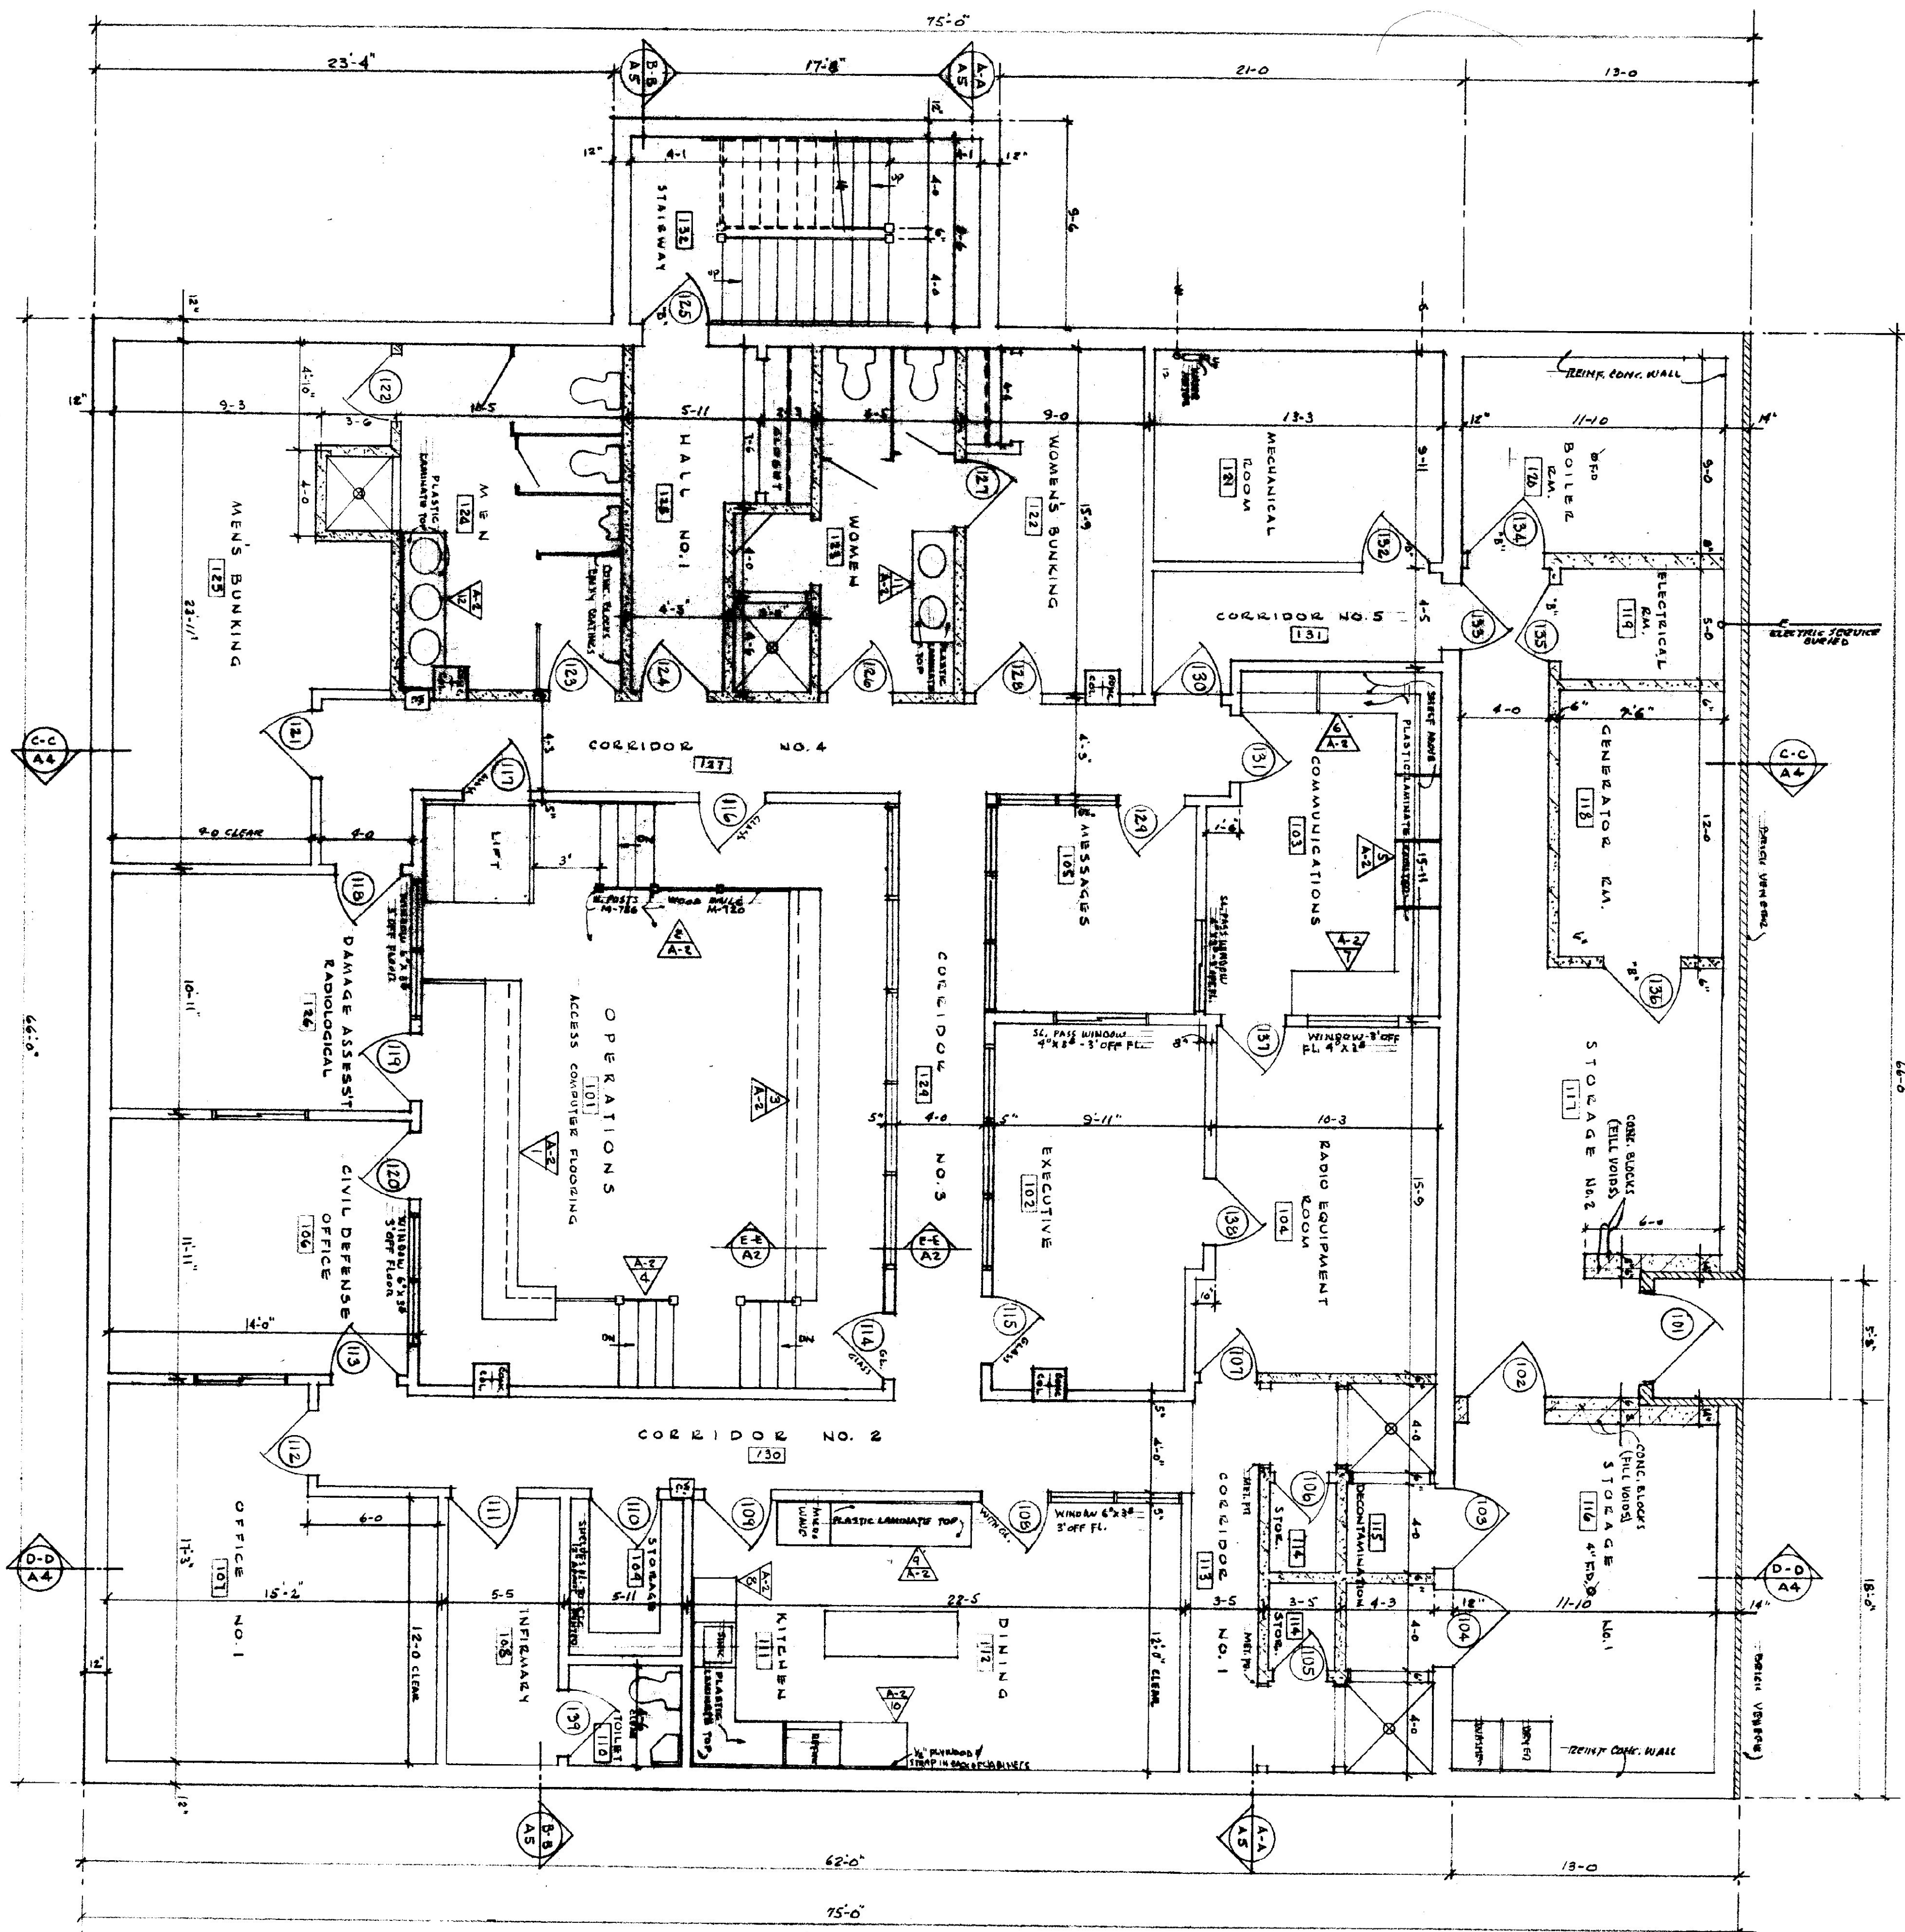

DOOR SCHEDULE									
NO.	SIZE	TRK	FRAME	MAT'L	LABEL	BUTTS	W/PLAT	CLOSER	REMARKS
101	4'x7'	3/4"	1/4" ALUM.	1/4" ALUM.				YES	STEEL CASE - TYPE "F" - SILENT
102	3'x7'	3/4"	"	"		"			"
103	3'x7'	"	"	"		"			"
104	3'x7'	"	"	"		"			"
105	2'x6'	"	"	"		"			"
106	2'x6'	"	"	"		"			"
107	2'x6'	"	"	"		"			"
108	3'x6'	"	"	"		"			"
109	3'x6'	"	"	"		"			"
110	3'x6'	"	"	"		"			"
111	3'x6'	"	"	"		"			"
112	3'x6'	"	"	"		"			"
113	3'x6'	"	"	"		"			"
114	3'x6'	"	"	"		"			"
115	3'x6'	"	"	"		"			"
116	3'x6'	"	"	"		"			"
117	3'x6'	"	"	"		"			"
118	3'x6'	"	"	"		"			"
119	3'x6'	"	"	"		"			"
120	3'x6'	"	"	"		"			"
121	3'x6'	"	"	"		"			"
122	3'x6'	"	"	"		"			"
123	3'x6'	"	"	"		"			"
124	3'x6'	"	"	"		"			"
125	3'x6'	"	"	"		"			"
126	3'x6'	"	"	"		"			"
127	3'x6'	"	"	"		"			"
128	3'x6'	"	"	"		"			"
129	3'x6'	"	"	"		"			"
130	3'x6'	"	"	"		"			"
131	3'x6'	"	"	"		"			"
132	3'x6'	"	"	"		"			"
133	3'x6'	"	"	"		"			"
134	3'x6'	"	"	"		"			"
135	3'x6'	"	"	"		"			"
136	3'x6'	"	"	"		"			"

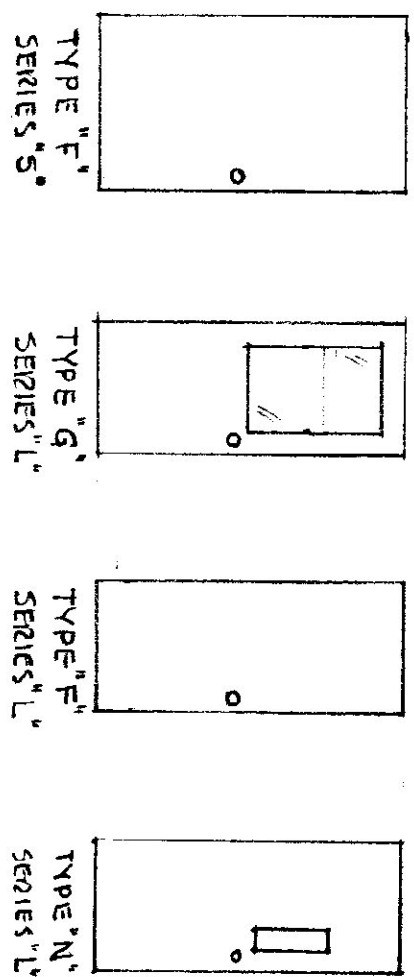


NOTES:
ALL DIMENSIONS TO BE VERIFIED
AT THE SITE BY THE CONTRACTOR.
ANY BELOW OR POINTS IN QUESTION
MUST BE REFERENCED TO THE ARCHITECT
FOR A DECISION BEFORE PROCEEDING
WITH THE WORK.

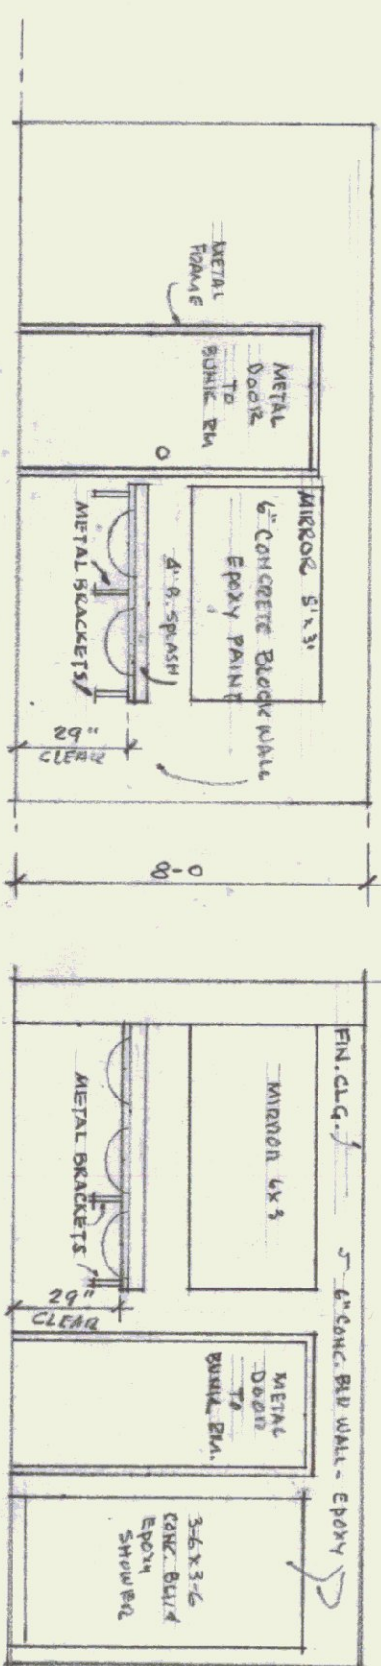

A-1 WOMEN'S TOILET-SINK WALL


A-2 MEN'S TOILET-SINK WALL

TOILET ELEVATIONS-ABOVE

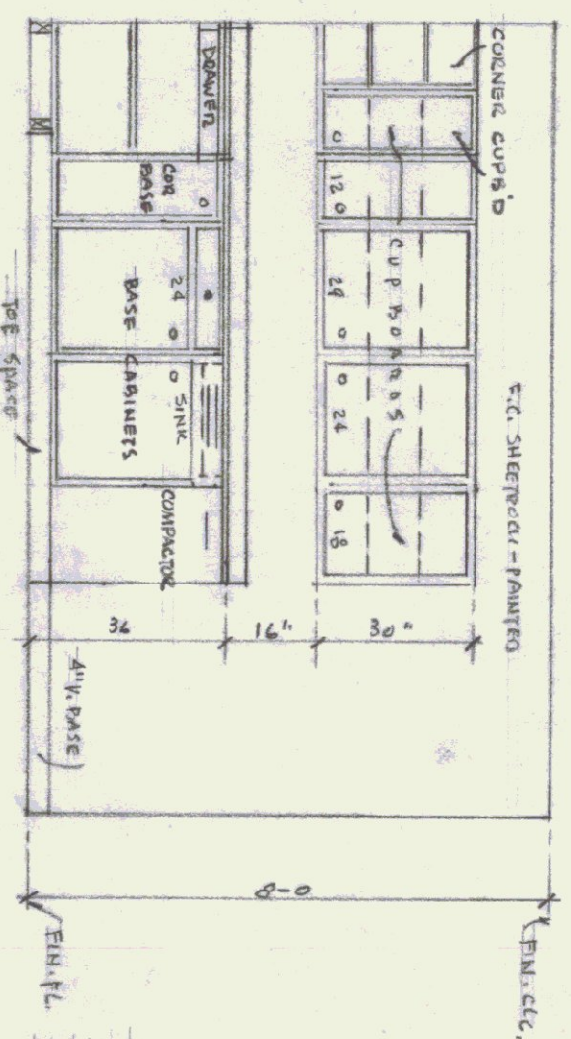


A-3 ELEVATION OF SINK WALL

NOTE: INSTALL 1/2 CDX PLYWOOD IN BACK OF ALL KITCHEN CABINETS

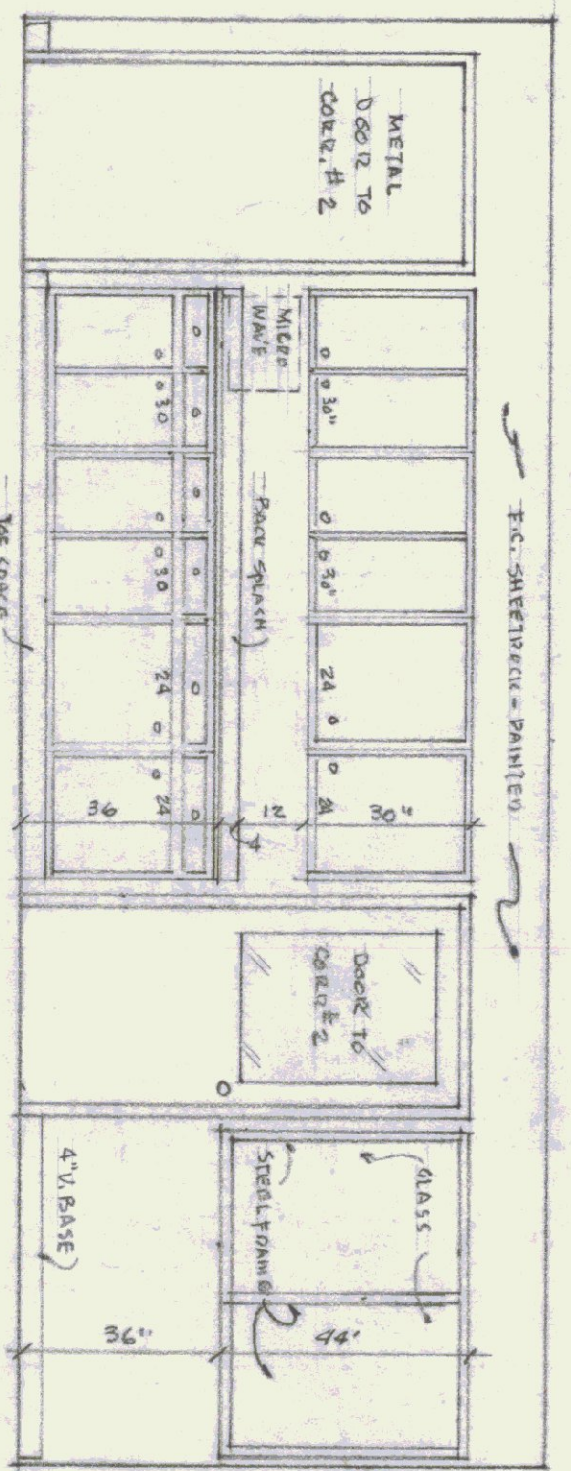


A-4 ELEVATION OF WINDOW WALL

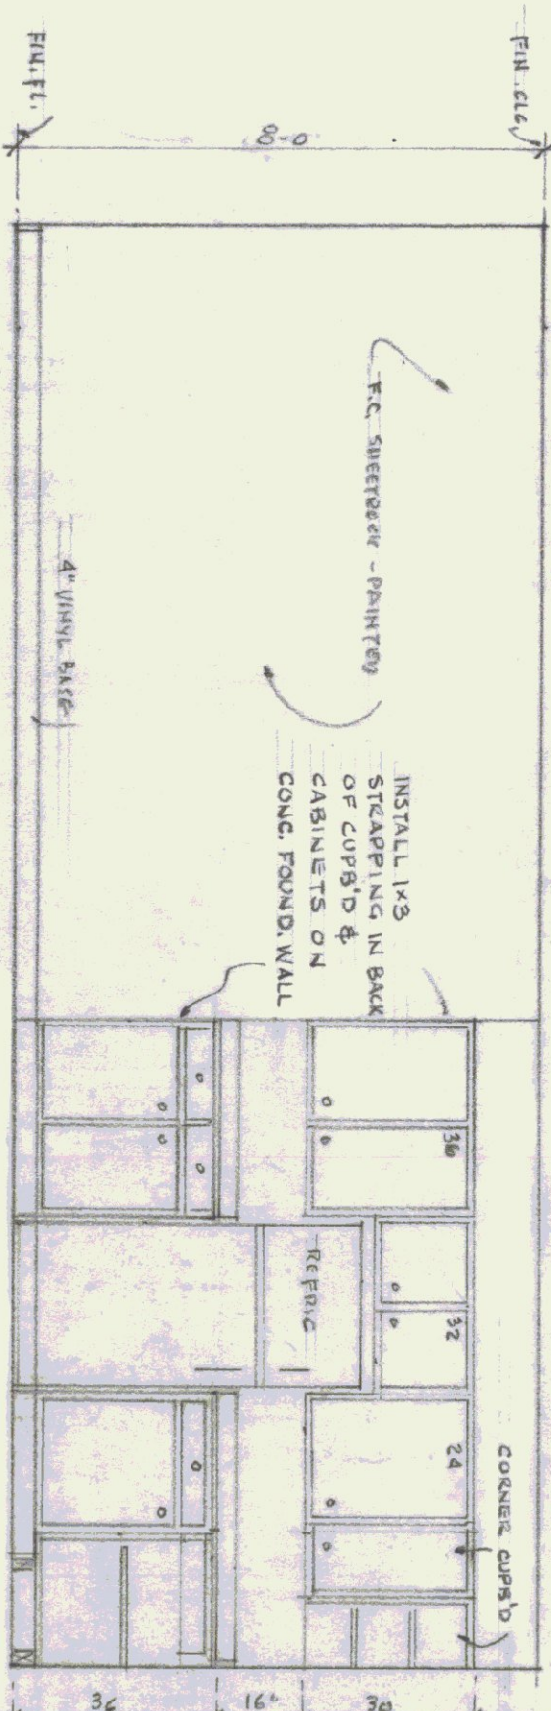

A-5 ELEVATION OF REFRIGERATOR WALL


KITCHEN ELEVATIONS-ABOVE

SCALE: 3/8" = 1'-0"

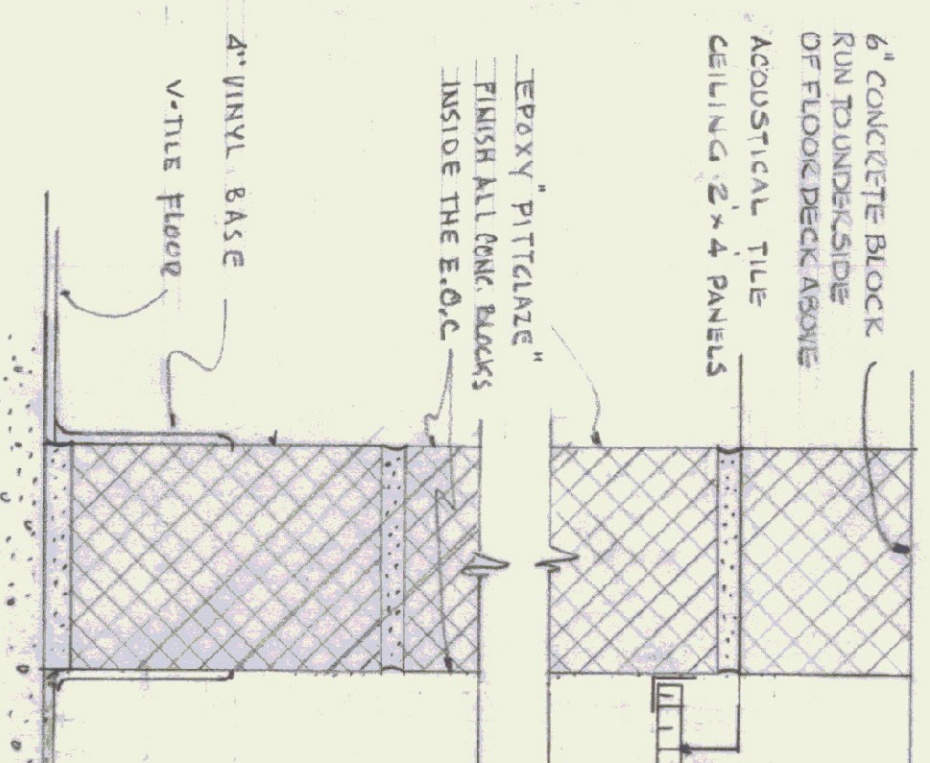


BLOCK WALL IN TOILET ROOMS


SCALE: 3/8" = 1'-0"

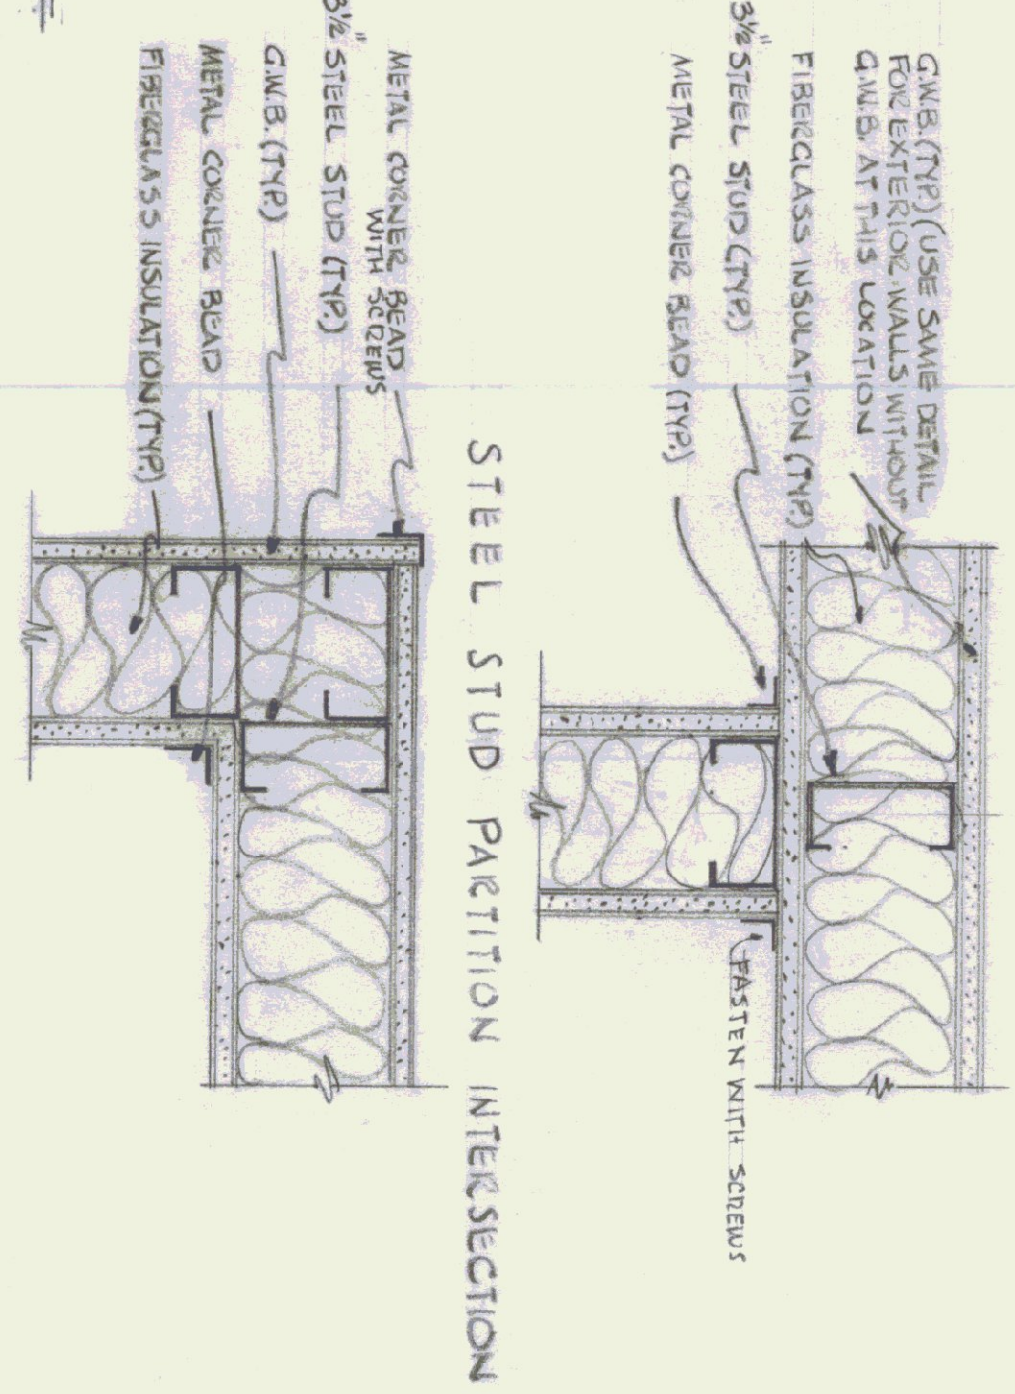


STEEL STUD PARTITION INTERSECTION

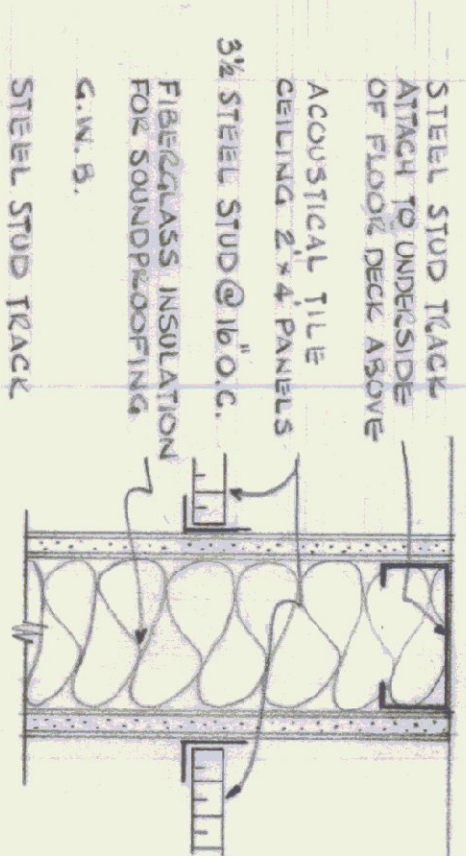

STEEL STUD TRACK

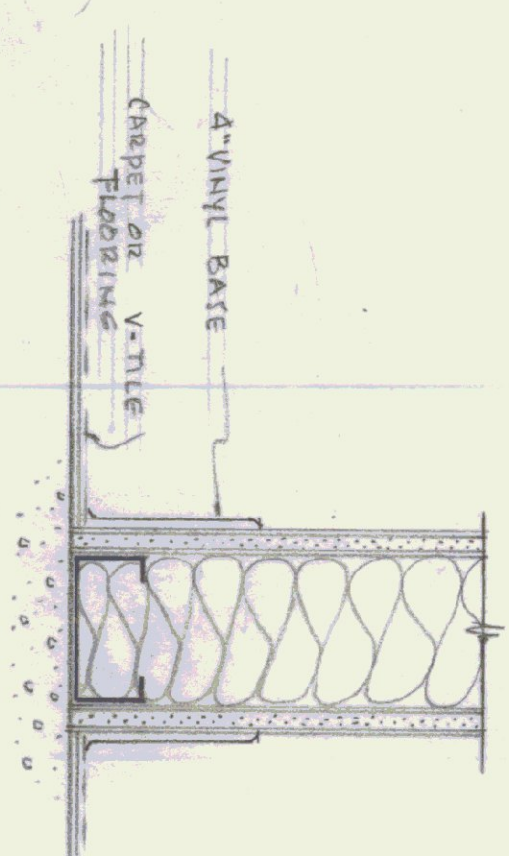


4" VINYL BASE

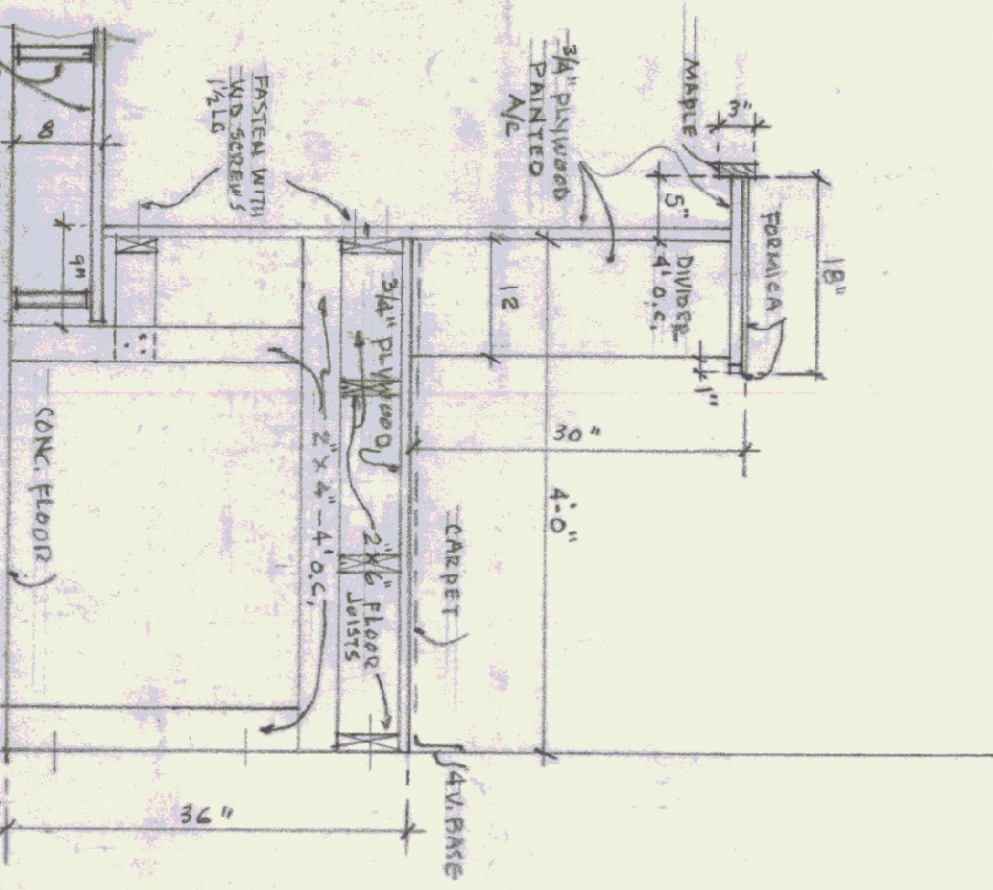


E-E SECTION THRU PLATFORM TABLE AREA IN OPERATIONS ROOM.

SCALE: 3/8" = 1'-0"

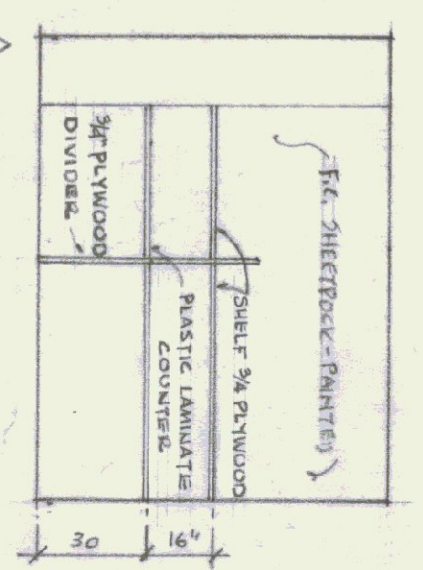


A-6 CORRIDOR NO. 5 WALL

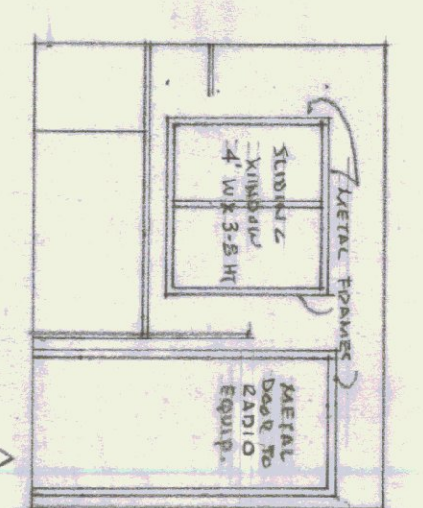


A-7 RADIO RM. WALL


COMMUNICATIONS ELEVATION-ABOVE

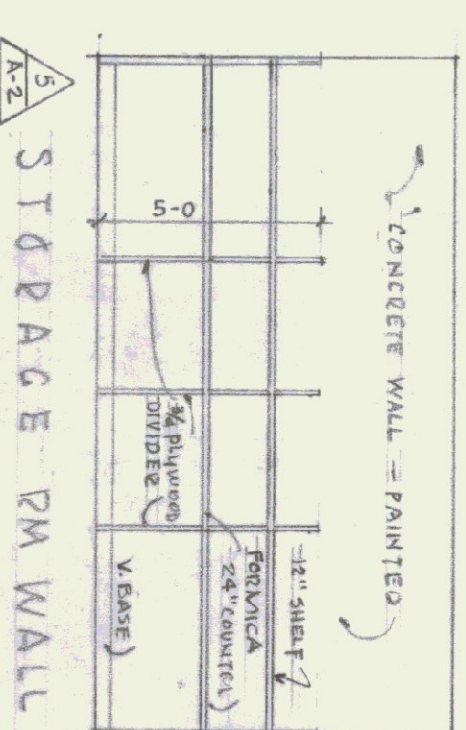


A-8 STORAGE RM WALL

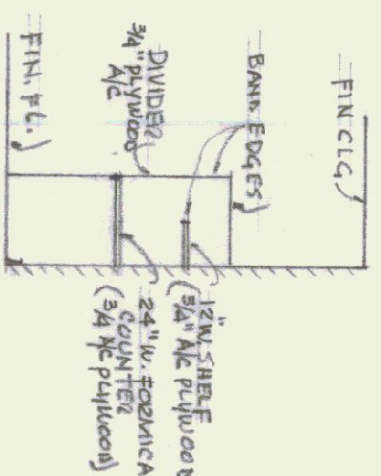


A-9 STORAGE RM WALL

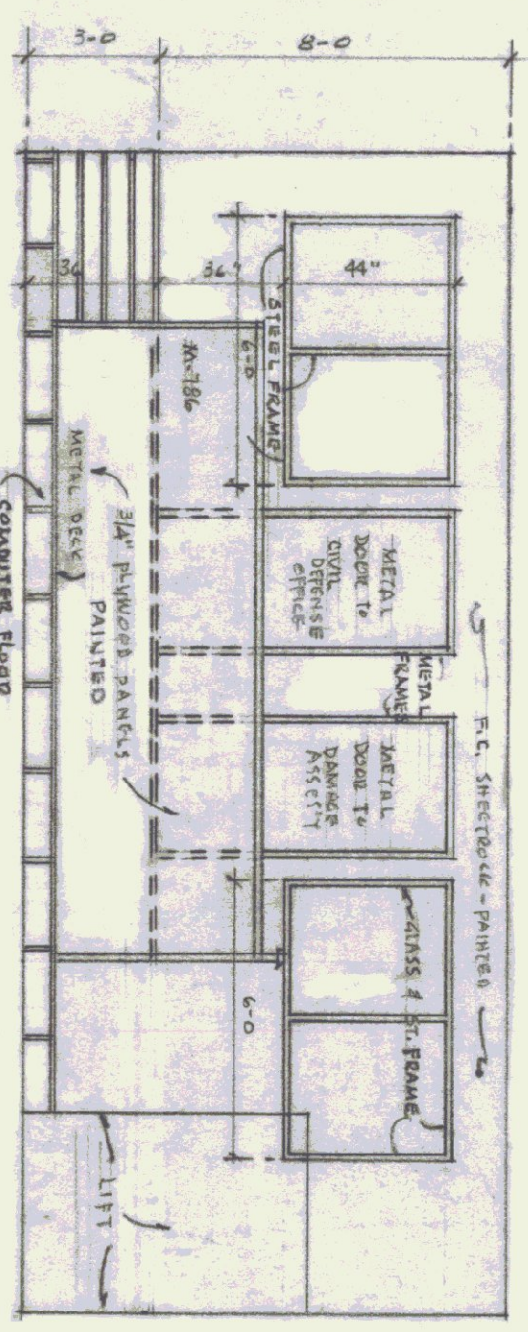


A-10 CIVIL DEFENSE OFFICE WALL

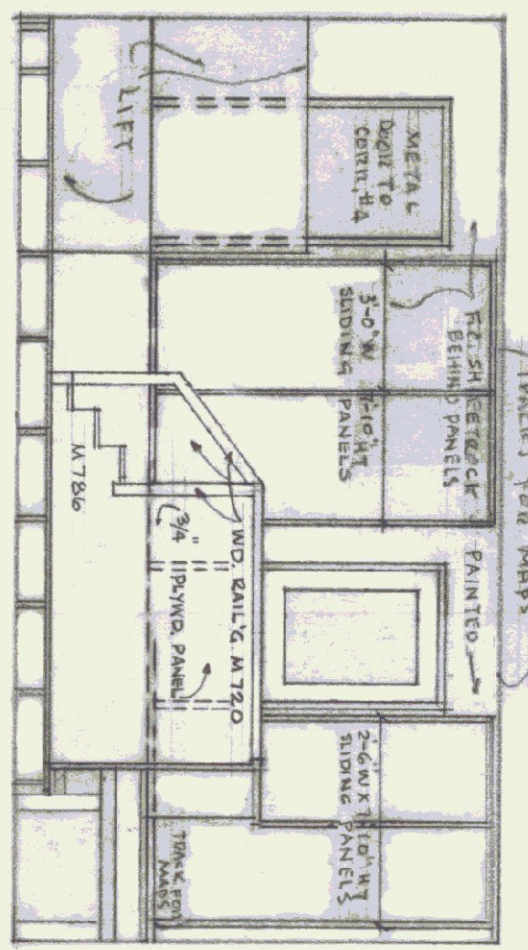

A-11 CORRIDOR NO. 4 WALL

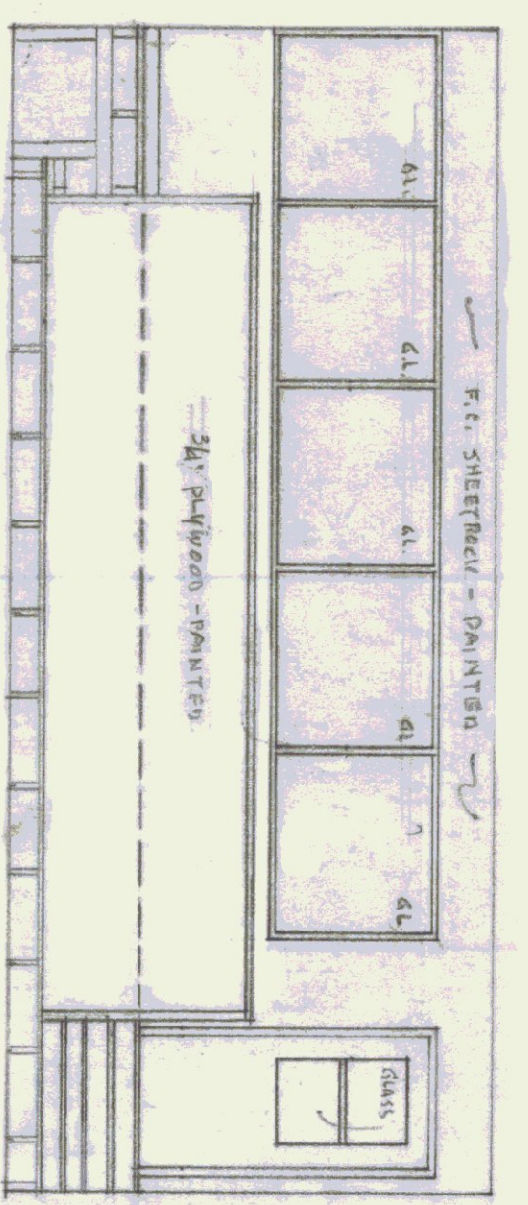

A-12 CORRIDOR NO. 3 WALL

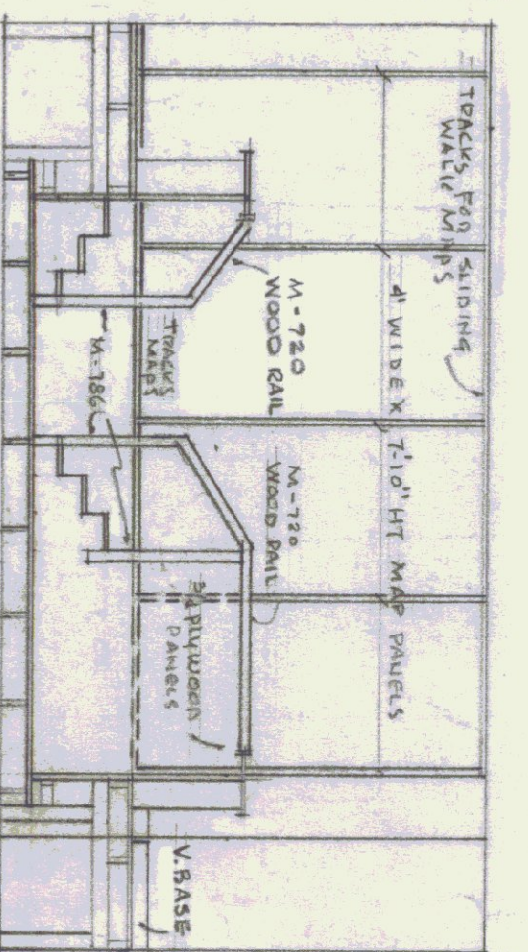

A-13 CORRIDOR NO. 2 WALL

NOTES:
ALL DIMENSIONS TO BE VERIFIED AT THE SITE BY THE CONTRACTOR. ANY ERROR OR POINTS IN QUESTION MUST BE REFERRED TO THE ARCHITECT FOR A DECISION BEFORE PROCEEDING WITH THE WORK.



REVISIONS	BY
4-8-45	DEWIS
DEWIS	BW

REGIONAL EMERGENCY OPERATING CENTER
STATE OF VERMONT - STATE BUILDINGS DEPT.
CIVIL DEFENSE DIV. DUMMERSTON, VERMONT
GORDON G. WOODS ASSOC. ARCHITECTS, BURLINGTON, VERMONT


DATE	MAK. 23, 1965
SCALE	3/8" = 1'-0"
JOB NO.	8420
SHEET	A2 E.O.C.
DRAWN	BOW AND BOW
CHECKED	

AGENCY OF TRANSPORTATION - NEW OFFICE
STATE OF VERMONT - DEPT. OF STATE BUILDINGS
DUMMERSTON VERMONT
GORDON G. WOODS ASSOC. ARCHITECTS, BURLINGTON, VERMONT

OF
A
4
A.O.T.
SHEETS

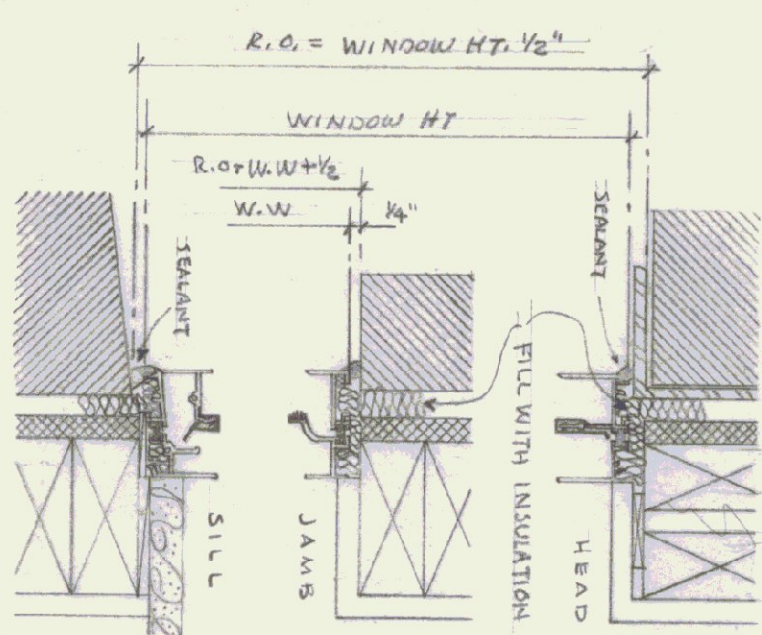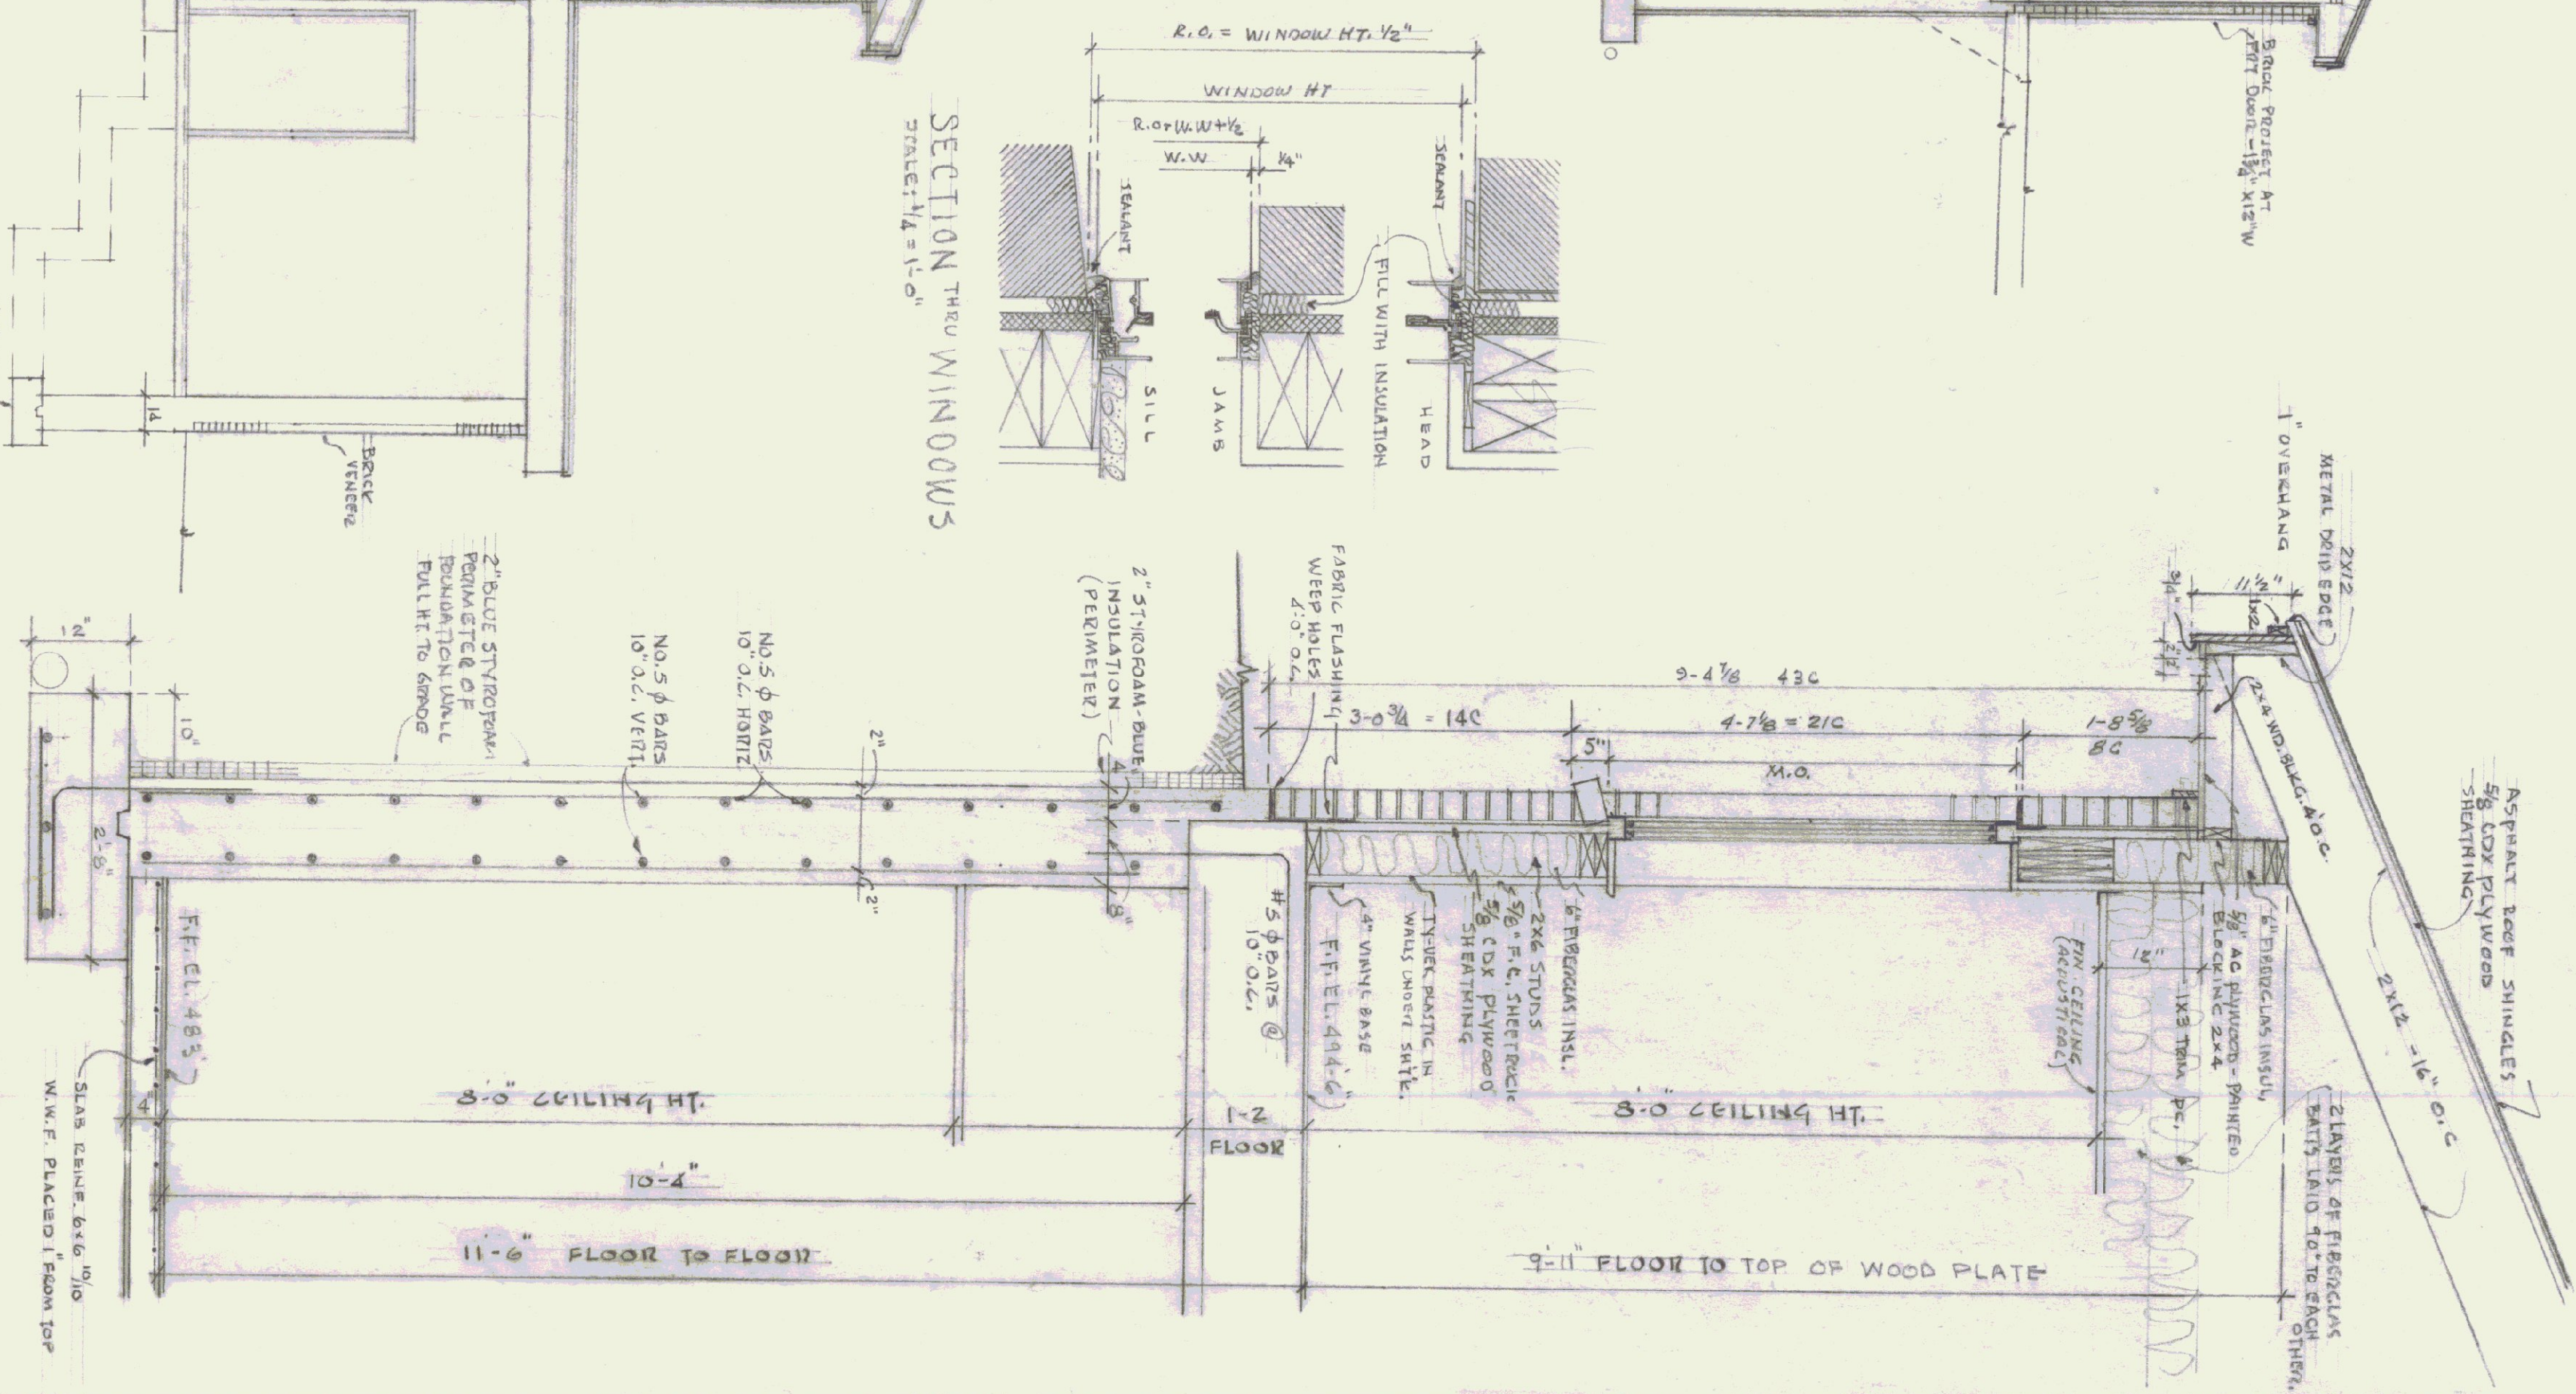

SECTION THRU WINDOWS
SCALE: 1/4" = 1'-0"

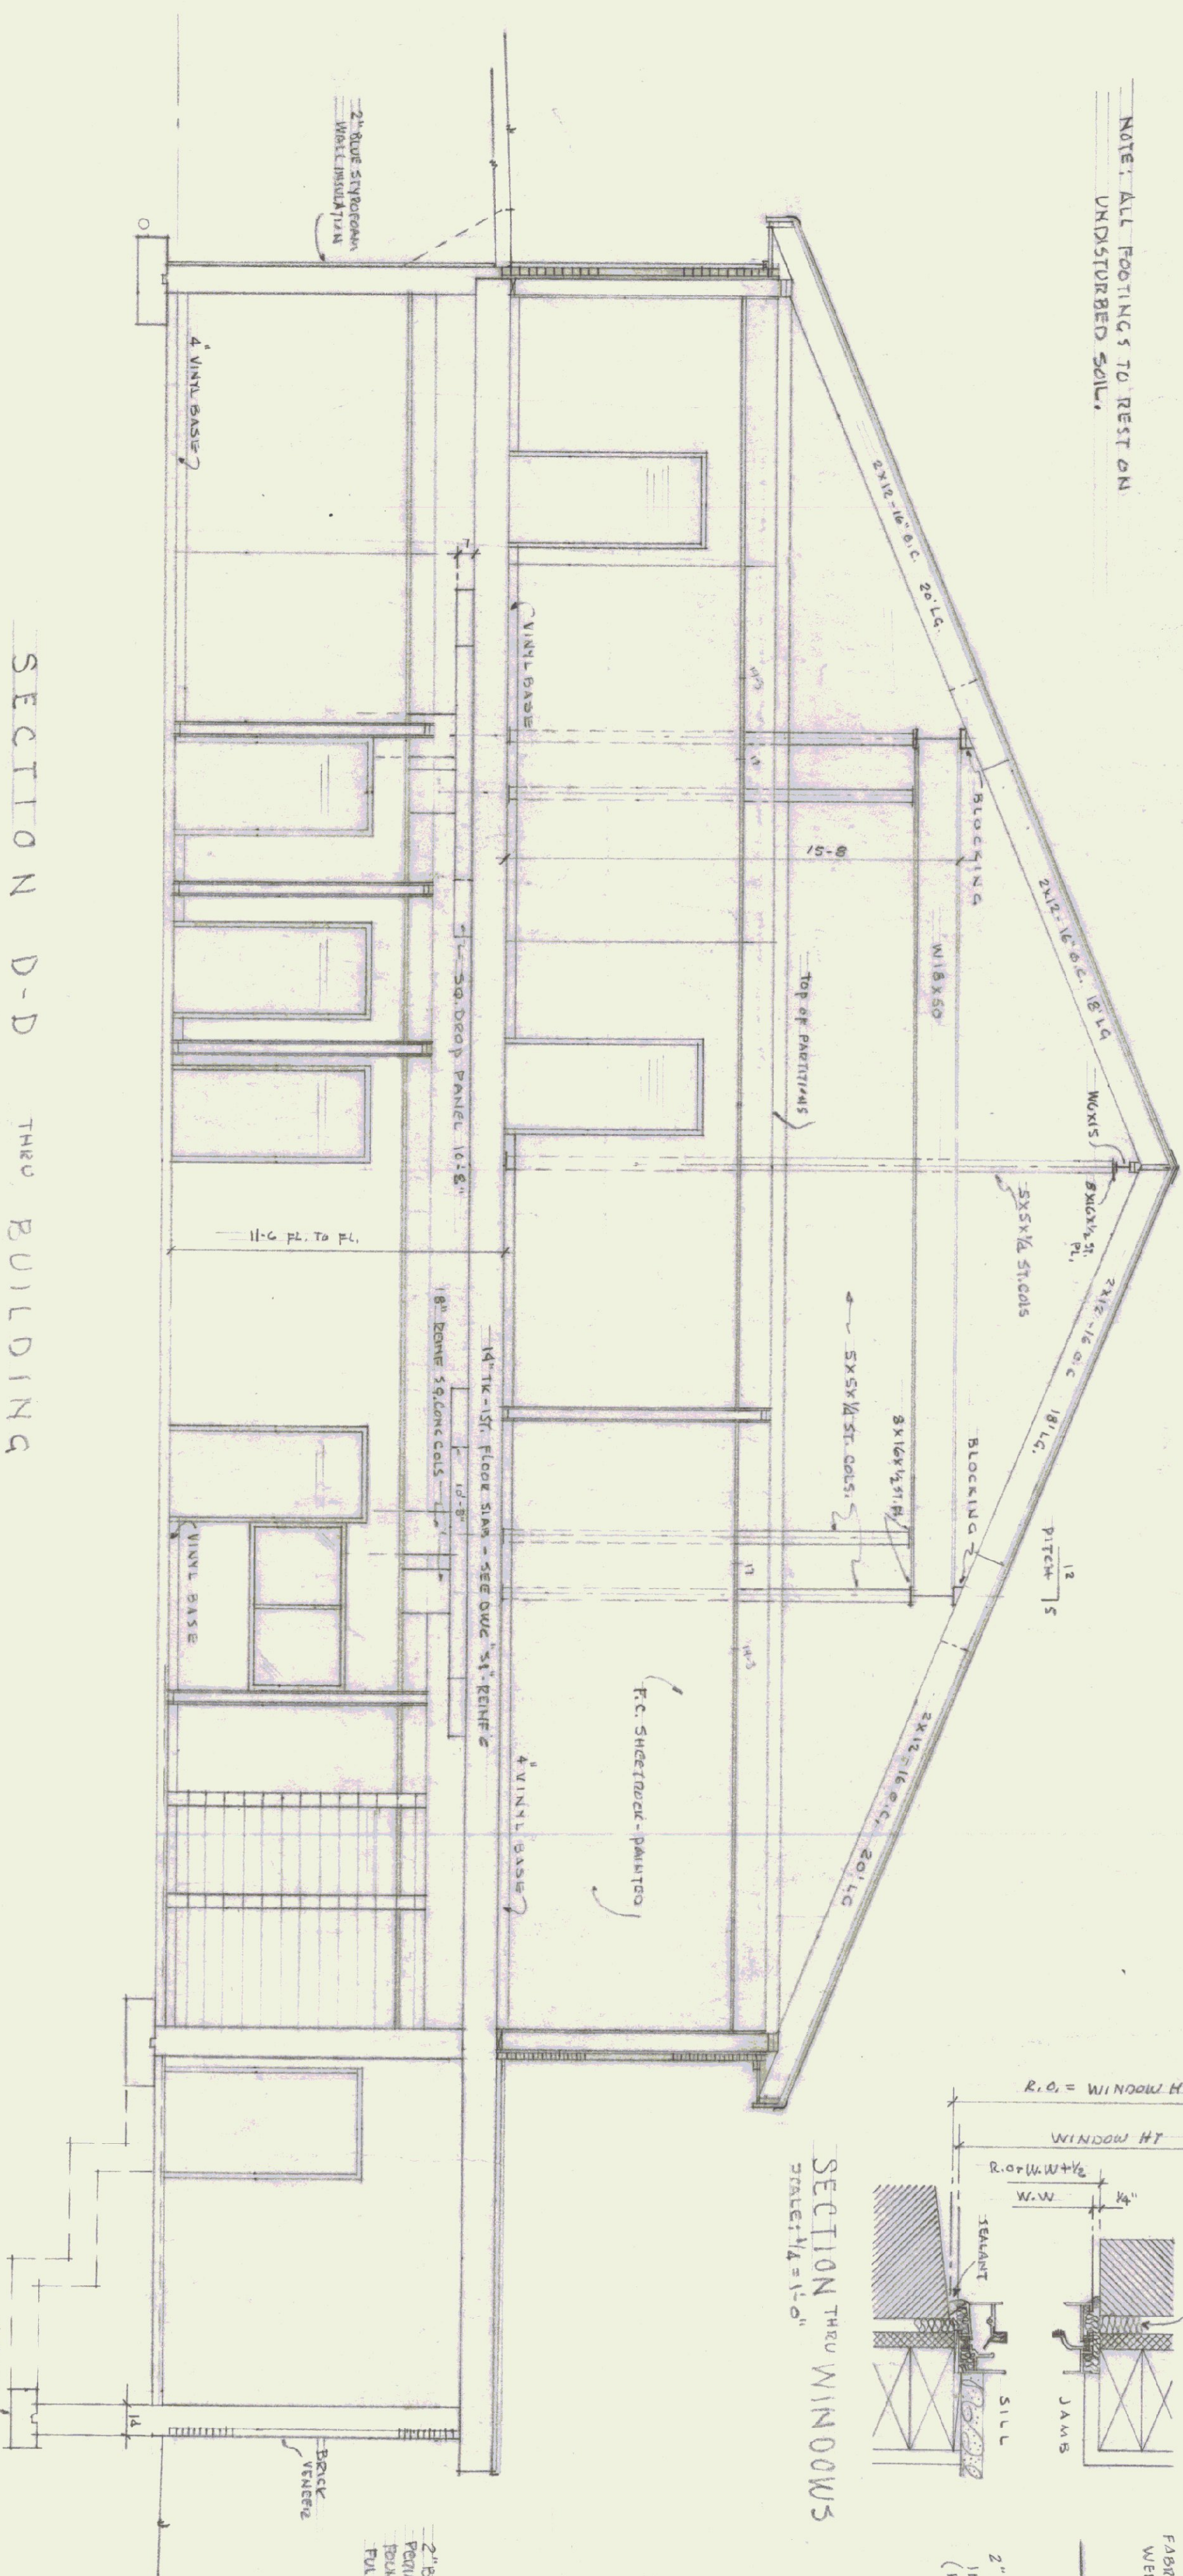


SECTION D-D ^{THRU} BUILDING

SECTION C-C THRU BUILDING
SCALE: 1/4" = 1'-0"


NOTE: ALL FOOTINGS TO REST ON UNDISTURBED SOIL.

NOTES:
ALL DIMENSIONS TO BE VERIFIED
AT THE SITE BY THE CONTRACTOR.
ANY ERROR OR POINTS IN QUESTION
MUST BE REFERRED TO THE
ARCHITECT FOR A DECISION
BEFORE PROCEEDING WITH THE WORK.

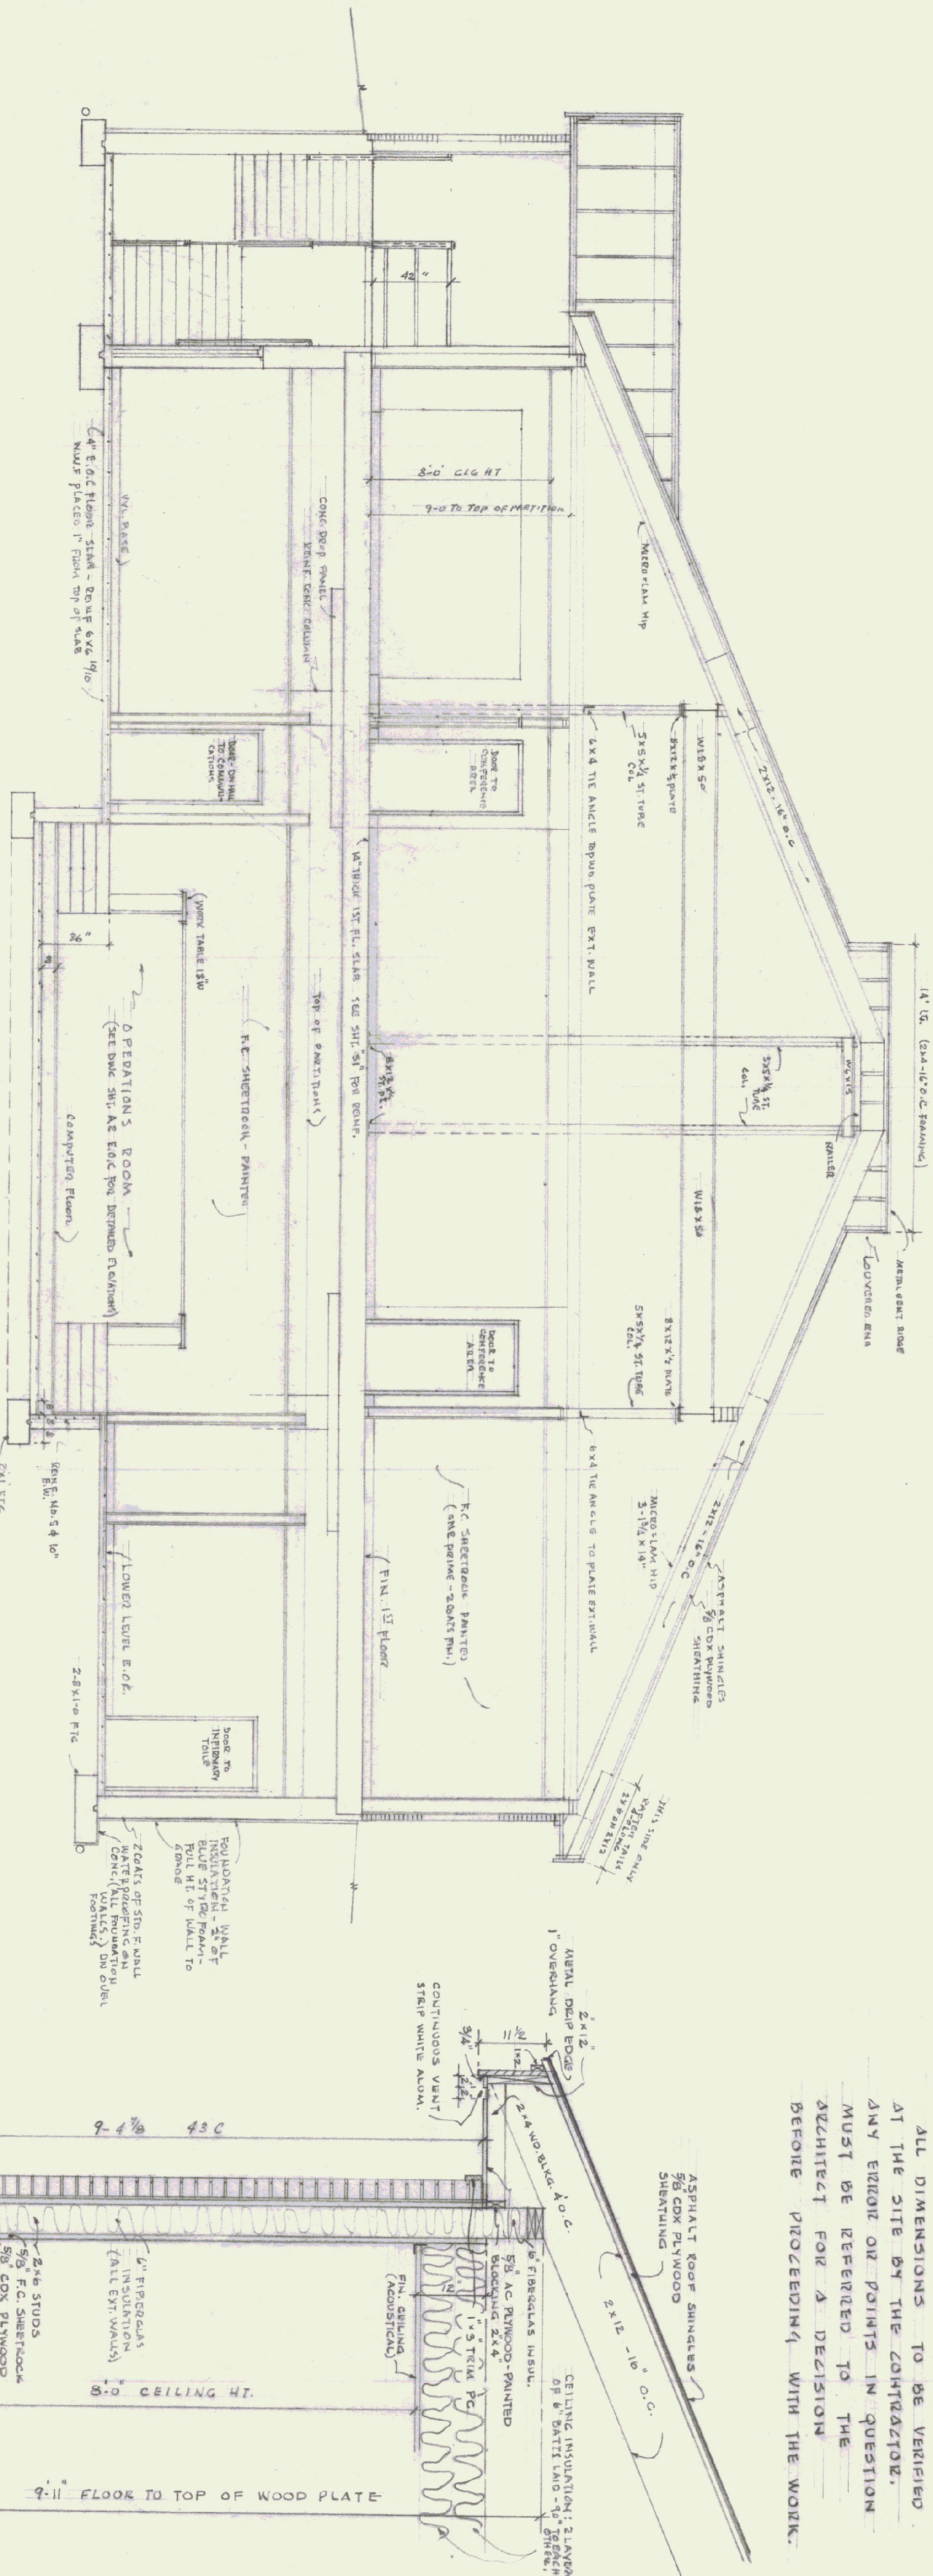

NOTE: FOR DETAILS OF FOUNDATION WALLS & FOOTINGS
SEE 3/4\"/>

SECTION "B-B" THRU BUILDING
SCALE: 1/4\"/>

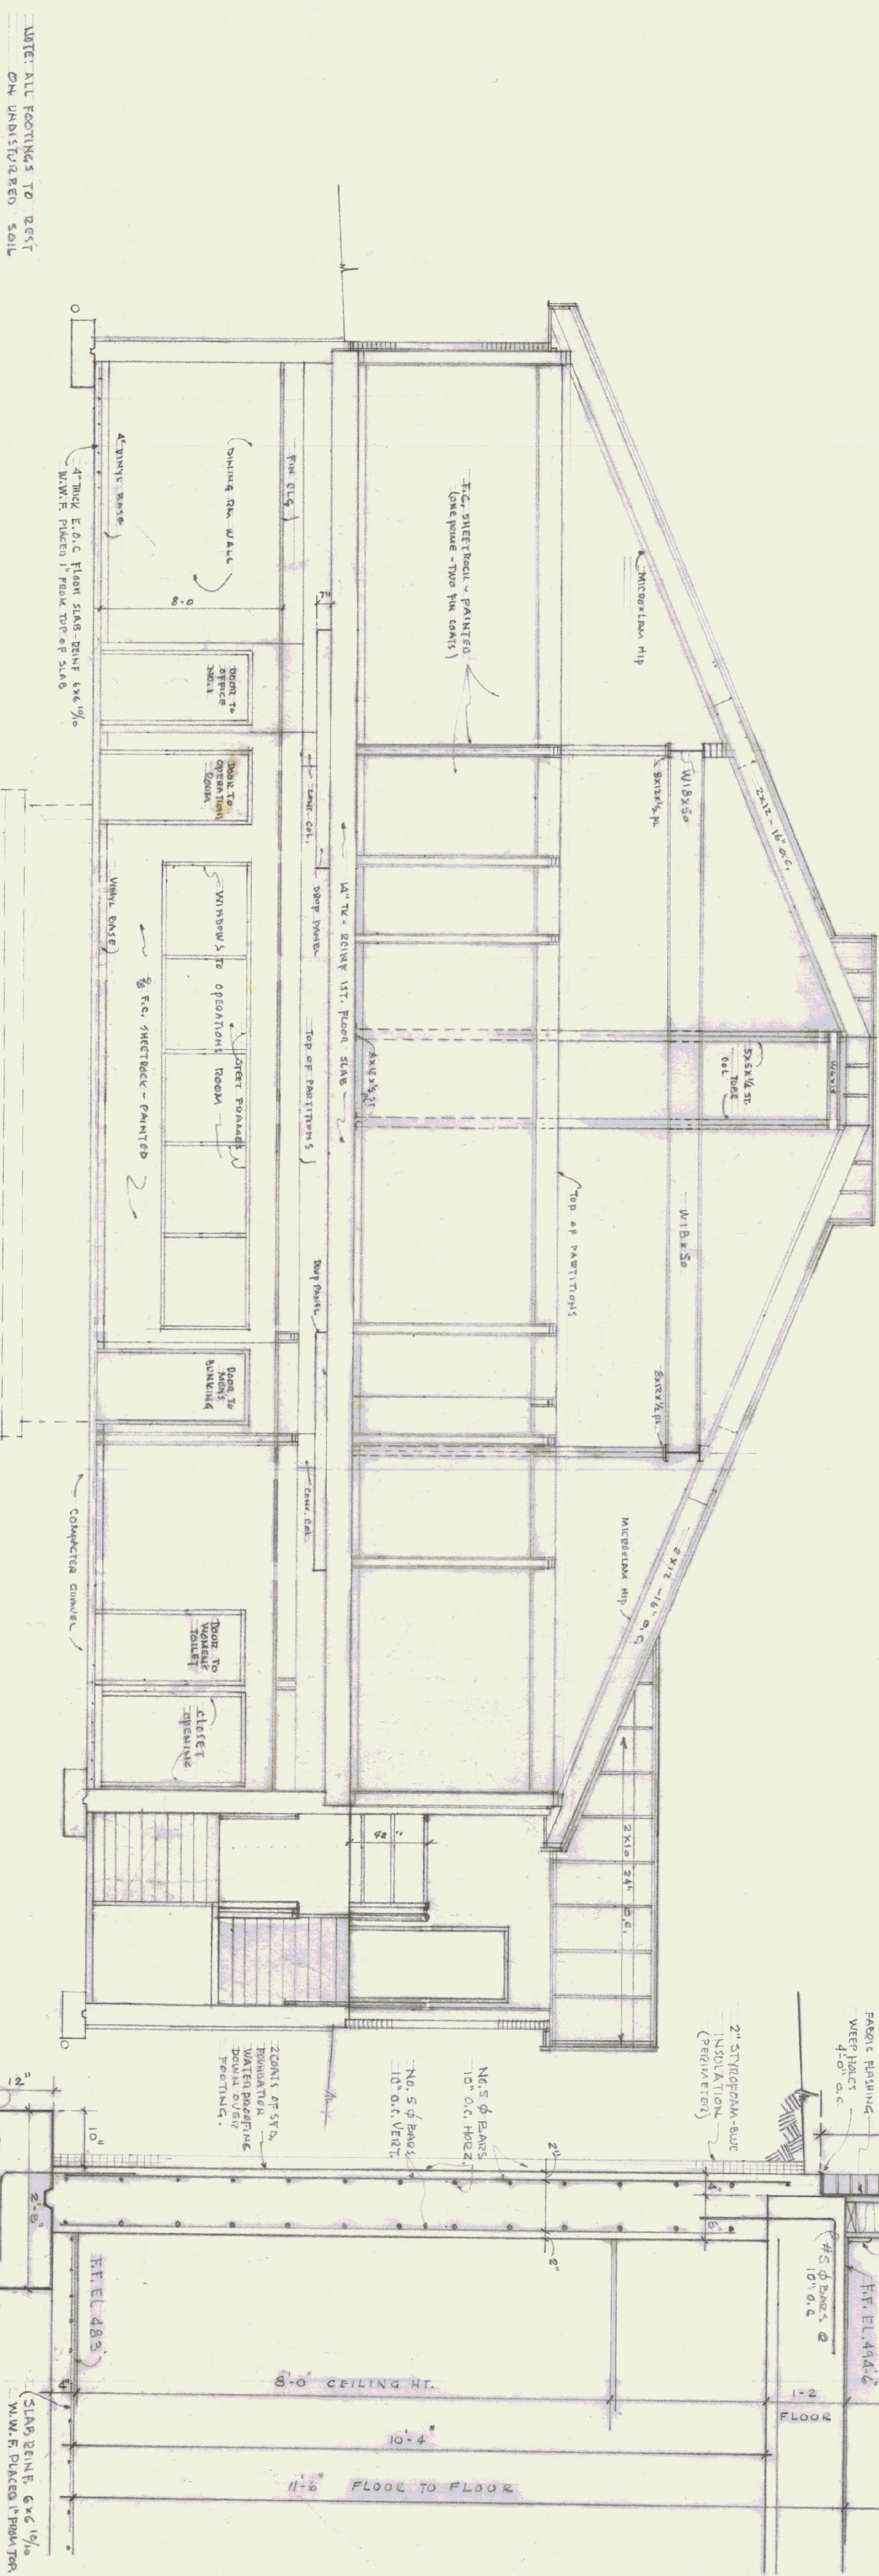

SECTION "A-A" THRU BUILDING

TYPICAL WALL SECTION
SCALE: 3/4\"/>

AGENCY OF TRANSPORTATION - NEW OFFICE
STATE OF VERMONT - DEPT OF STATE BUILDINGS
DUMMERSTON VERMONT
GORDON G. WOODS ASSOC. ARCHITECTS, BURLINGTON, VERMONT

DATE	MAR. 25, 1965
SCALE	AS NOTED
JOB NO.	6420
SHEET	5
DRAWN	Emilio
CHECKED	

REVISIONS	BY
4-8-65	CONCE
WORK	BW

NOTES:
ALL DIMENSIONS TO BE VERIFIED
AT THE SITE BY THE CONTRACTOR.
ANY ERROR OR POINTS IN QUESTION
MUST BE REFERRED TO THE ARCHITECT
FOR A DECISION BEFORE PROCEEDING
WITH THE WORK.


CEILING CONTRACTOR SHALL CHECK
WITH THE ELECTRICAL LIGHTING PLAN
FOR LOCATION OF SUPPORTING MAIN
TEES AND FINISH CEILING LAYOUT.

24"x48" ACOUSTICAL TILE SUSPENDED
CEILING MINERAL TILES TO BE USED.
CEILING HEIGHT 8'-0" IN ALL ROOMS.

CONSTRUCTED ONE HOUR FIRE RATED
CEILING SYSTEMS.

ALL LIGHTING FIXTURES SHALL BE
SECURELY FASTENED TO THE MAIN
TEES OF THE SUSPENDED CEILING
SYSTEM. LIGHTING FIXTURES 2'x4' DECEASED.

CEILING CONTRACTOR SHALL CHECK
WITH HEATING CONTRACTOR IN
REGARDS TO THE LOCATION OF THE
HEATING DIFFUSERS AND DUCT WORK
ETC.

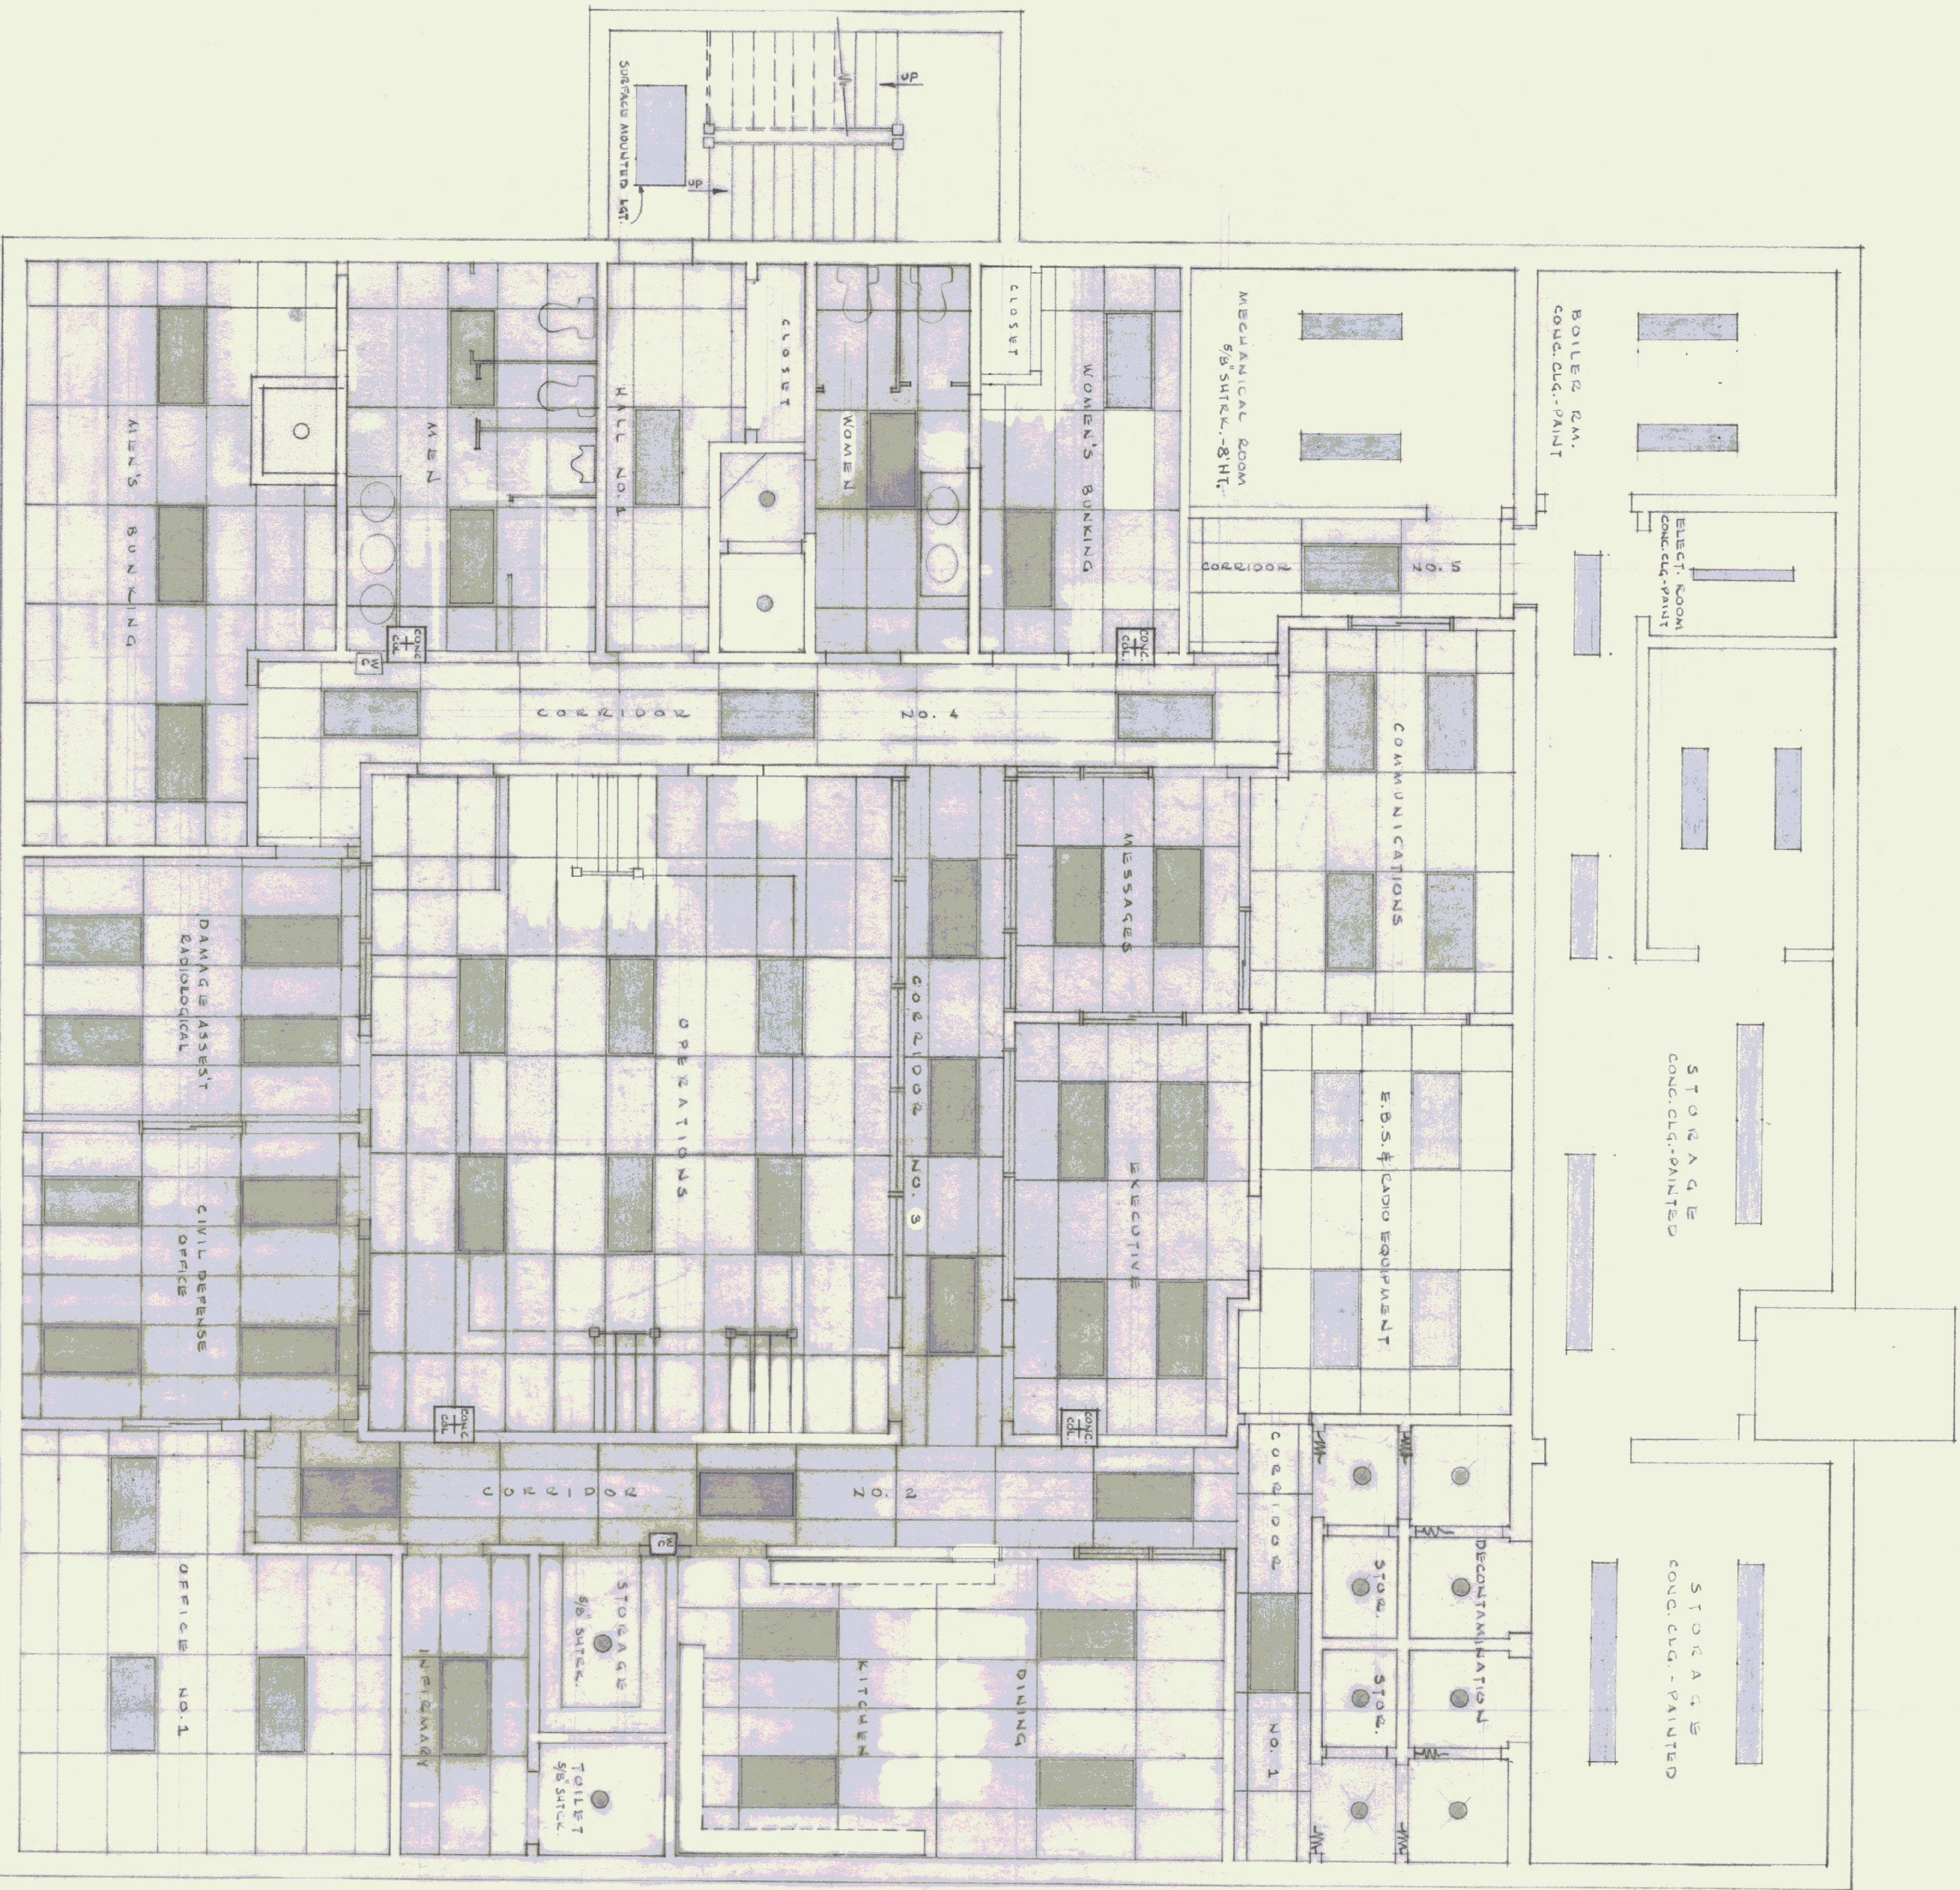


LOWER LEVEL - EMERGENCY OPERATING CENTER - CEILING

REVISIONS	BY
4-8-83 LYE	JGAV

REGIONAL EMERGENCY OPERATING CENTER
STATE OF VERMONT - STATE BUILDINGS DEPT.
CIVIL DEFENSE DIV., DUMMERSTON, VERMONT
GORDON G. WOODS ASSOC., ARCHITECTS, BURLINGTON, VERMONT

DRAWN JW/SV
CHECKED
DATE MAY, 23, 1983
SCALE 1/4" = 1'-0"
JOB NO. 5420
SHEET C1 EOC.
OF 6 SHEETS

E.O.C. 64-0 INSIDE

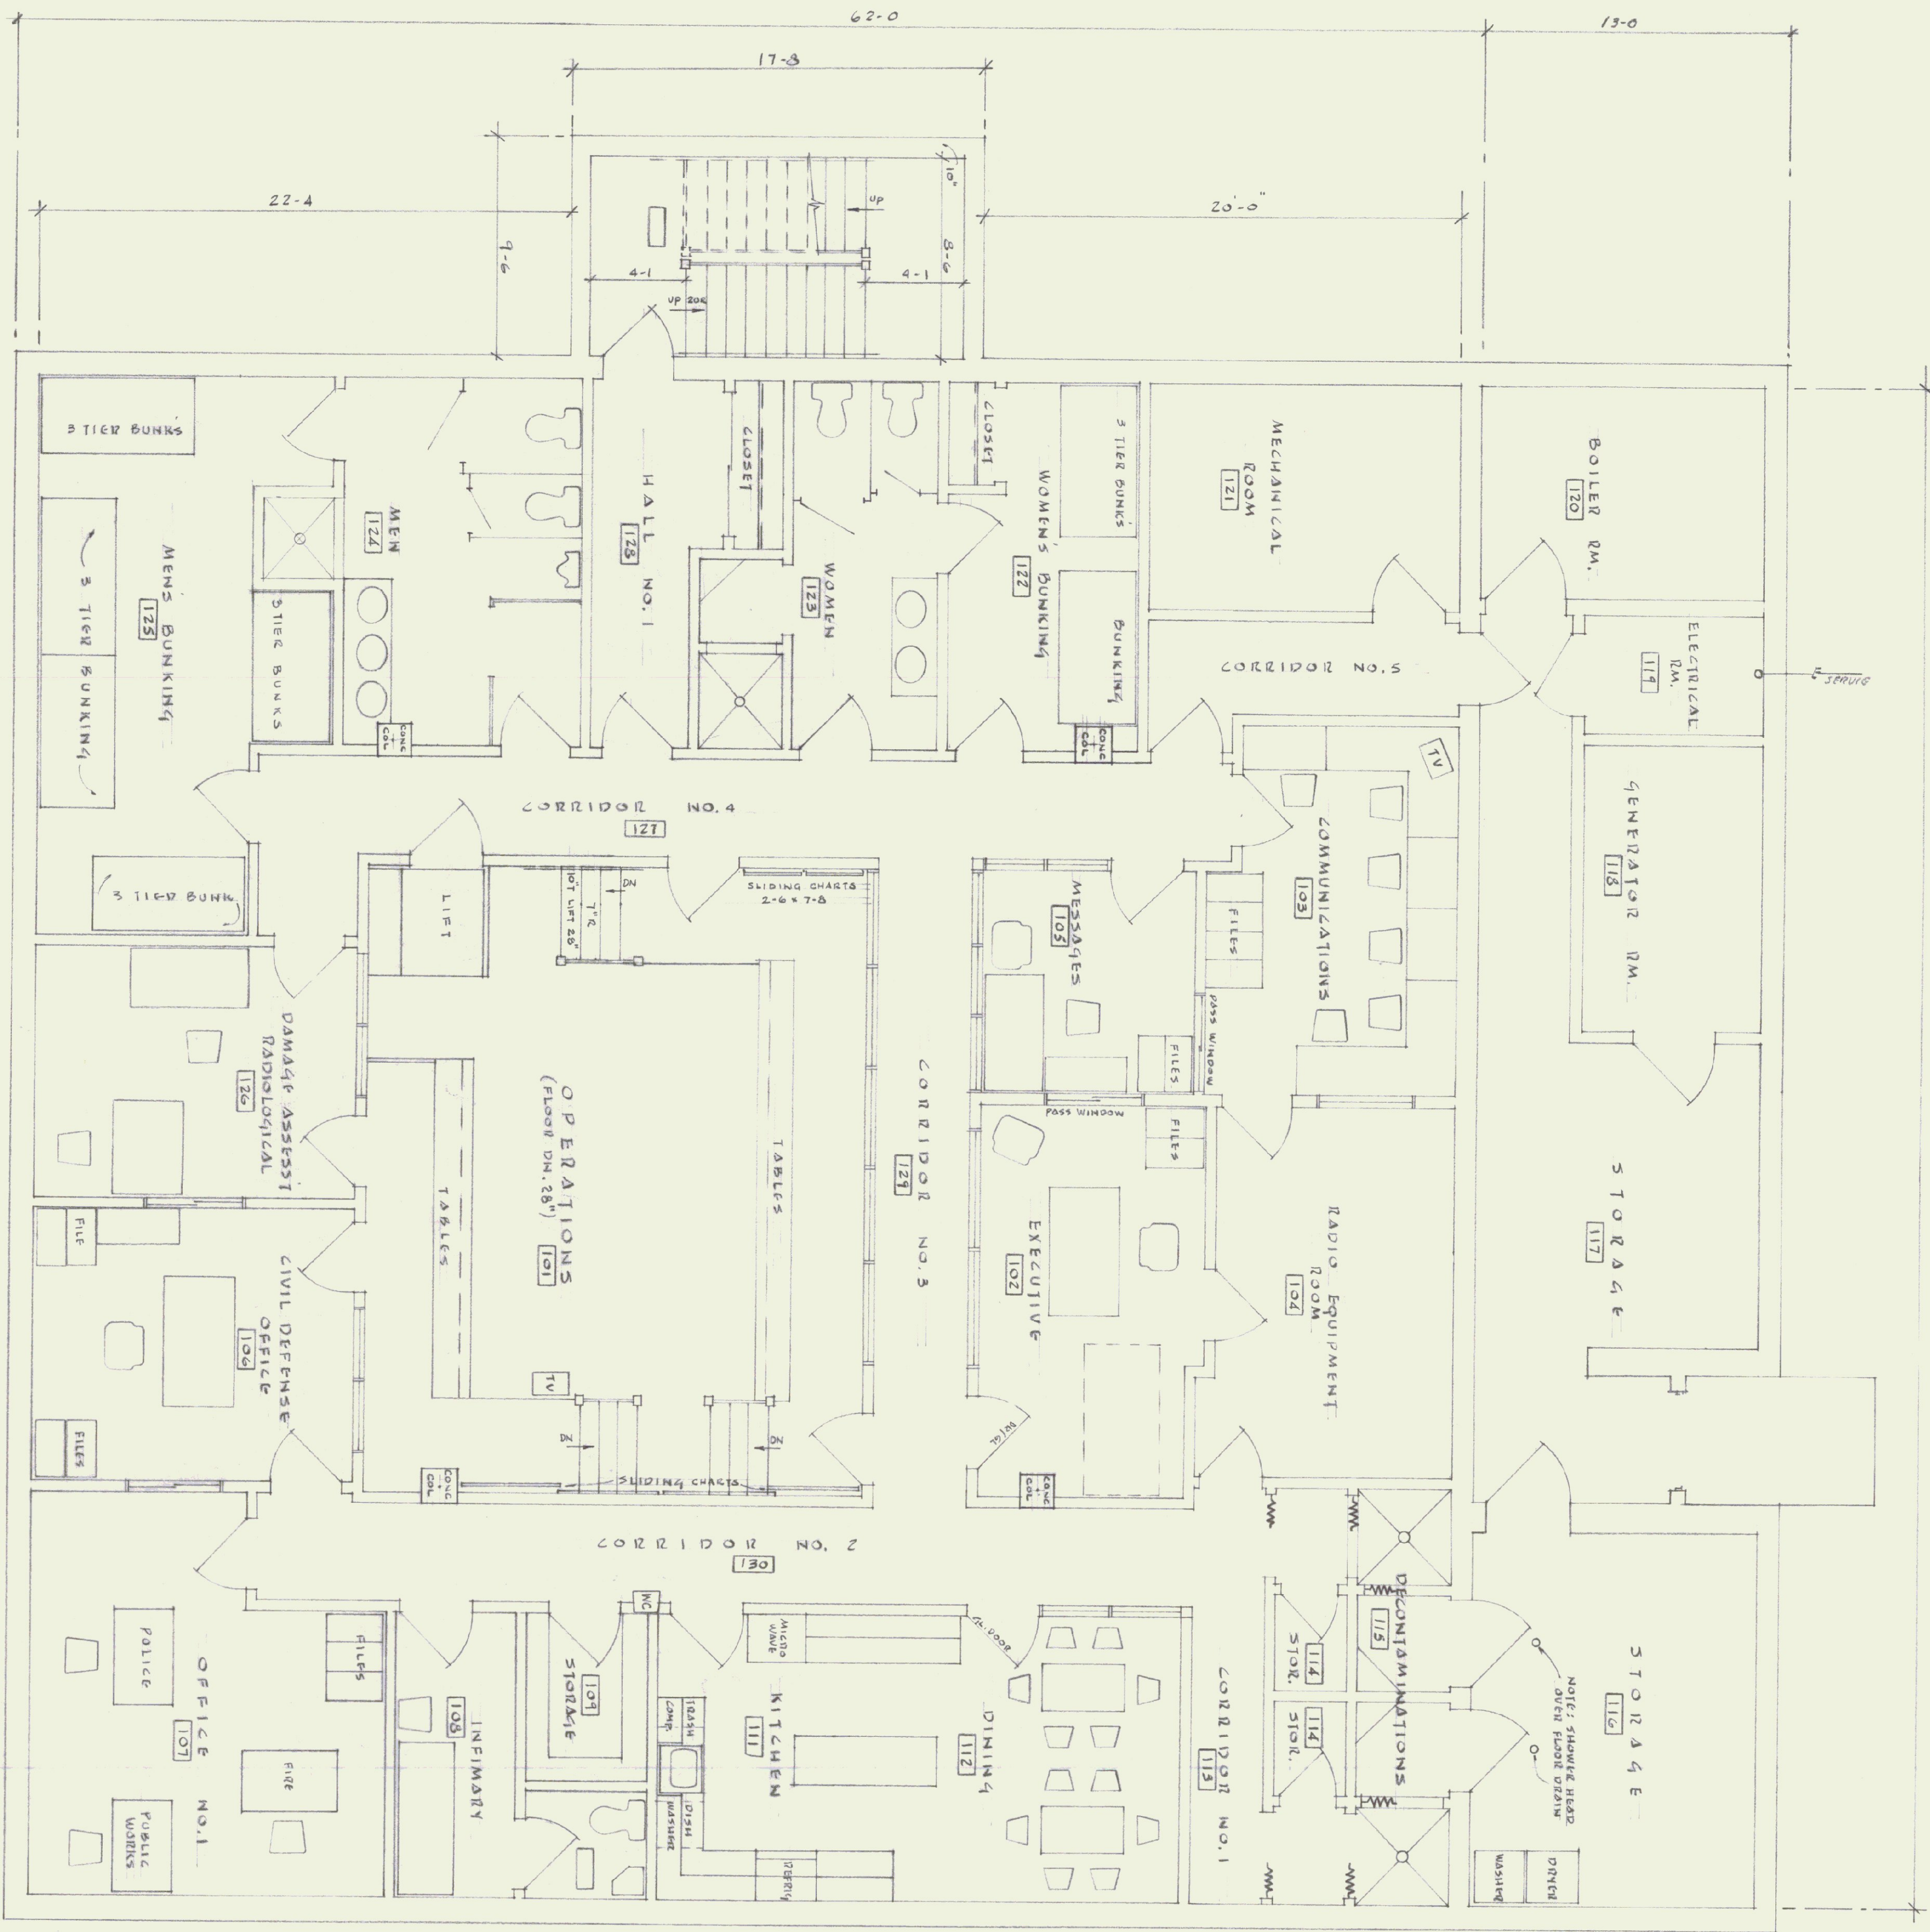

LOWER LEVEL - EMERGENCY OPERATING CENTER MASTER PLAN
SCALE: 1/4" = 1'-0"

ROOM FINISH SCHEDULE

RM NO.	ROOM NAME	FLOOR	BASE	WALLS	CEILING	HT.	REMARKS
101	OPERATIONS	EXPOSED CONC., V. TILE	VINYL-4"	PAINTED GYP. BZ.	SUSP. MIN. TILE	8'-0"	
102	EXECUTIVE	CARPET	NONE	EPoxy COATING CONC. BLK. PINTED	SUSP. GYP. BZ.		
103	COMMUNICATIONS	COMPUTER RM. FL.		EXPOSED CONC.	NONE		
104	RADIO EQUIPMENT						
105	MESSAGES						
106	CIVIL DEFENSE						
107	OFFICE NO. 1						
108	INFIRMARY						
109	STORAGE						
110	TOILET						
111	KITCHEN						
112	DINING						
113	CORRIDOR NO. 1						
114	STORAGE						
115	DECONTAMINATION						
116	STORAGE NO. 1						
117	STORAGE NO. 2						
118	GENERATOR RM.						
119	ELECTRICAL RM.						
120	BOILER RM.						
121	MECHANICAL RM.						
122	WOMEN'S BUNKING						
123	WOMEN'S TOILET						
124	MEN'S TOILET						
125	MEN'S BUNKING						
126	DAMAGE ASSESS'T						
127	CORRIDOR NO. 4						
128	HALL NO. 1						
129	CORRIDOR NO. 3						
130	CORRIDOR NO. 2						
131	CORRIDOR NO. 5						
132	STAIRWAY						

NOTES:
ALL DIMENSIONS TO BE VERIFIED
AT THE SITE BY THE CONTRACTOR.
ANY ERROR OR POINTS IN QUESTION
MUST BE REFERRED TO THE ARCHITECT
FOR A DECISION BEFORE PROCEEDING
WITH THE WORK.

REGIONAL EMERGENCY OPERATING CENTER
STATE OF VERMONT-STATE BUILDINGS DEPT.
CIVIL DEFENSE DIV., DUMMERSTON, VERMONT
GORDON G. WOODS ASSOC., ARCHITECTS, BURLINGTON, VERMONT

DRAWN
JW/PSW
CHECKED
DATE
MARCH 24, 1985
SCALE
1/4" = 1'-0"
JOB NO.
3420
SHEET
6
OF
6
MI
E.O.C.

REVISIONS	BY
46-85 Revised JW	

1 cept
MOT
FINISH