

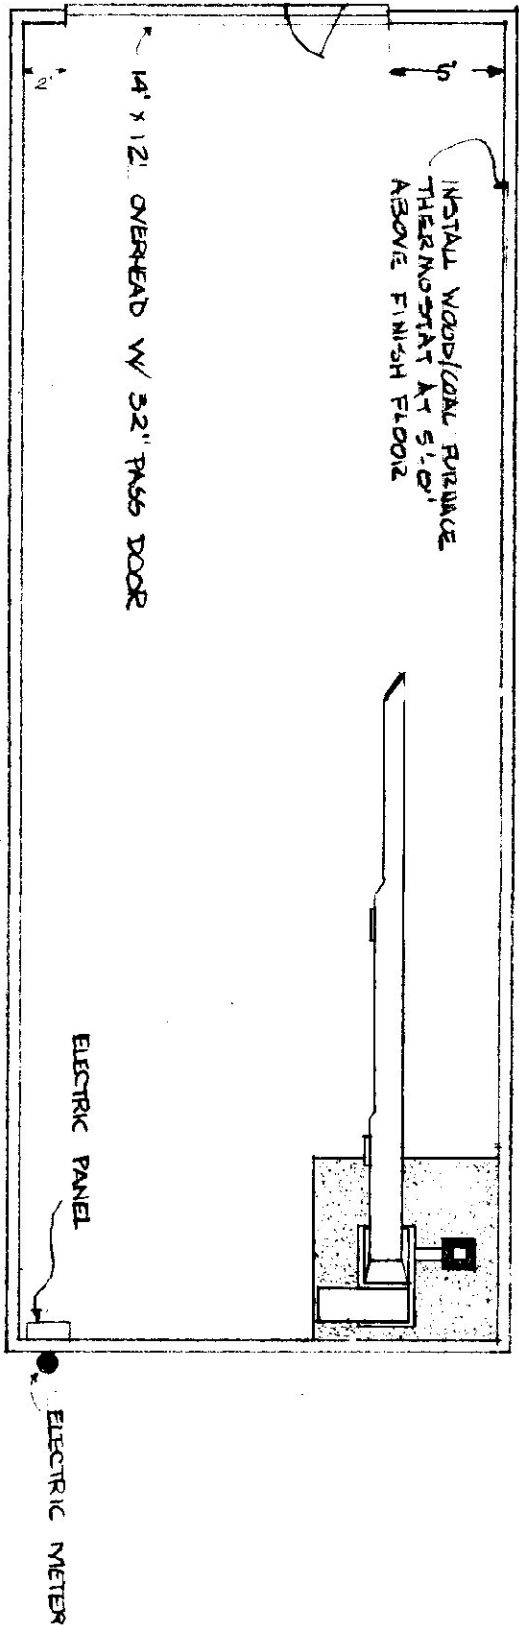
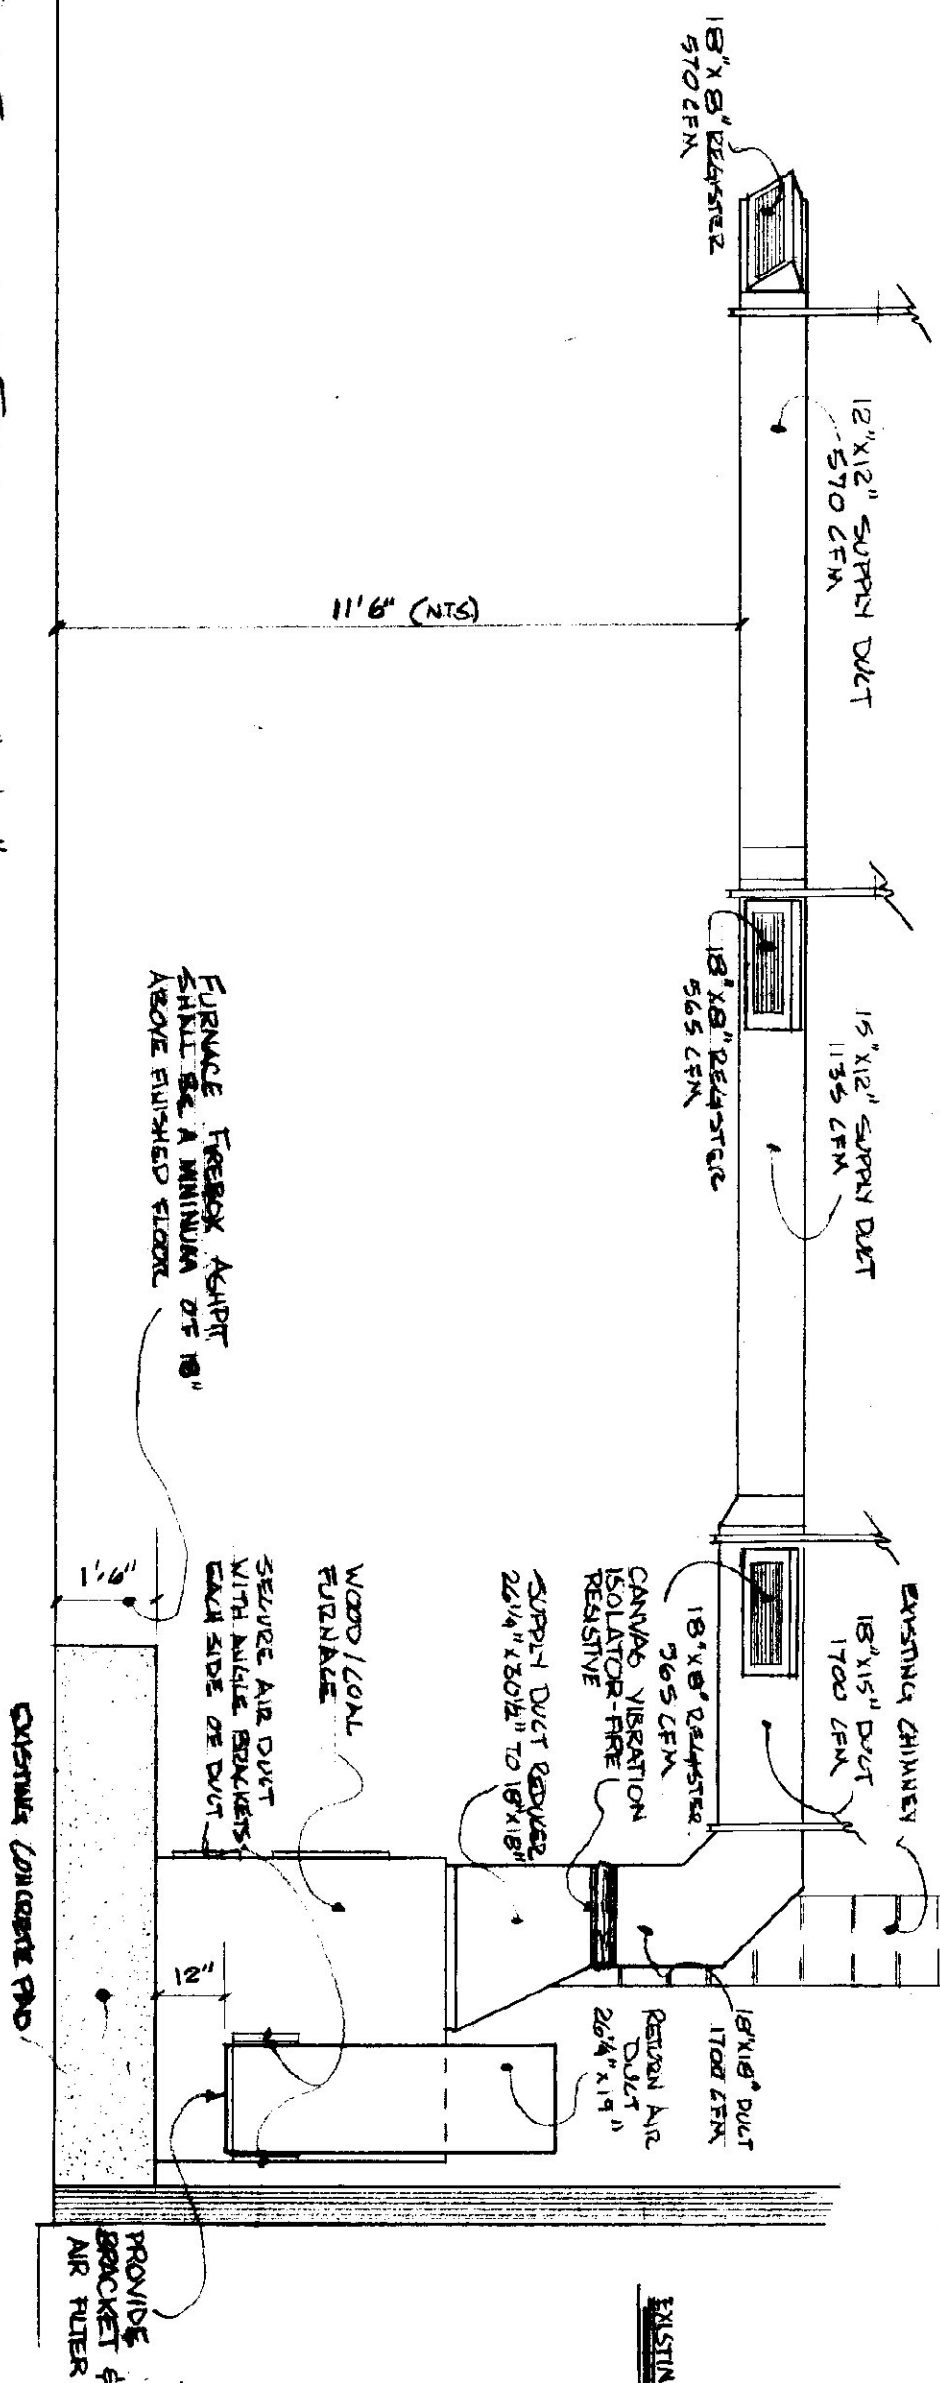


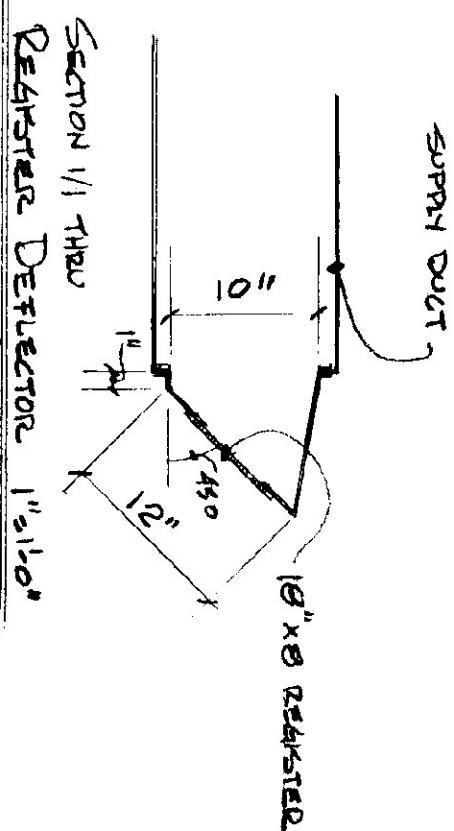

FLOOR PLAN
SCALE: 1/8" = 1'-0"

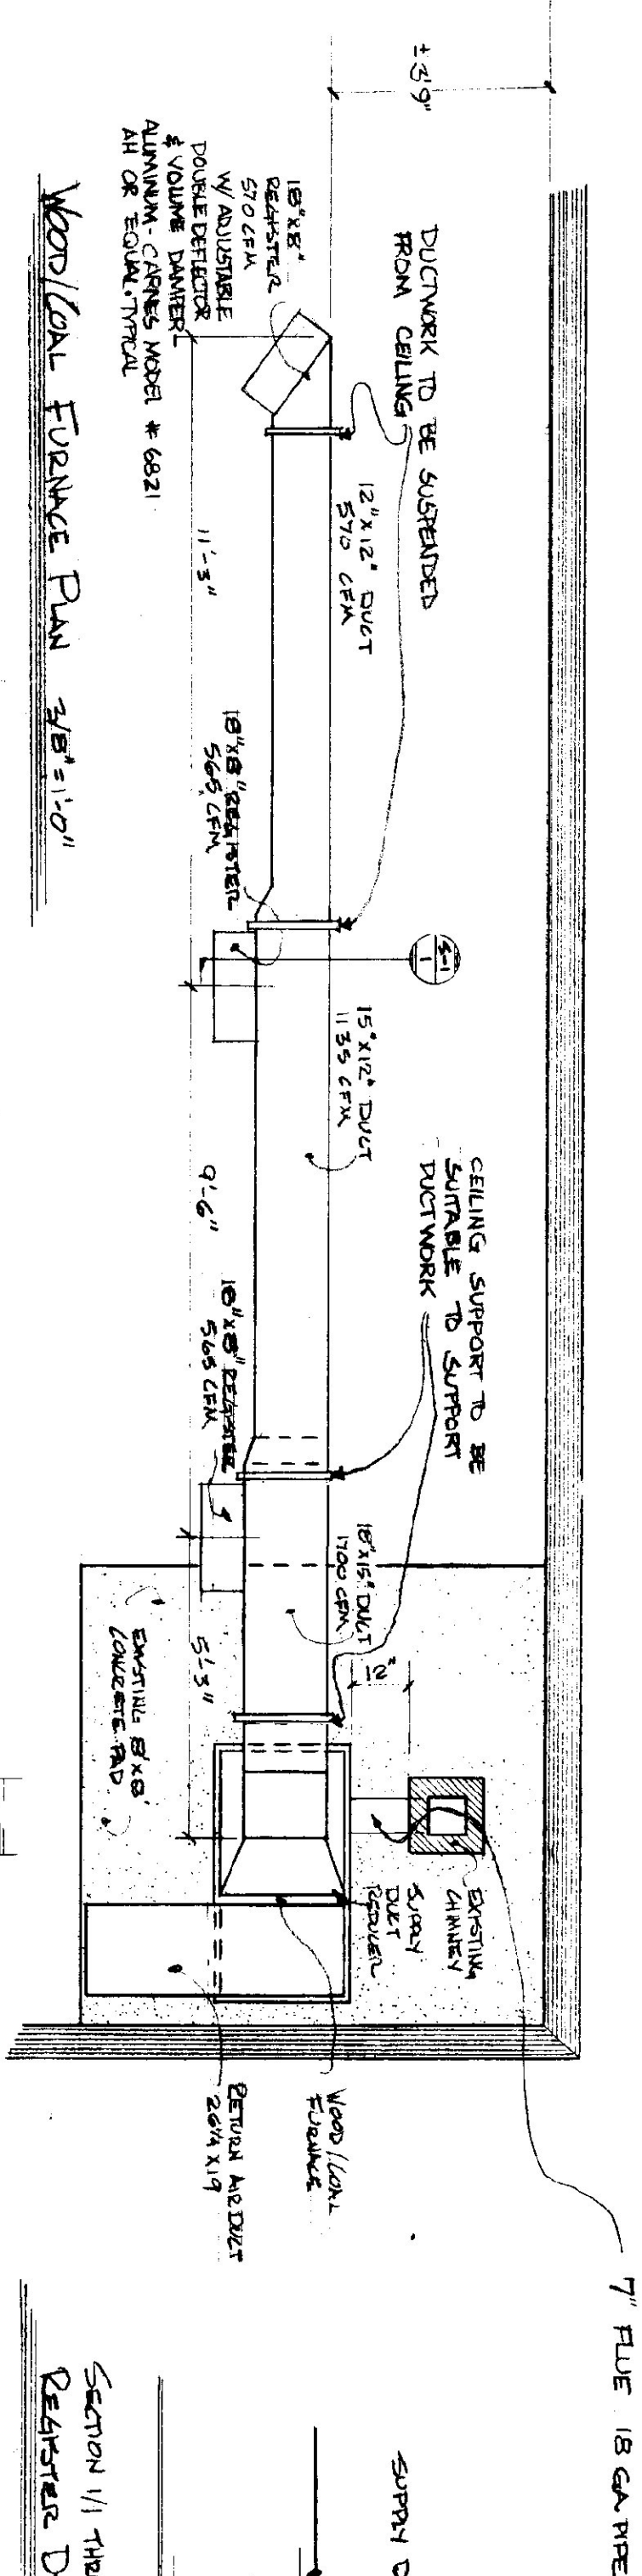

FRONT ELEVATION OF FURNACE SCALE: 3/8" = 1'-0"

STATE OF VERMONT			
DIVISION OF STATE BUILDINGS			
AGENCY OF ADMINISTRATION			
MONTPELIER, VERMONT			
WOOD/COAL FURNACE INSTALLATION			
AT THE AGENCY OF TRANSPORTATION GARAGE			
MARLBORO, VERMONT			
DATE:	SCALE:	REVISIONS:	DWG. NO.
APRIL 17, 1961	AS SHOWN		
DRAWN BY:	APPROVED BY:		
HAYSON	[Signature]		
			1 OF 1