




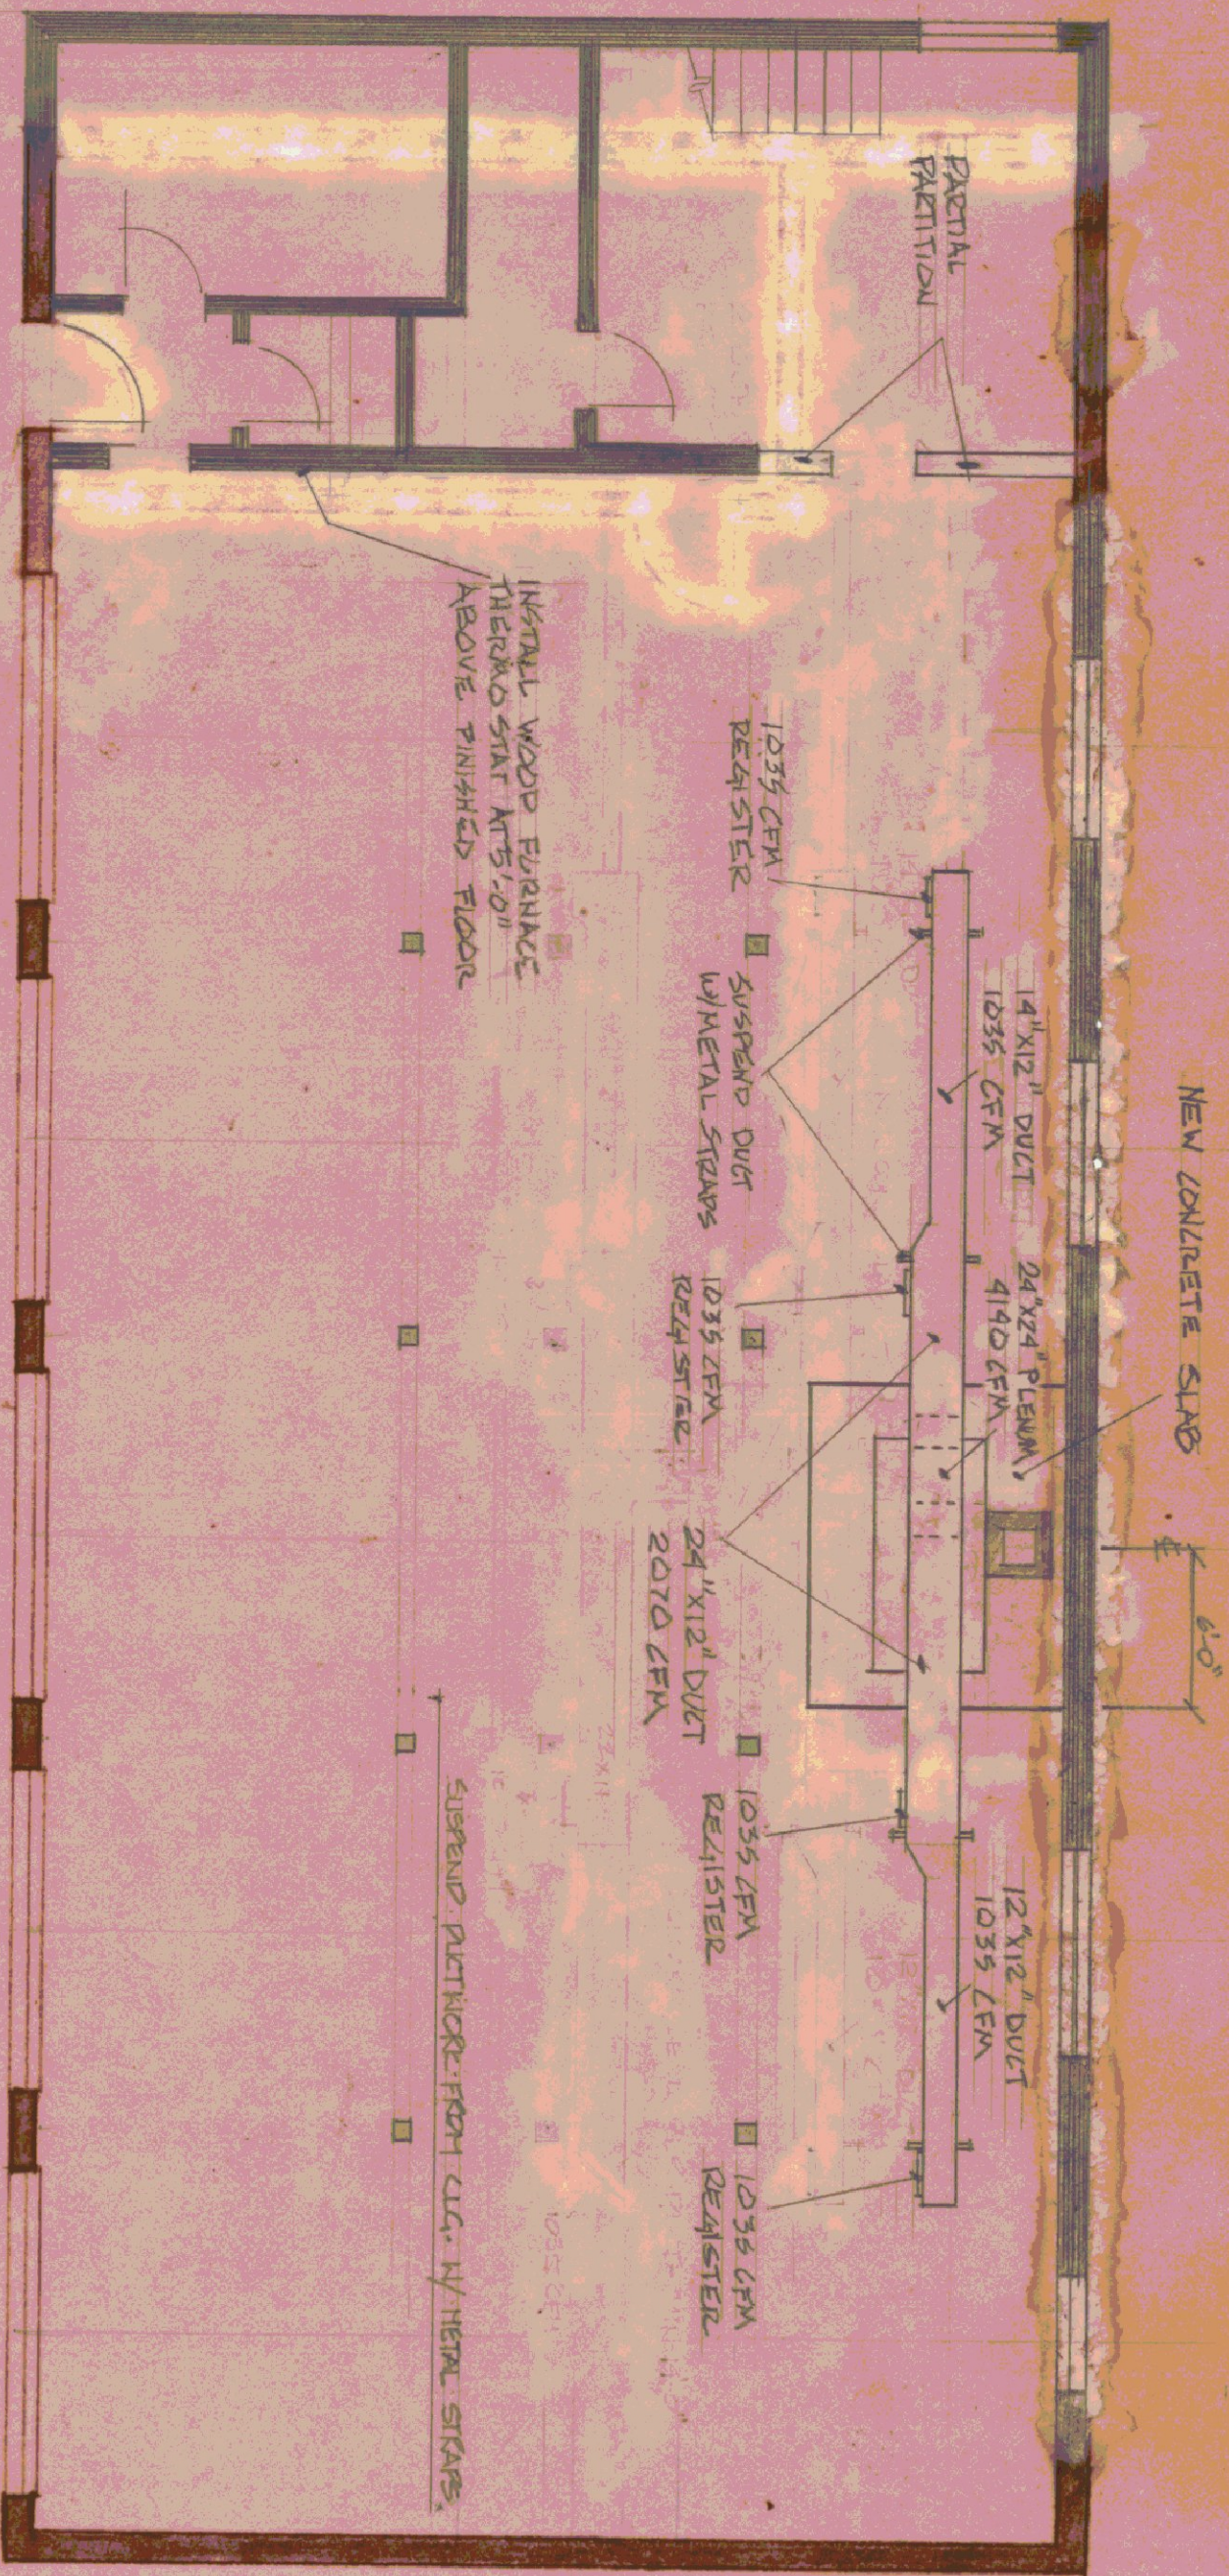


FLOOR PLAN
SCALE: 1/8" = 1'-0"

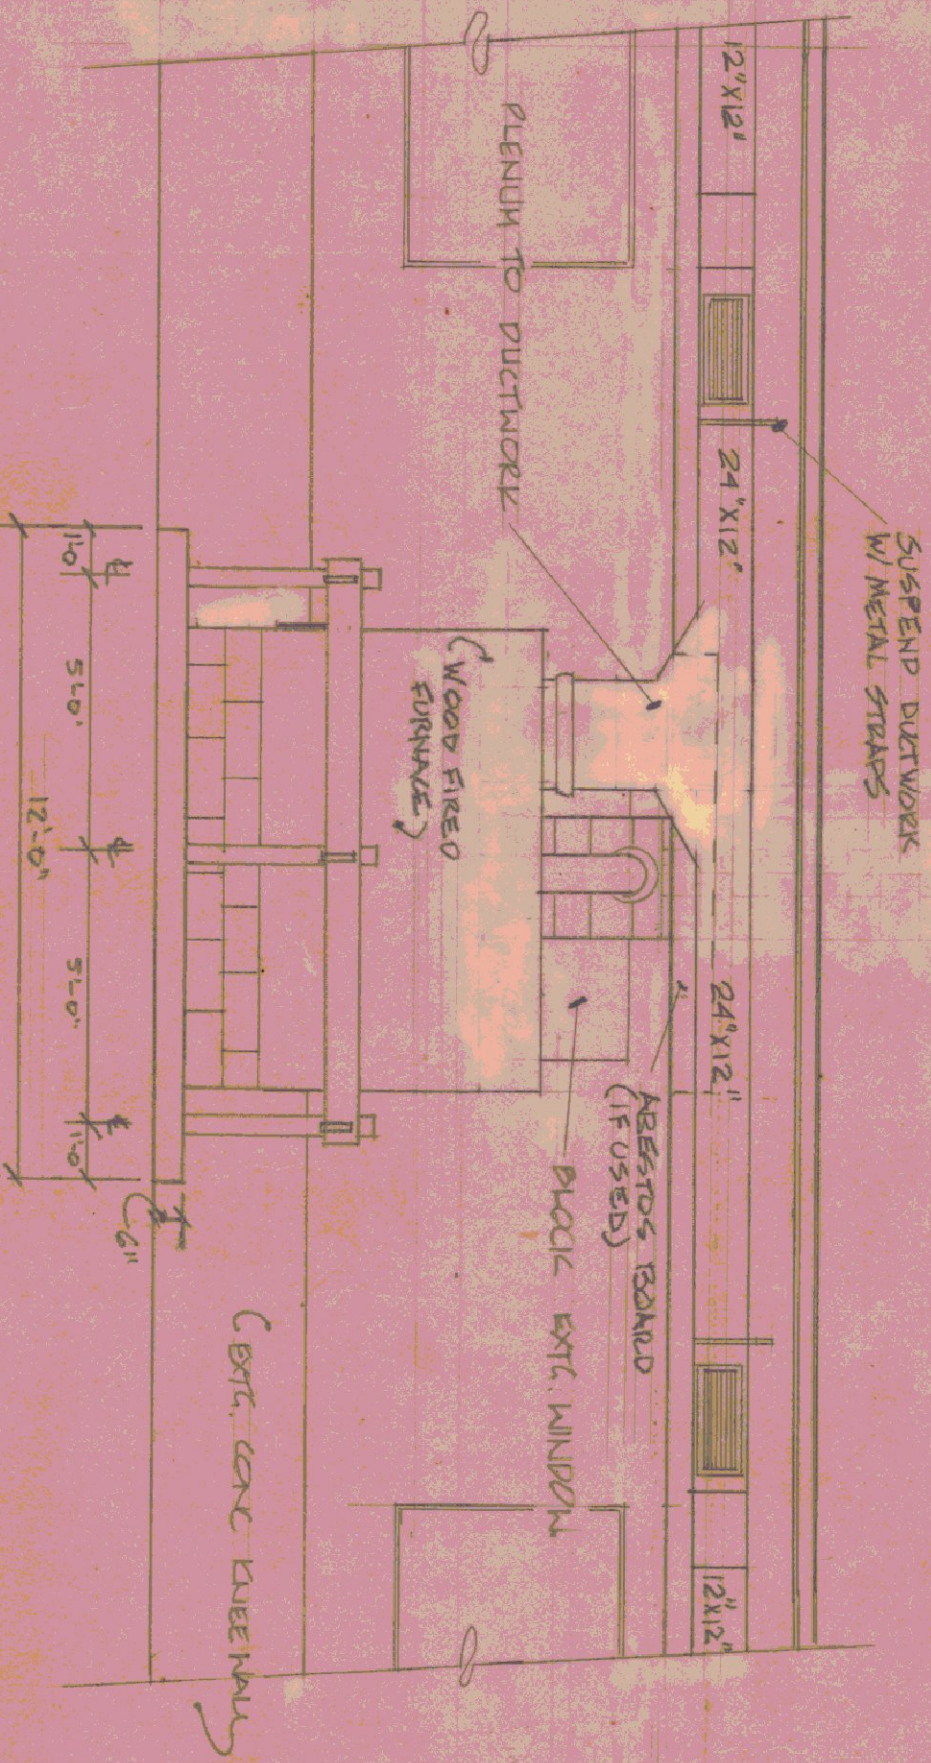

ELEVATION @ SIDE OF FURNACE
1/4" = 1'-0"

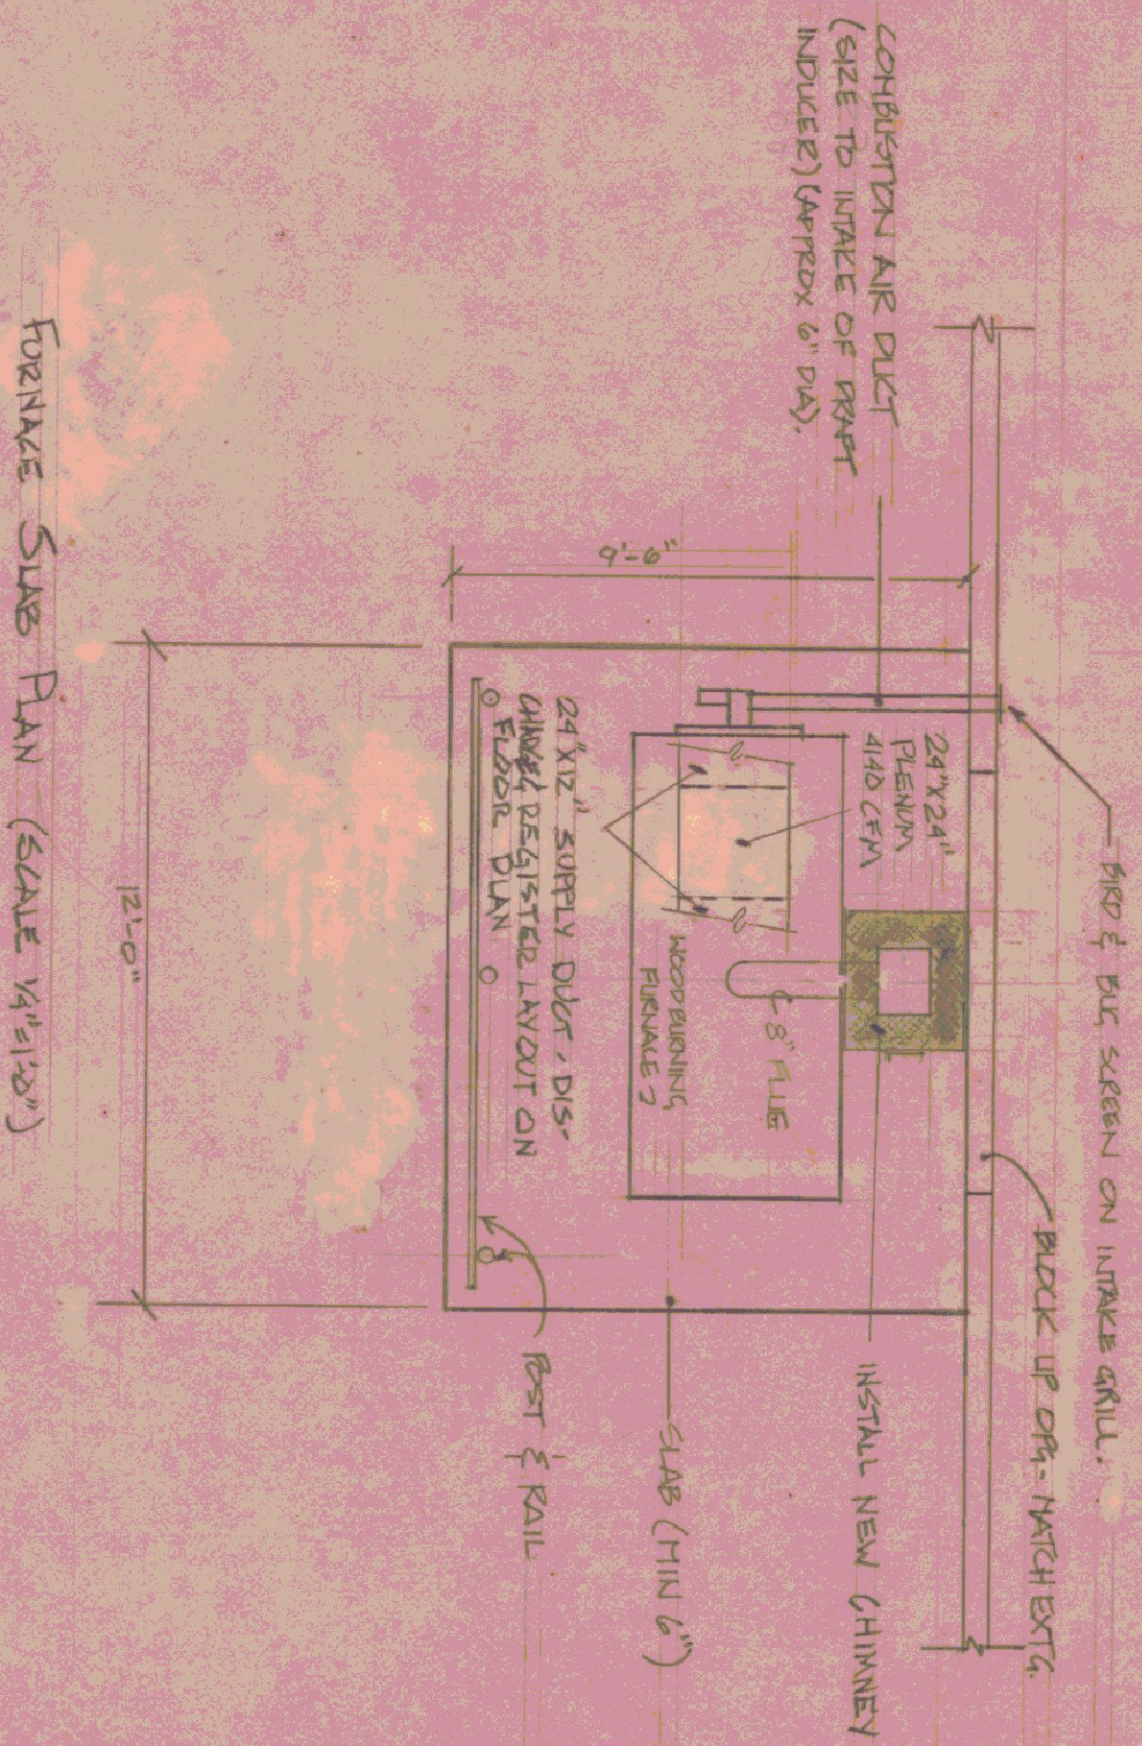

FURNACE SUB PLAN (SCALE 1/4" = 1'-0")

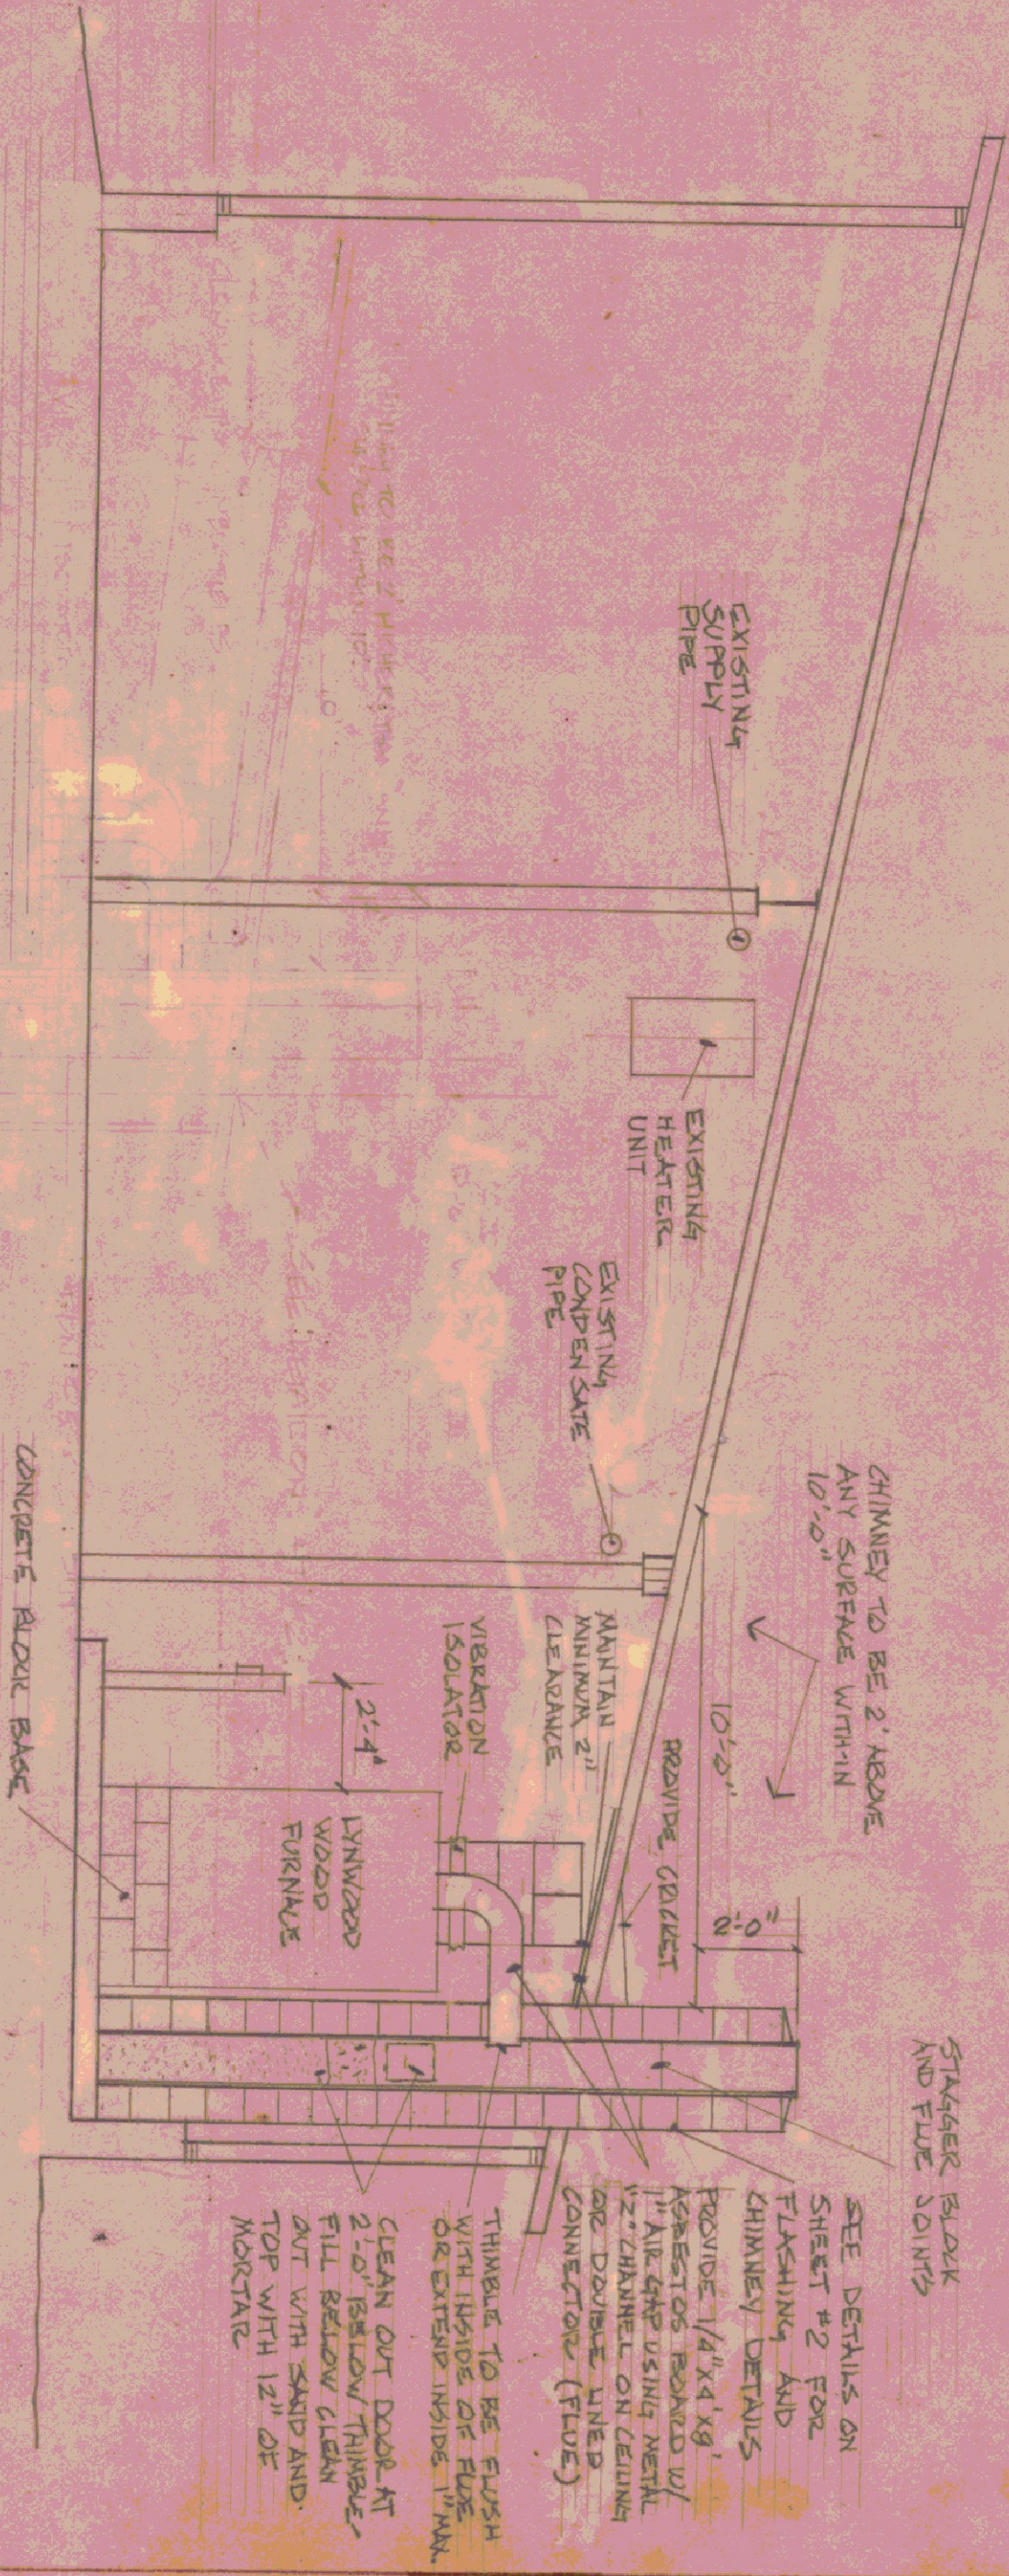

ELEVATION @ REAR OF FURNACE

THESE ELEVATIONS TAKE PRECEDENT OVER ELEVATIONS ON SHEET 2 - ARCHD INST. OF ELEV. DETAILS ON SHEET 2 ARE SET IN EFFECT

STATE OF VERMONT			
DIVISION OF STATE BUILDINGS			
AGENCY OF ADMINISTRATION			
MONTPELIER, VERMONT			
WOODBURNING FURNACE INSTALLATION			
@ AGENCY OF TRANSPORTATION GARAGE			
ROCKINGHAM, VERMONT			
DATE:	8-20-80	SCALE:	AS NOTED
DRAWN BY:	HKF/KH	APPROVED BY:	G. M. M. / KH
REVISIONS:	10-20-80 KH	DWG. NO.	1 OF 3