


PUMPING SCHEDULE

- P-1 AMERICAN STANDARD 18" HIGH ELONGATED CADET TOILET, MODEL 9408.018 SLOAN ROYAL FLUSH VALVE 110-3
- P-2 AM. STD. ULTERNE LAV, 30"x18" MODEL 0350.015" MODEL 2238.202 GOOSENECK SHUT
- P-3 HANSEY TAYLOR BRACKET FTH, MODEL 0000

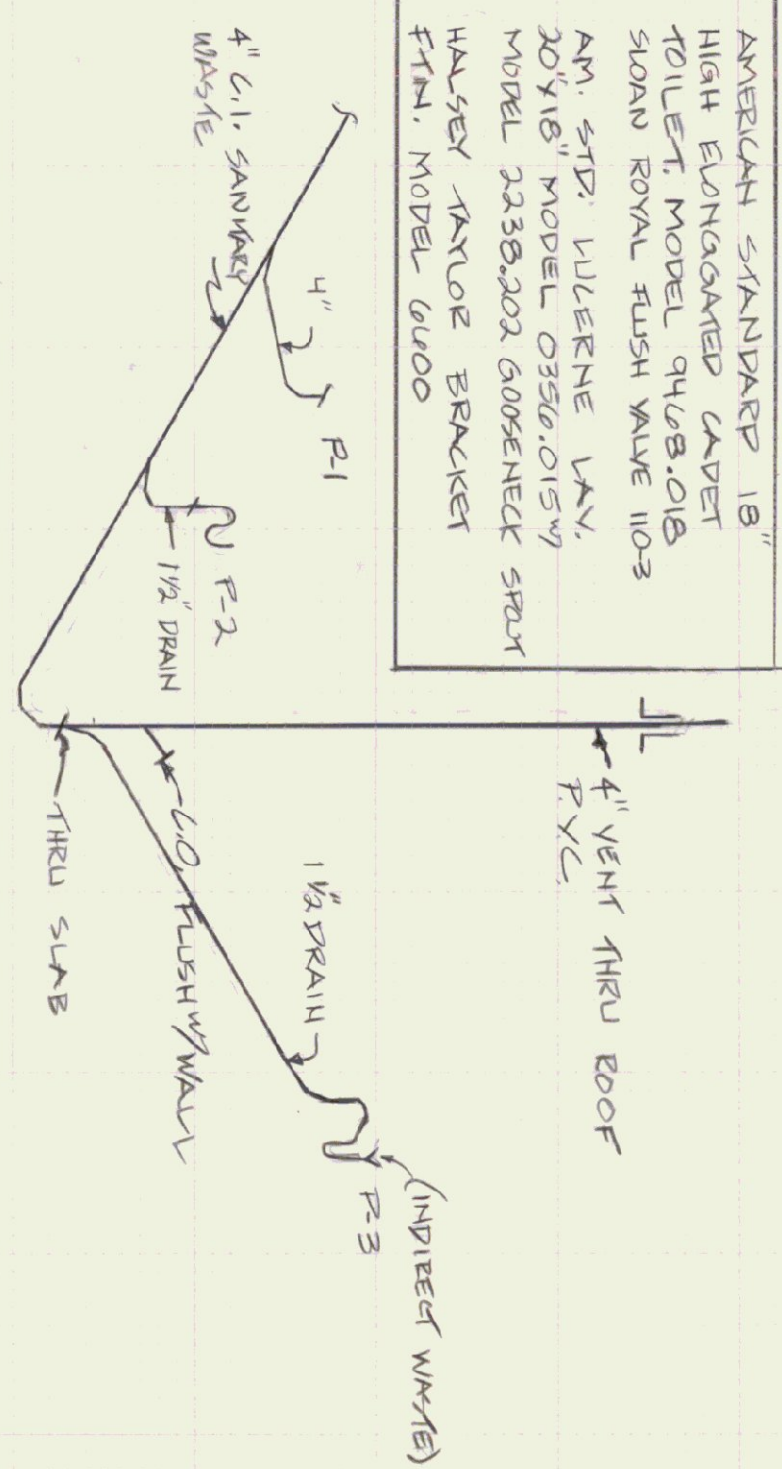


SANITARY WASTE RISER DIAGRAM

N.T.S.

NOTE: ALL PIPE UNDER SLAB TO BE CAST SECOND

--- COLD WATER
--- HOT WATER

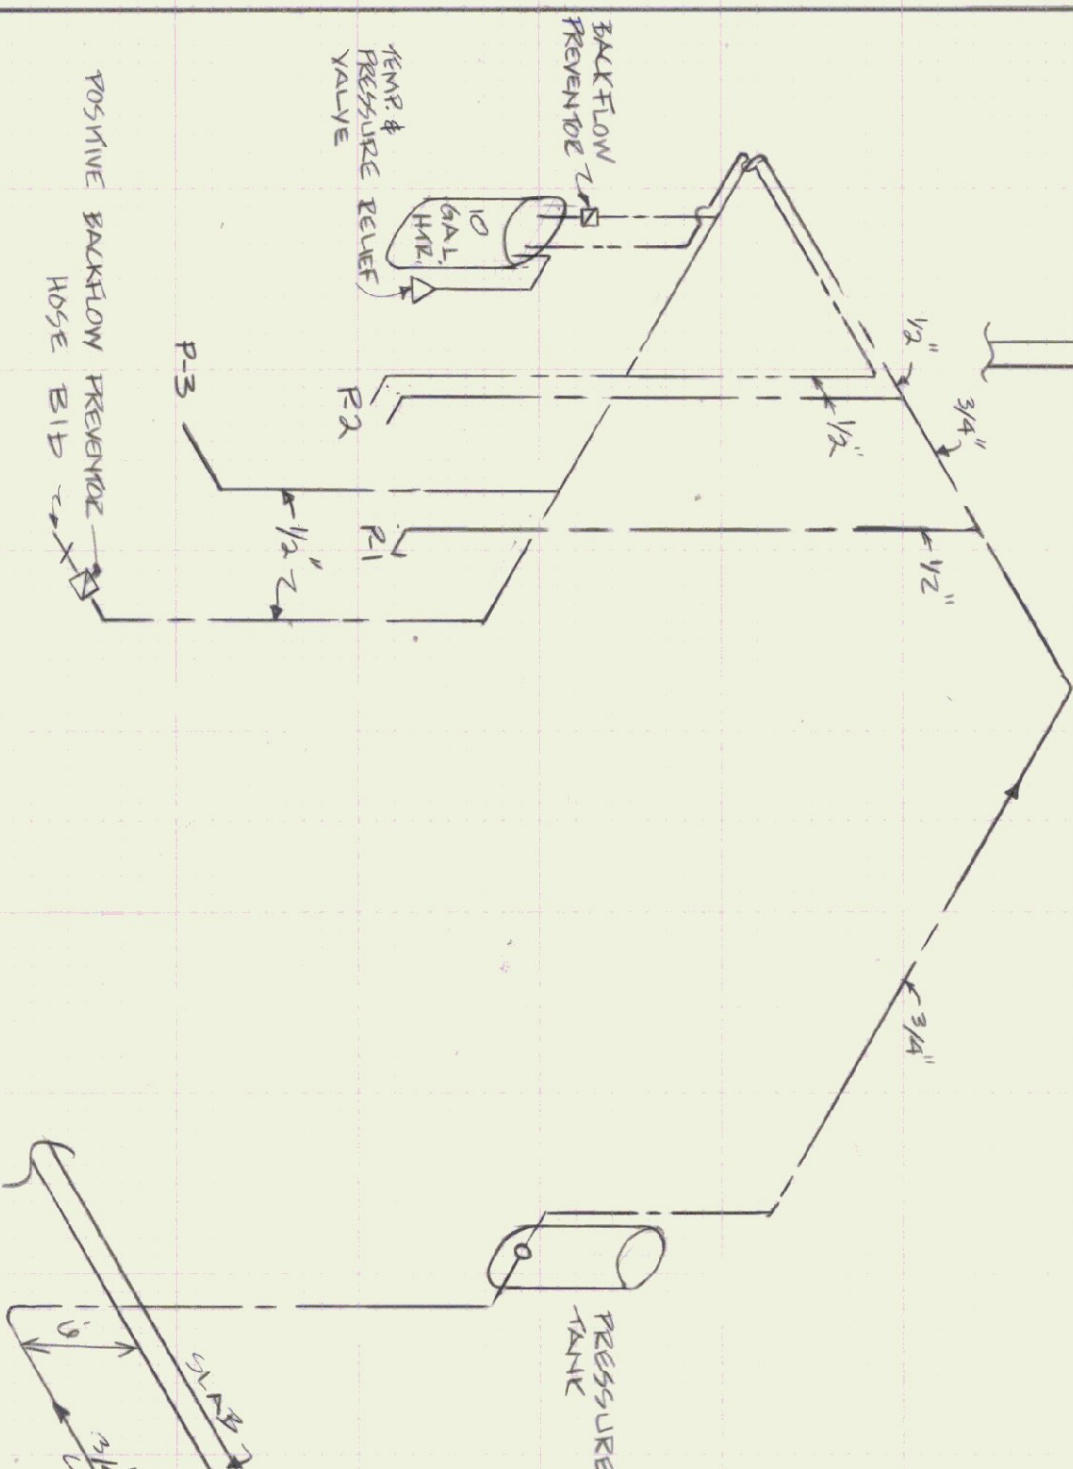

HOT & COLD WATER RISER DIAGRAM



STATE OF VERMONT
DEPARTMENT OF STATE BUILDINGS
AGENCY OF ADMINISTRATION
MONTPELIER, VERMONT

TUNBRIDGE HIGHWAY GARAGE
PLUMBING DETAILS

TUNBRIDGE		VERMONT	
DATE:	SCALE:	REVISIONS:	WG. NO.
9/15/87	M.T.S.		7-1
DRAWN BY:	APPROVED BY:		
E. T. RUST	F. R. RUST		