
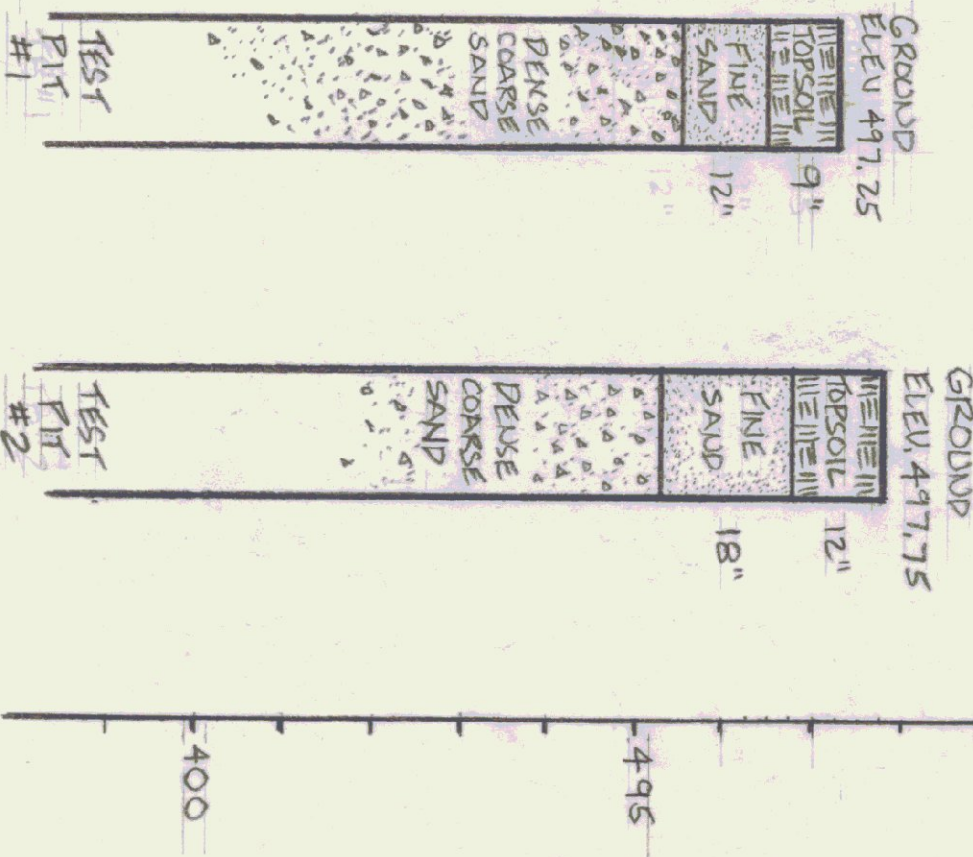
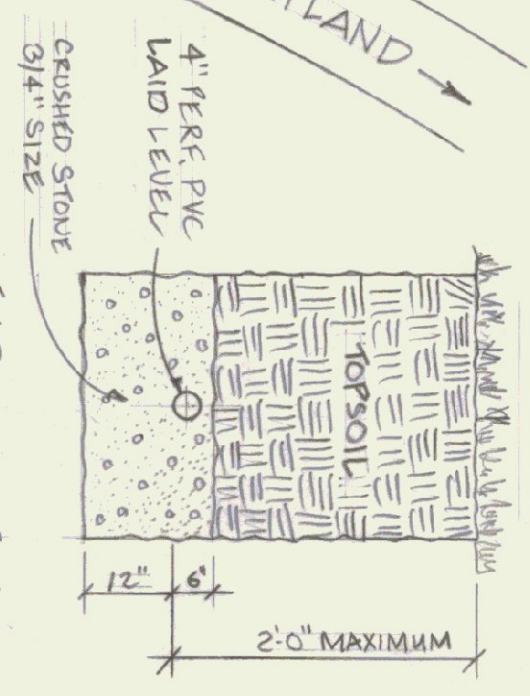
 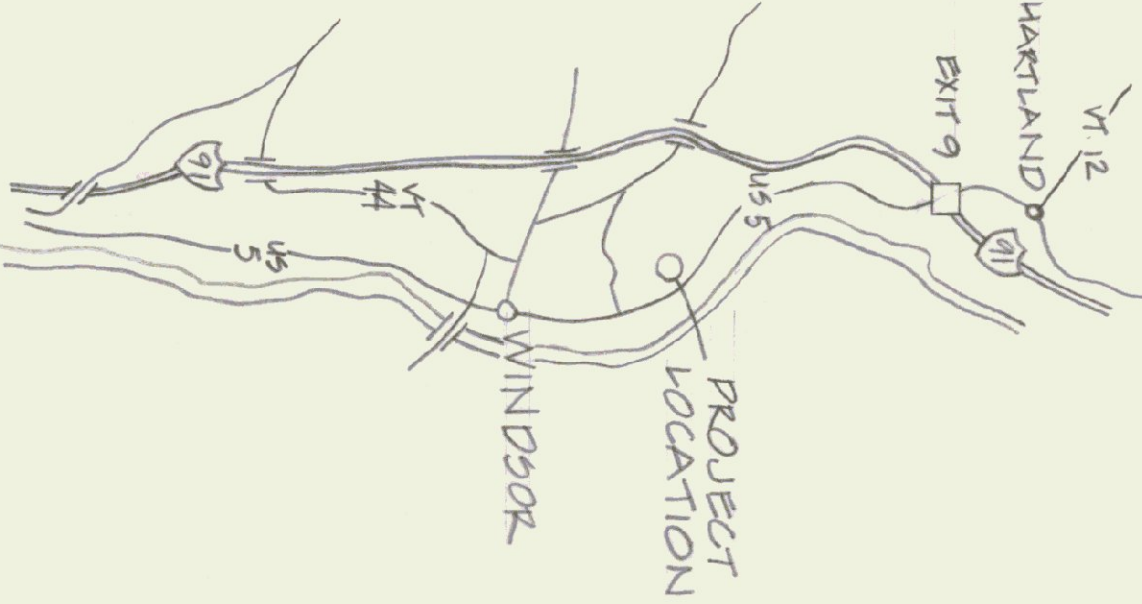




STATE OF VERMONT
DIVISION OF STATE BUILDINGS
AGENCY OF ADMINISTRATION
MONTPELIER, VERMONT

VERMONT AGENCY OF TRANSPORTATION
SITE PLAN
5 DAY GARAGE
WINDSOR, VERMONT DISTRICT 4

DATE: AUG 6, 1983	SCALE: 1" = 50'-0"	REVISIONS: 10/25/83 JTO	DWG. NO. 5-1
DRAWN BY: A. ROWAN	APPROVED BY: F. TERRY	142400 AVE	1 OF 12

SEPTIC DESIGN INFORMATION

- DESIGN FLOW — 150 GPF
- PERCOLATION RATE — 11 MIN / INCH
- APPLICATION RATE — 0.9 GAL / FT² / DAY
- FACTOR OF SAFETY — 1.25
- TEST PIT LOCATION
- PERCOLATION TEST

