

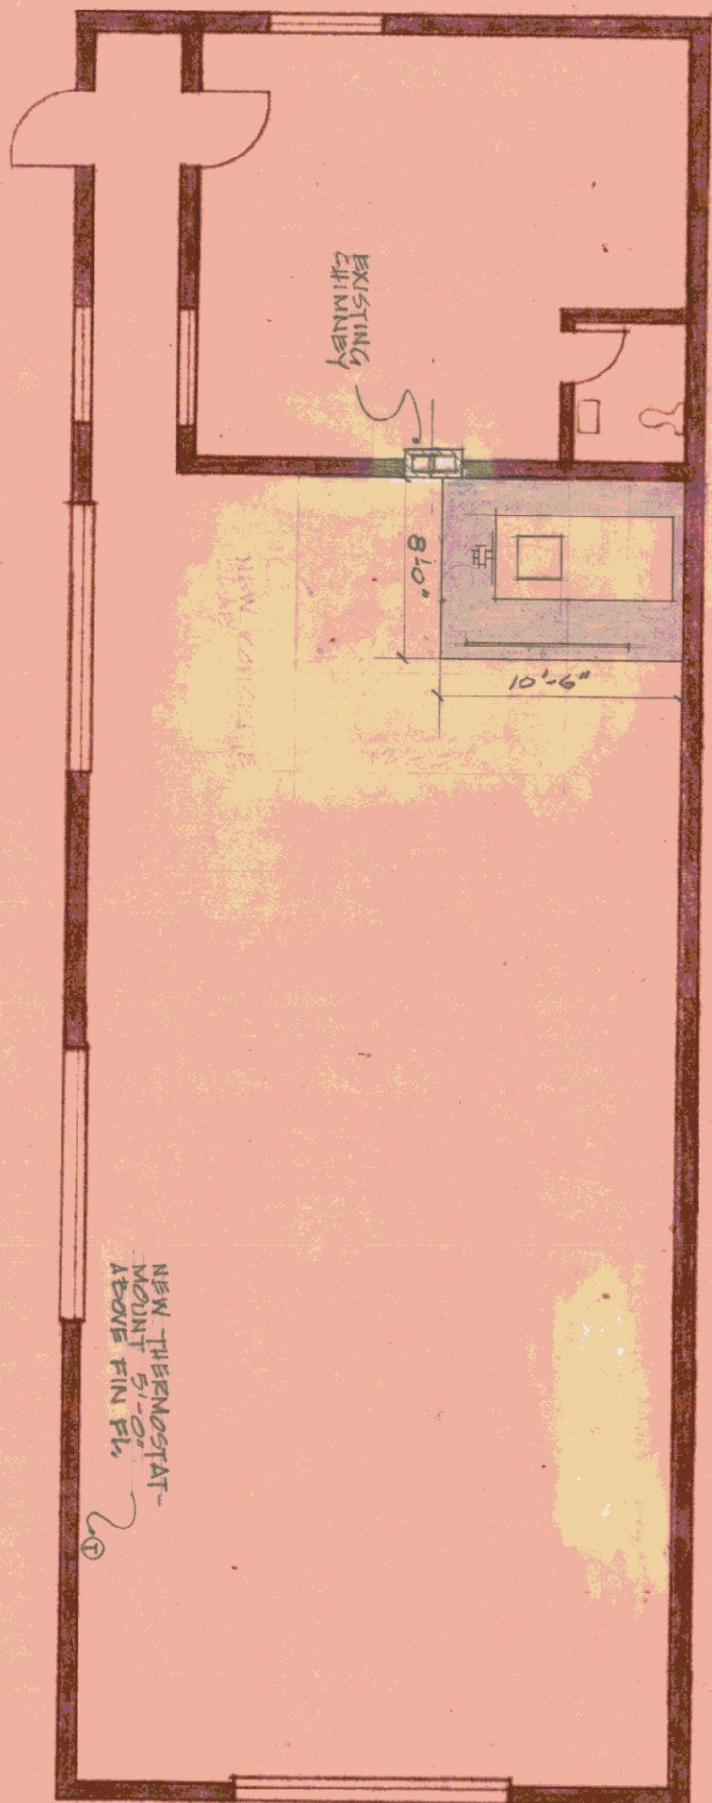


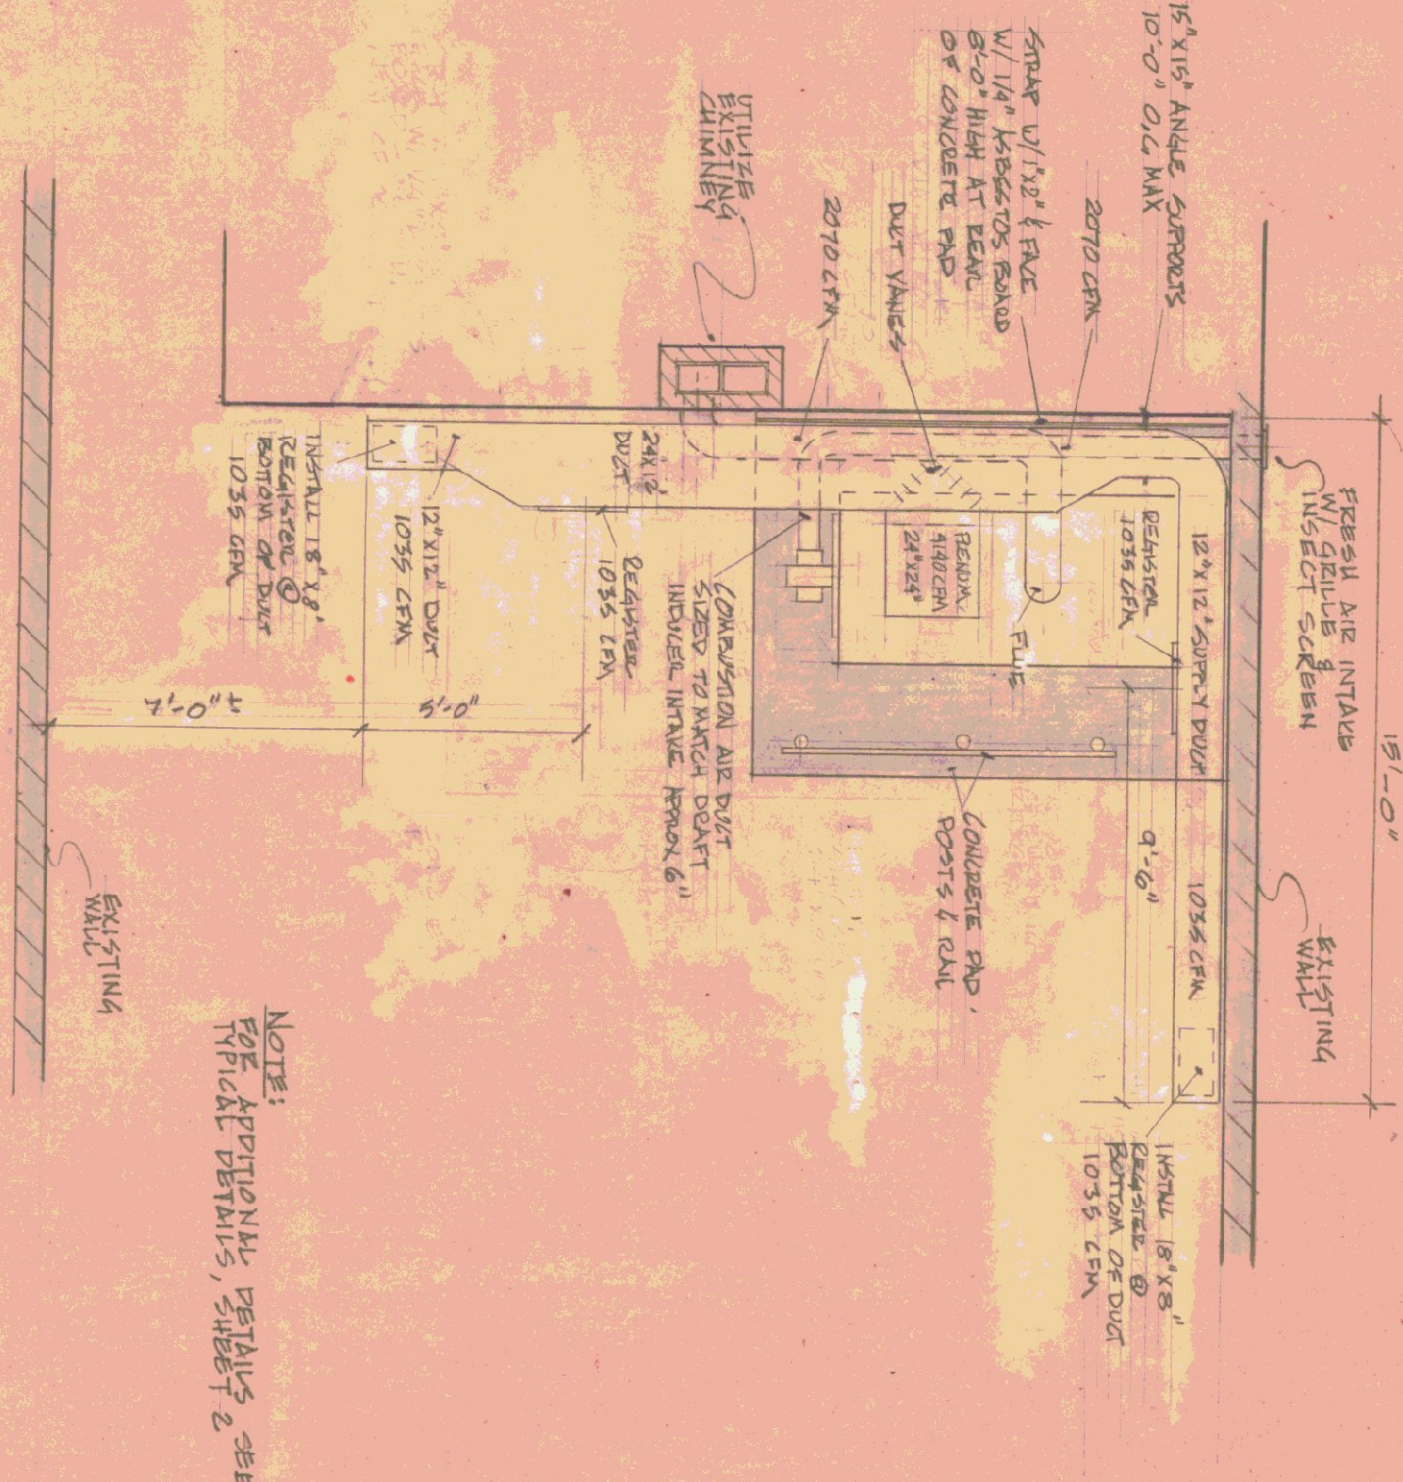

FLOOR PLAN
SCALE: $\frac{1}{8}" = 1'-0"$

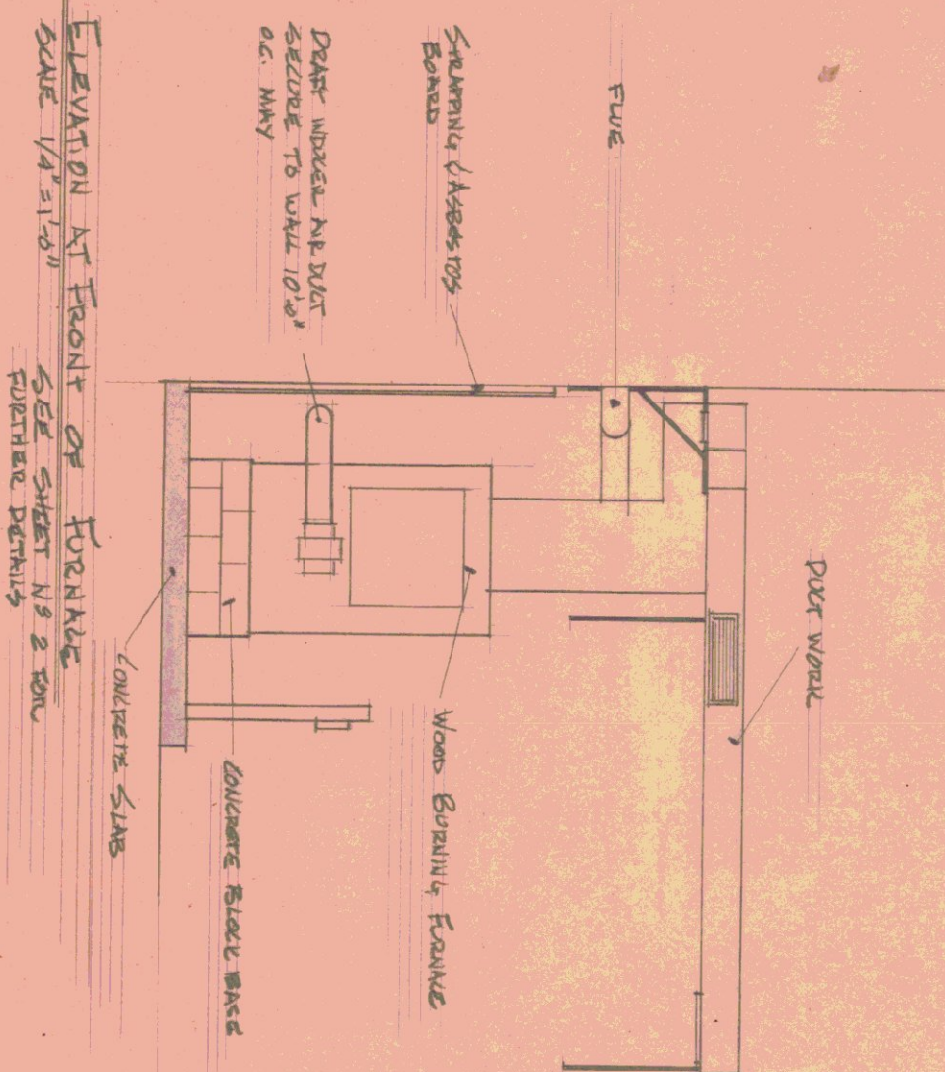

PLAN @ FURNACE SLAB
SCALE: $\frac{1}{4}" = 1'-0"$

NOTE:
FOR ADDITIONAL DETAILS, SEE
TRIAL DETAILS, SHEET 2

STATE OF VERMONT			
DIVISION OF STATE BUILDINGS			
AGENCY OF ADMINISTRATION			
MONTPELIER, VERMONT			
WOODBURNING FURNACE INSTALLATION			
AGENCY OF TRANSPORTATION AGENCY			
WOODSTOCK, VT.			
DATE:	SCALE:	REVISIONS:	DWG. NO.
8-11-80	AS NOTED	drawn by: 10-15-80	1 OF 3
DRAWN BY:	APPROVED BY:		
RT	RM/1/80		