



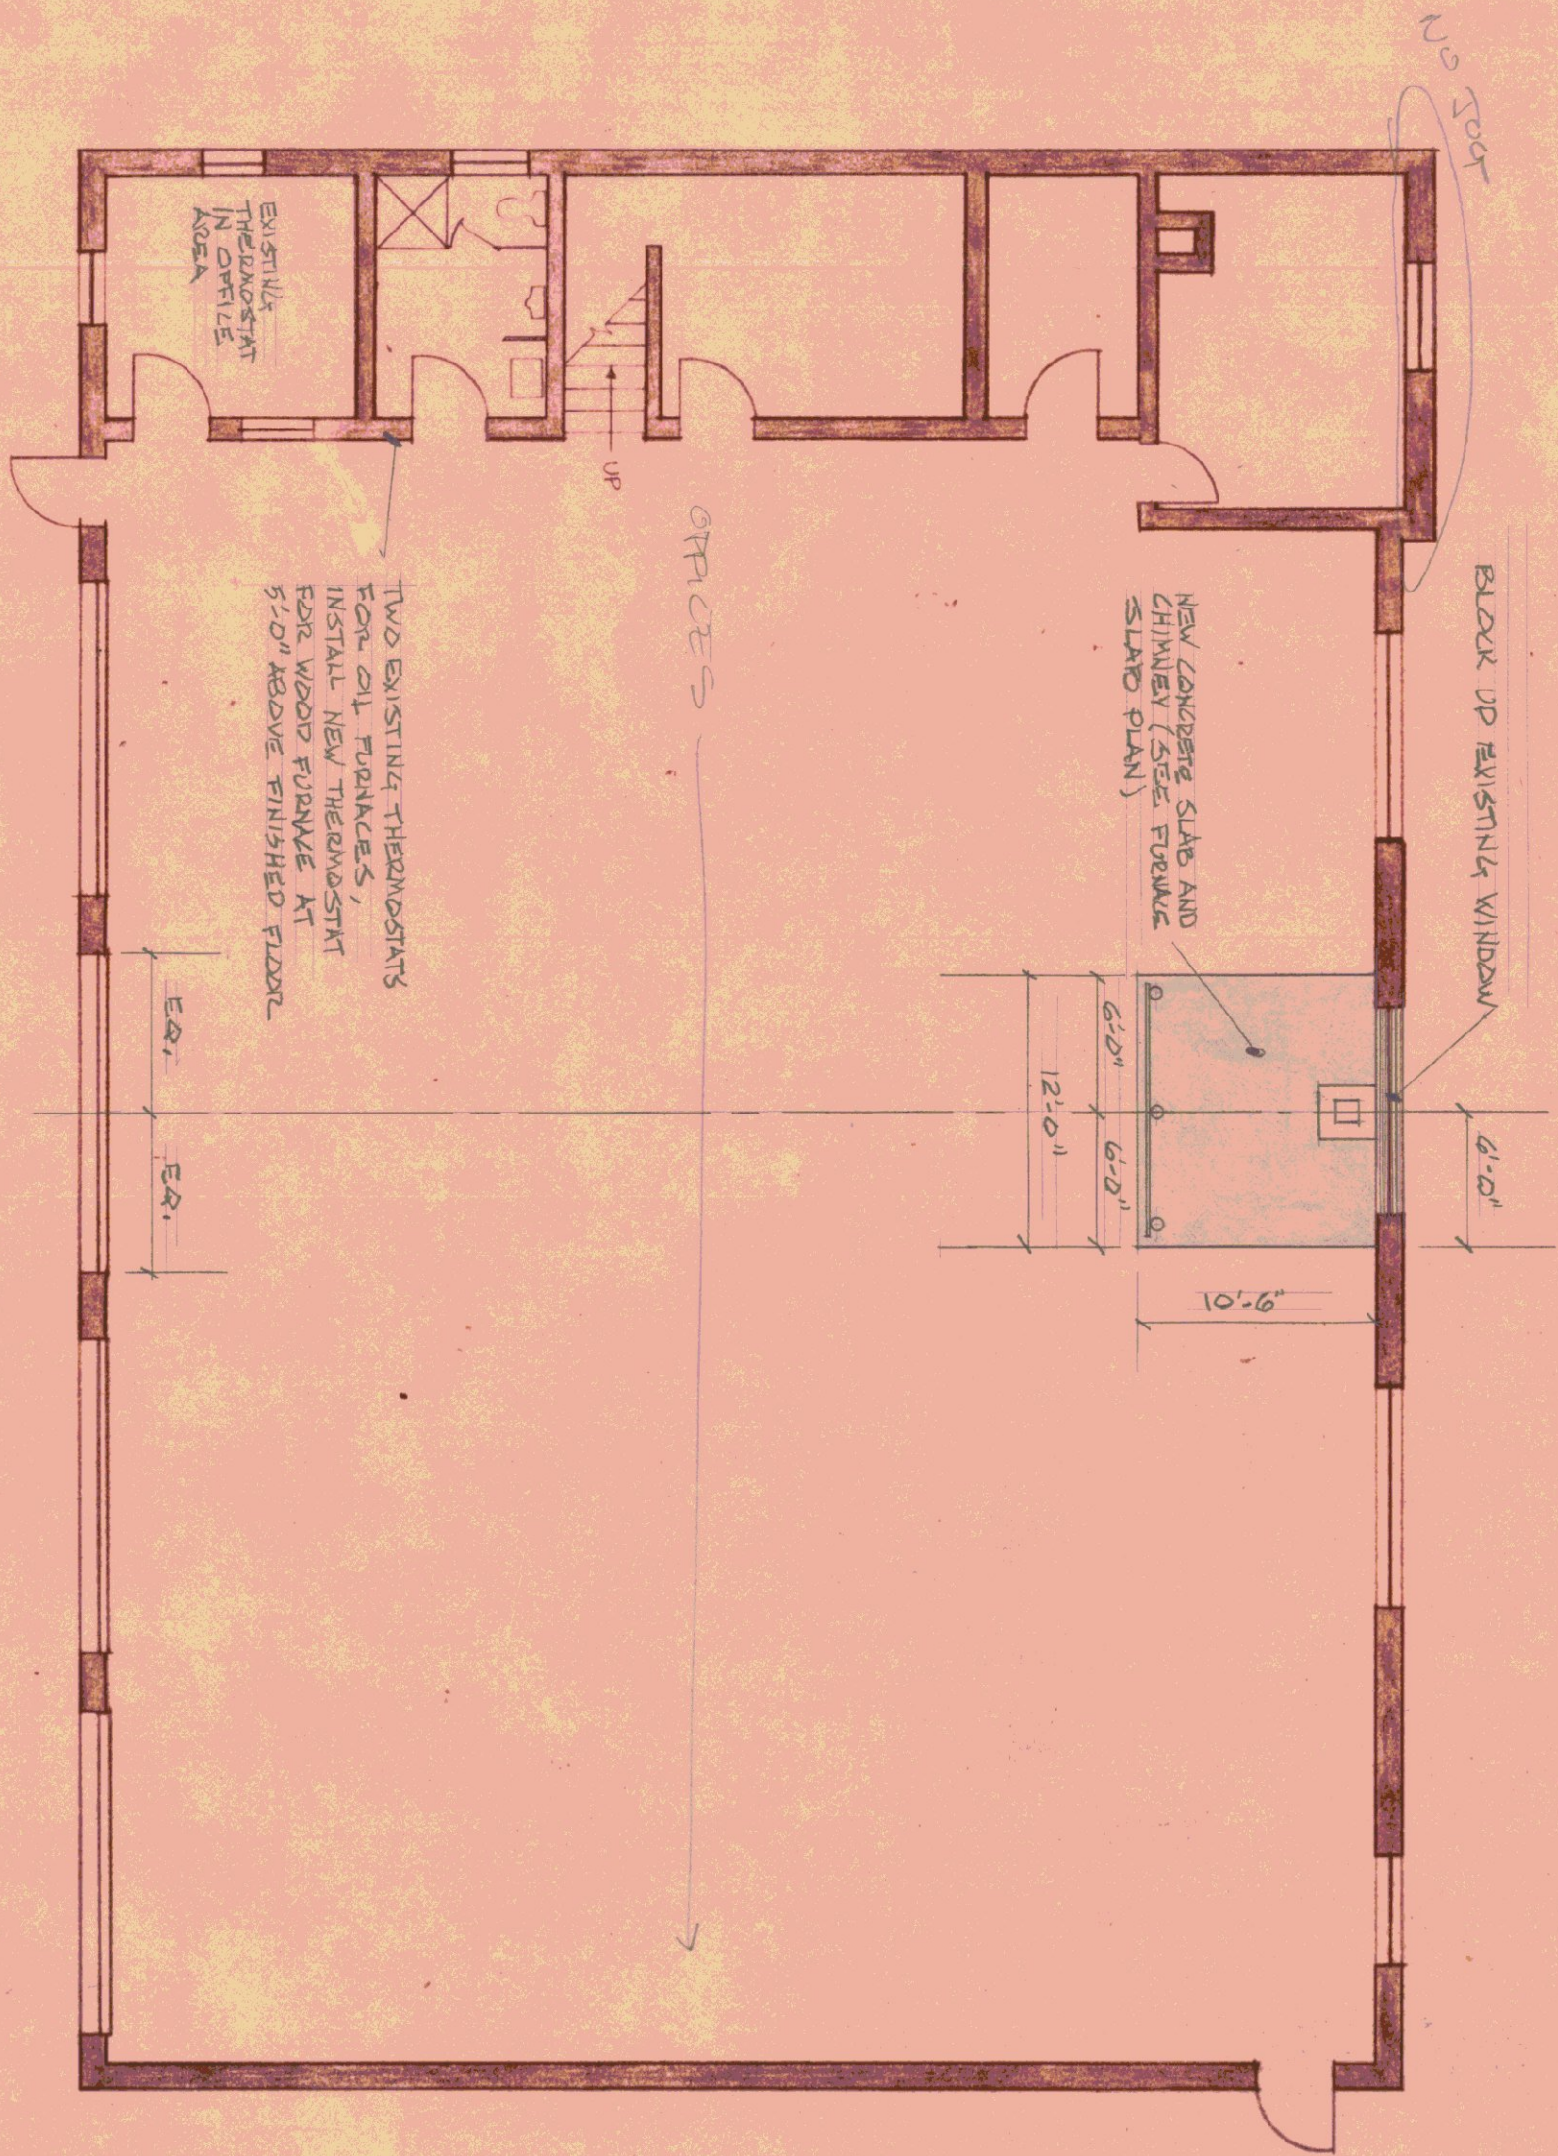

FLOOR PLAN
SCALE: $\frac{1}{8}"=1'-0"$

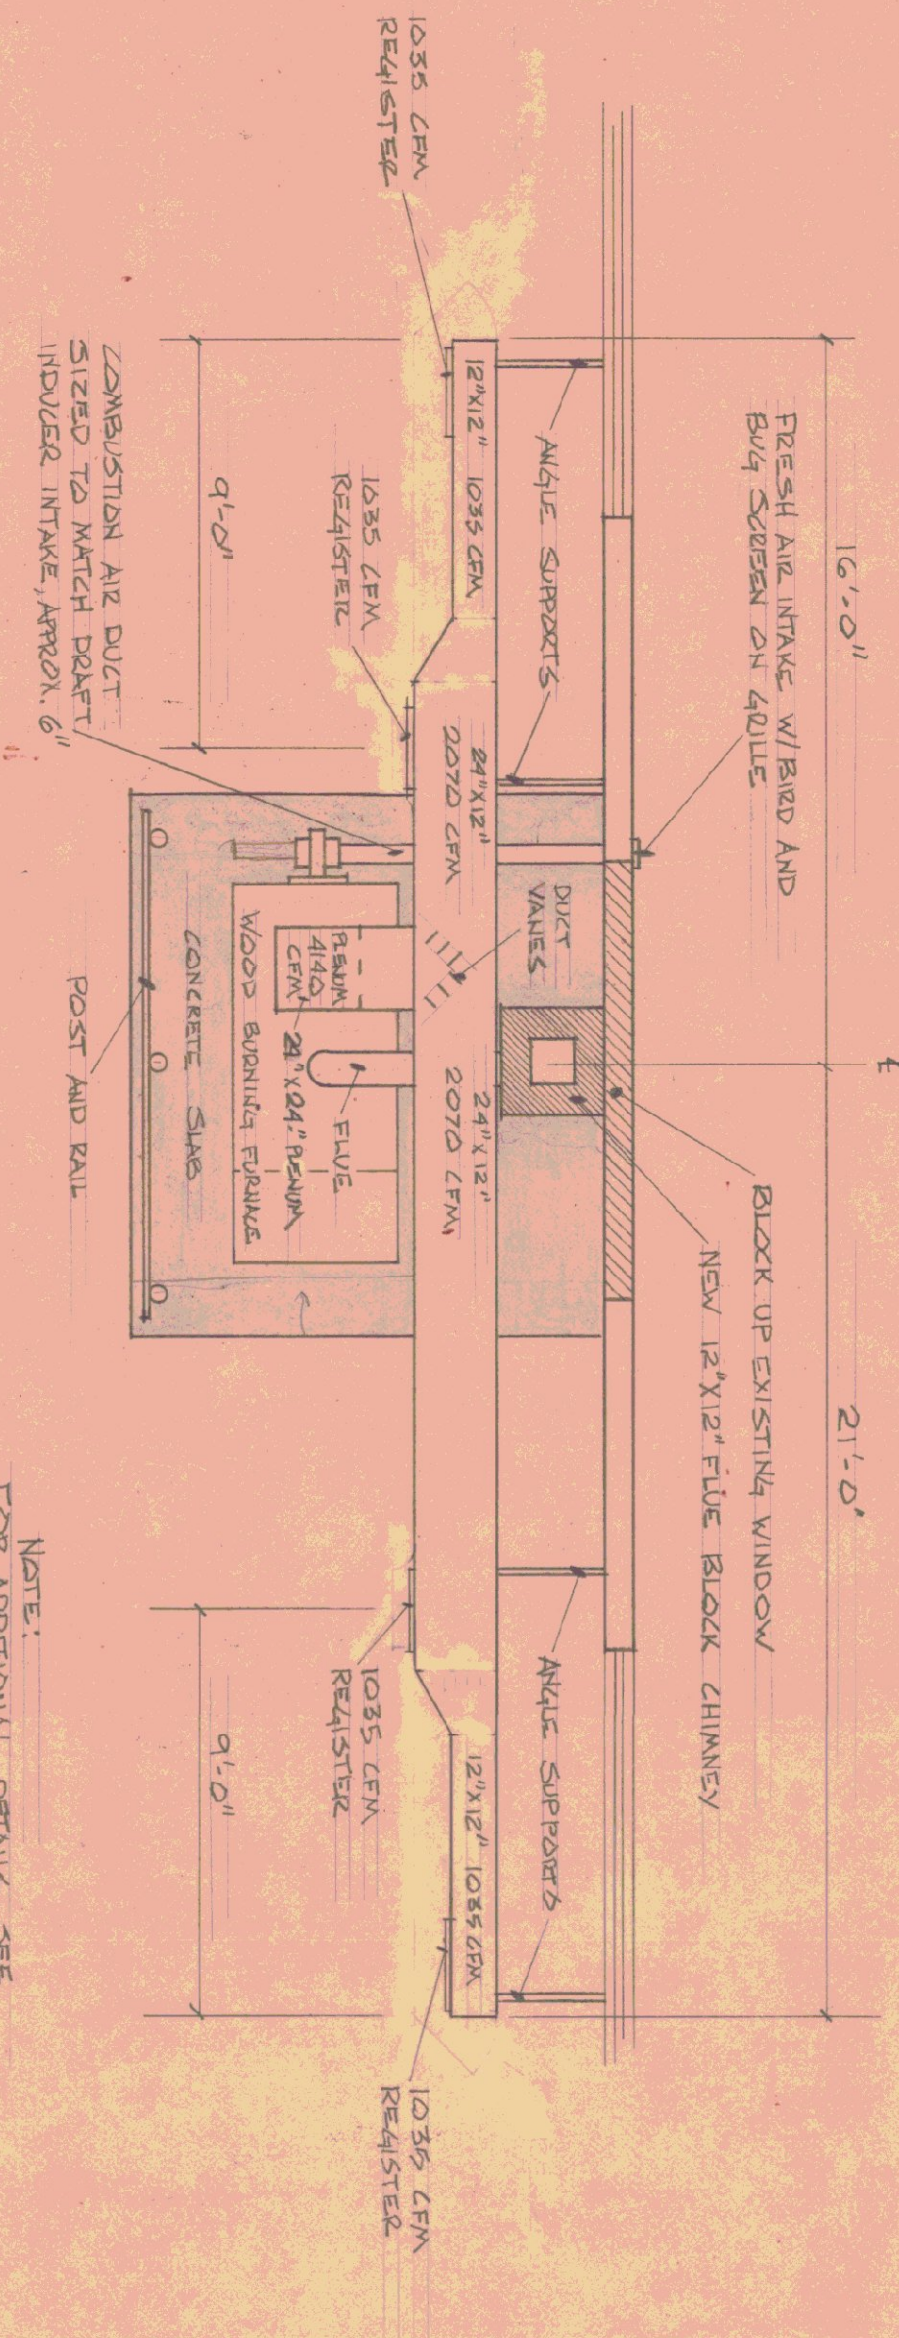

NOTE:
FOR ADDITIONAL DETAILS, SEE
TYPICAL DETAILS, SHEET N-2

PLAN AT FURNACE AT SLAB SCALE: $\frac{1}{4}"=1'-0"$

STATE OF VERMONT			
DIVISION OF STATE BUILDINGS			
AGENCY OF ADMINISTRATION			
MONTPELIER, VERMONT			
WOOD BURNING FURNACE INSTALLATION			
AT THE AGENCY OF TRANSPORTATION GARAGE			
NEWBURY, VERMONT			
DATE: 7-28-80	SCALE: AS NOTED	REVISIONS: 10-17-80 KH.	DWG. NO. 1 OF 2
DRAWN BY: LH/HANSON	APPROVED BY: G.M. MONTPELIER		