


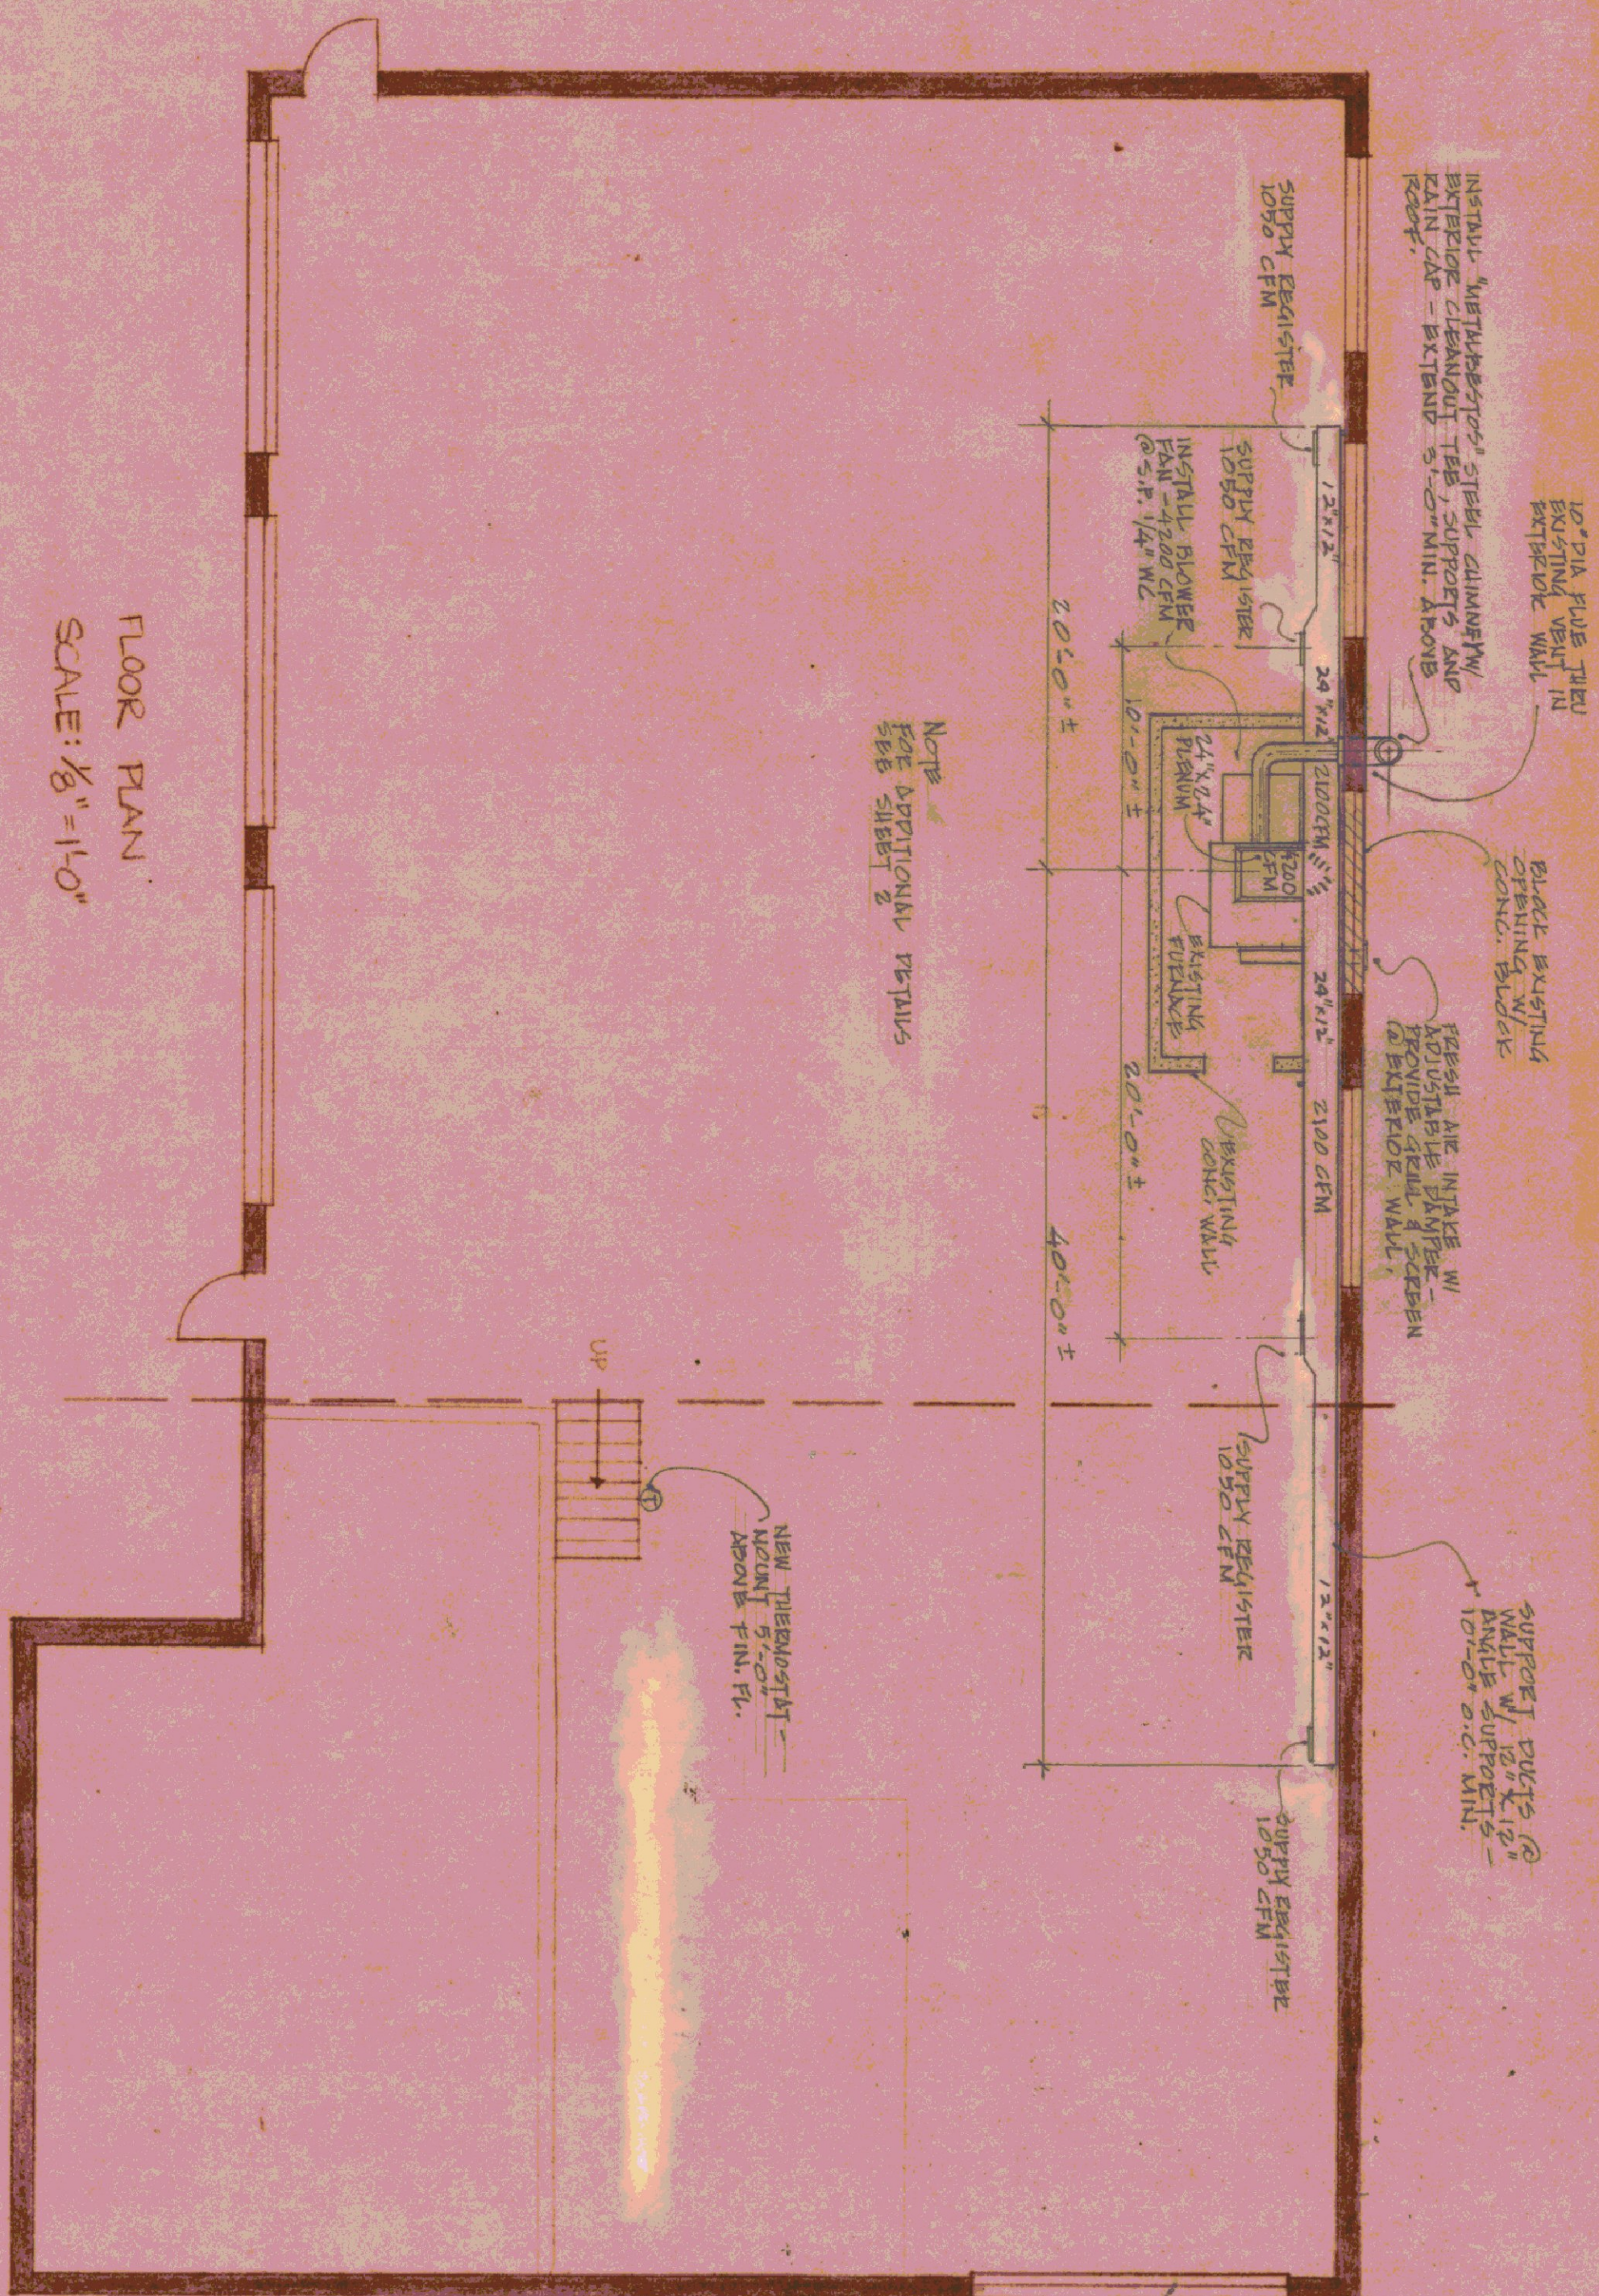

FLOOR PLAN
SCALE: 1/8"=1'-0"

ORIGINAL ONE BAY GARAGE

STATE OF VERMONT			
DIVISION OF STATE BUILDINGS			
AGENCY OF ADMINISTRATION			
MONTPELIER, VERMONT			
WOODBURNING FURNACE INSTALLATION			
@ AGENCY OF TRANSPORTATION GARAGE			
BRADFORD, VT.			
DATE: 7-29-80	SCALE: AS NOTED	REVISIONS: CHANGED 2009-10-15-80	DWG. NO.
DRAWN BY: Lkt J. Hovius	APPROVED BY: J. Hovius		1 OF 3