




FIRST FLOOR PLAN - PLUMBING
 SCALE: 1/4" = 1'-0"

FIXTURE SCHEDULE

FIXTURES	SOIL	WASTE	TRAPS	VENT	TRAP
WATER FLOORS	4"				INT.
BATHS	2"	1"	1 1/2"	1"	INT.
LAVATORY	1 1/2"	1 1/2"	1 1/2"	1 1/2"	INT.
HYD. BATH	1 1/2"	1 1/2"	1 1/2"	1 1/2"	INT.
BATH	1 1/2"	1 1/2"	1 1/2"	1 1/2"	INT.
DRINK FOUNTAIN	1 1/2"	1 1/2"	1 1/2"	1 1/2"	INT.
LAB. SINK	1 1/2"	1 1/2"	1 1/2"	1 1/2"	INT.

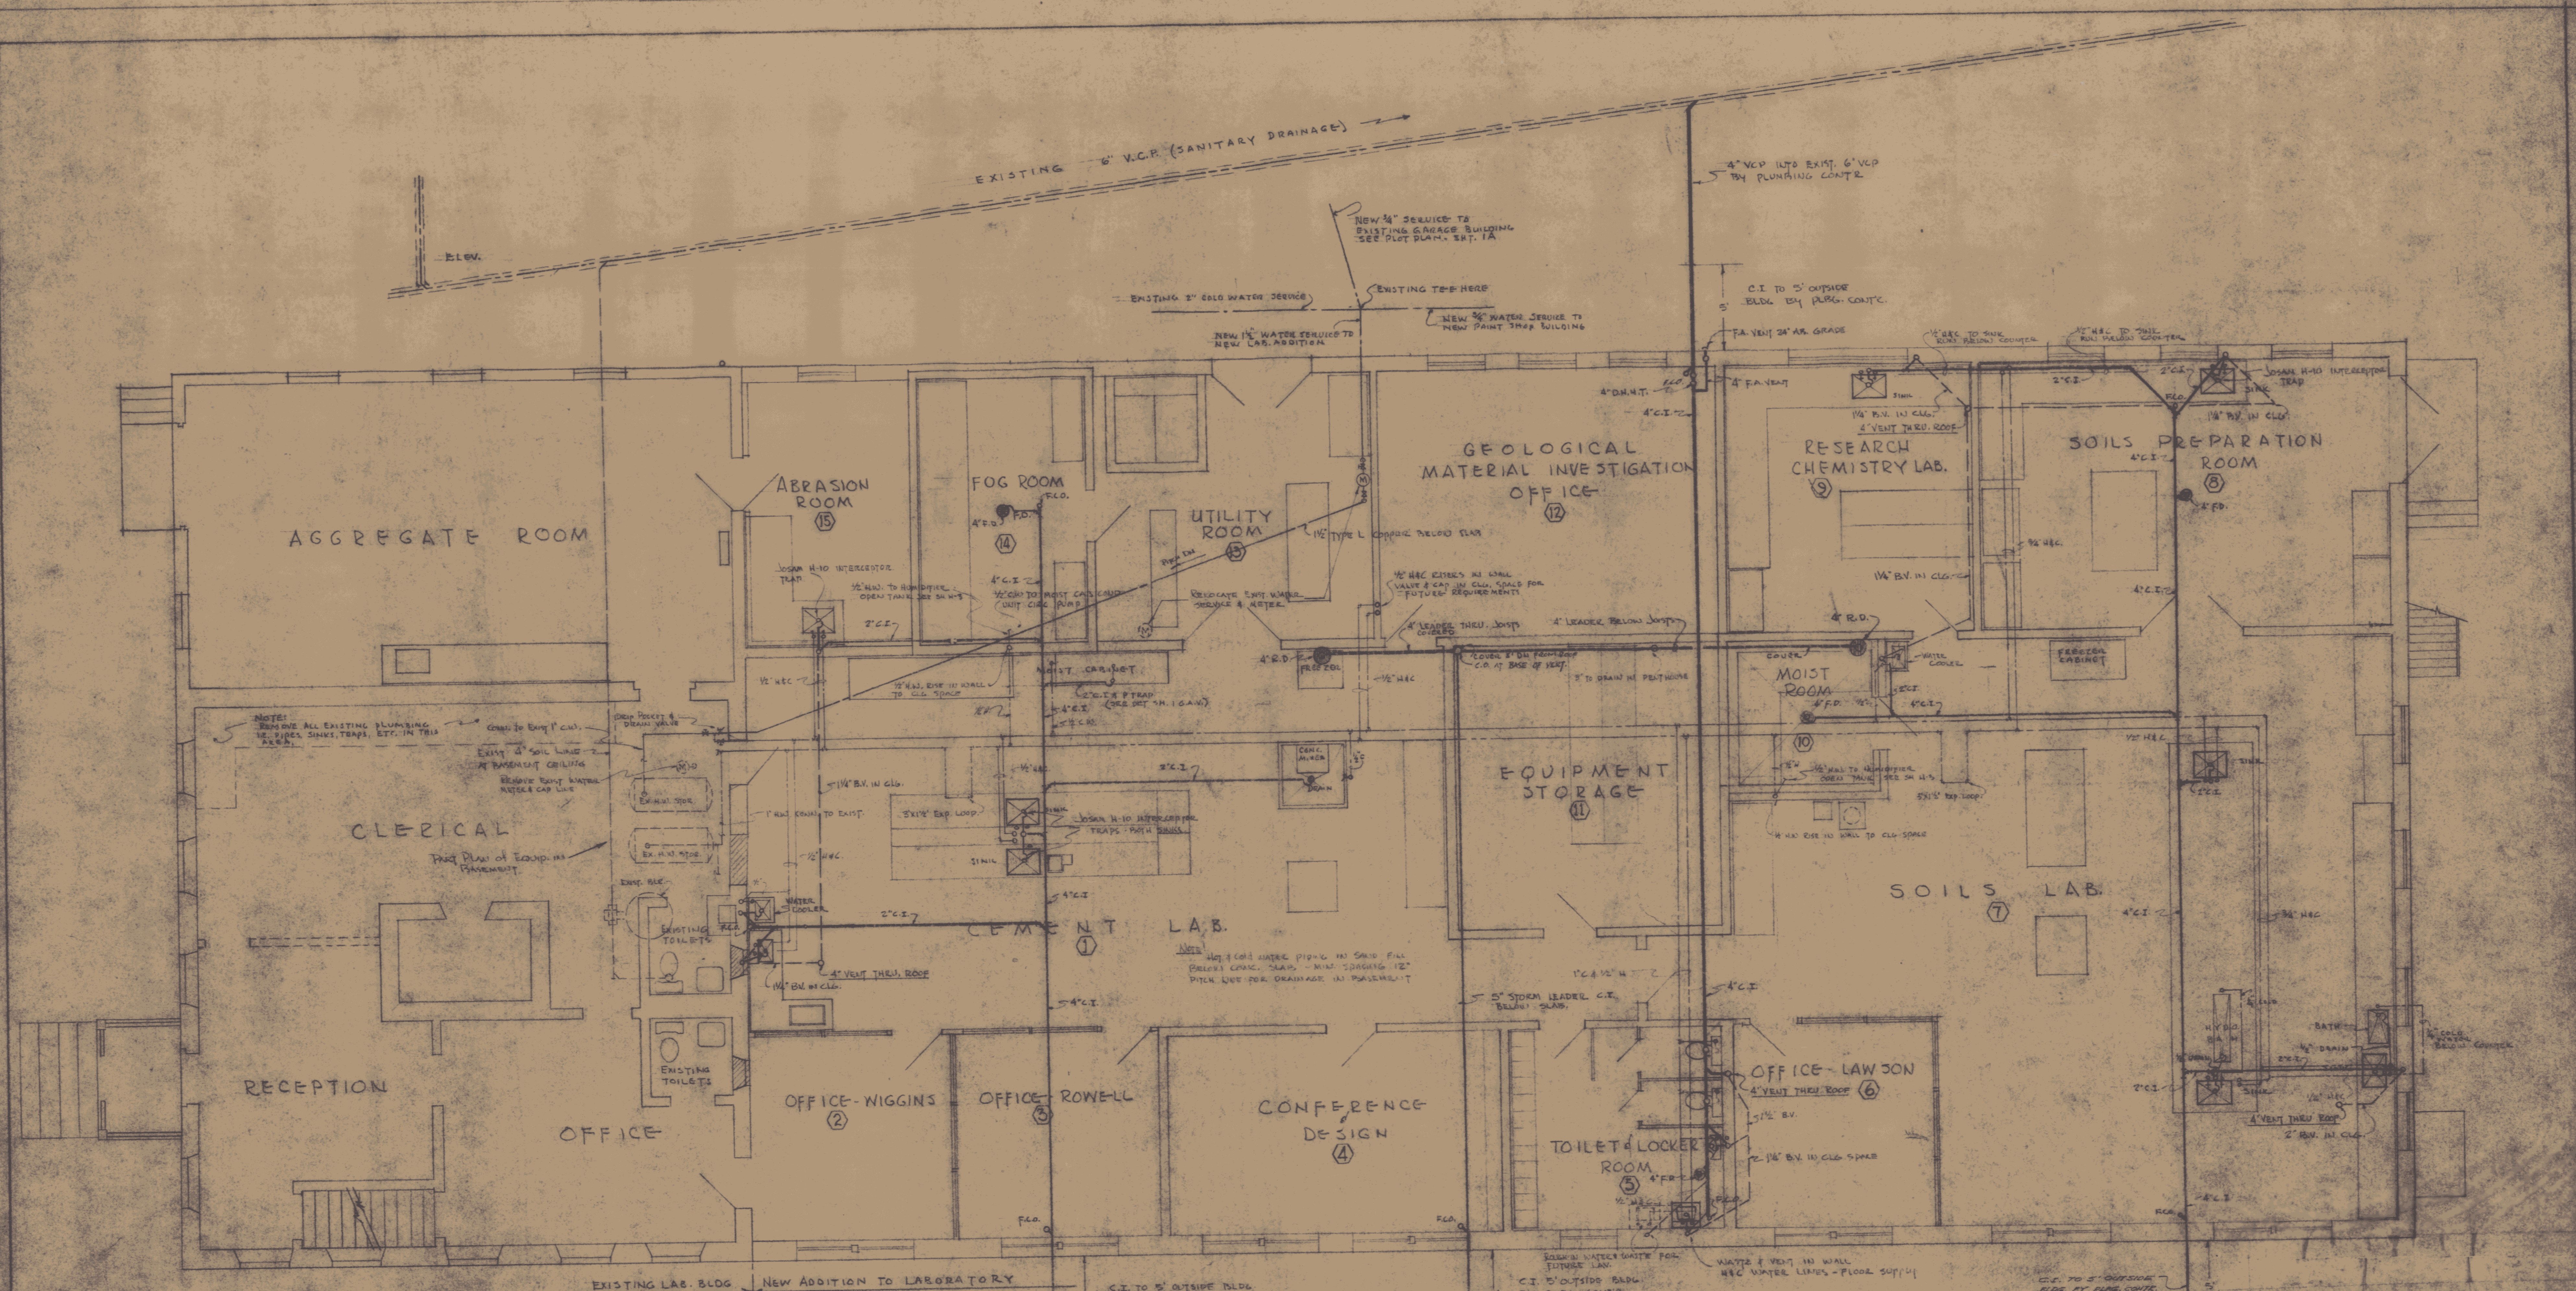

JENNISON ENGINEERING INC.
 35 COLLEGE ST. BURLINGTON, VT.

**ADDITION TO VERMONT
 STATE HIGHWAY LABORATORY**
 MONT PELLEE, VERMONT

GORDON G. WOODS
 REGISTERED PROFESSIONAL ENGINEER
 ST. JOHNSBURY, VERMONT