



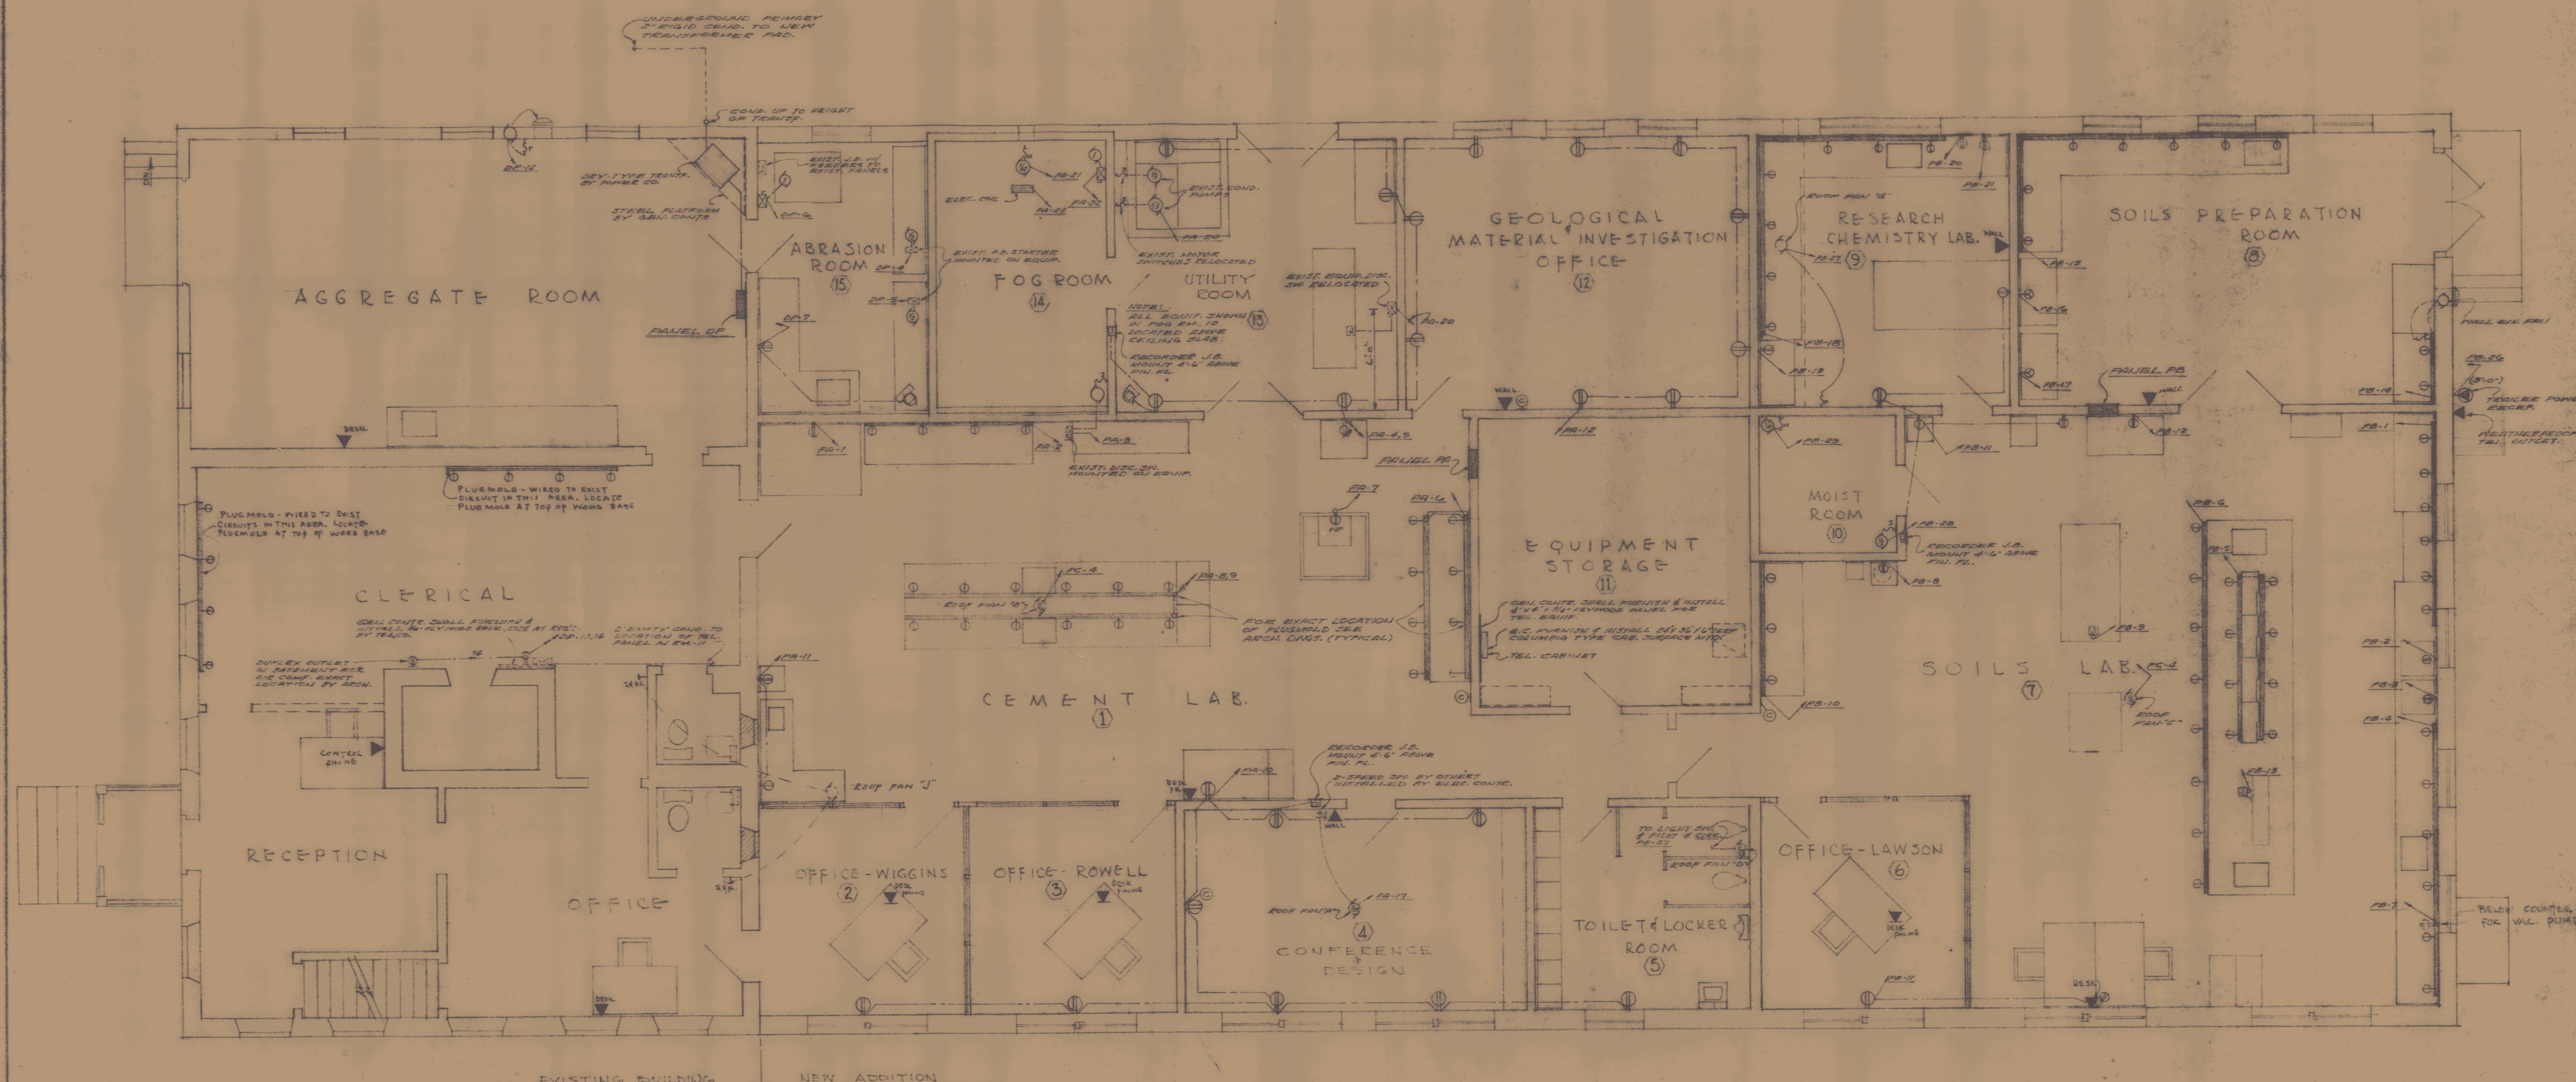

FIRST FLOOR PLAN - ELECTRICAL

SCALE: 1/4" = 1'-0"

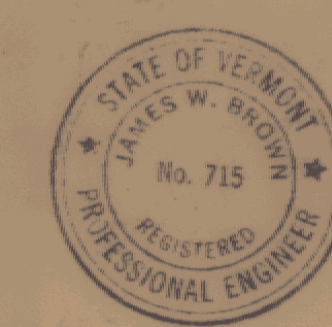

JENNISON ENGINEERING INC.
95 COLLEGE ST. BURLINGTON, VT.

ADDITION TO VERMONT
STATE HIGHWAY LABORATORY
MONTPELIER, VERMONT

GORDON G. WOODS
ARCHITECTS & ENGINEERS
ST. JOHNSBURY, VERMONT

DATE: MAR. 61
E1