




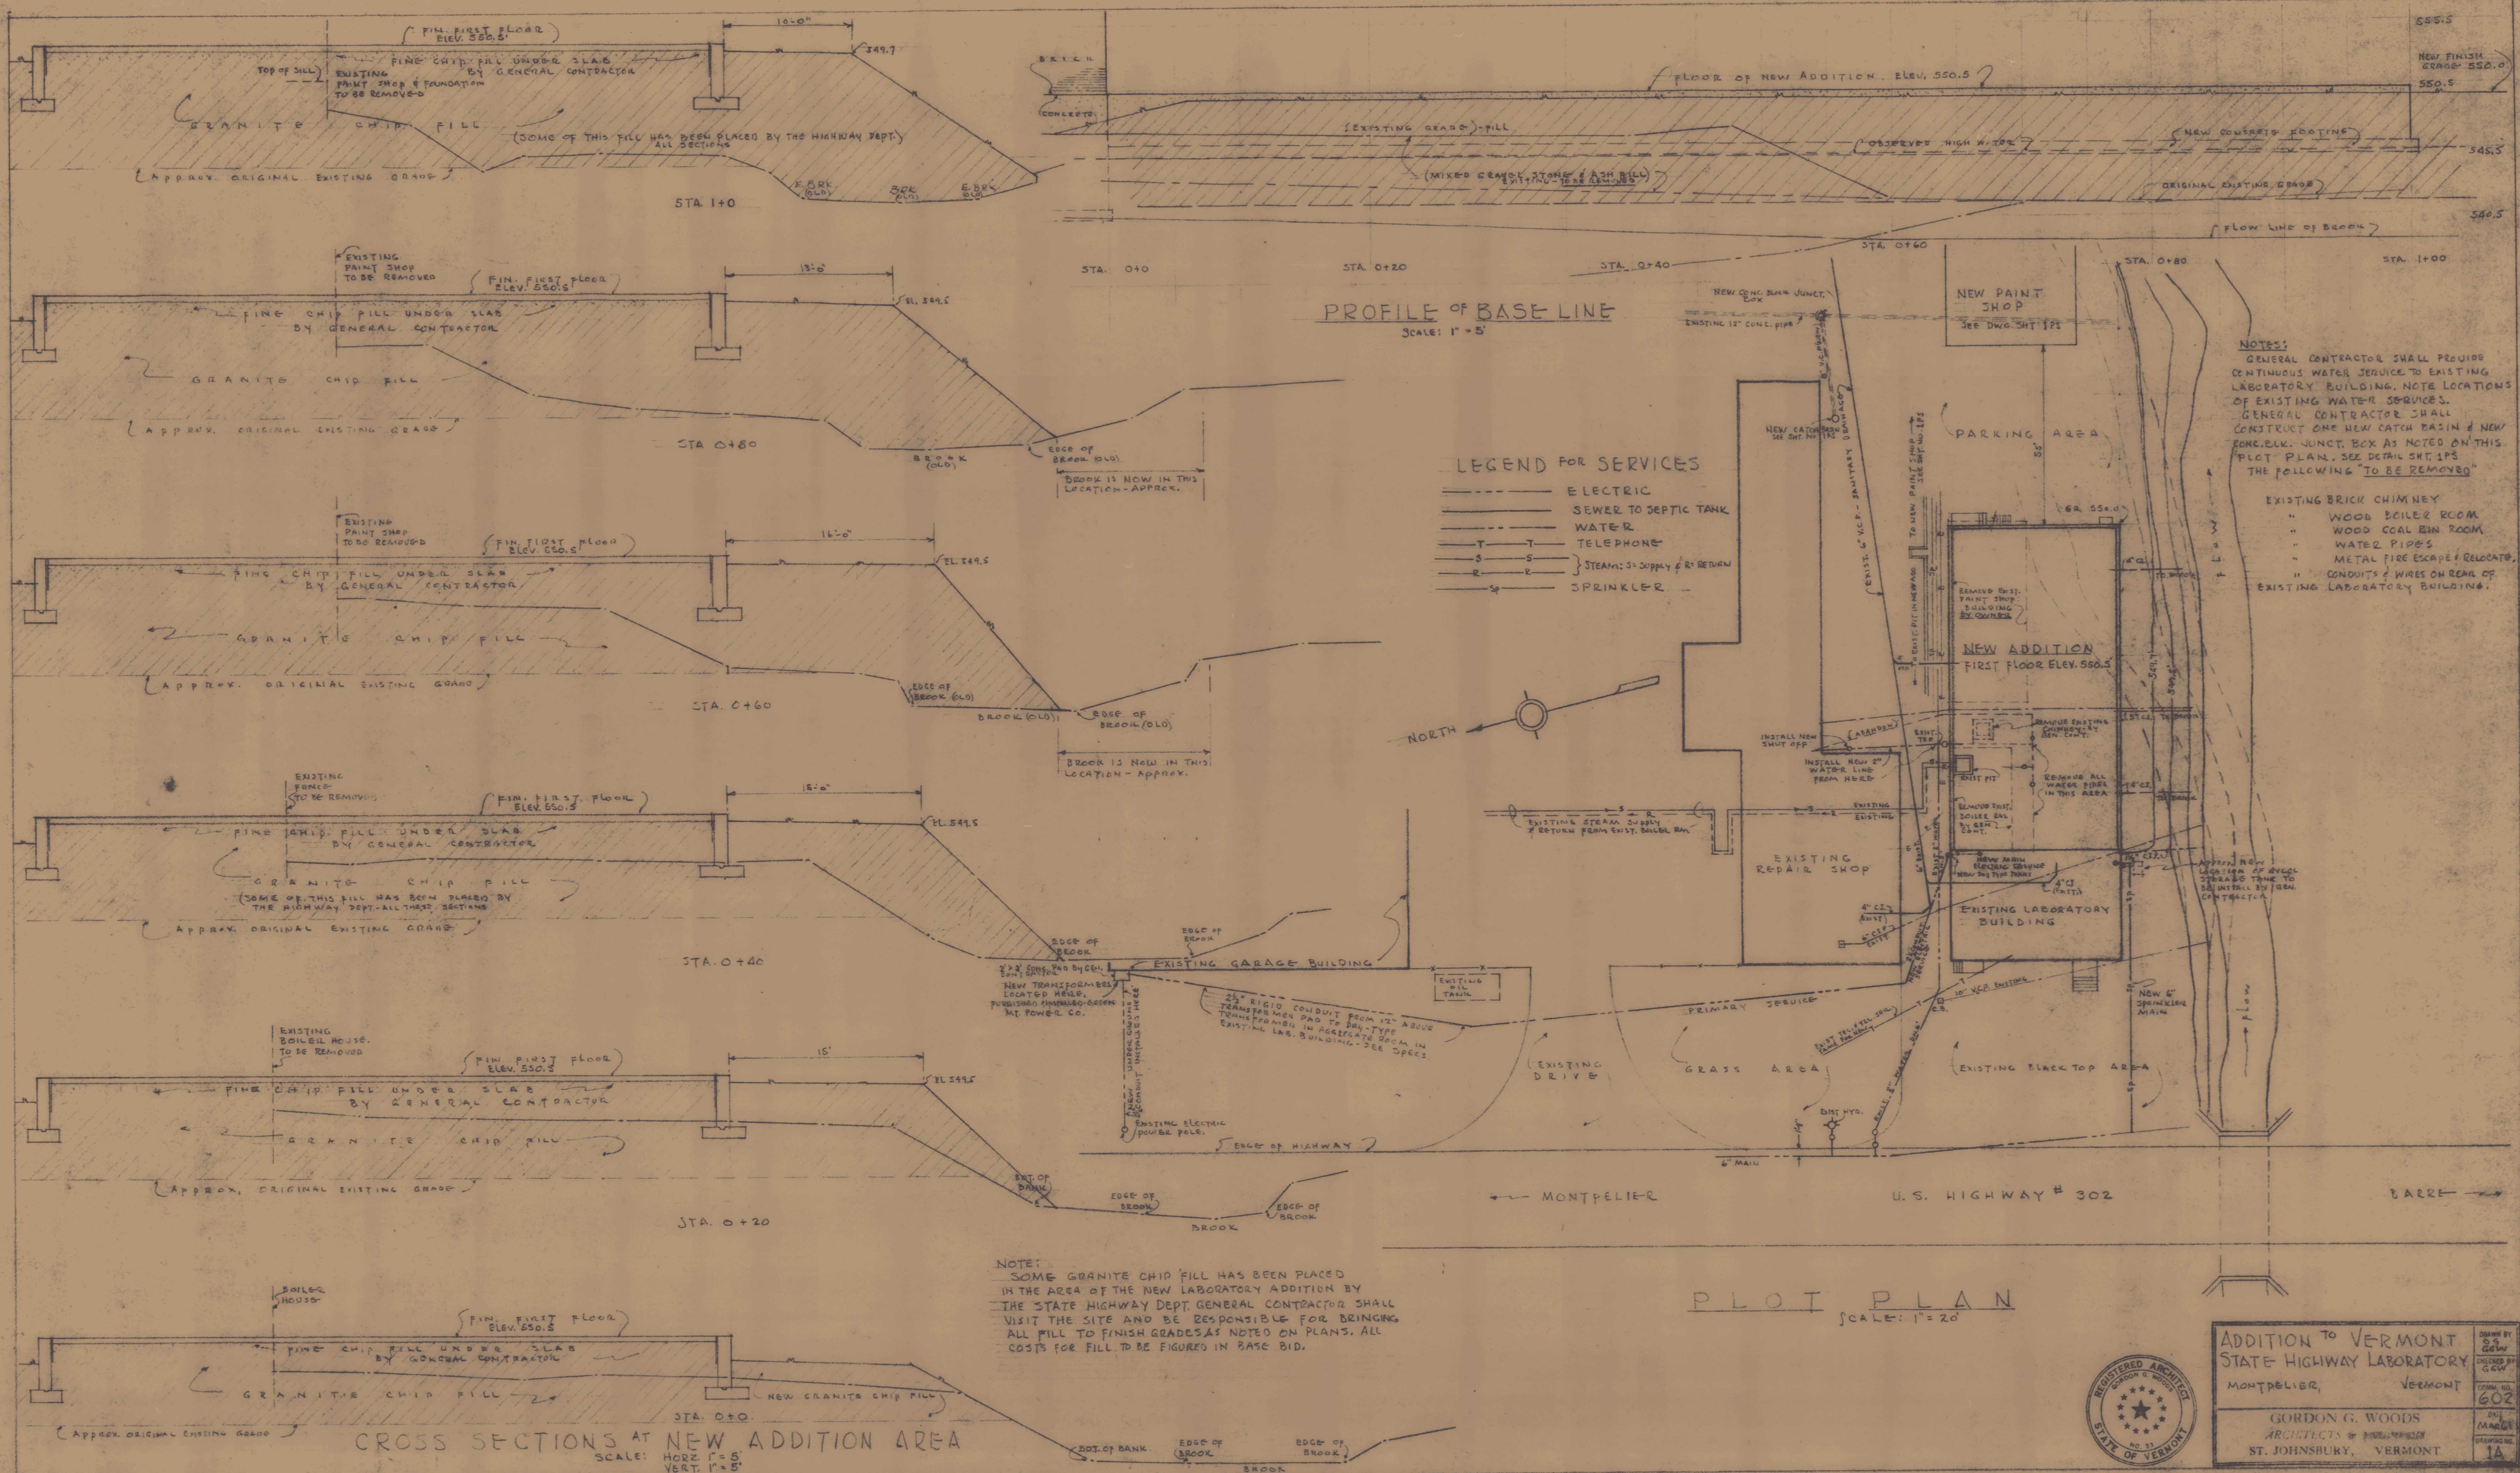


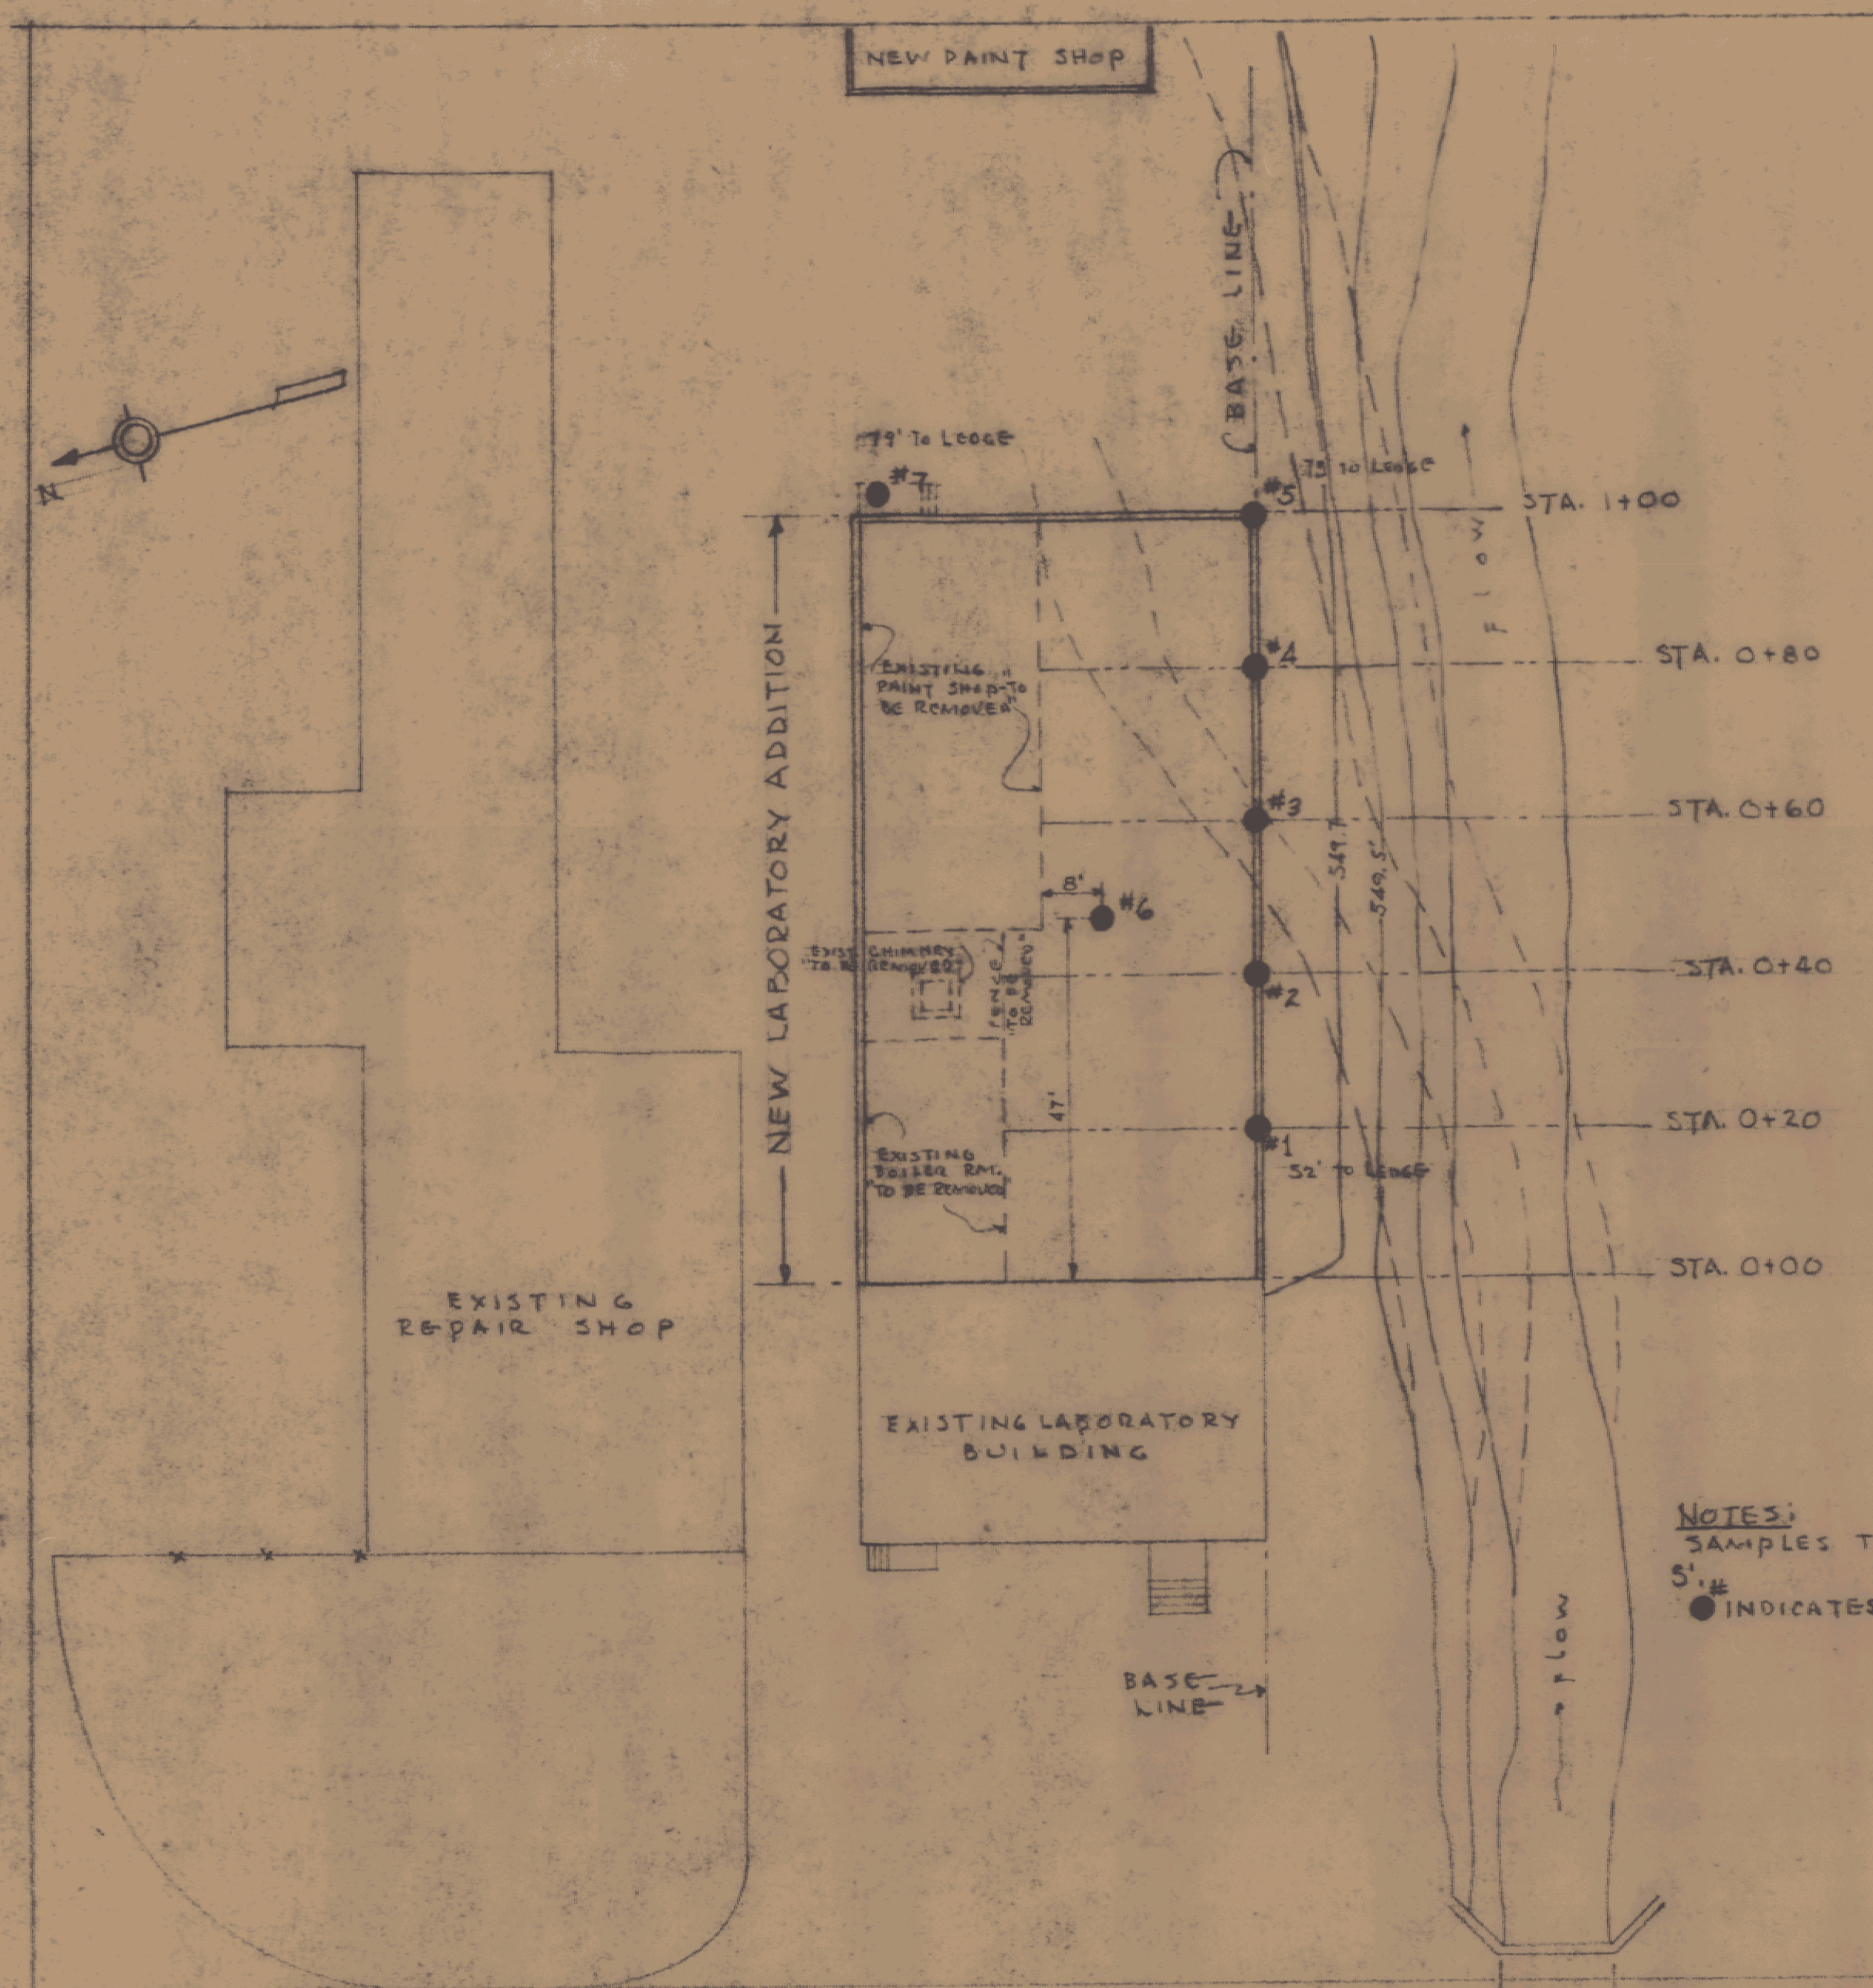

U.S. HIGHWAY # 302
PLOT PLAN FOR CROSS SECTION & SOIL TEST BORINGS
 SCALE: 1" = 20'

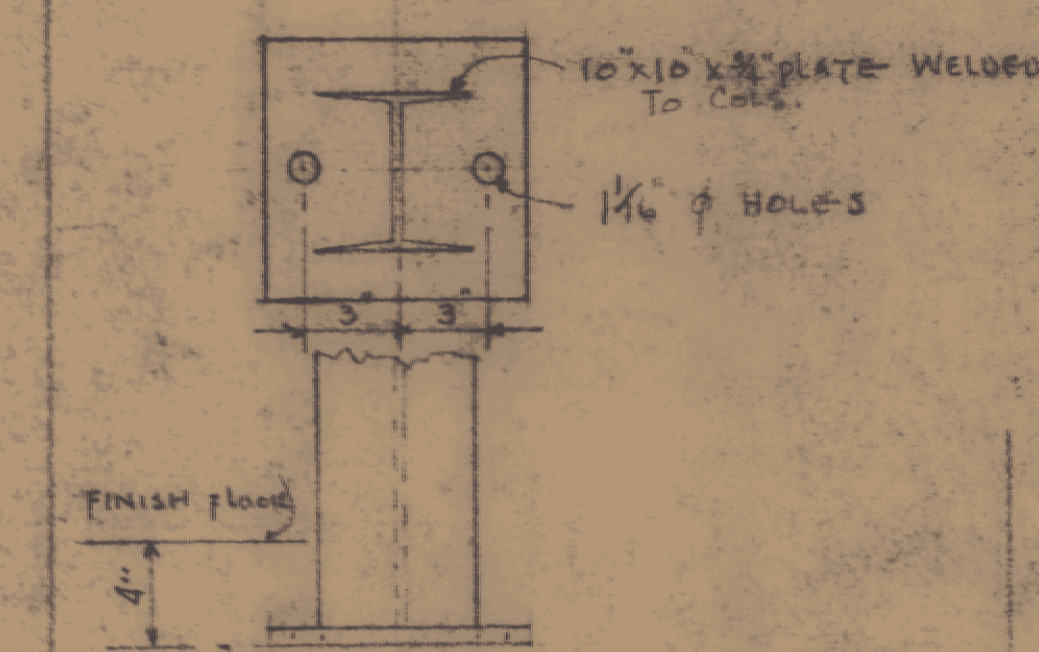


COL. BASE DETAIL
 SCALE: 1/2" = 1'-0"

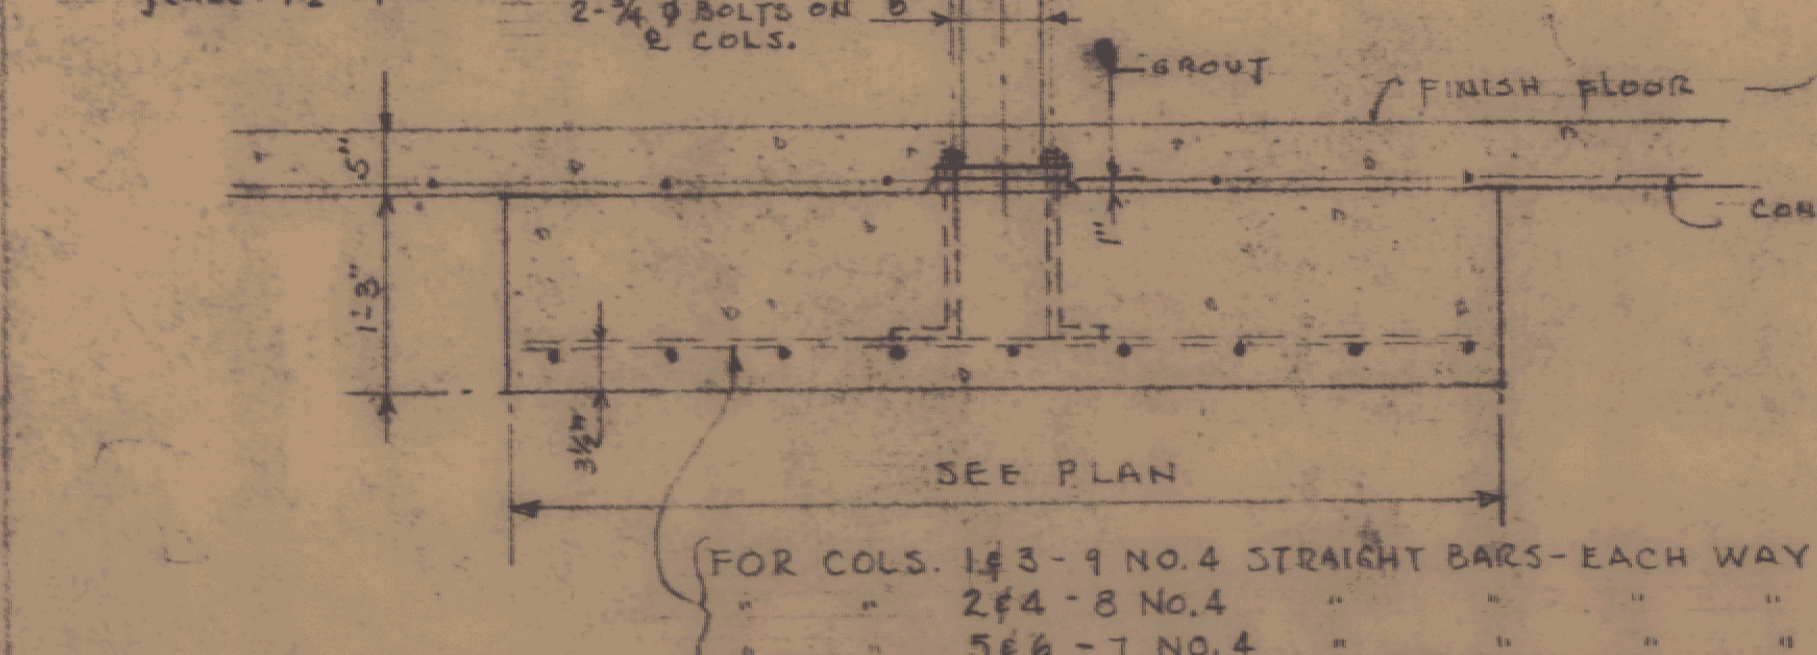


DETAIL OF COLUMN FOOTINGS
 SCALE: 3/4" = 1'-0"

TYPICAL SECTION THRU EXTERIOR WALL
 SCALE: 3/4" = 1'-0"

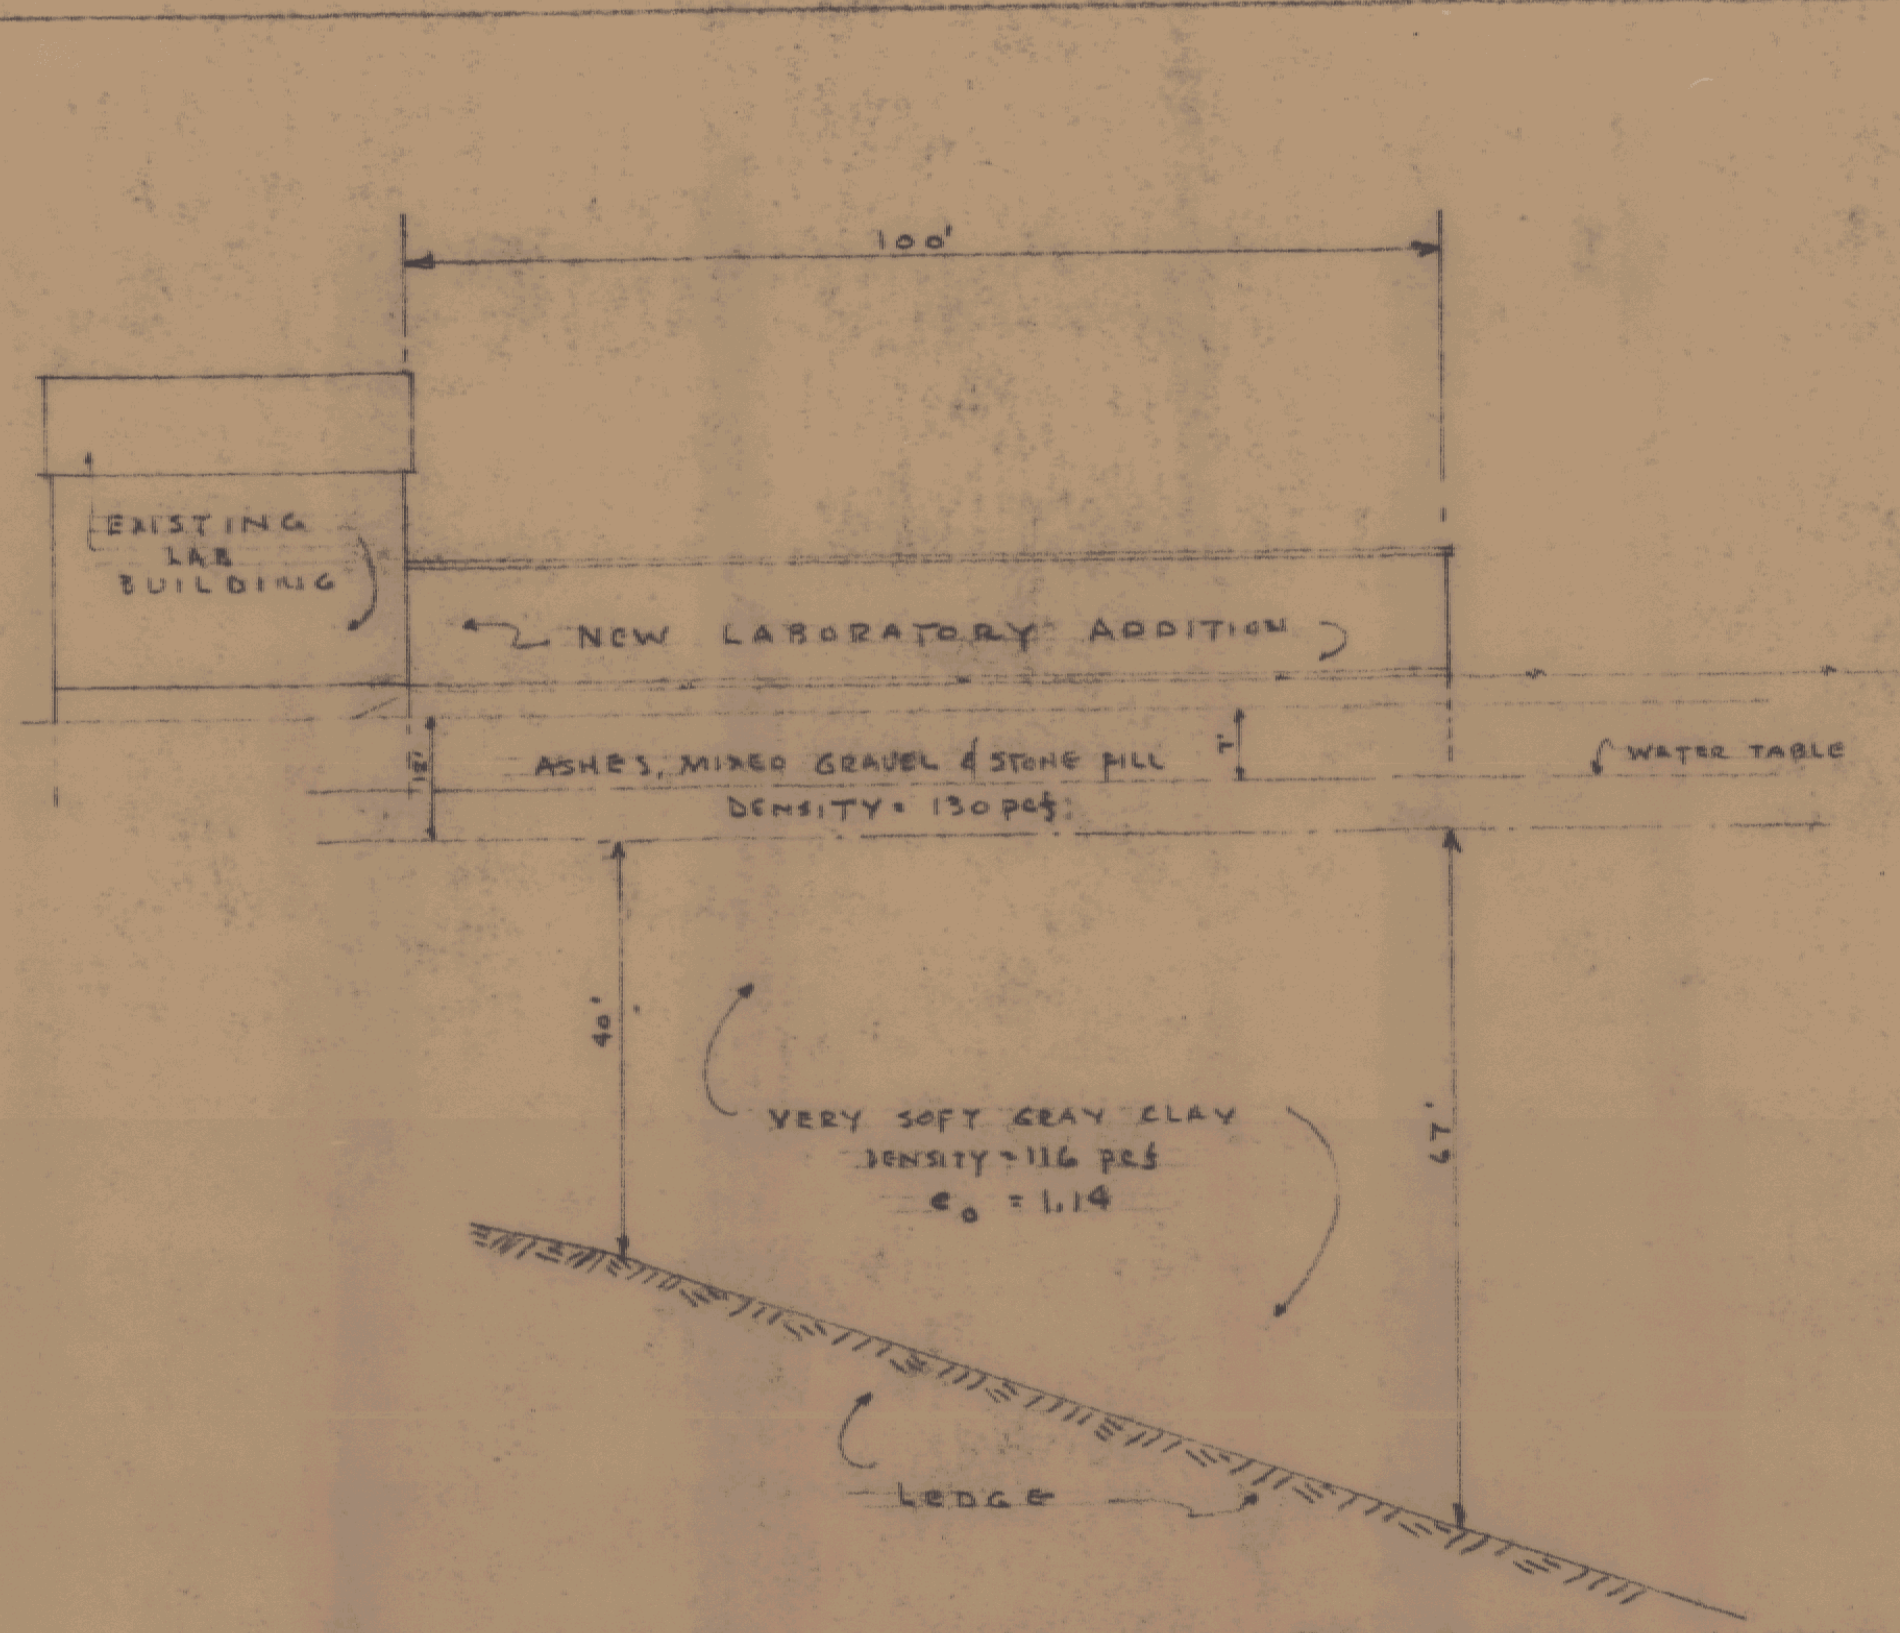


CROSS SECTION THRU BASE LINE
 SCALE: 1" = 20'

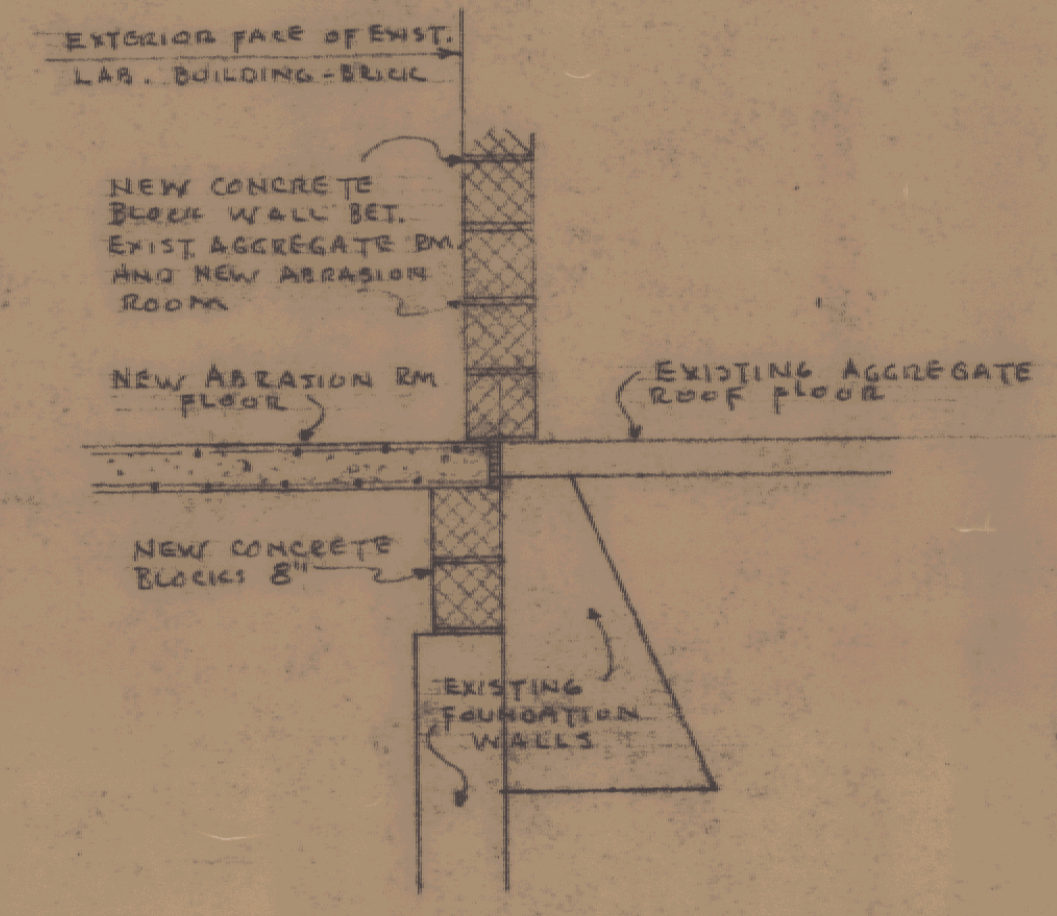

SECTION "Y-Y" THRU NEW AND OLD FLOORS
 SCALE: 1/2" = 1'-0"


- LEGEND**
- CONCRETE
 - CONCRETE BLOCKS
 - BRICK IN PLAN
 - EXISTING WALLS

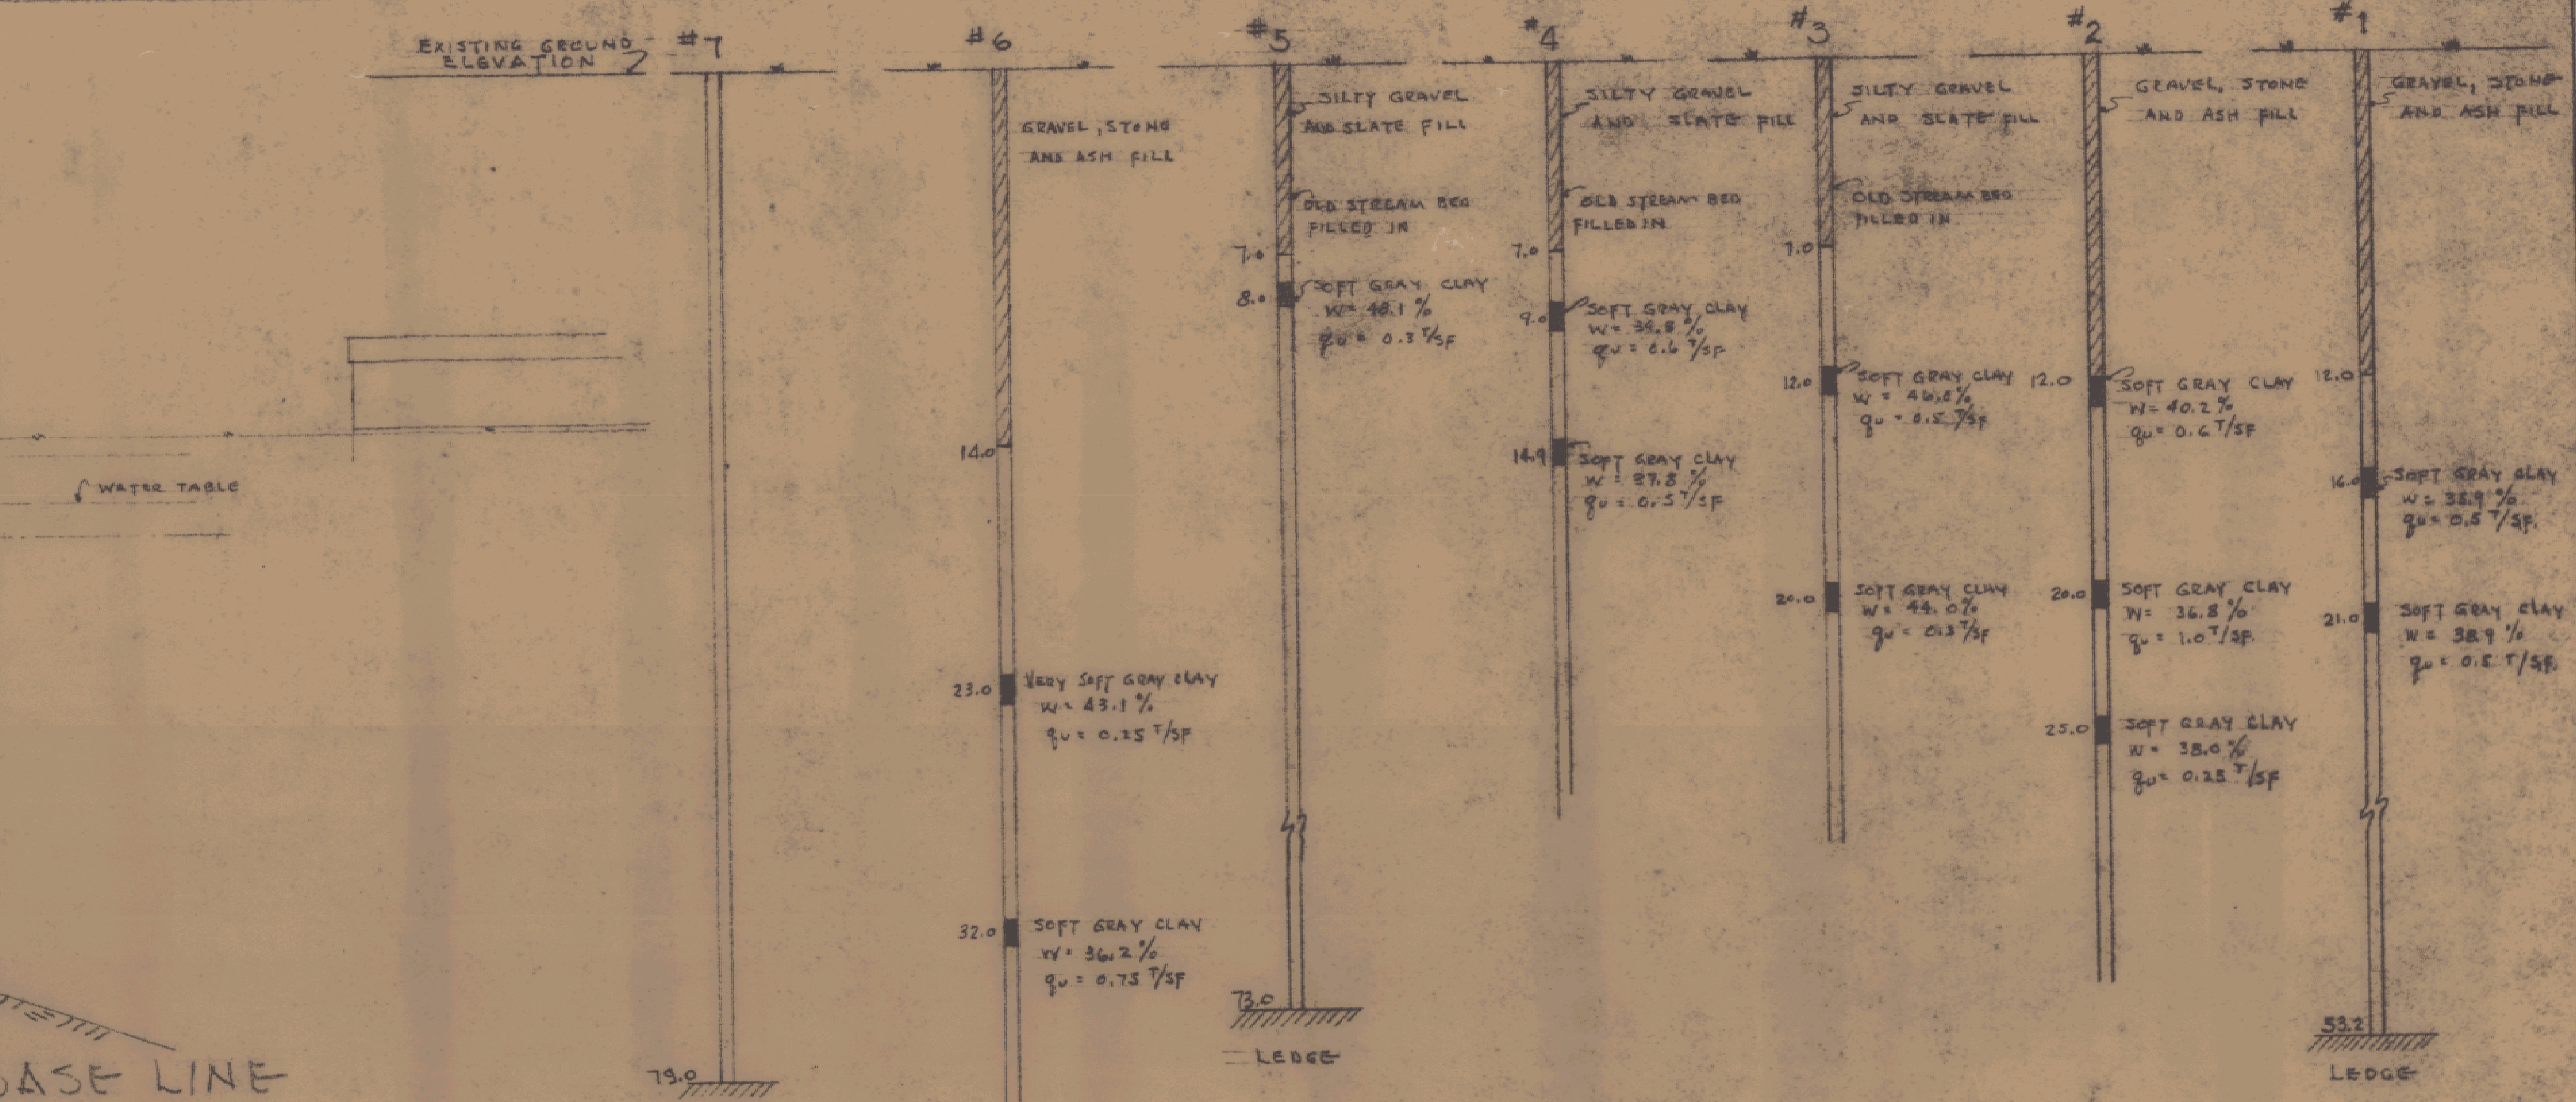

SOIL TEST BORING DATA
 SCALE: 1" = 5'


NOTE: FOUNDATIONS BASED ON AN ALLOWABLE SOIL PRESSURE OF 1000#/SF FOR DEAD LOADS ONLY 1200#/SF FOR DEAD LOAD PLUS LIVE (ROOF)

DETAIL OF PLATFORM WALL & FTG.
 SCALE: 1/2" = 1'-0"

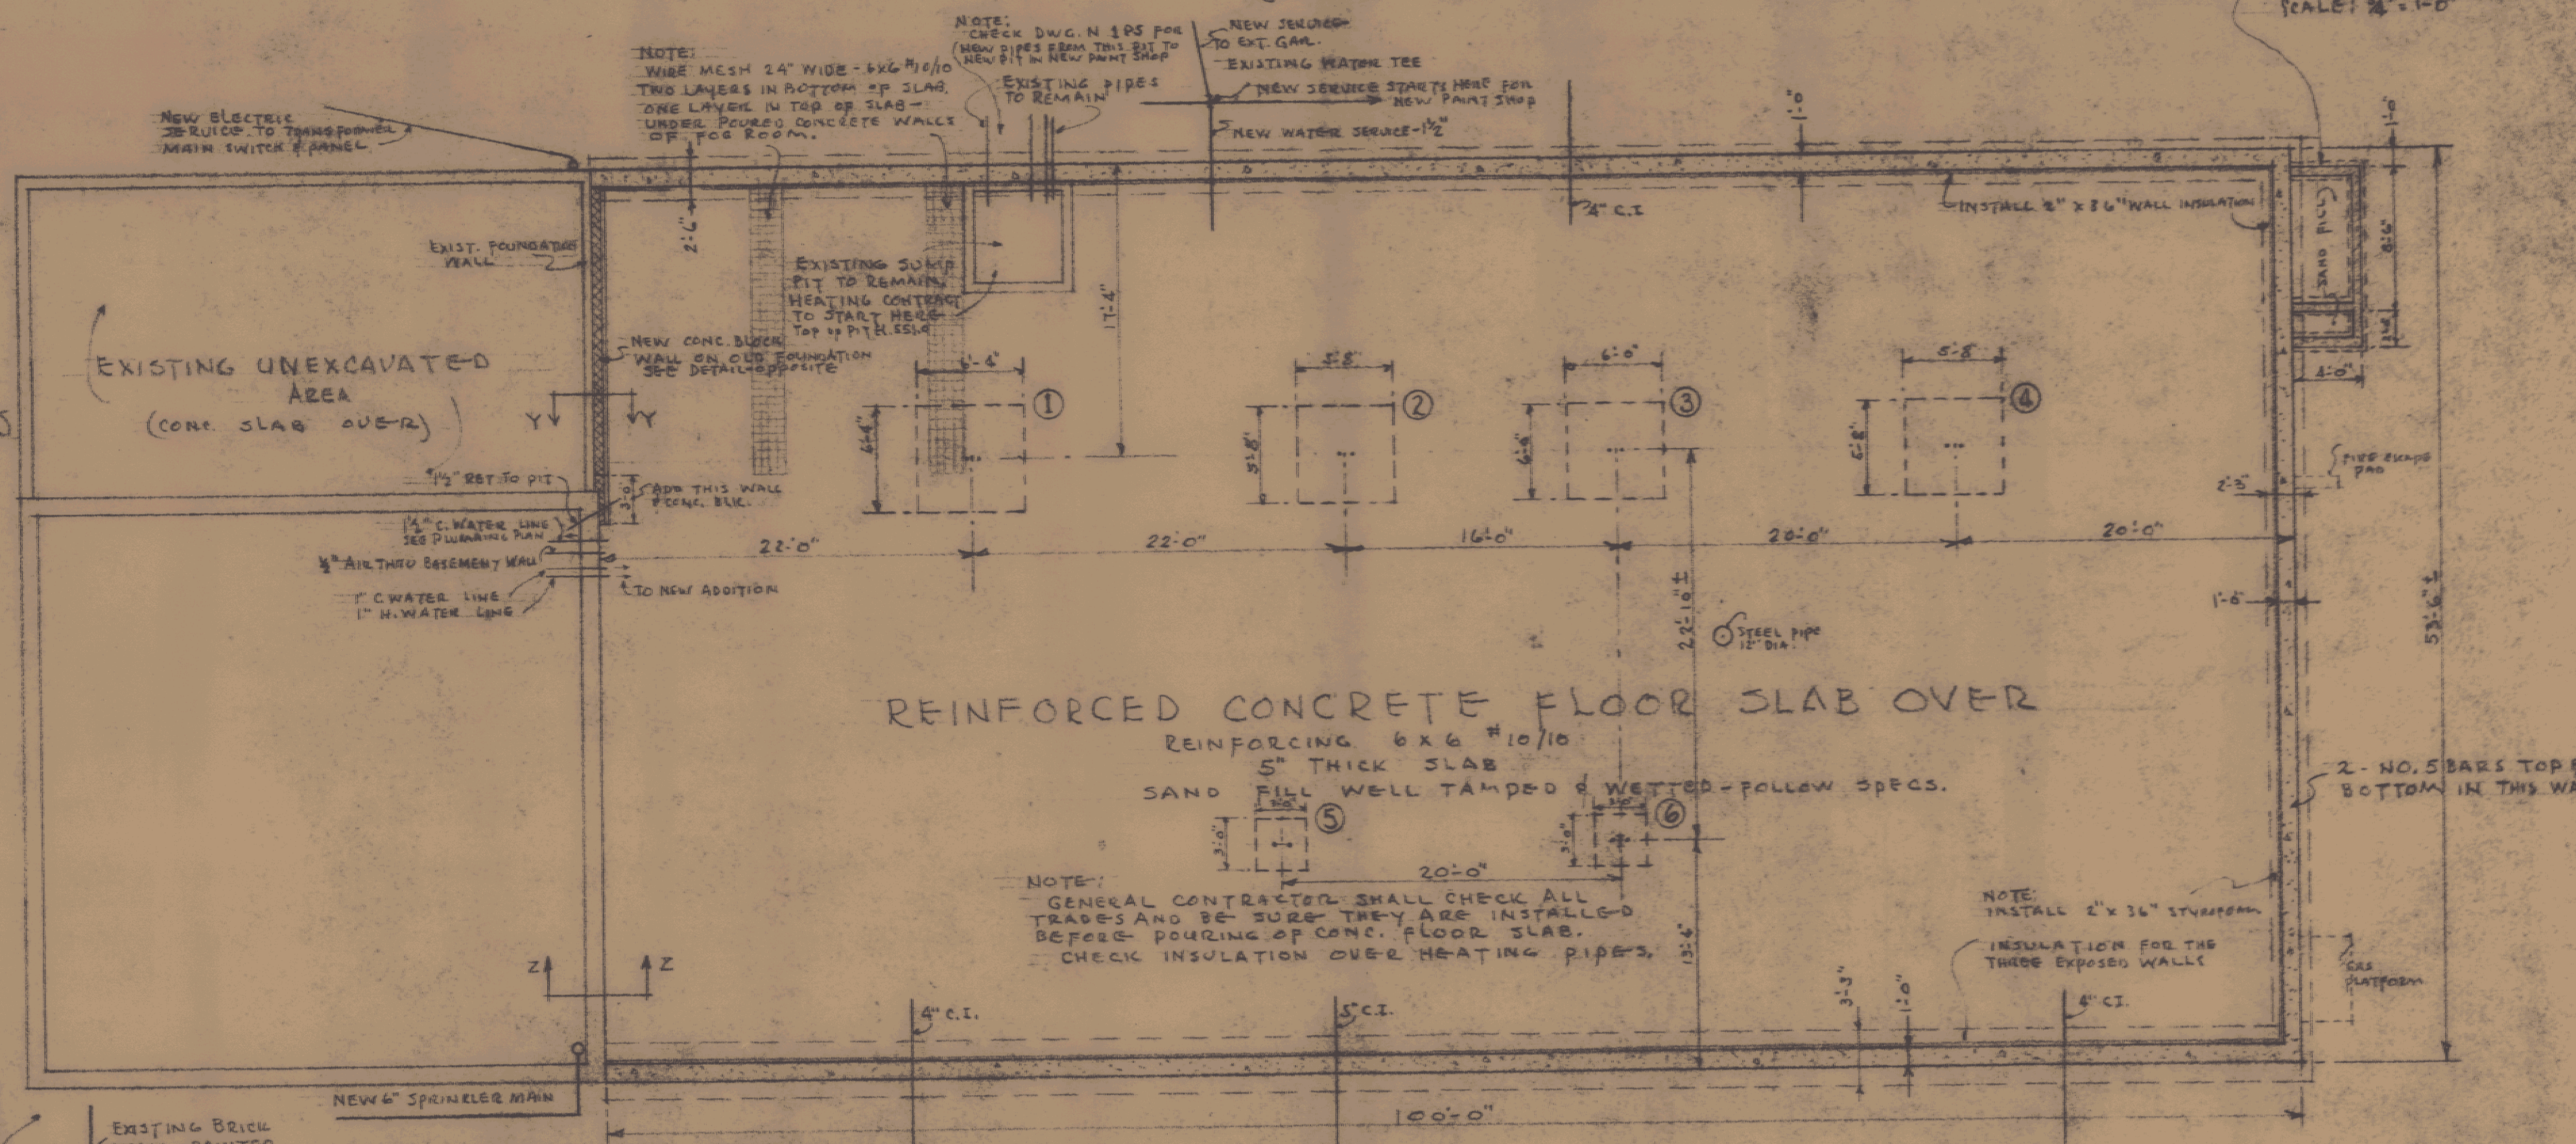

FOUNDATION PLAN
 SCALE: 1/2" = 1'-0"


SECTION Z-Z
 SCALE: 3/4" = 1'-0"

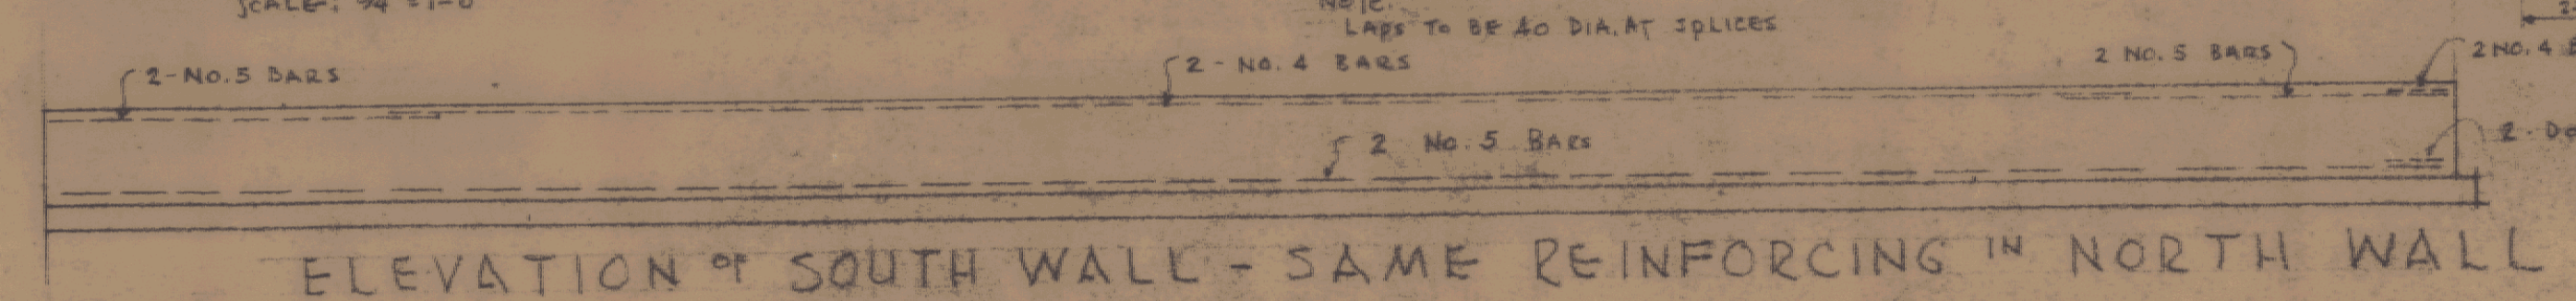

ELEVATION OF SOUTH WALL - SAME REINFORCING IN NORTH WALL



ADDITION TO VERMONT STATE HIGHWAY LABORATORY
 MONTPELIER, VERMONT
 GORDON G. WOODS
 ARCHITECTS
 ST. JOHNSBURY, VERMONT
 DATE: MAR. 61
 DRAWING NO. 602








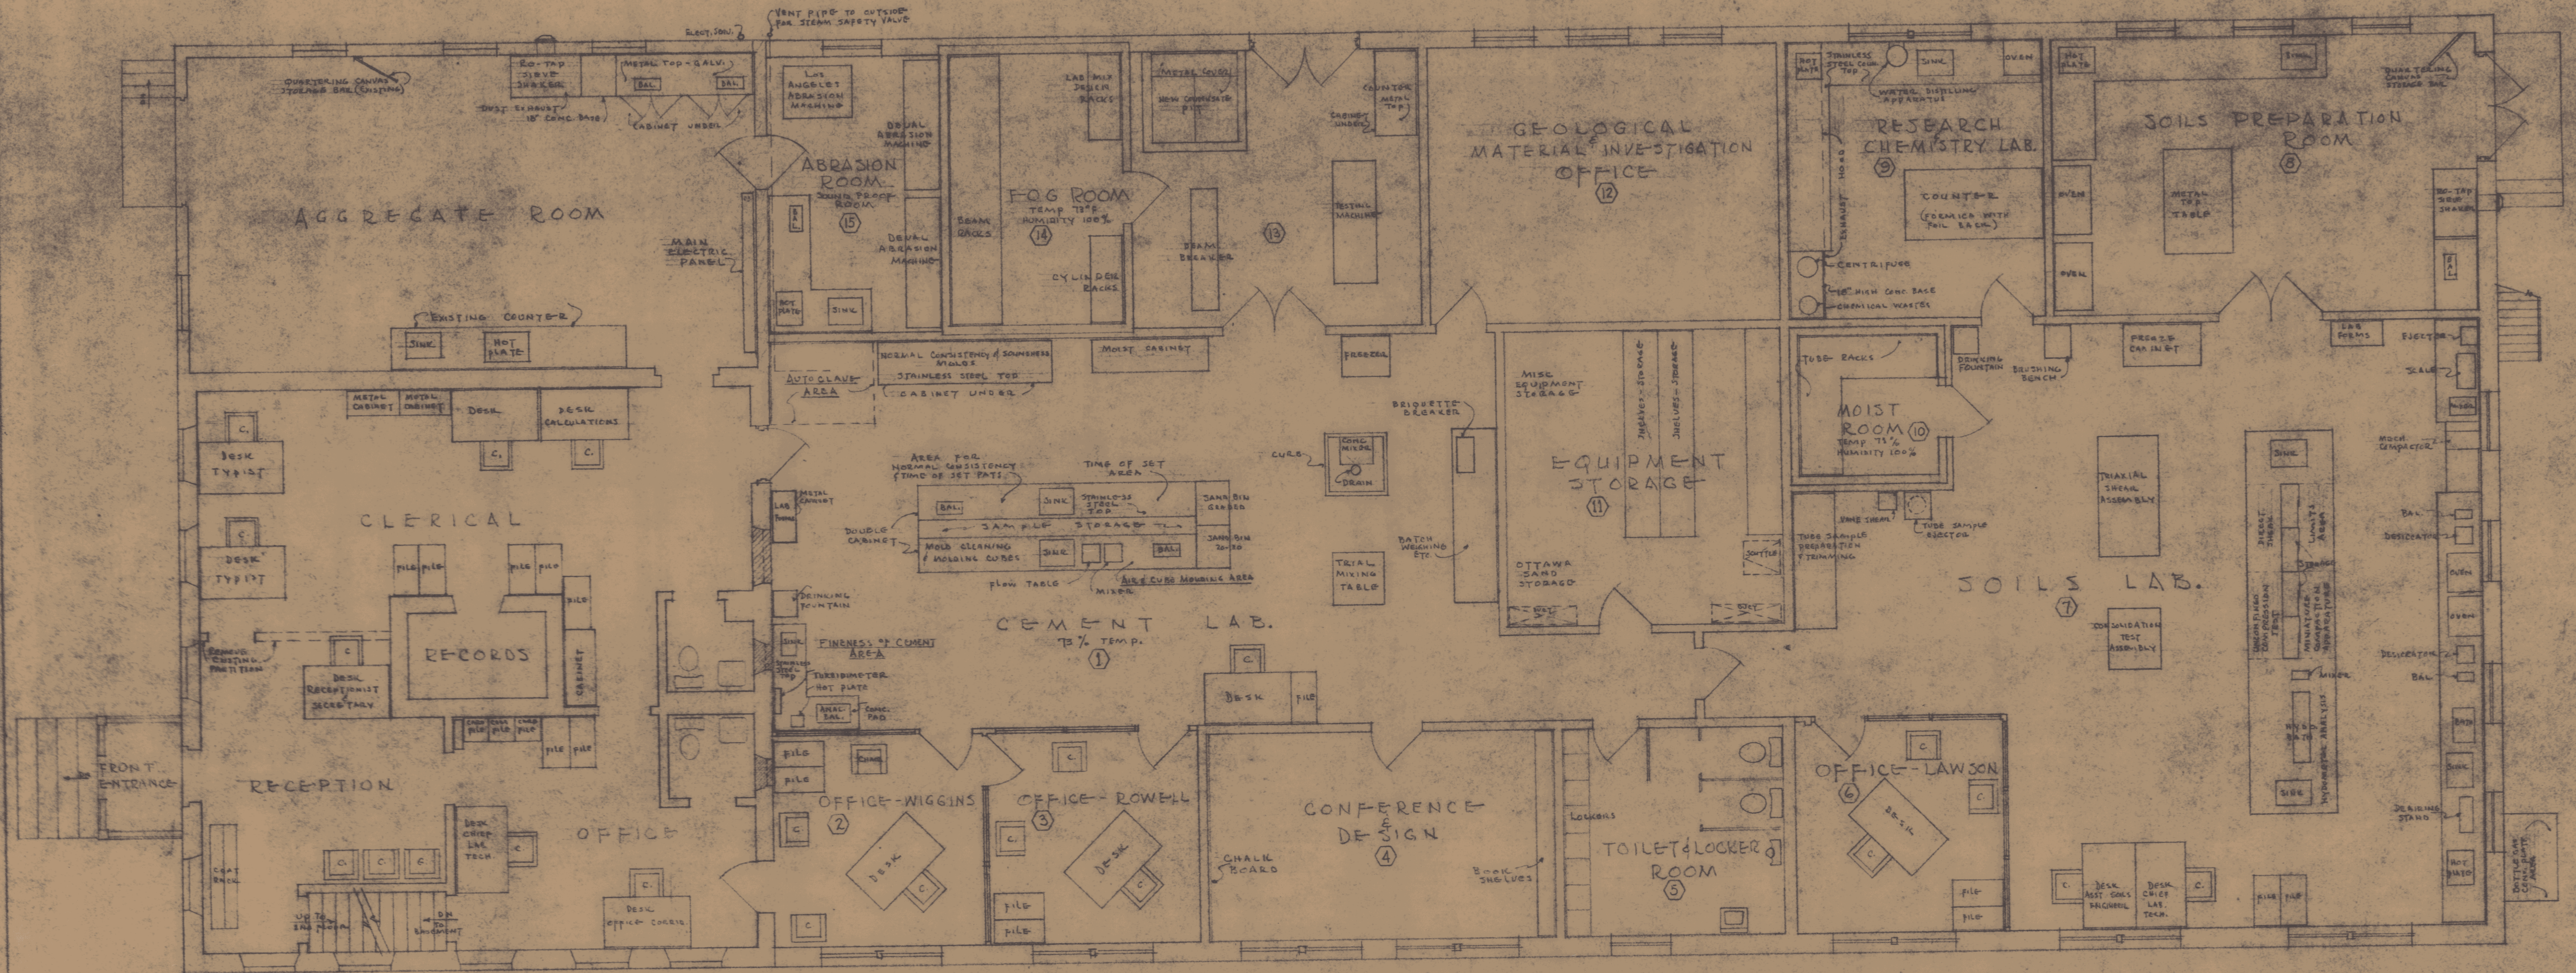
























MASTER FIRST FLOOR PLAN
SCALE: 1/4" = 1'-0"

NOTE:
THIS PLAN SHOWS THE CONTRACTORS THE LOCATION (APPROX) OF ALL THE EQUIPMENT AND APPARATUS USED IN THE NEW LABORATORY ADDITION.





ADDITION TO VERMONT
STATE HIGHWAY LABORATORY
MONTPELIER, VERMONT
GORDON G. WOODS
ARCHITECTS
ST. JOHNSBURY, VERMONT

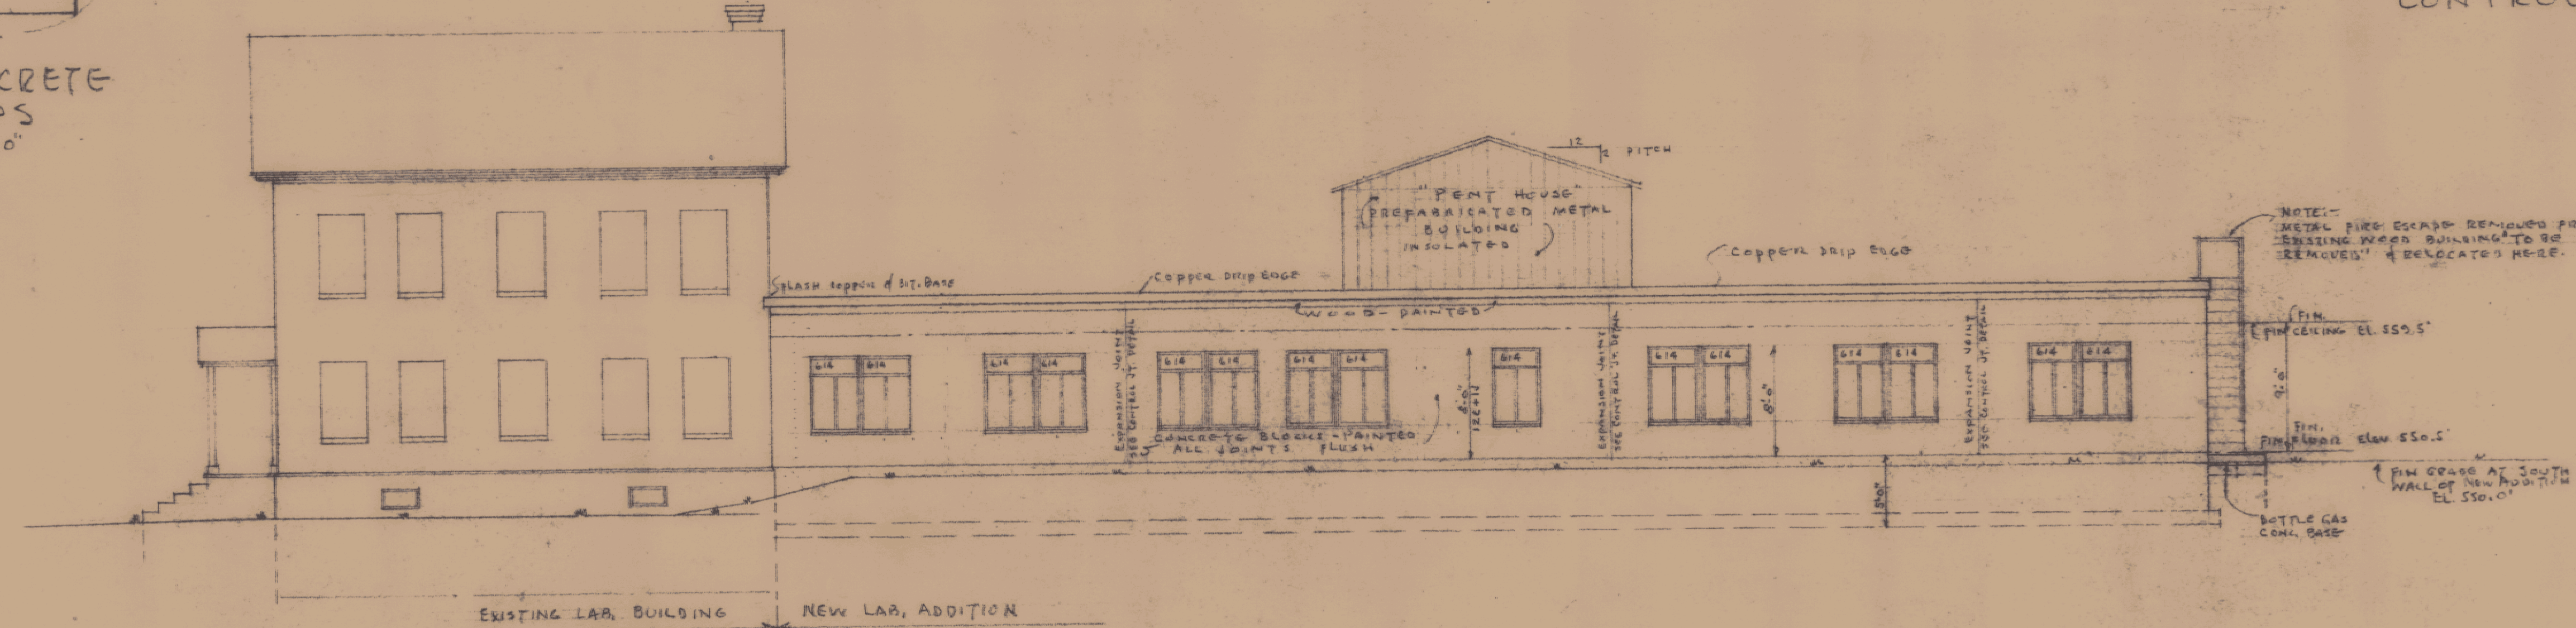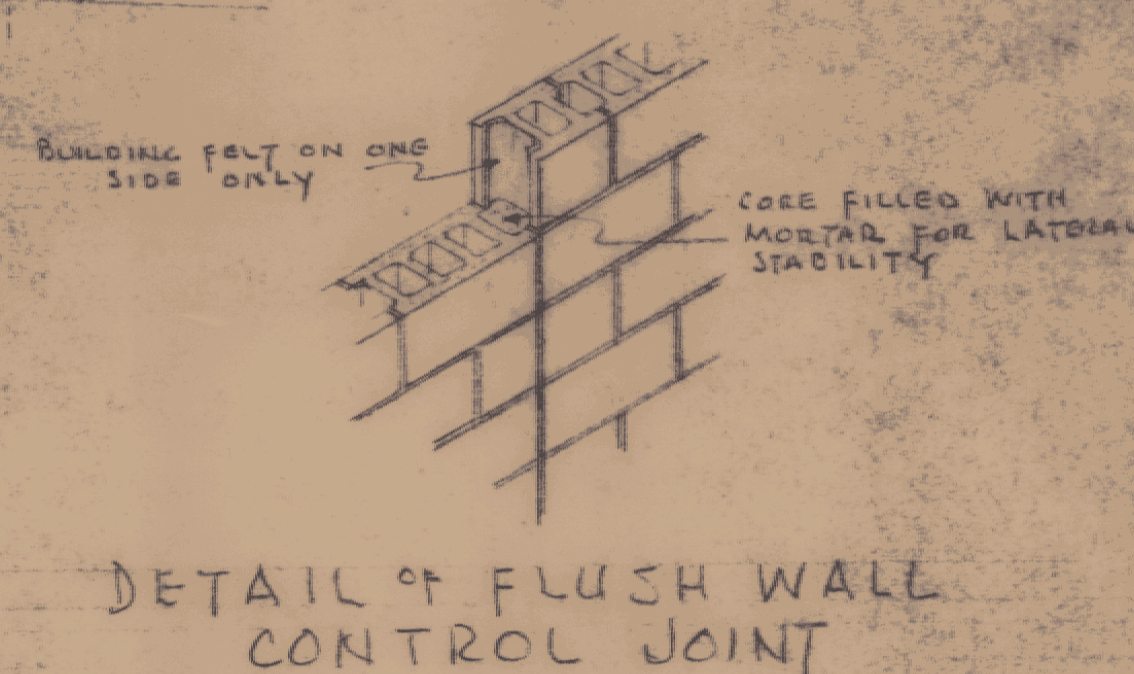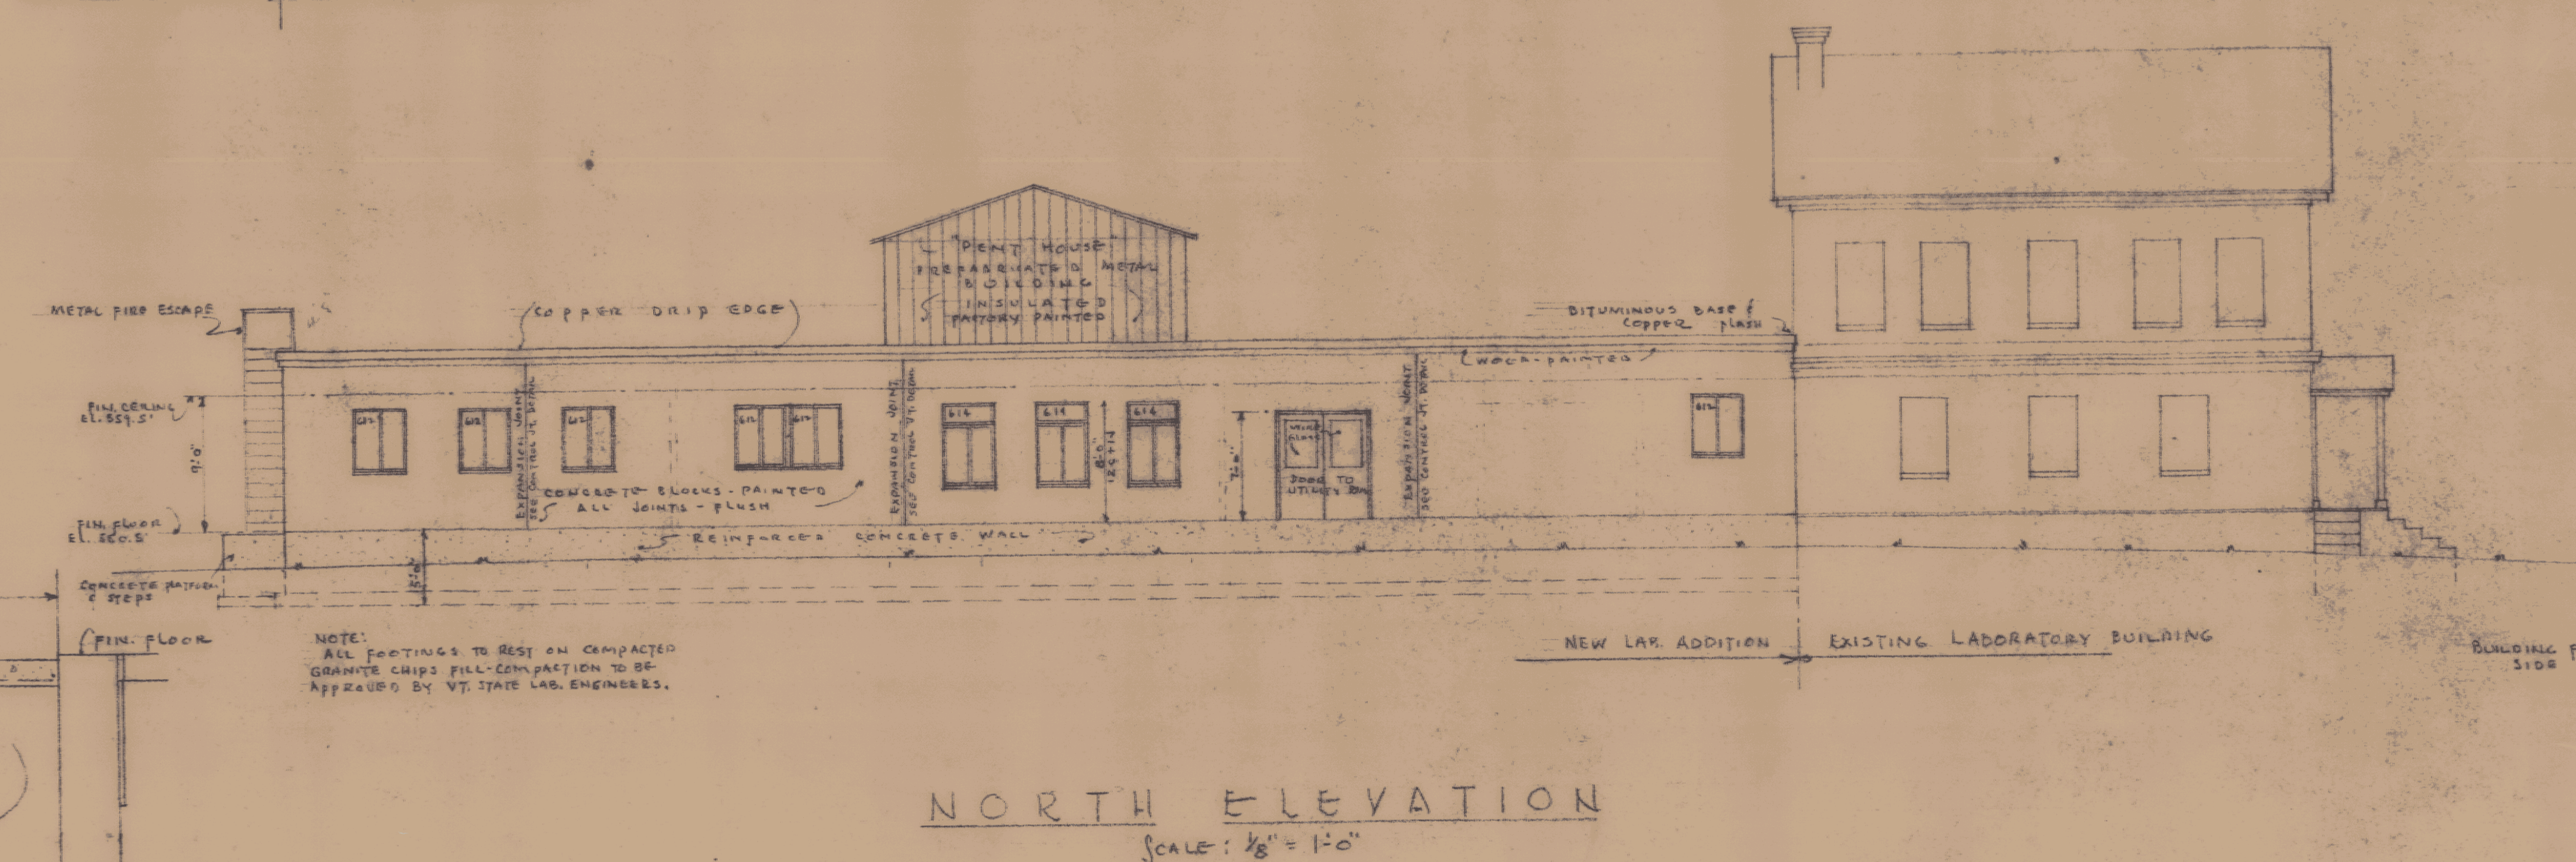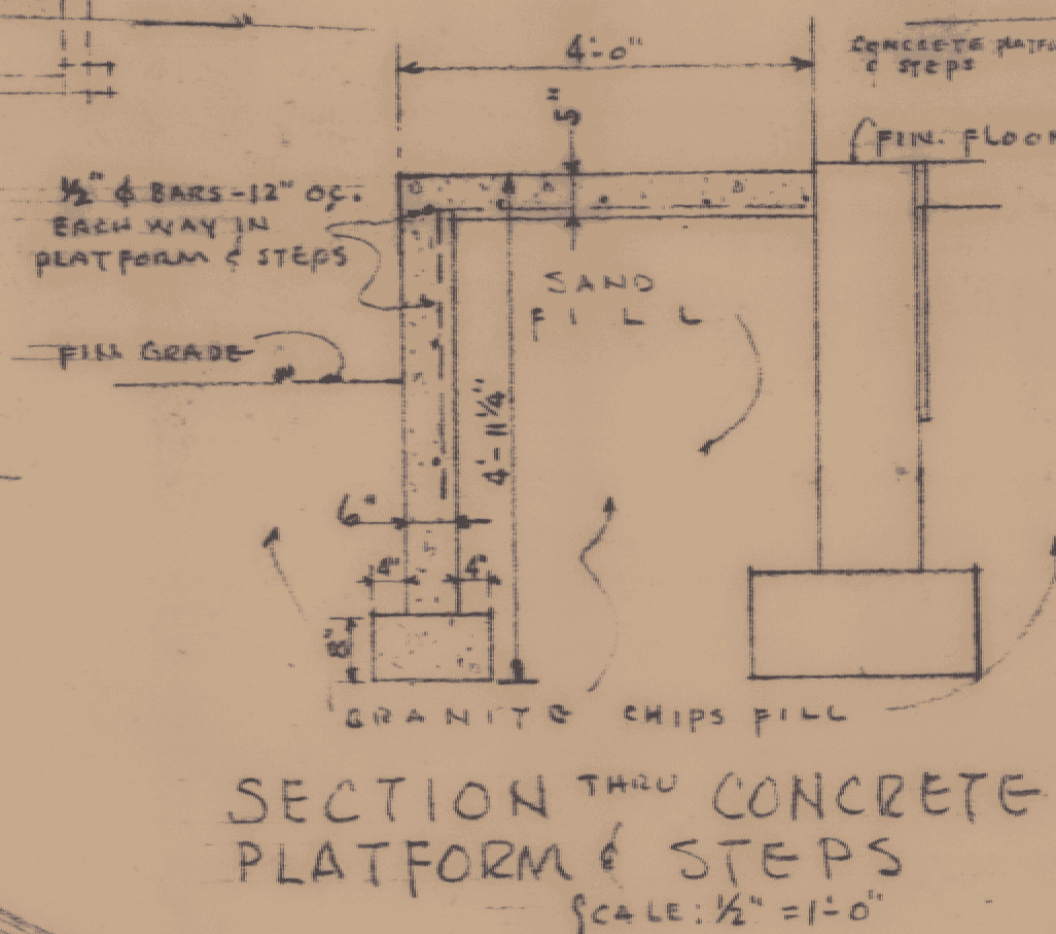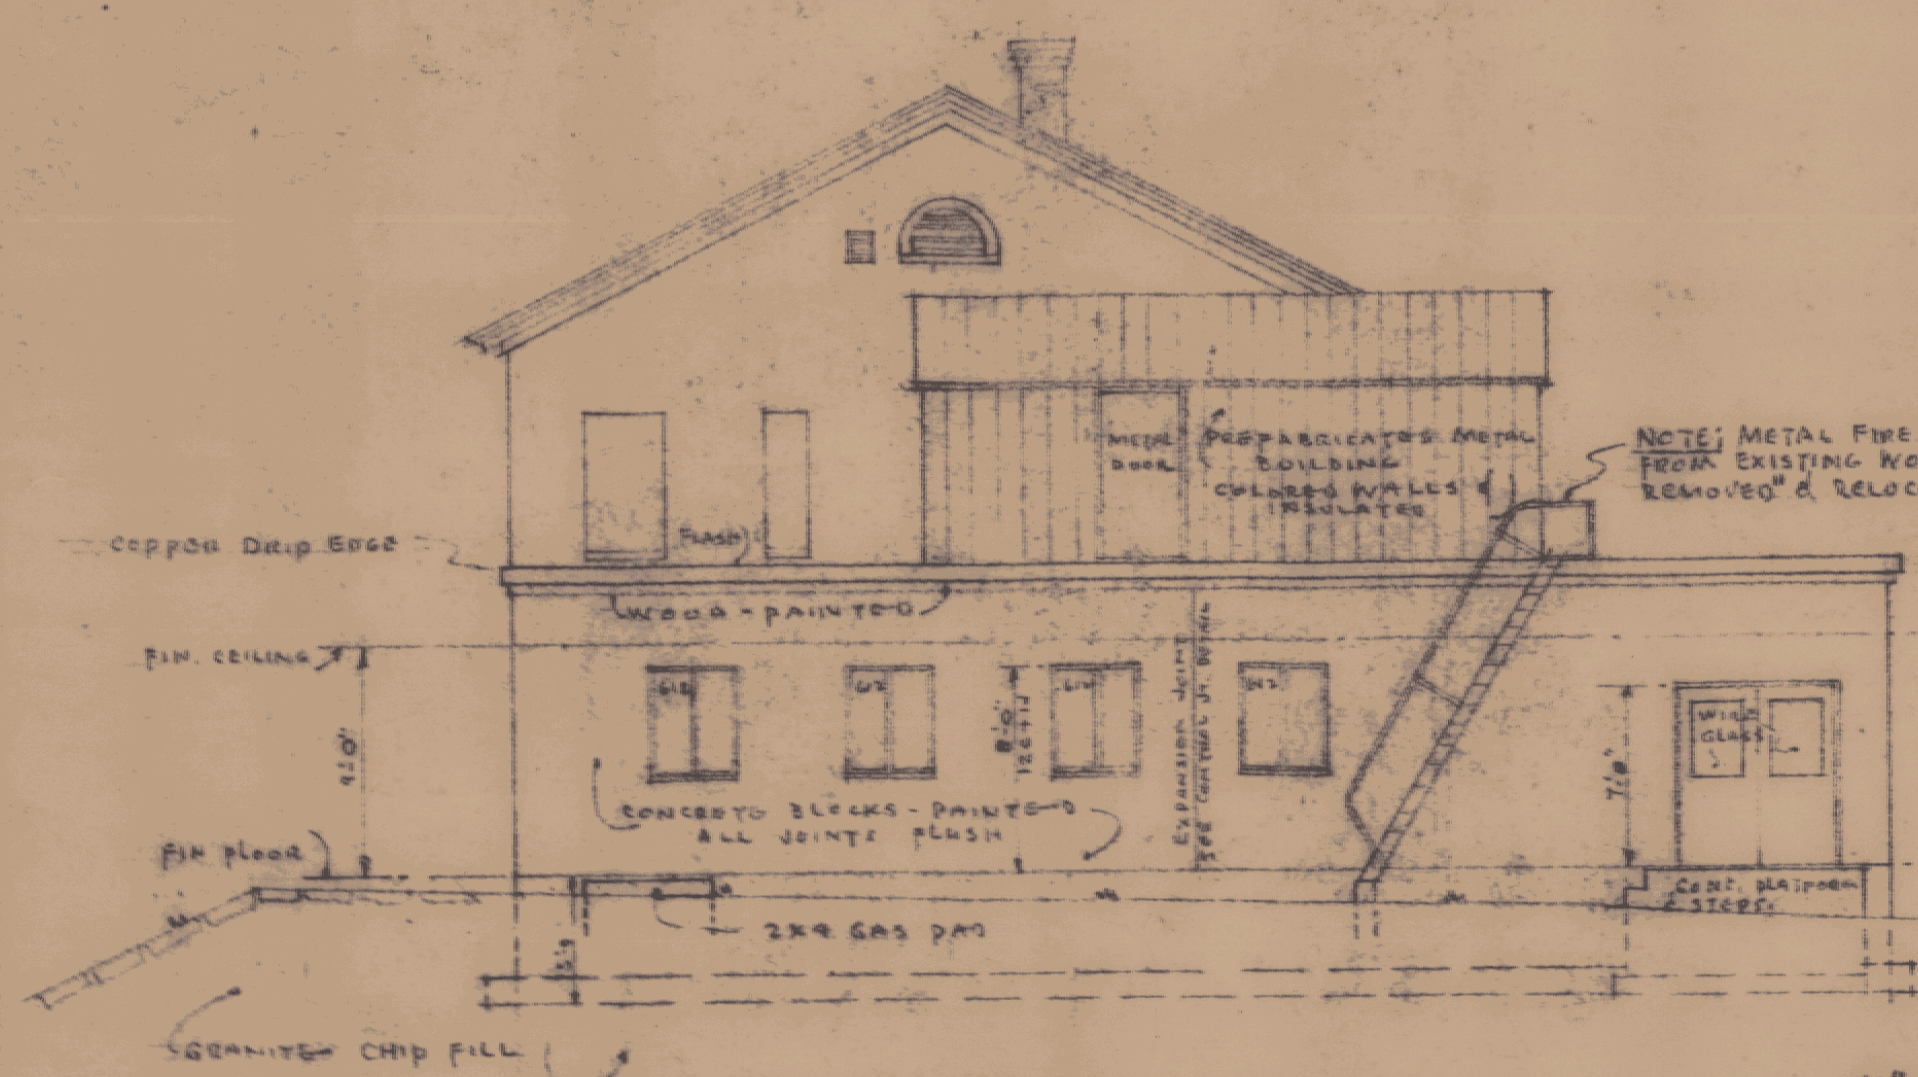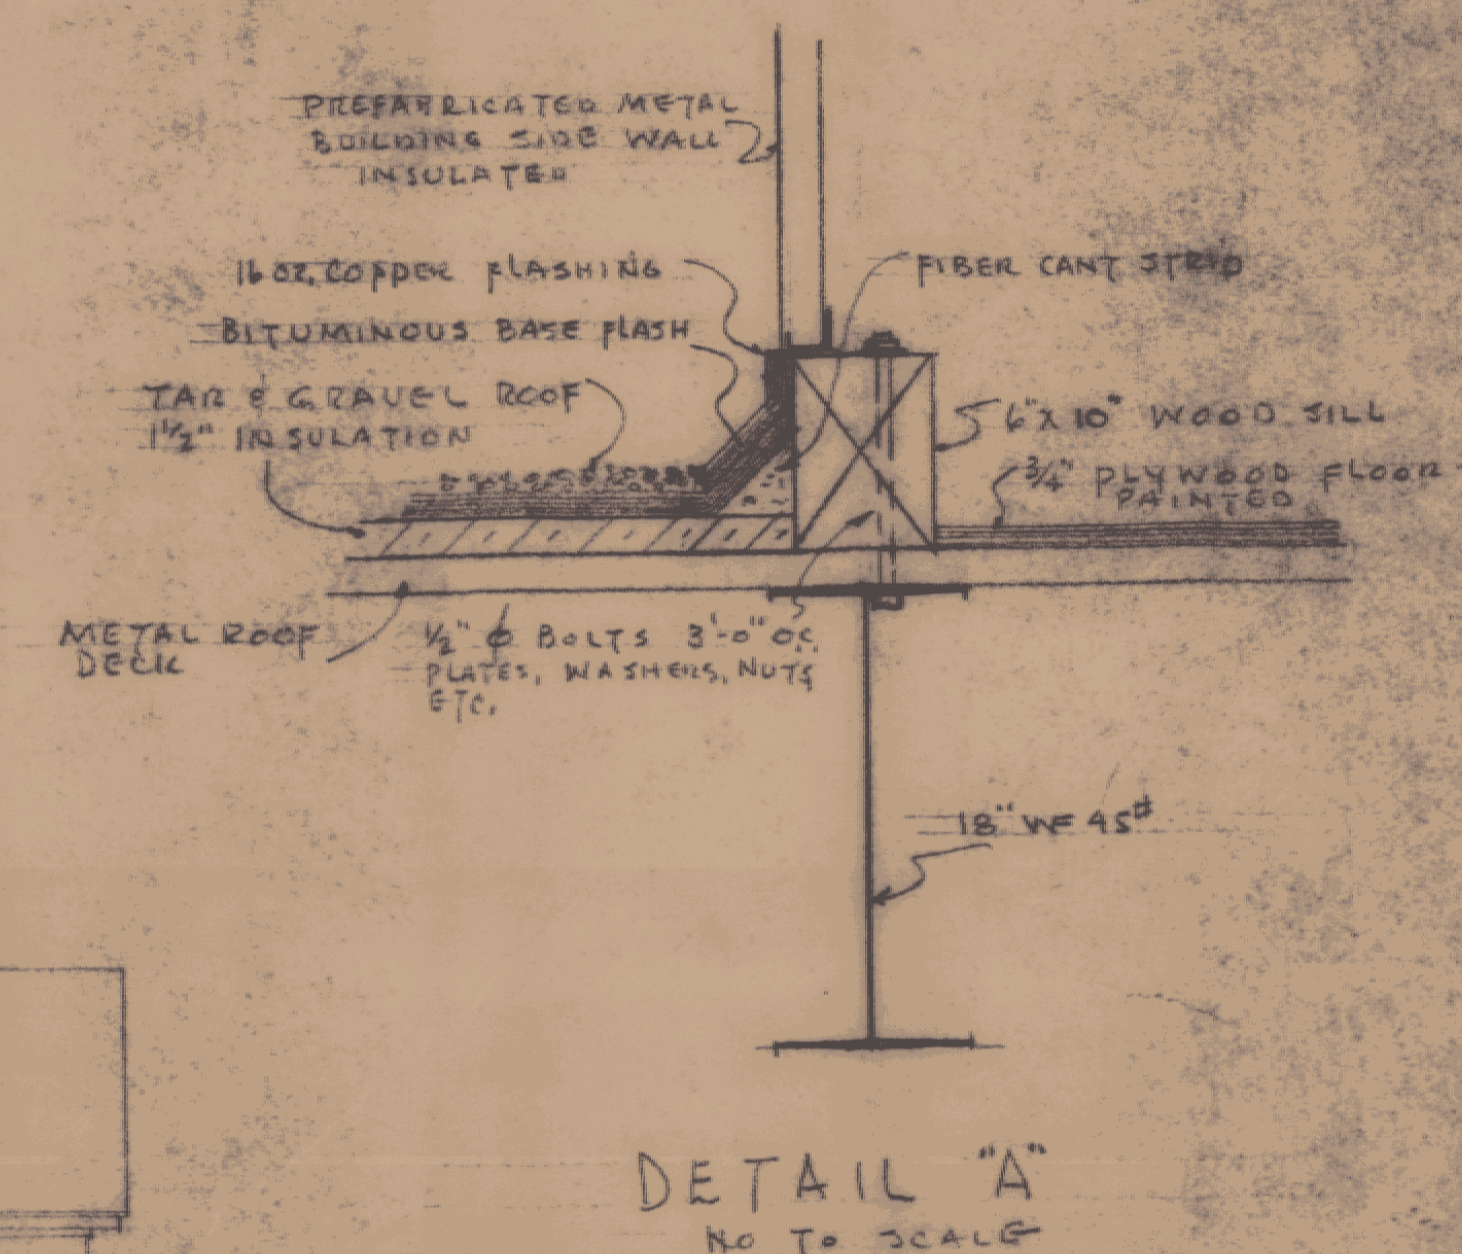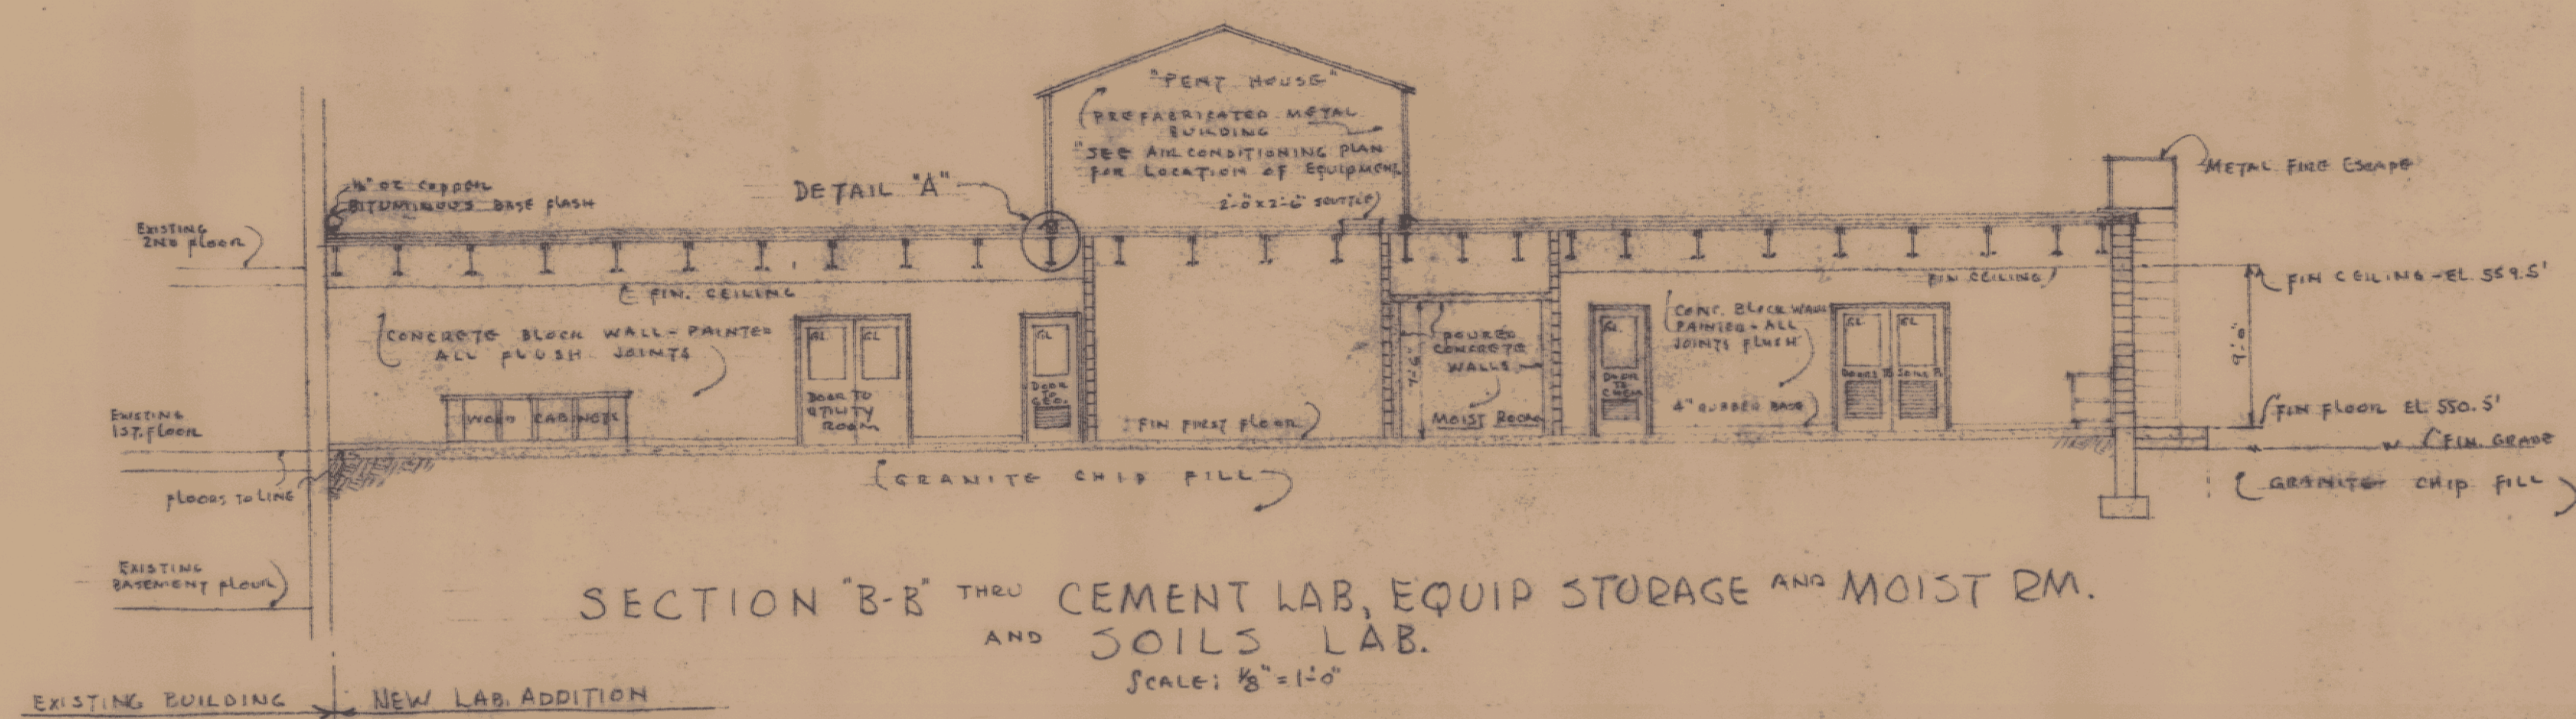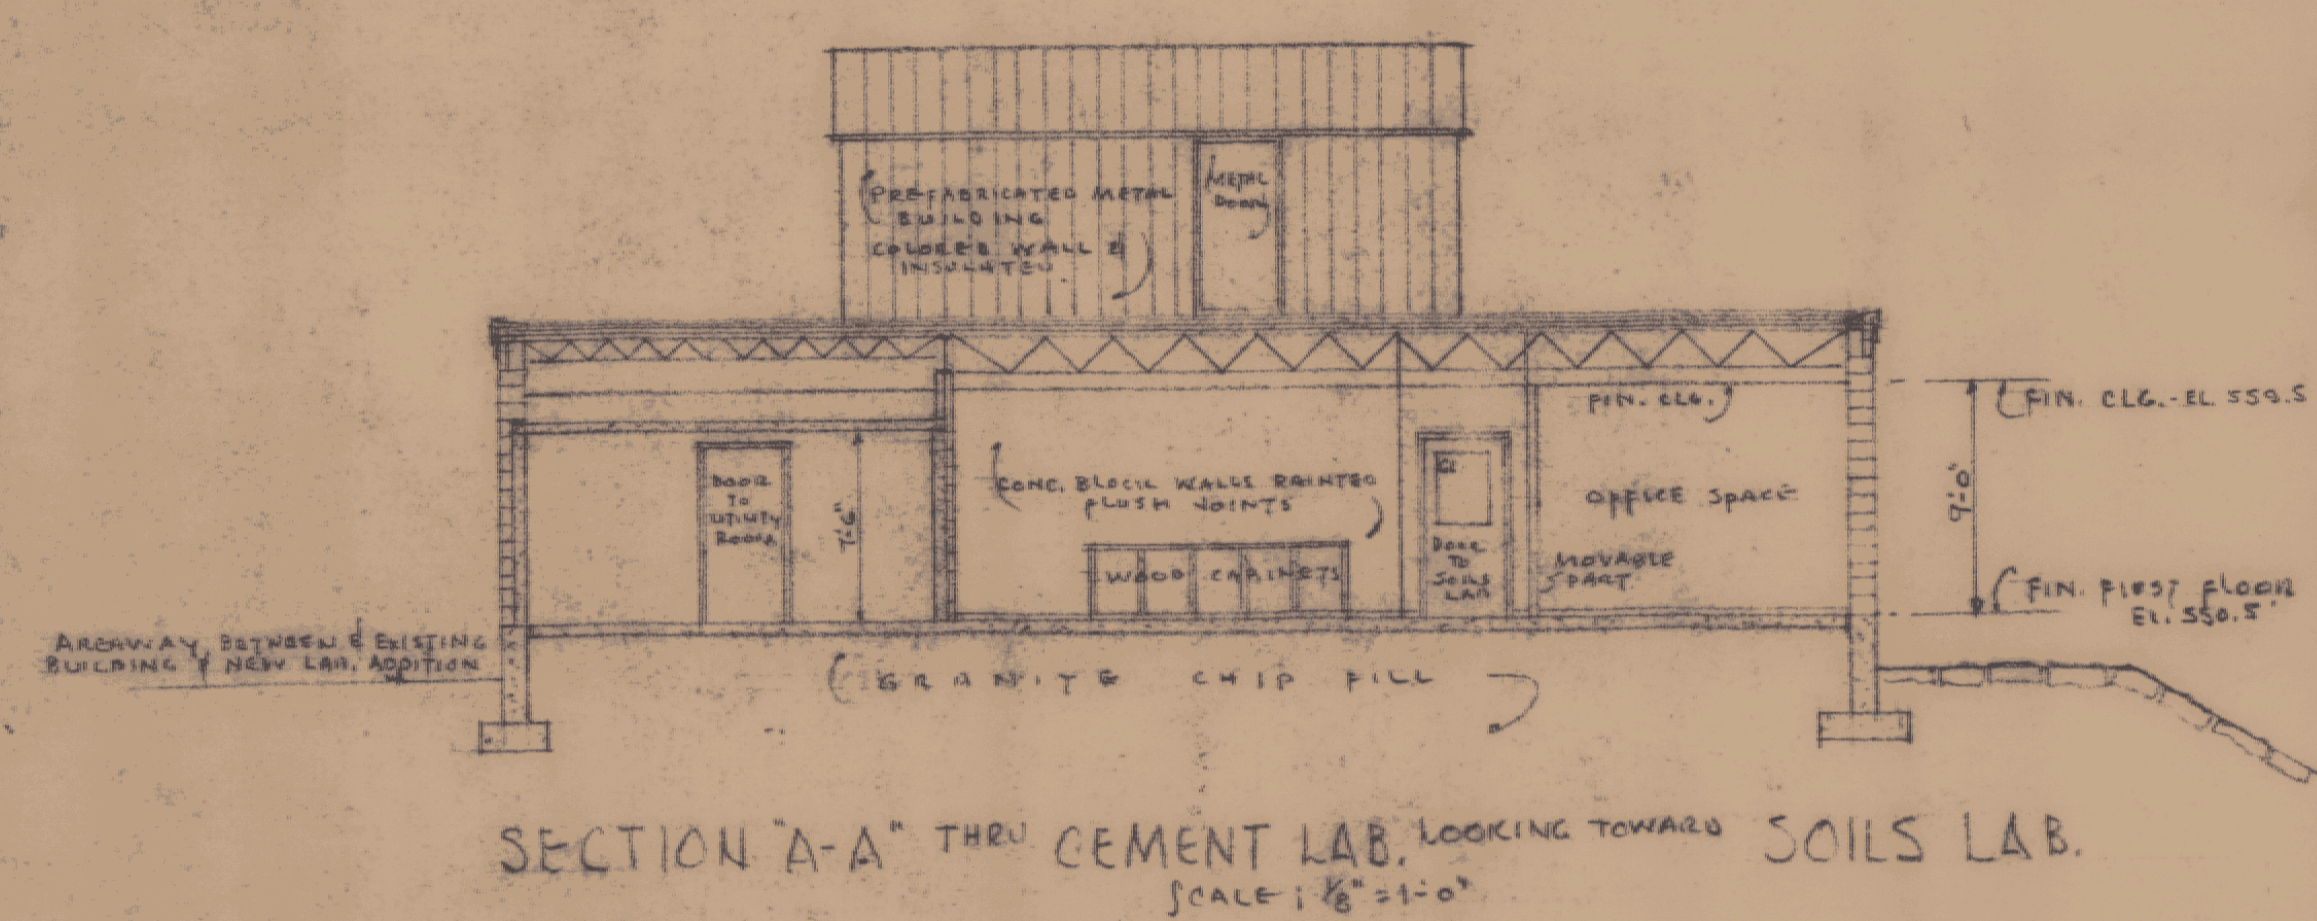

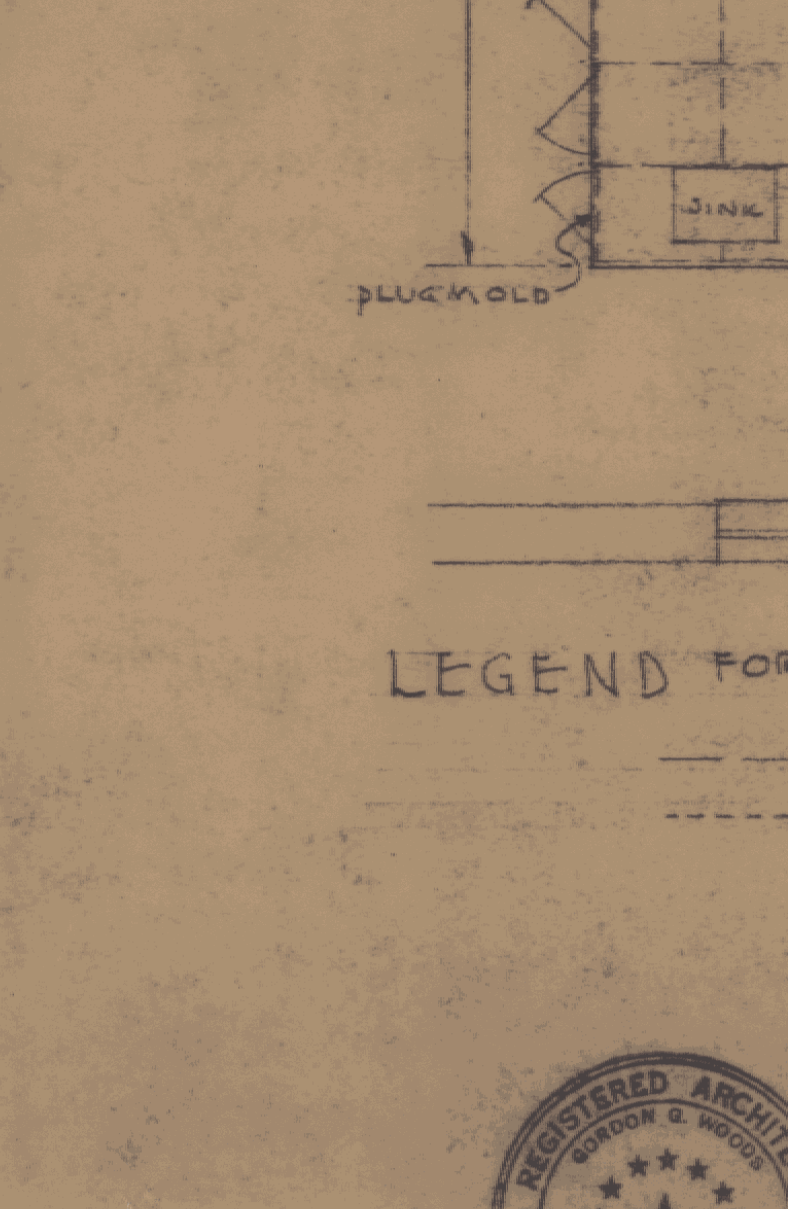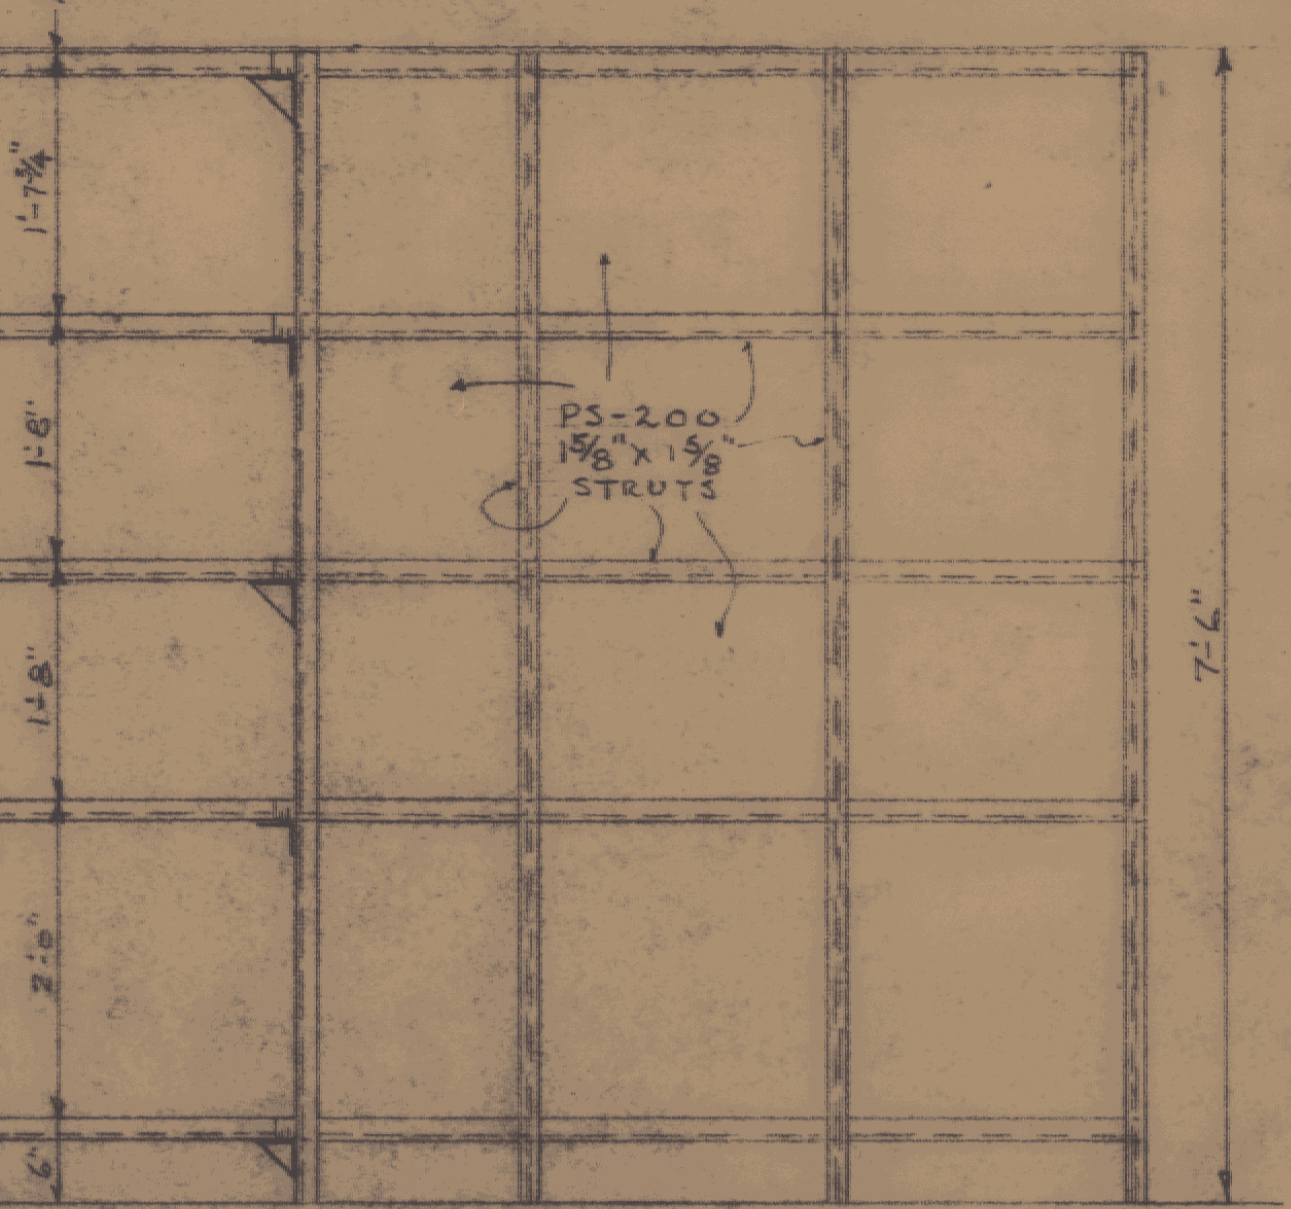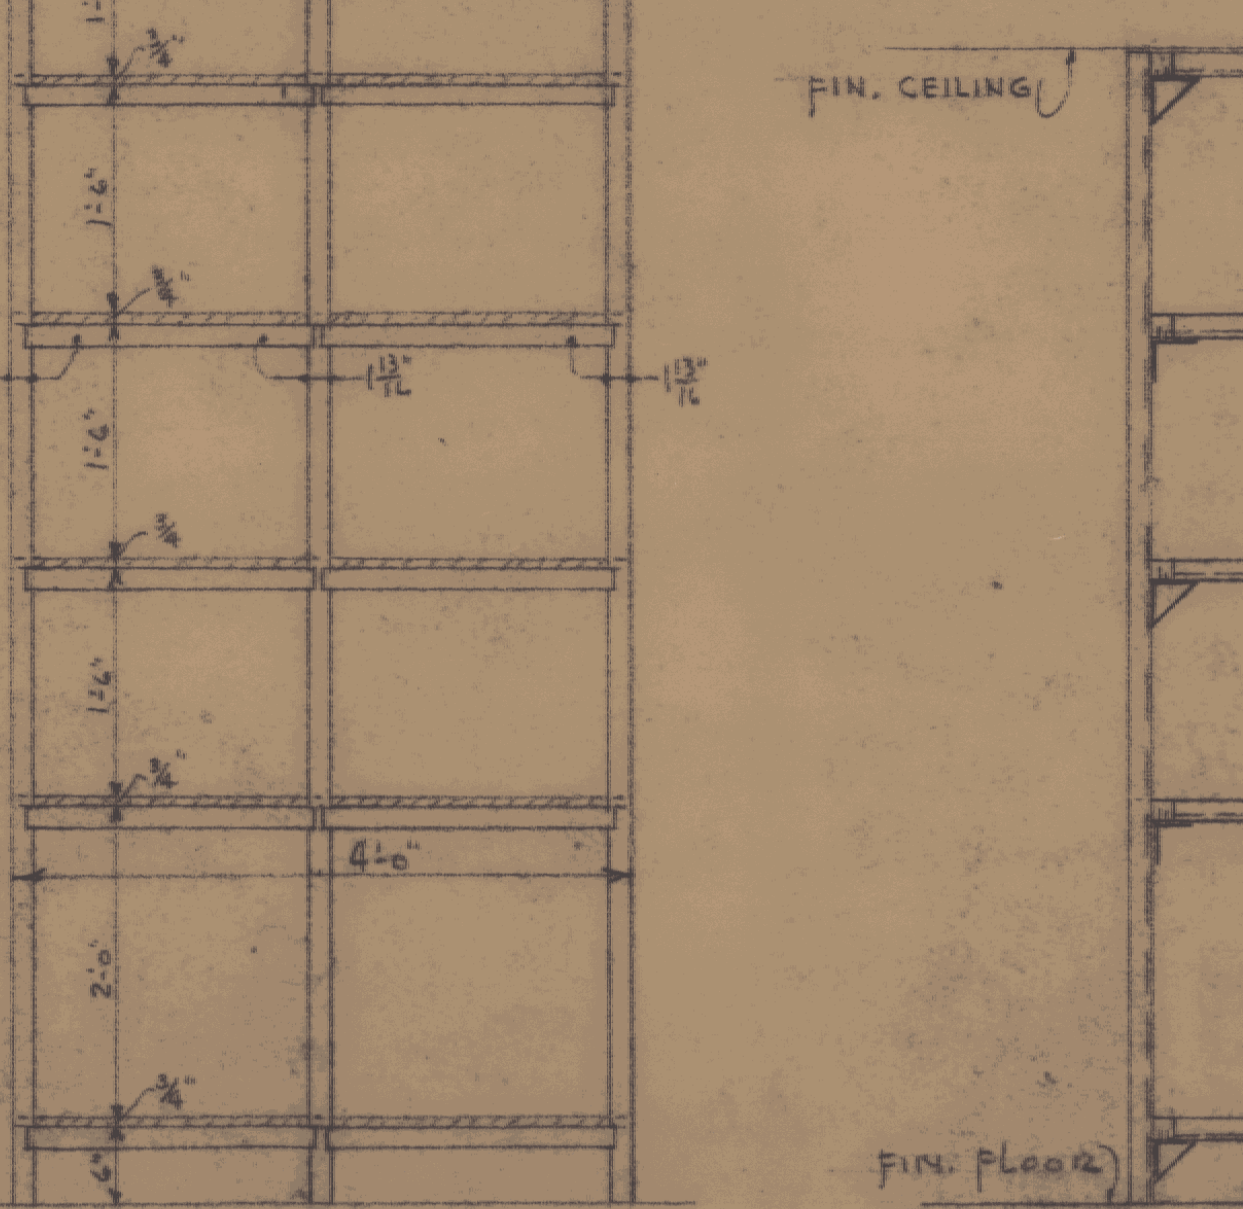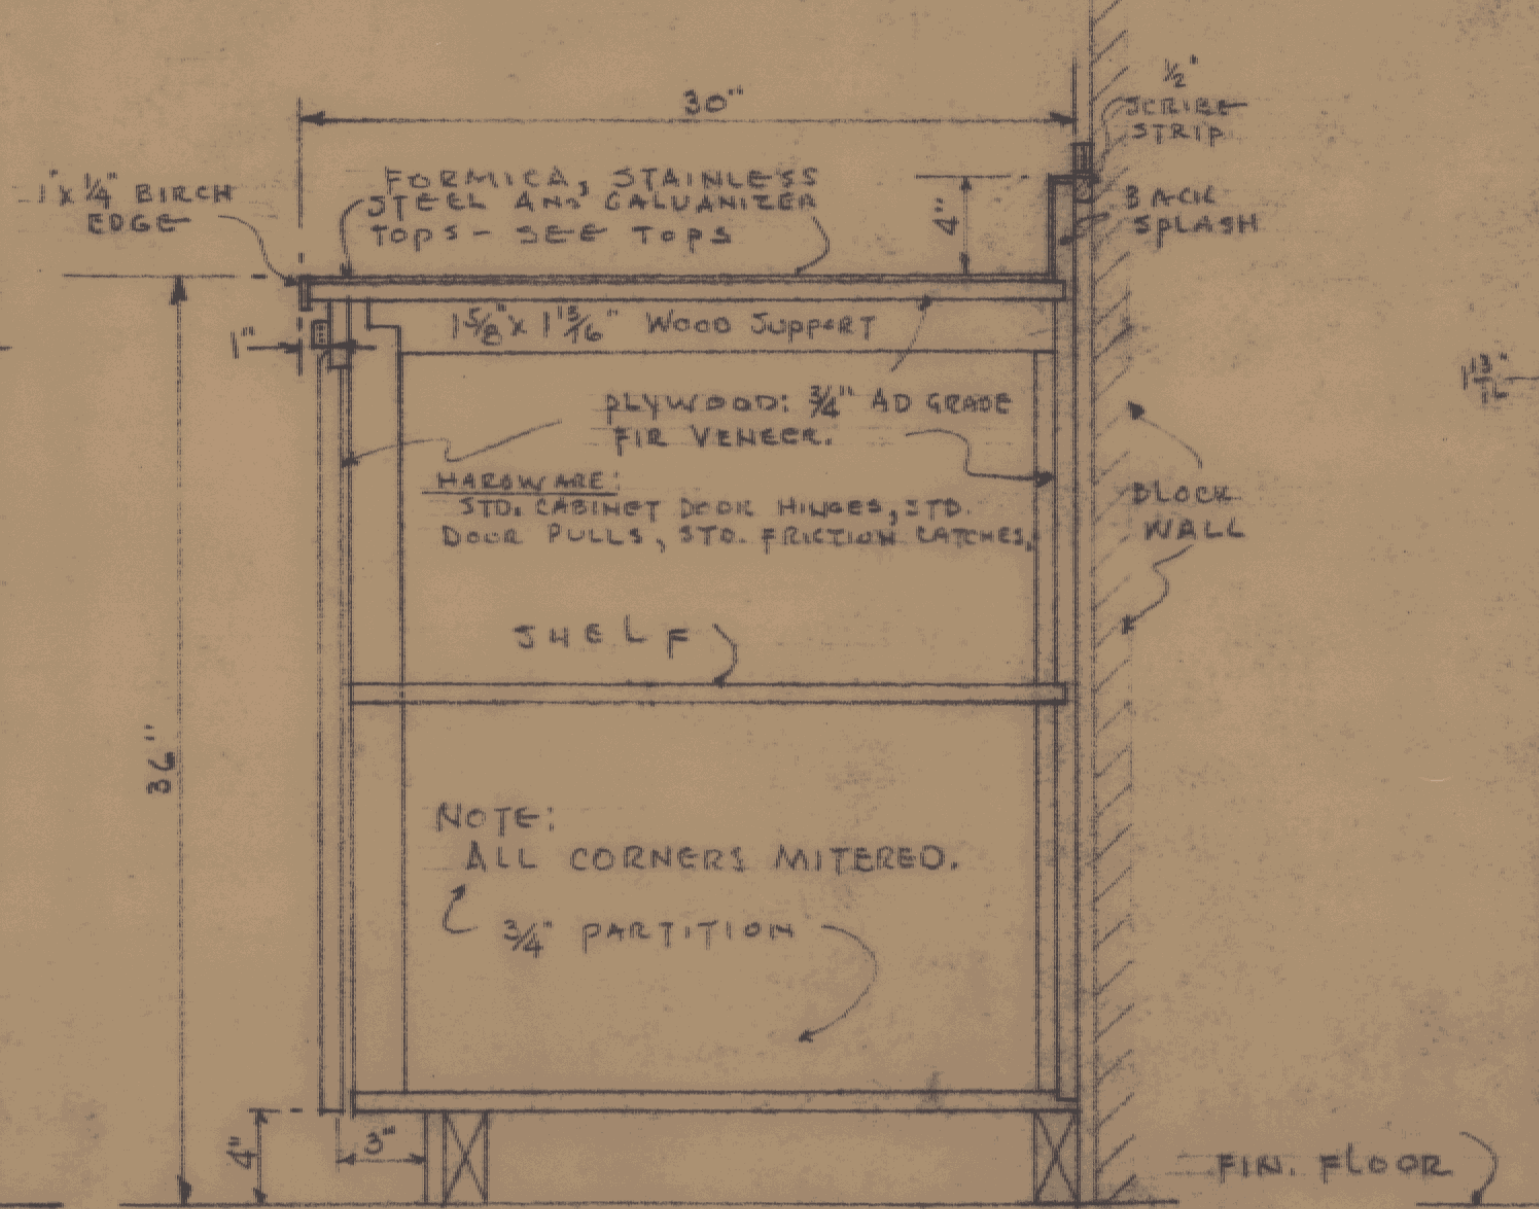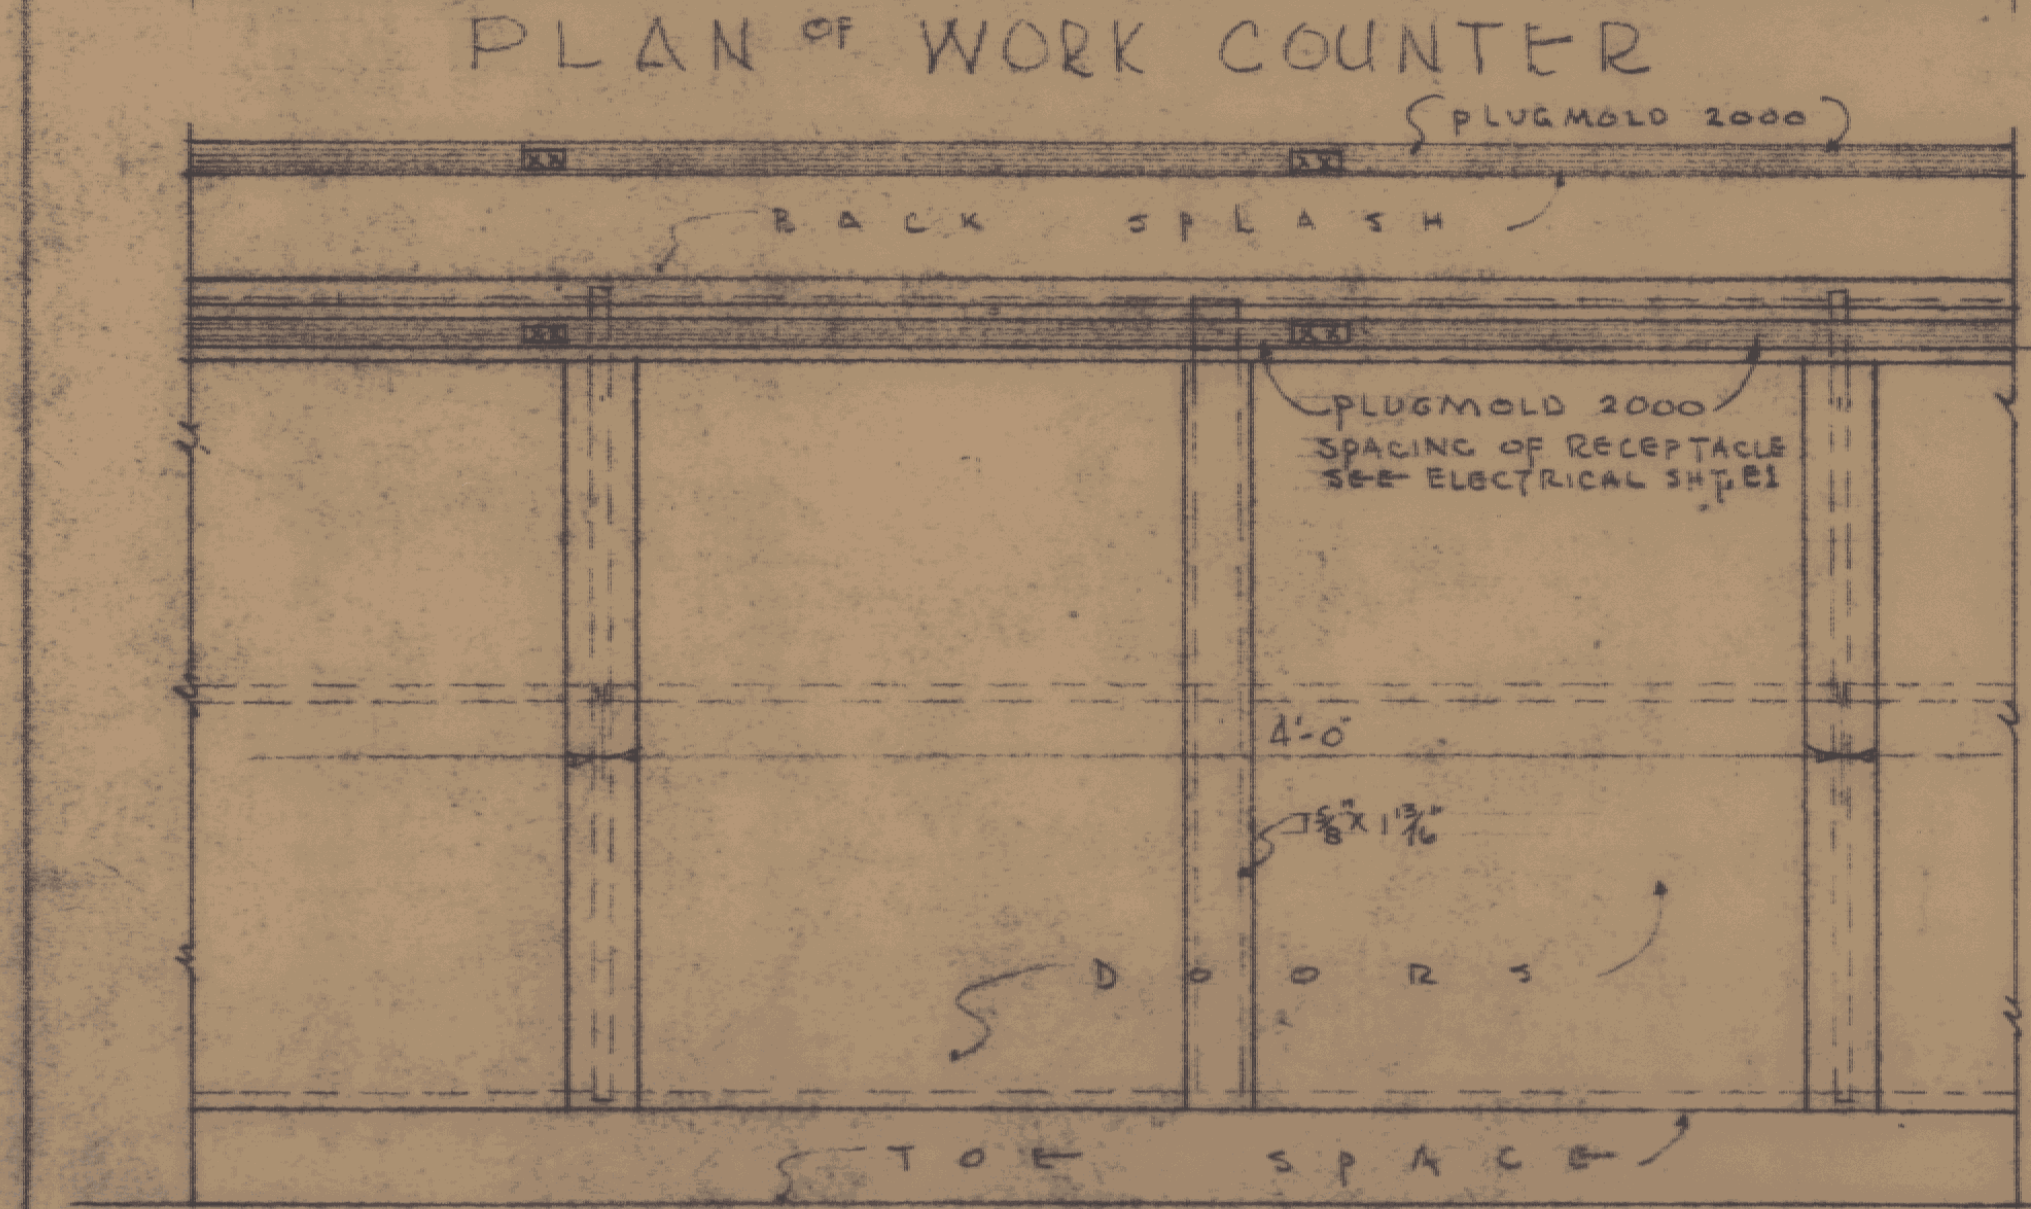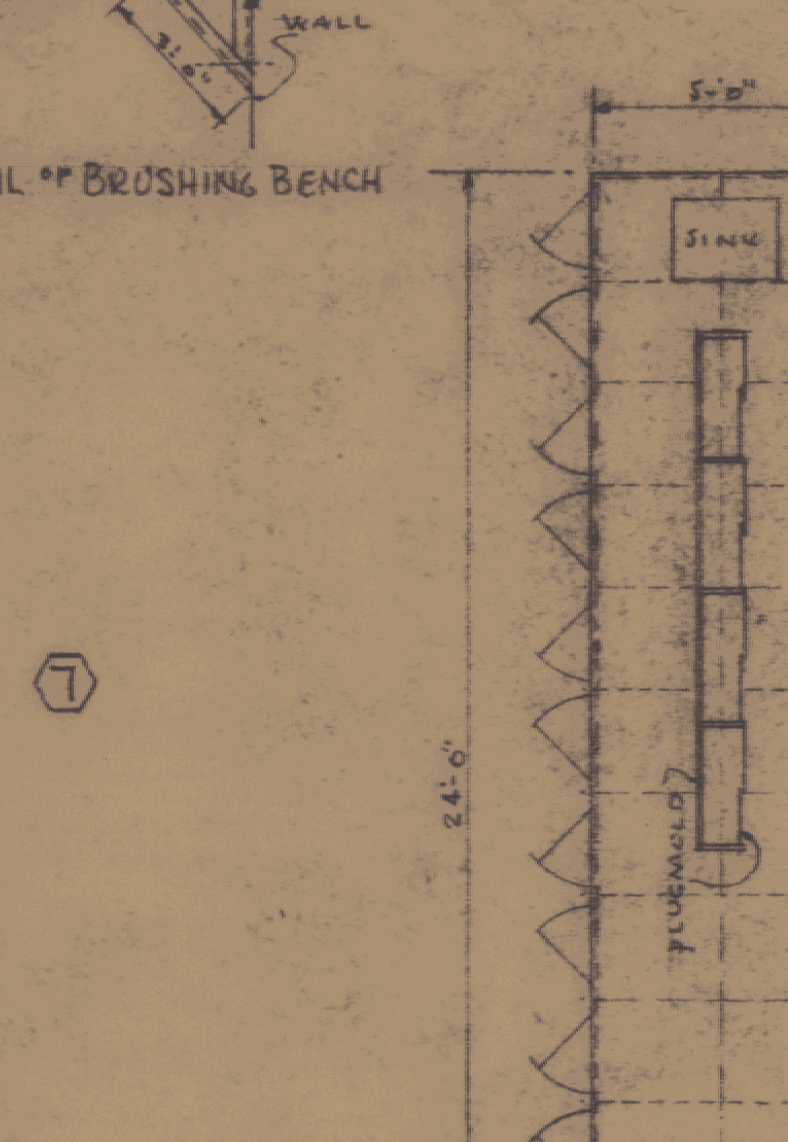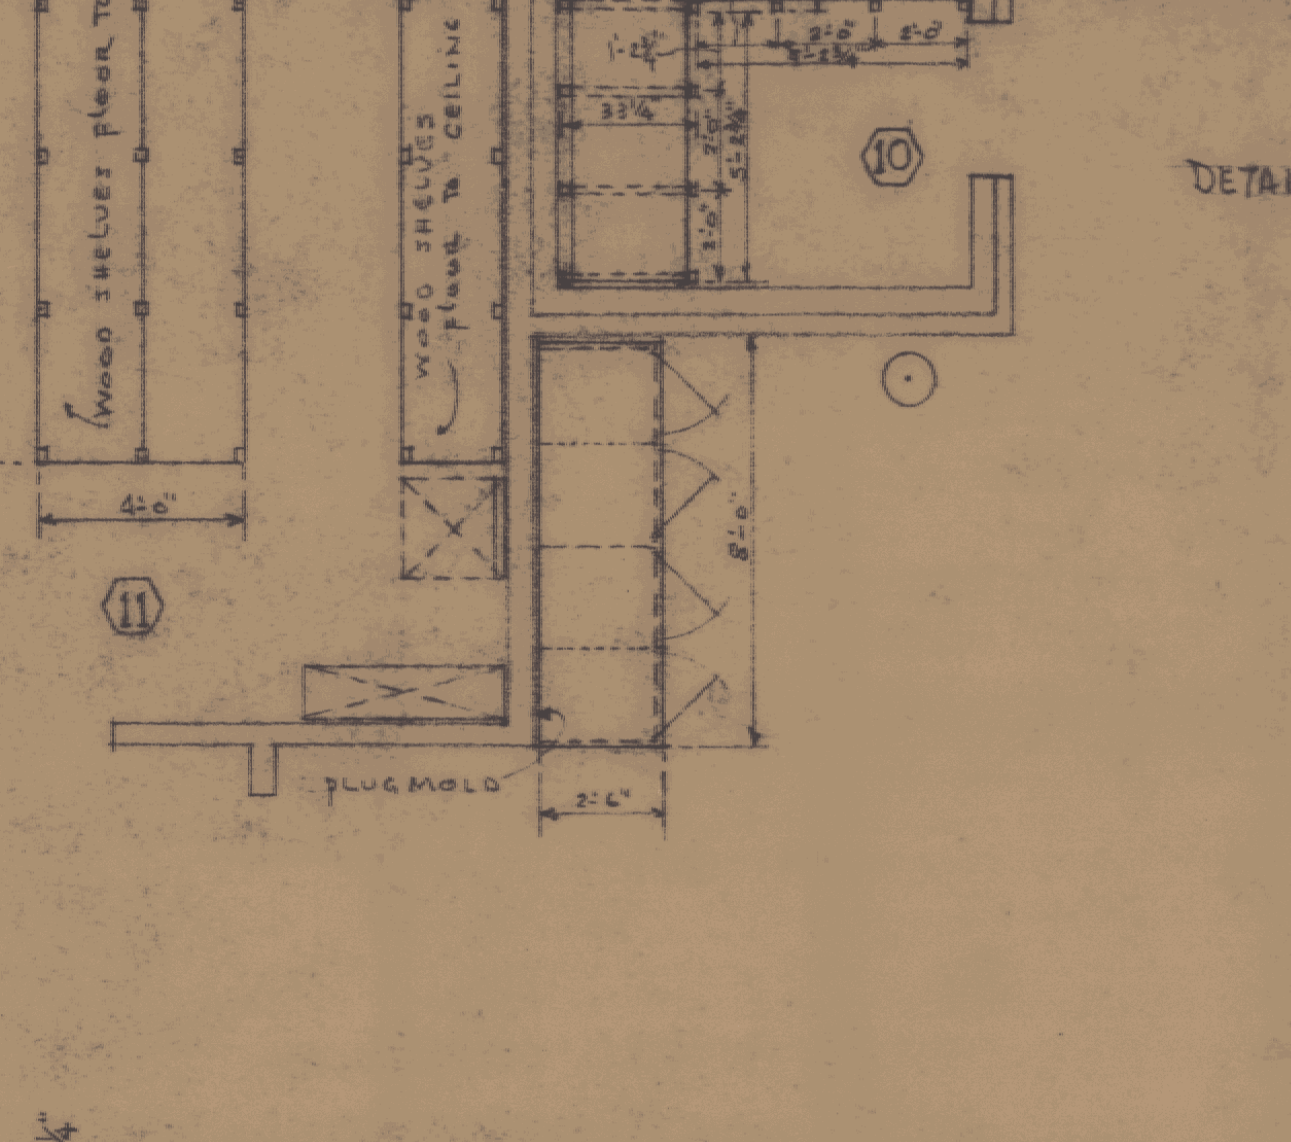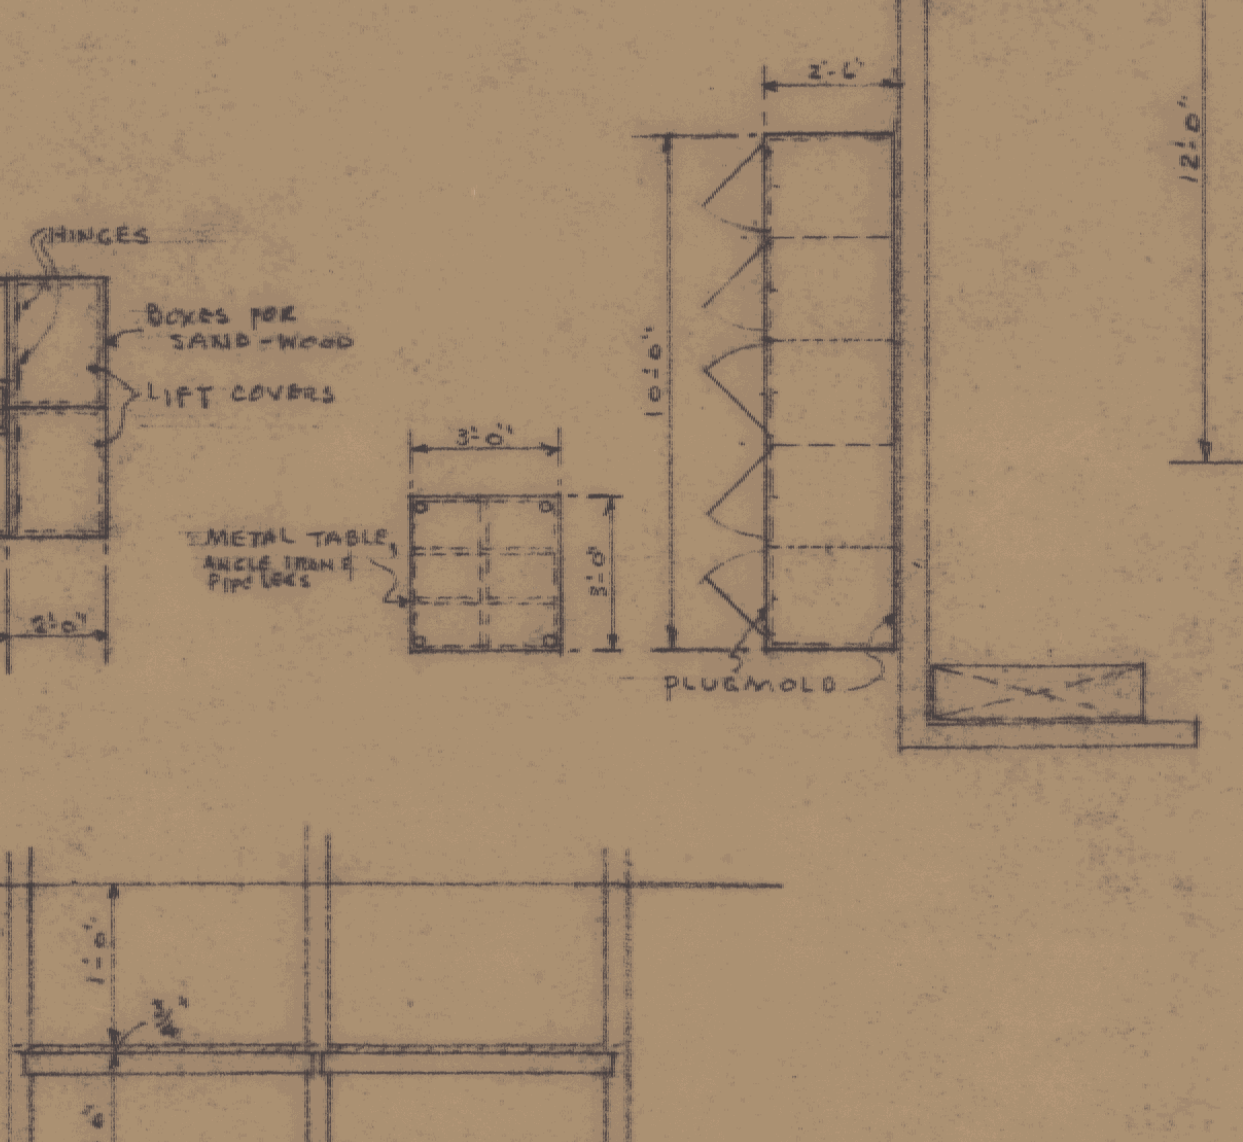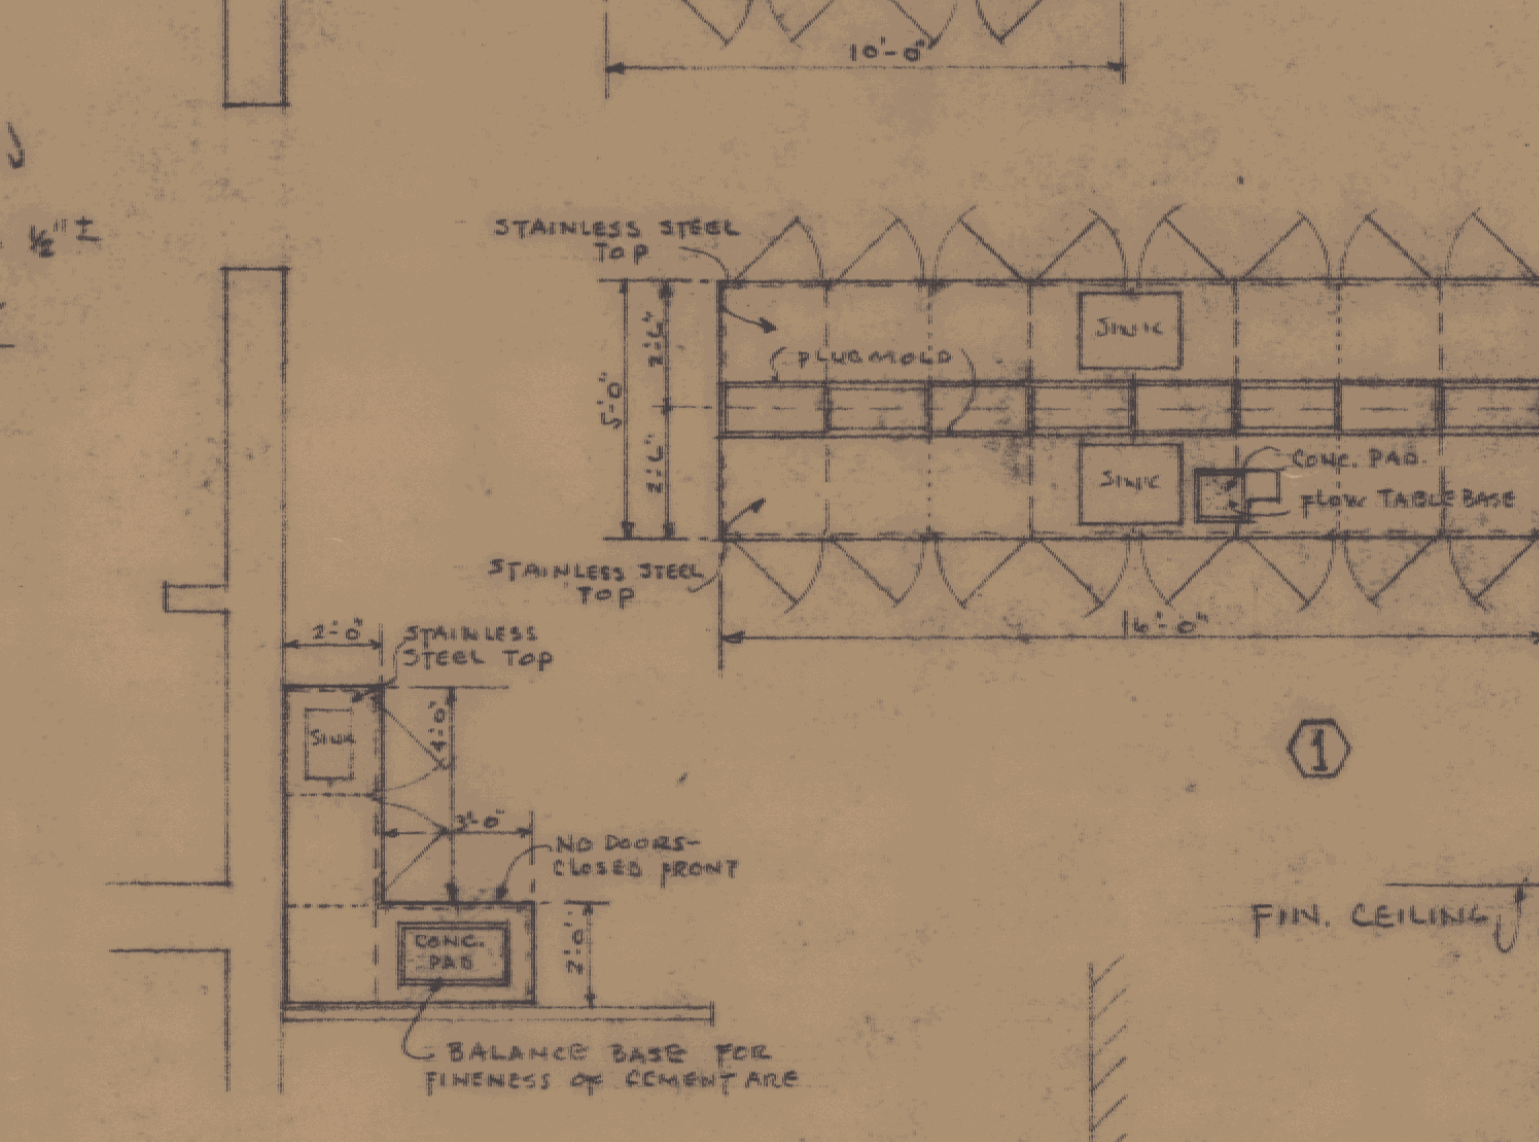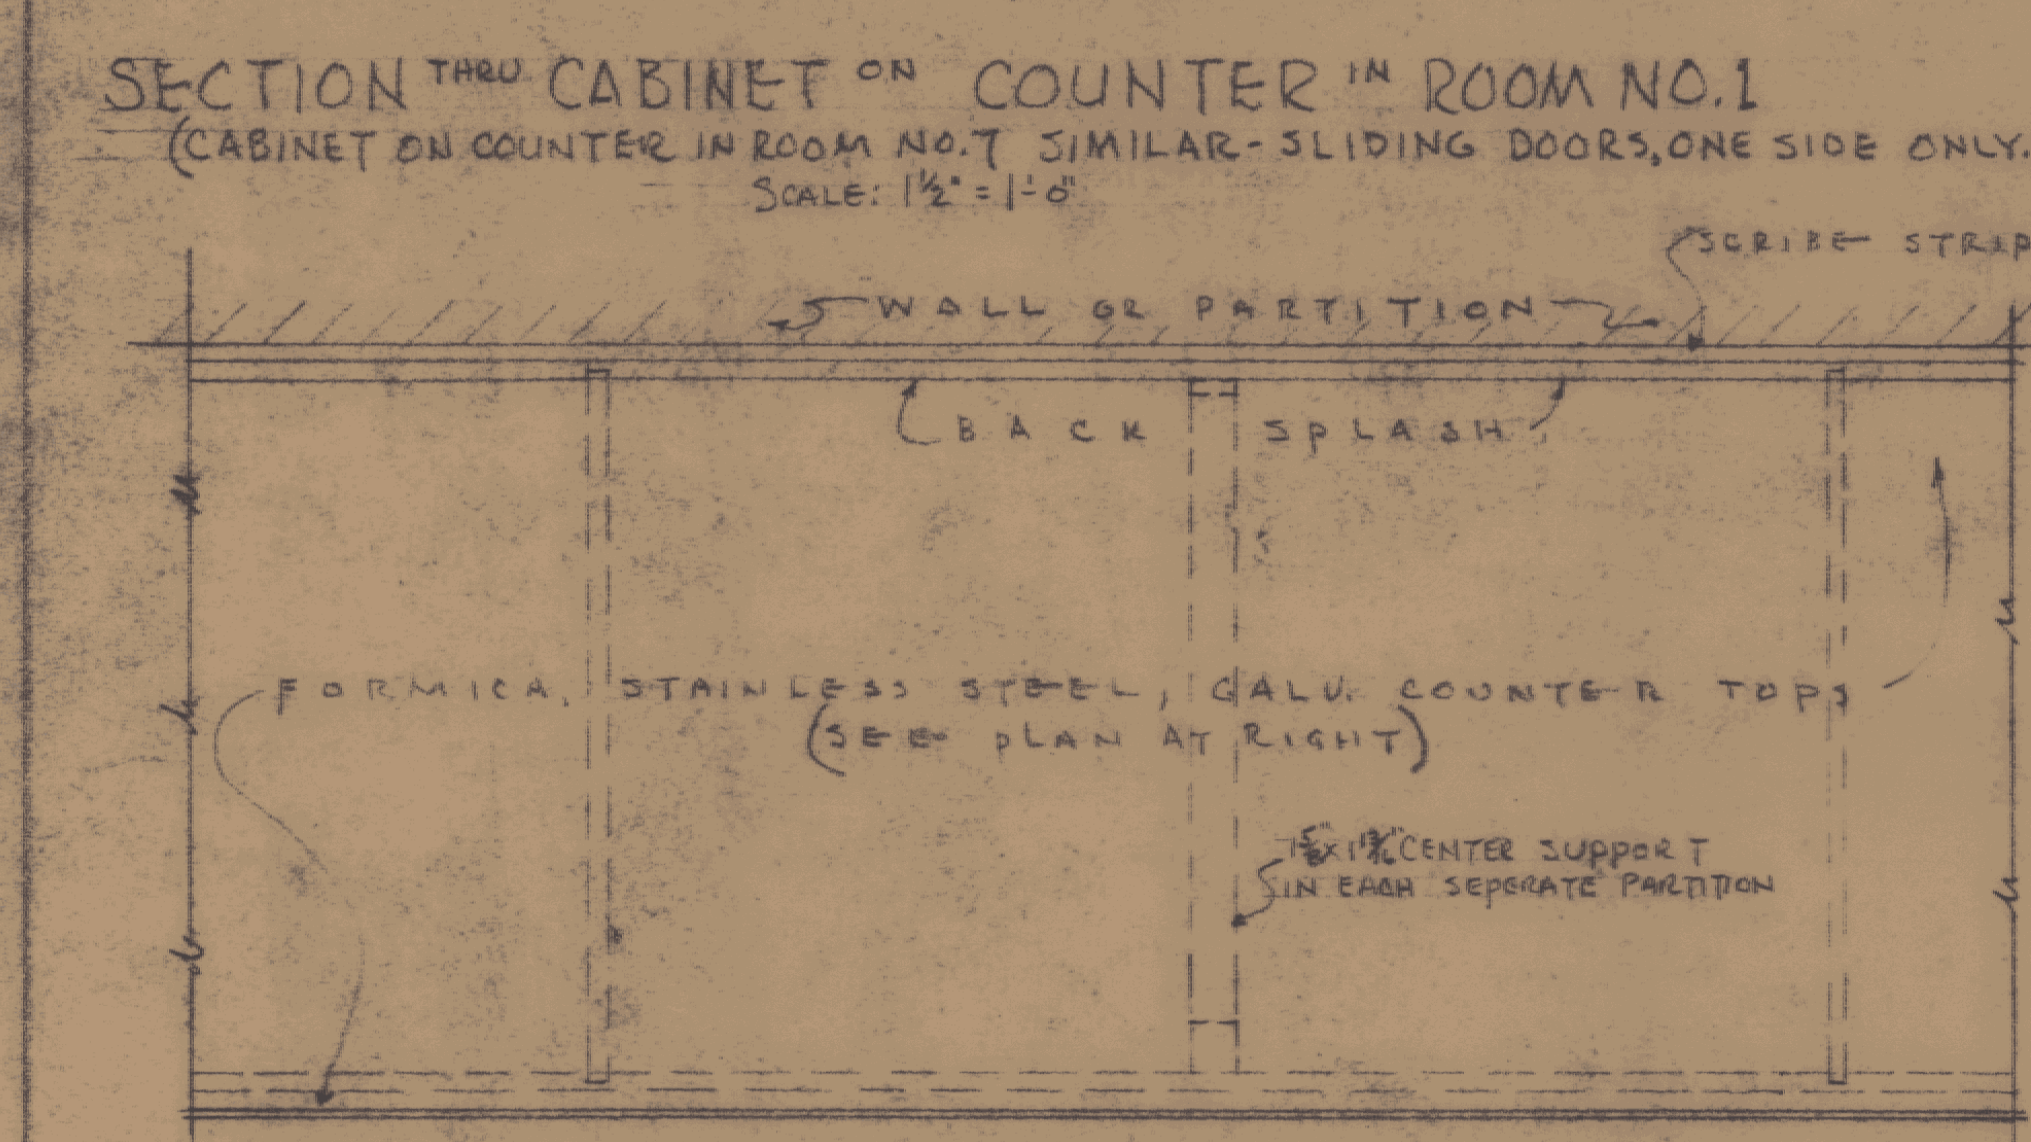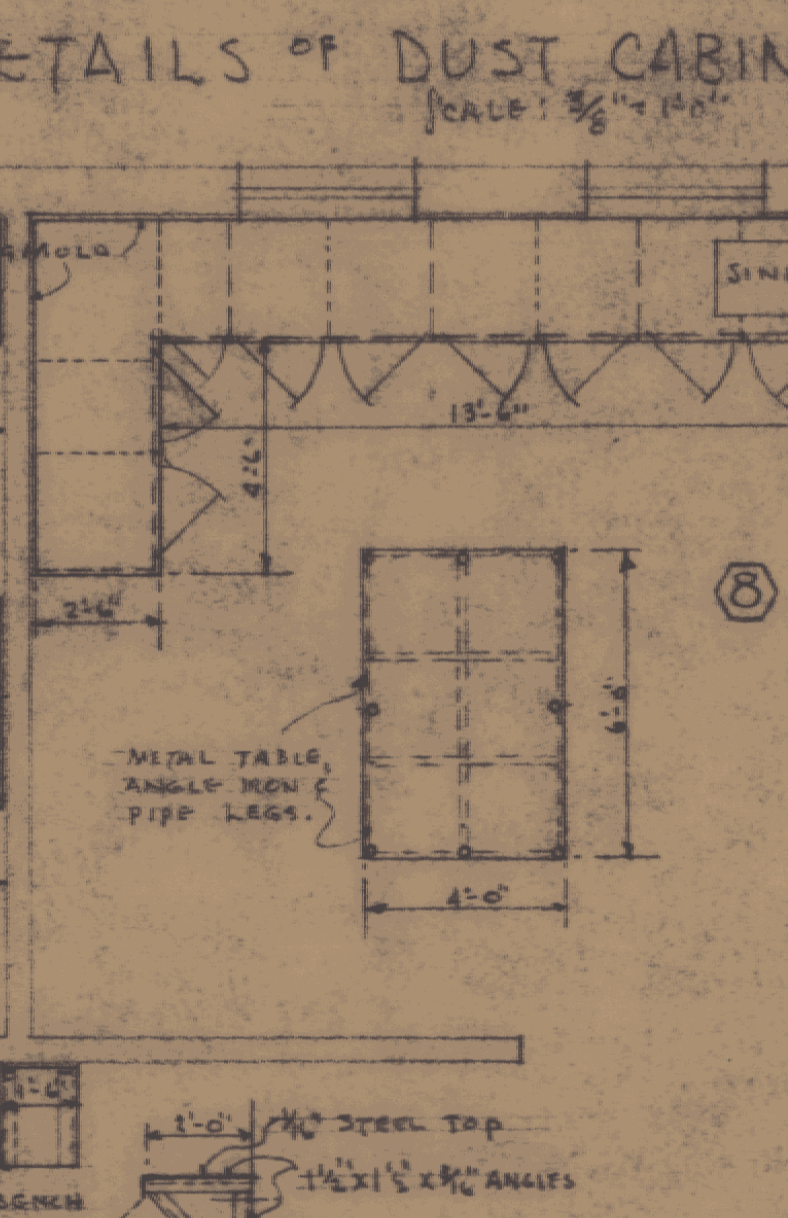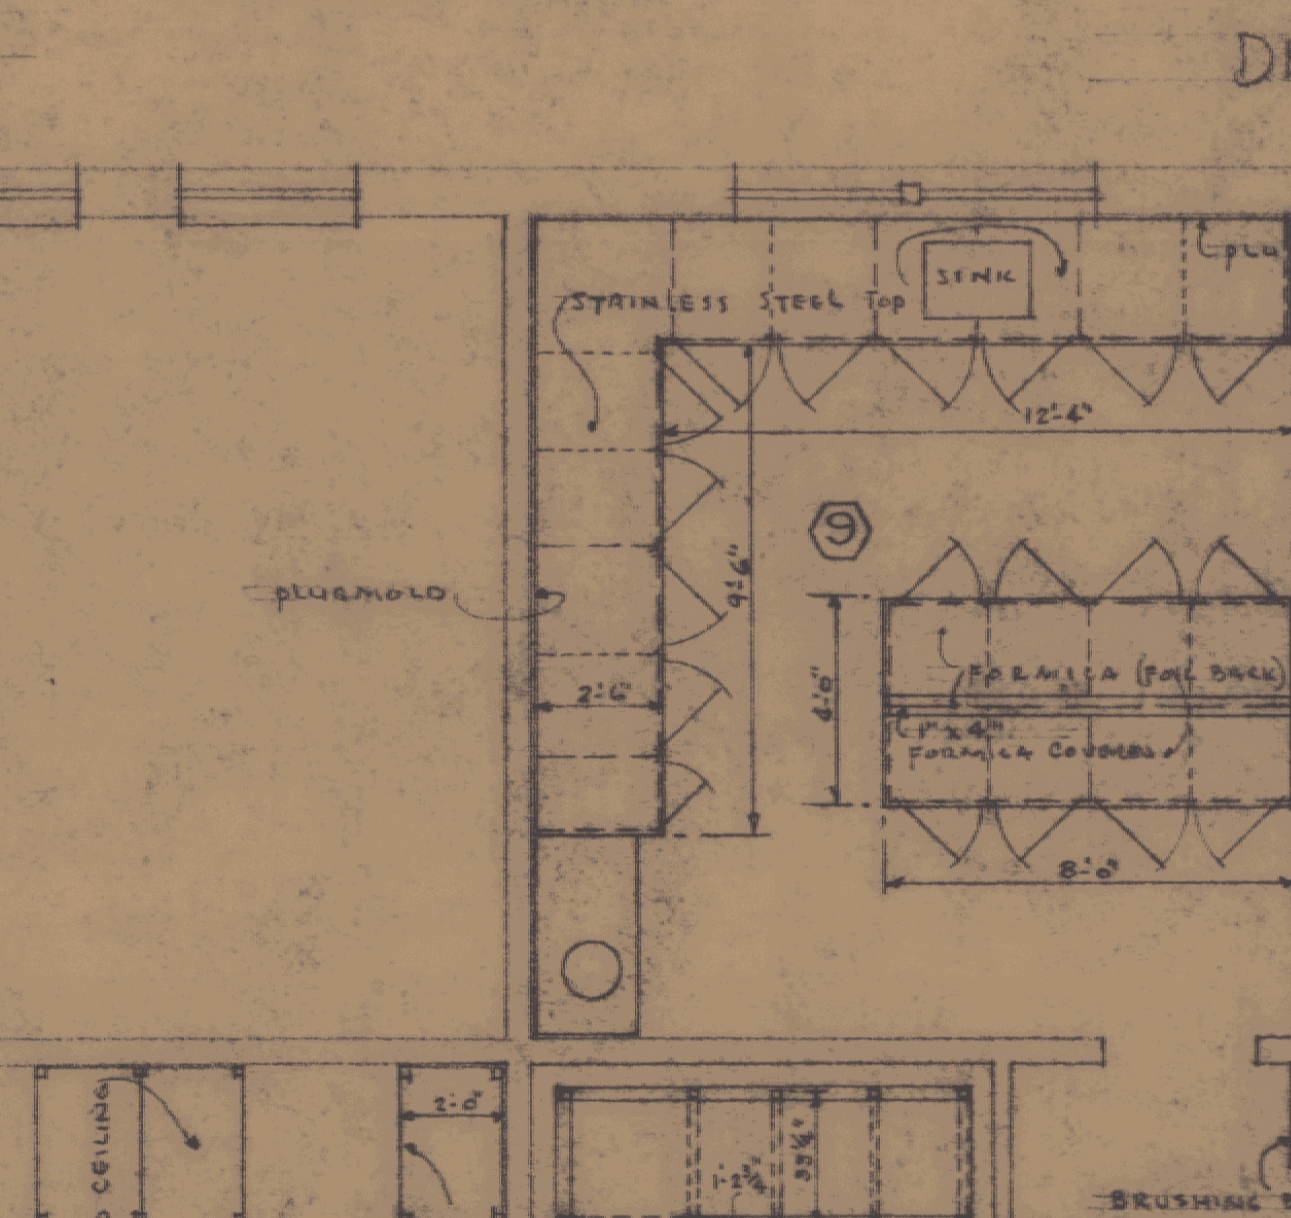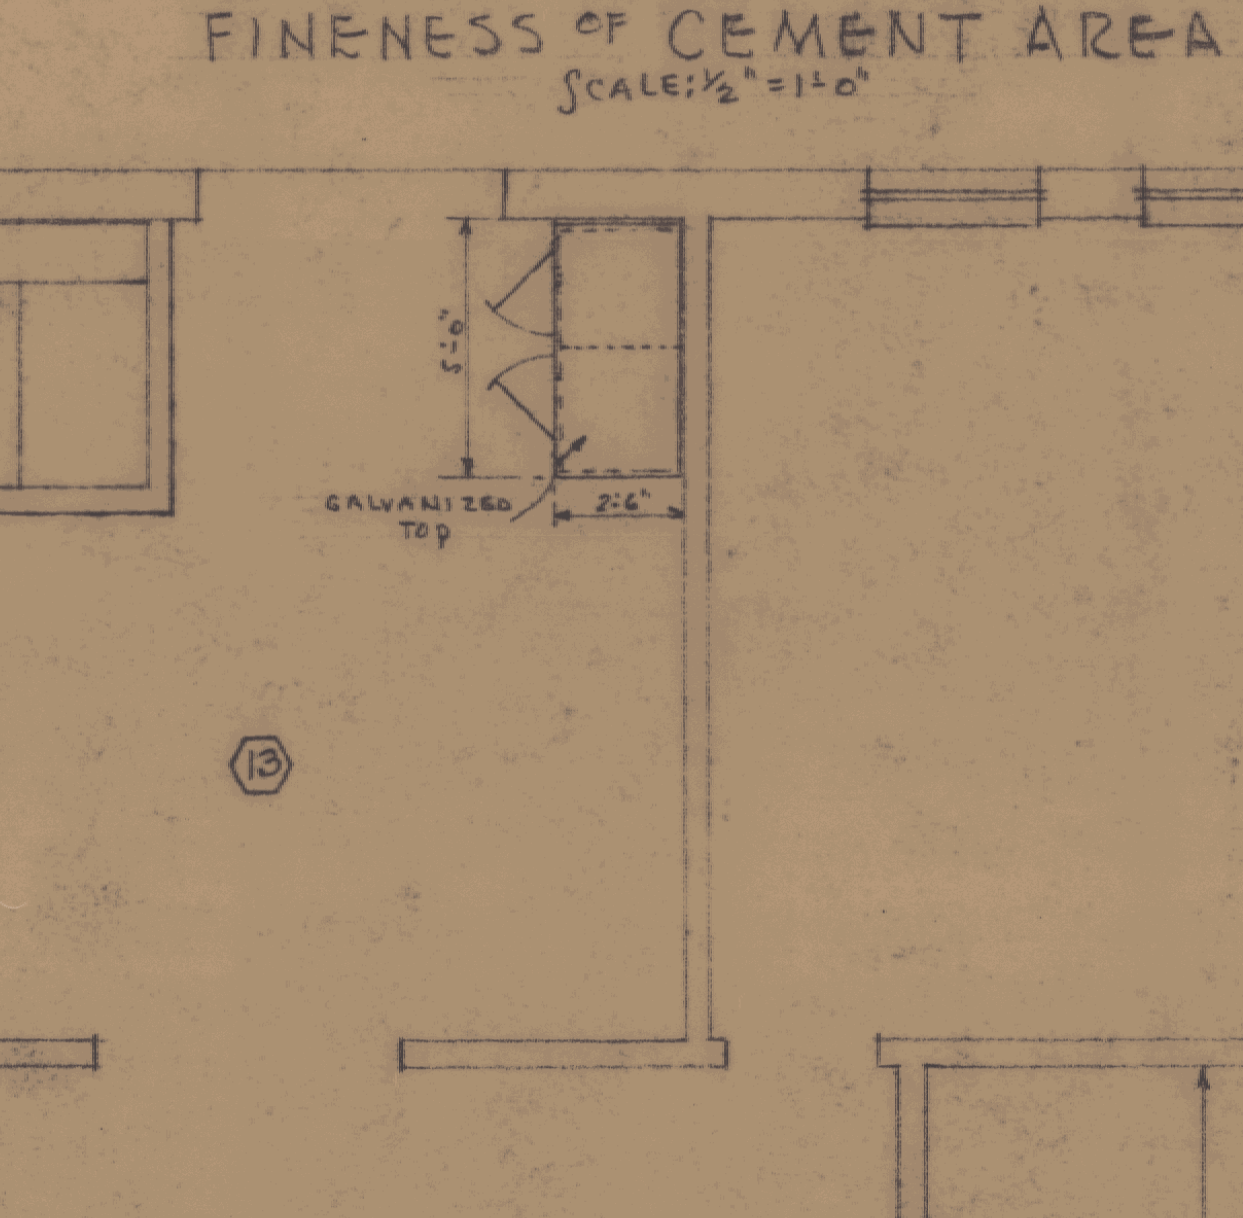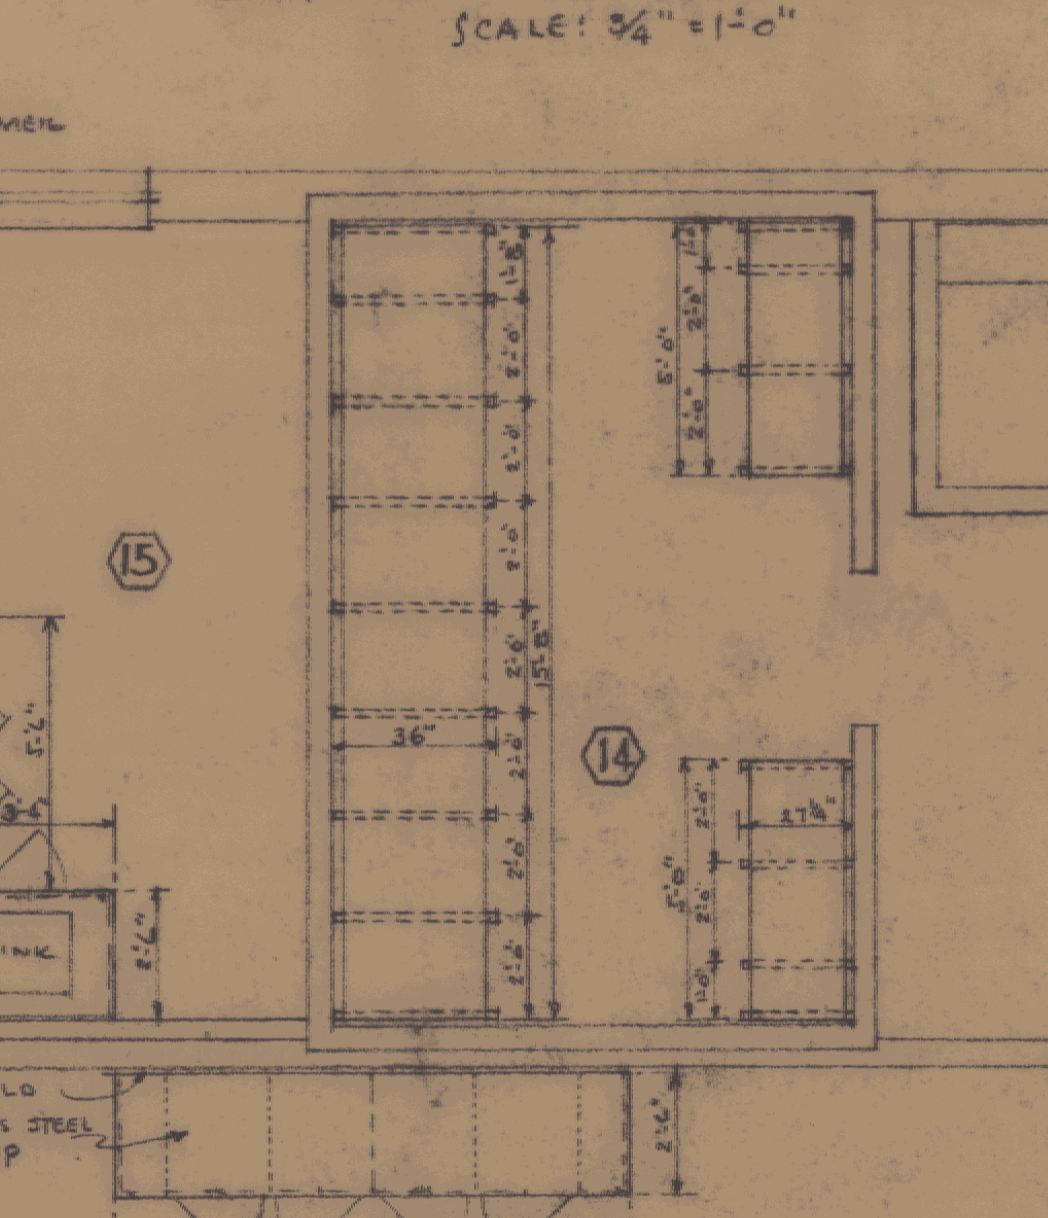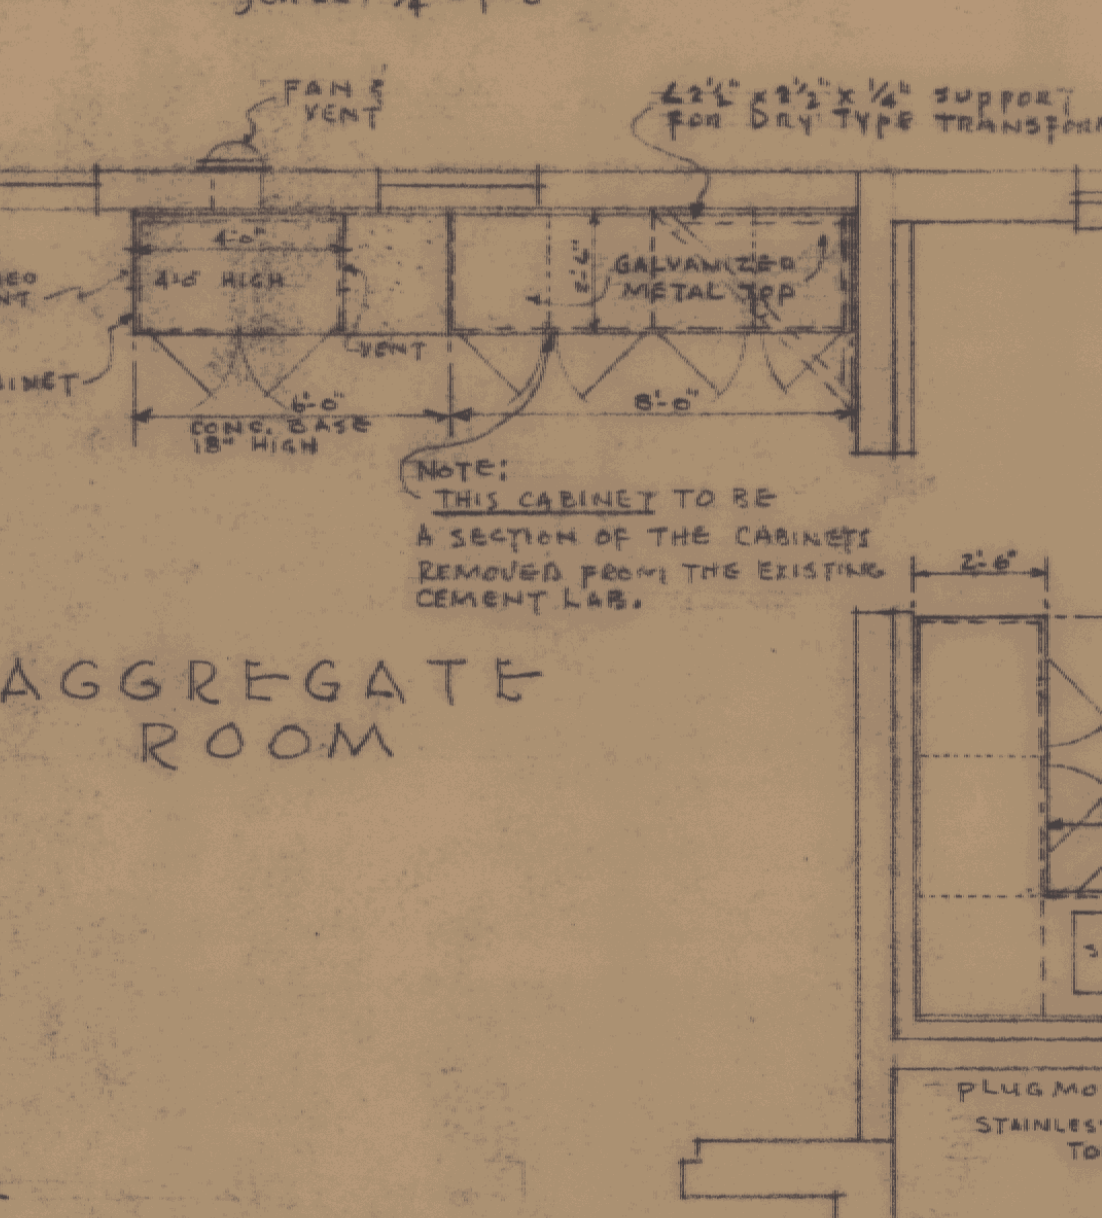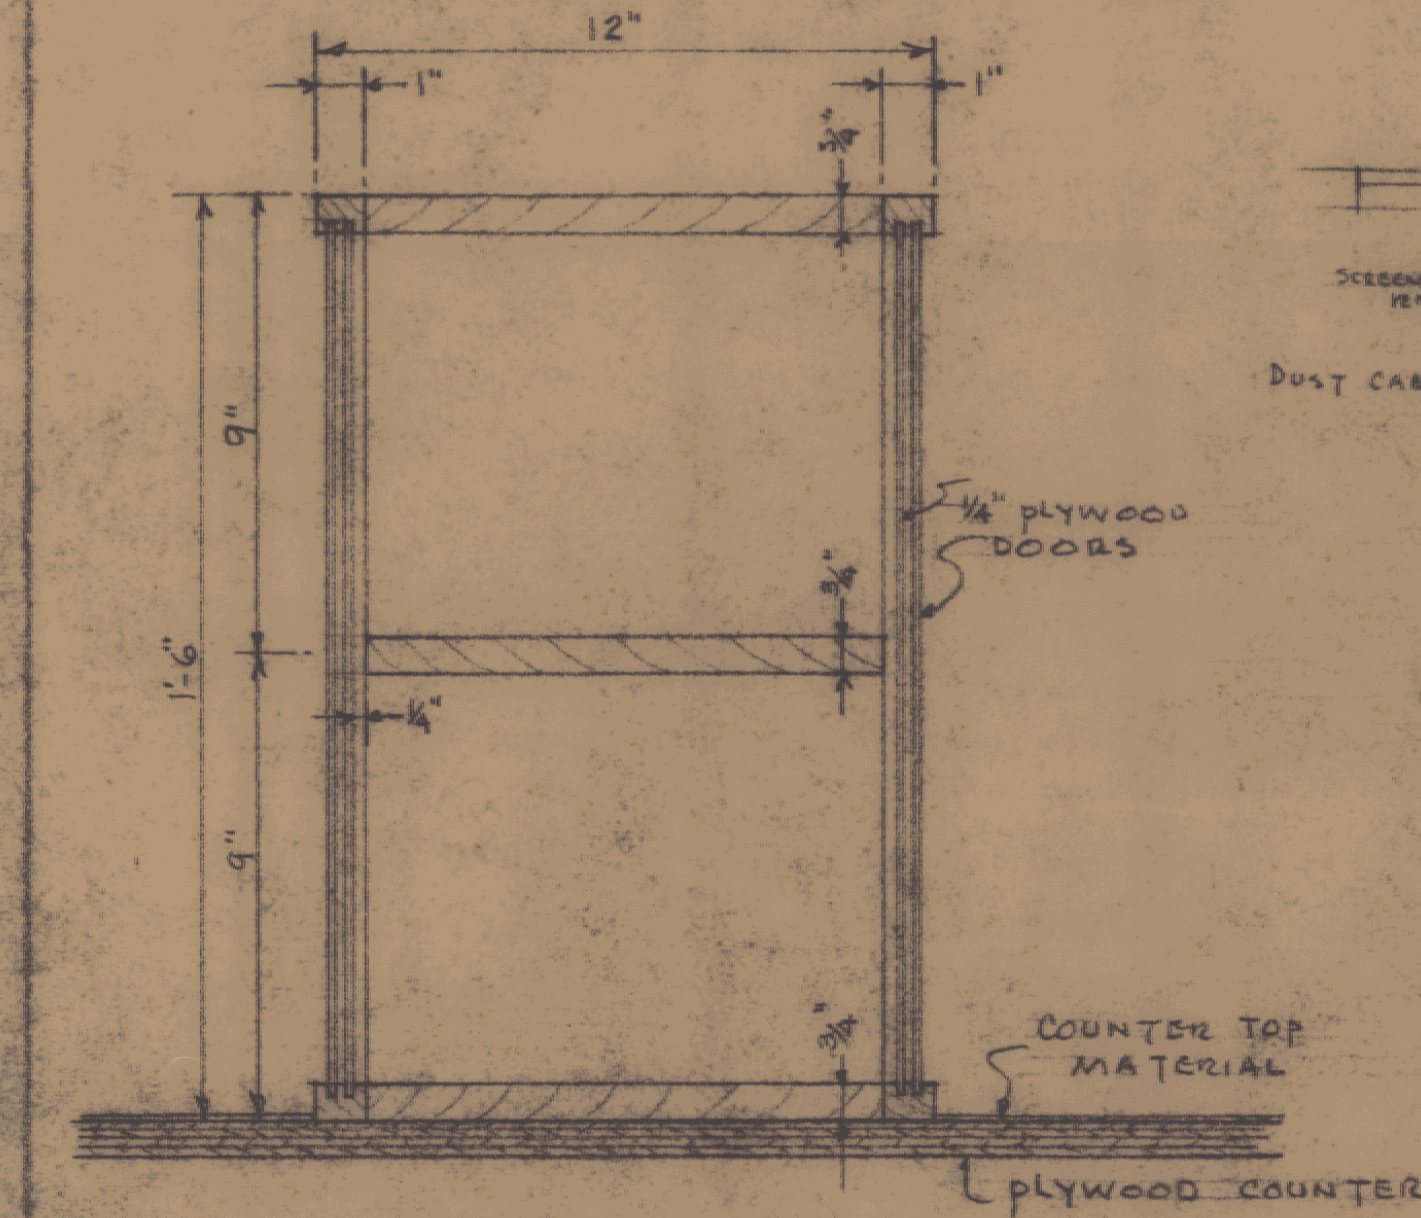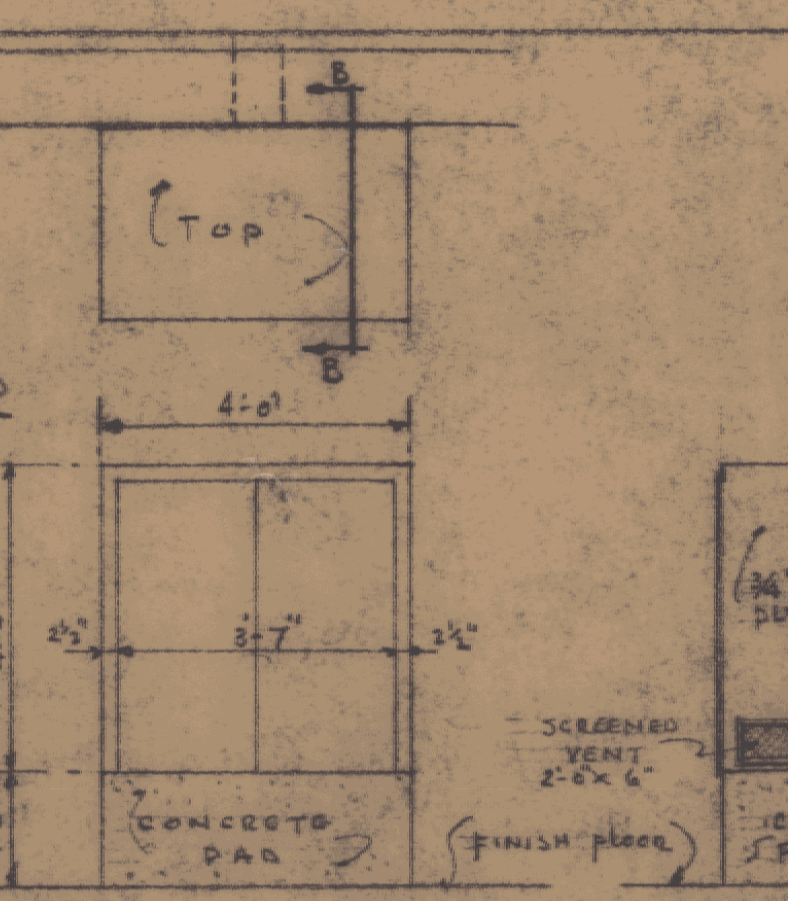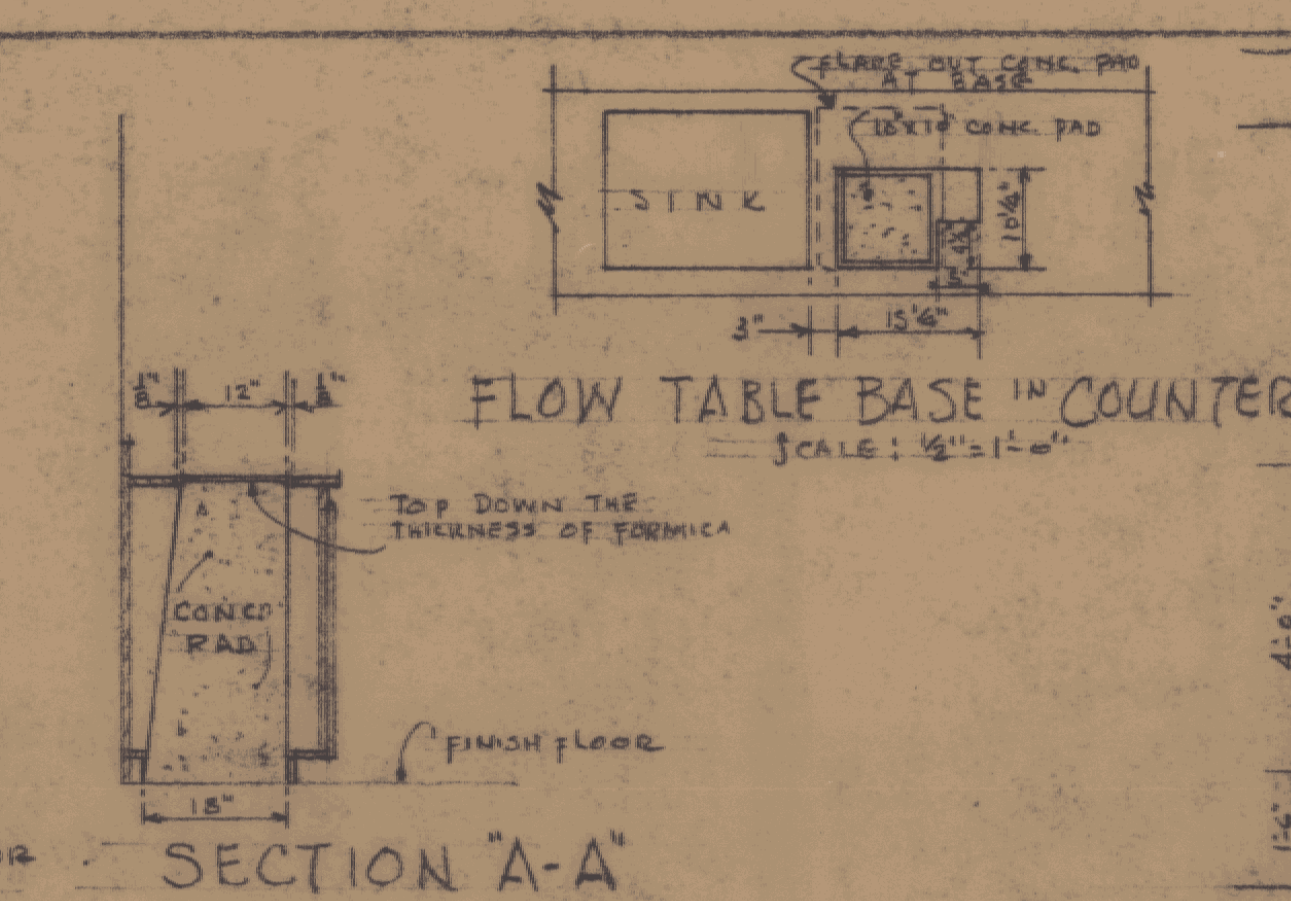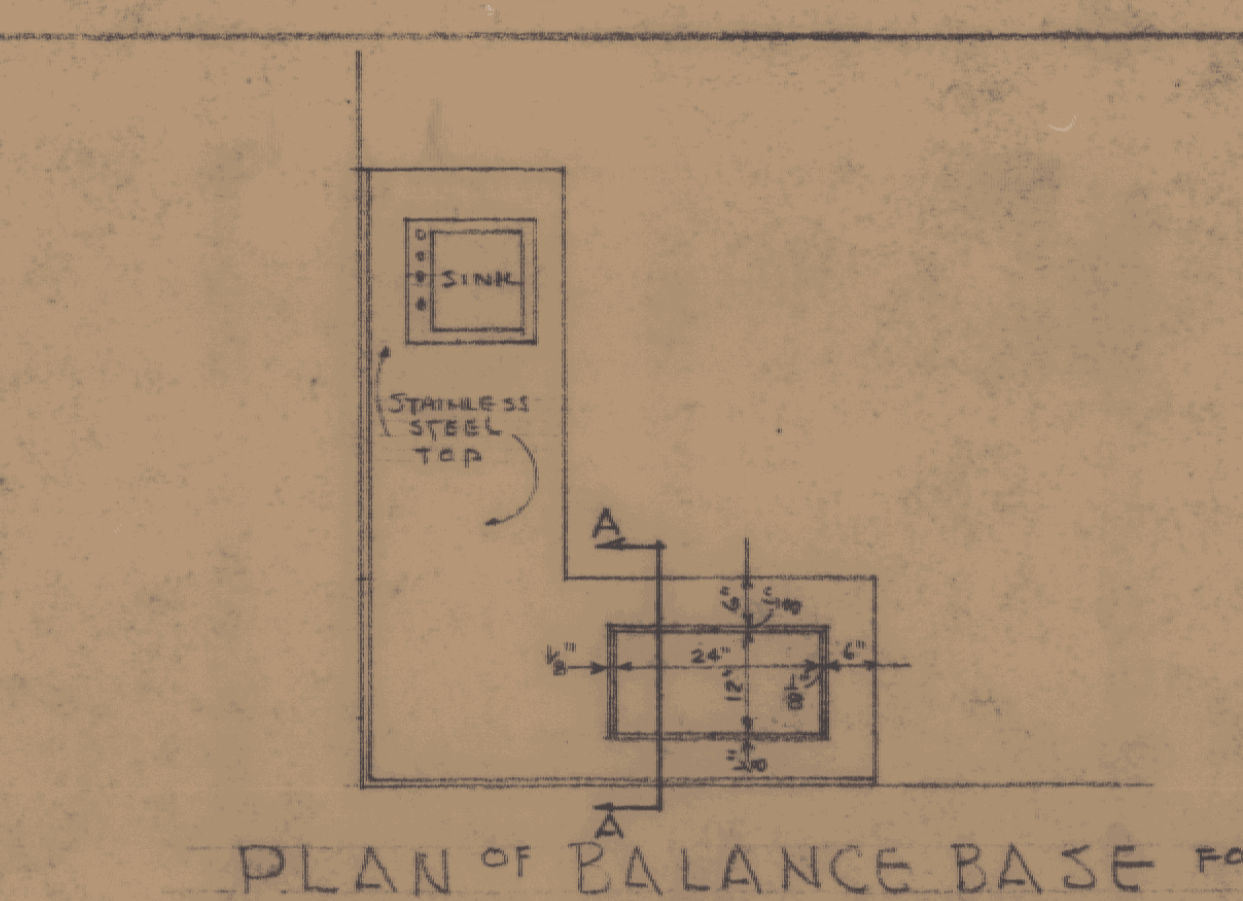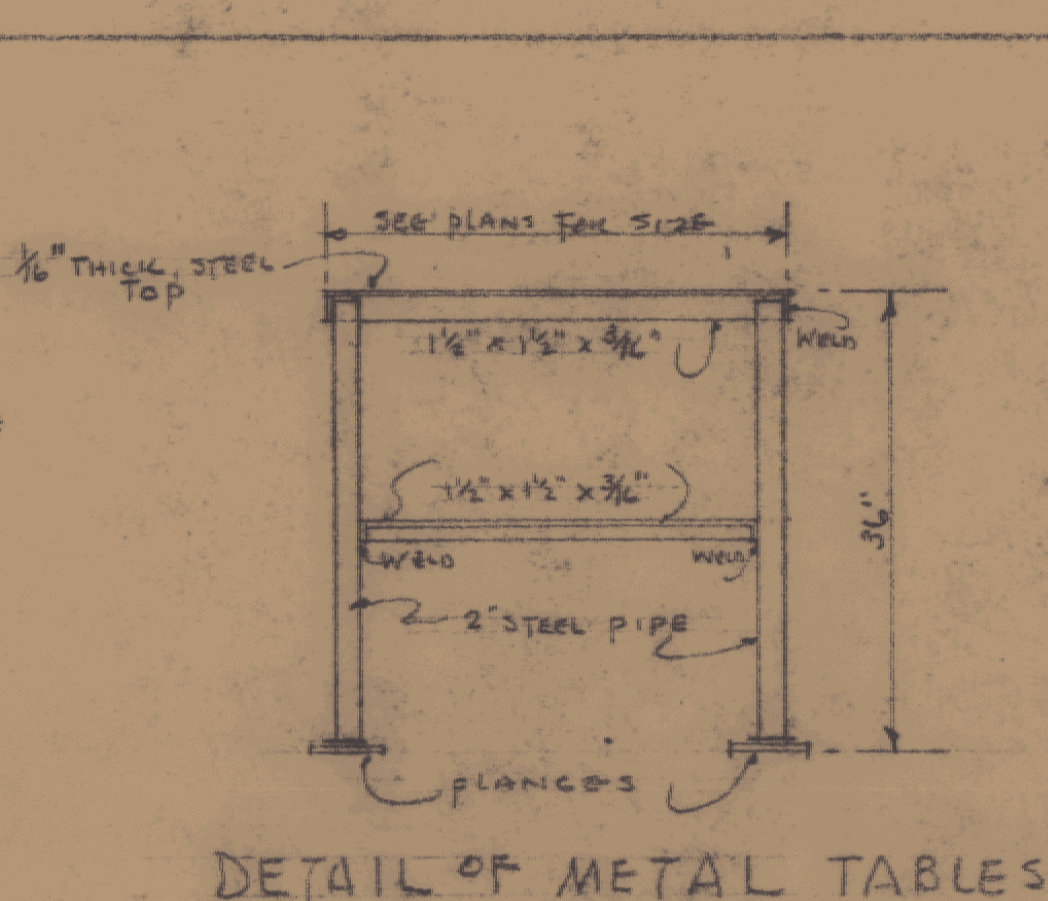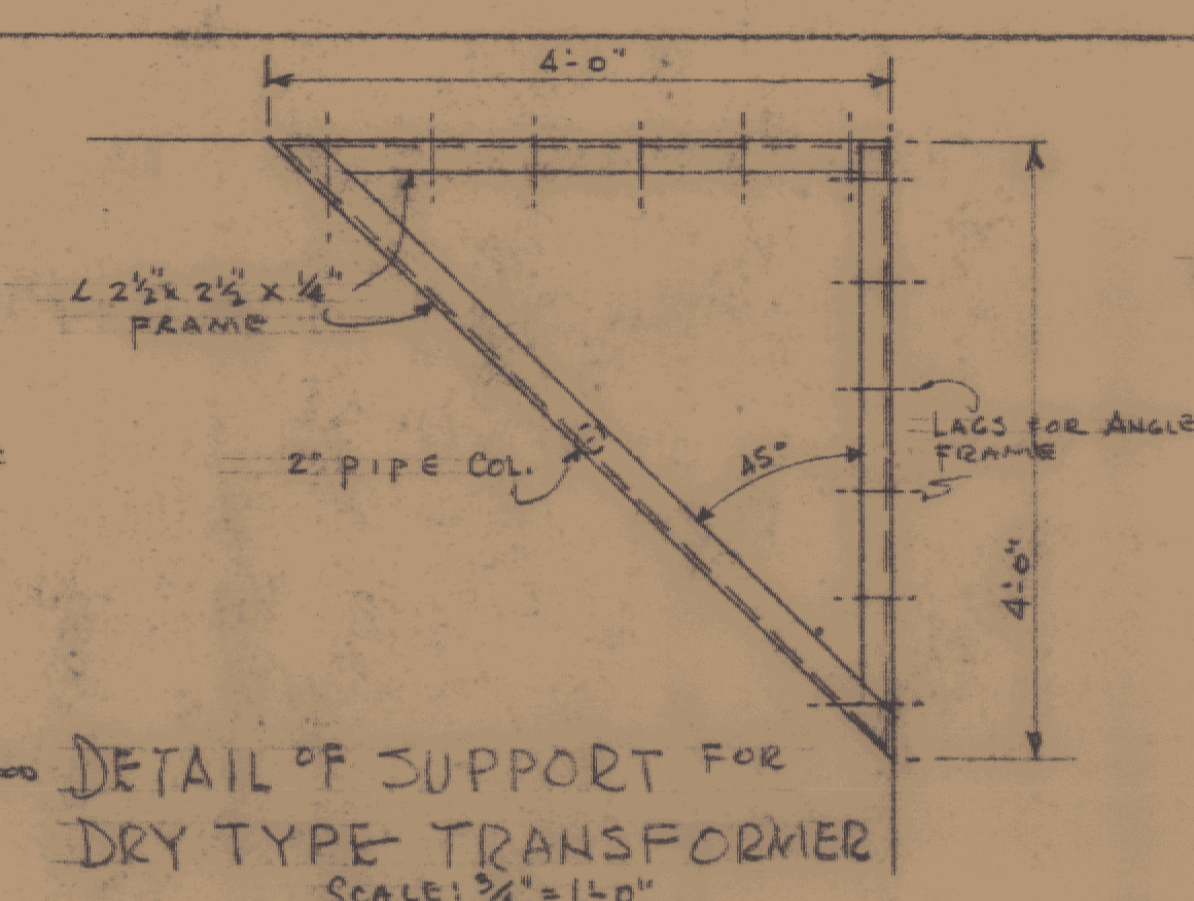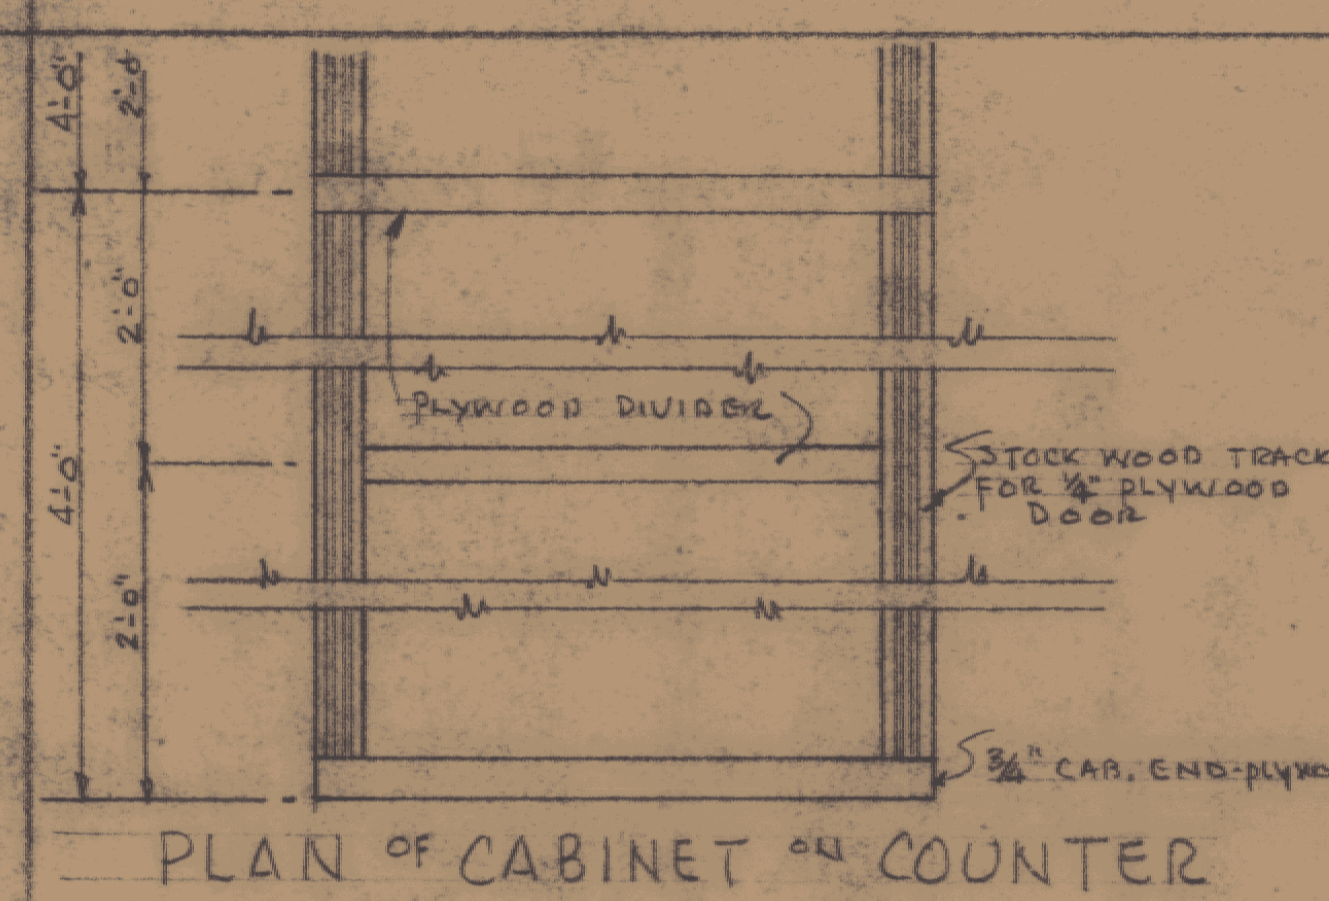

LEGEND FOR



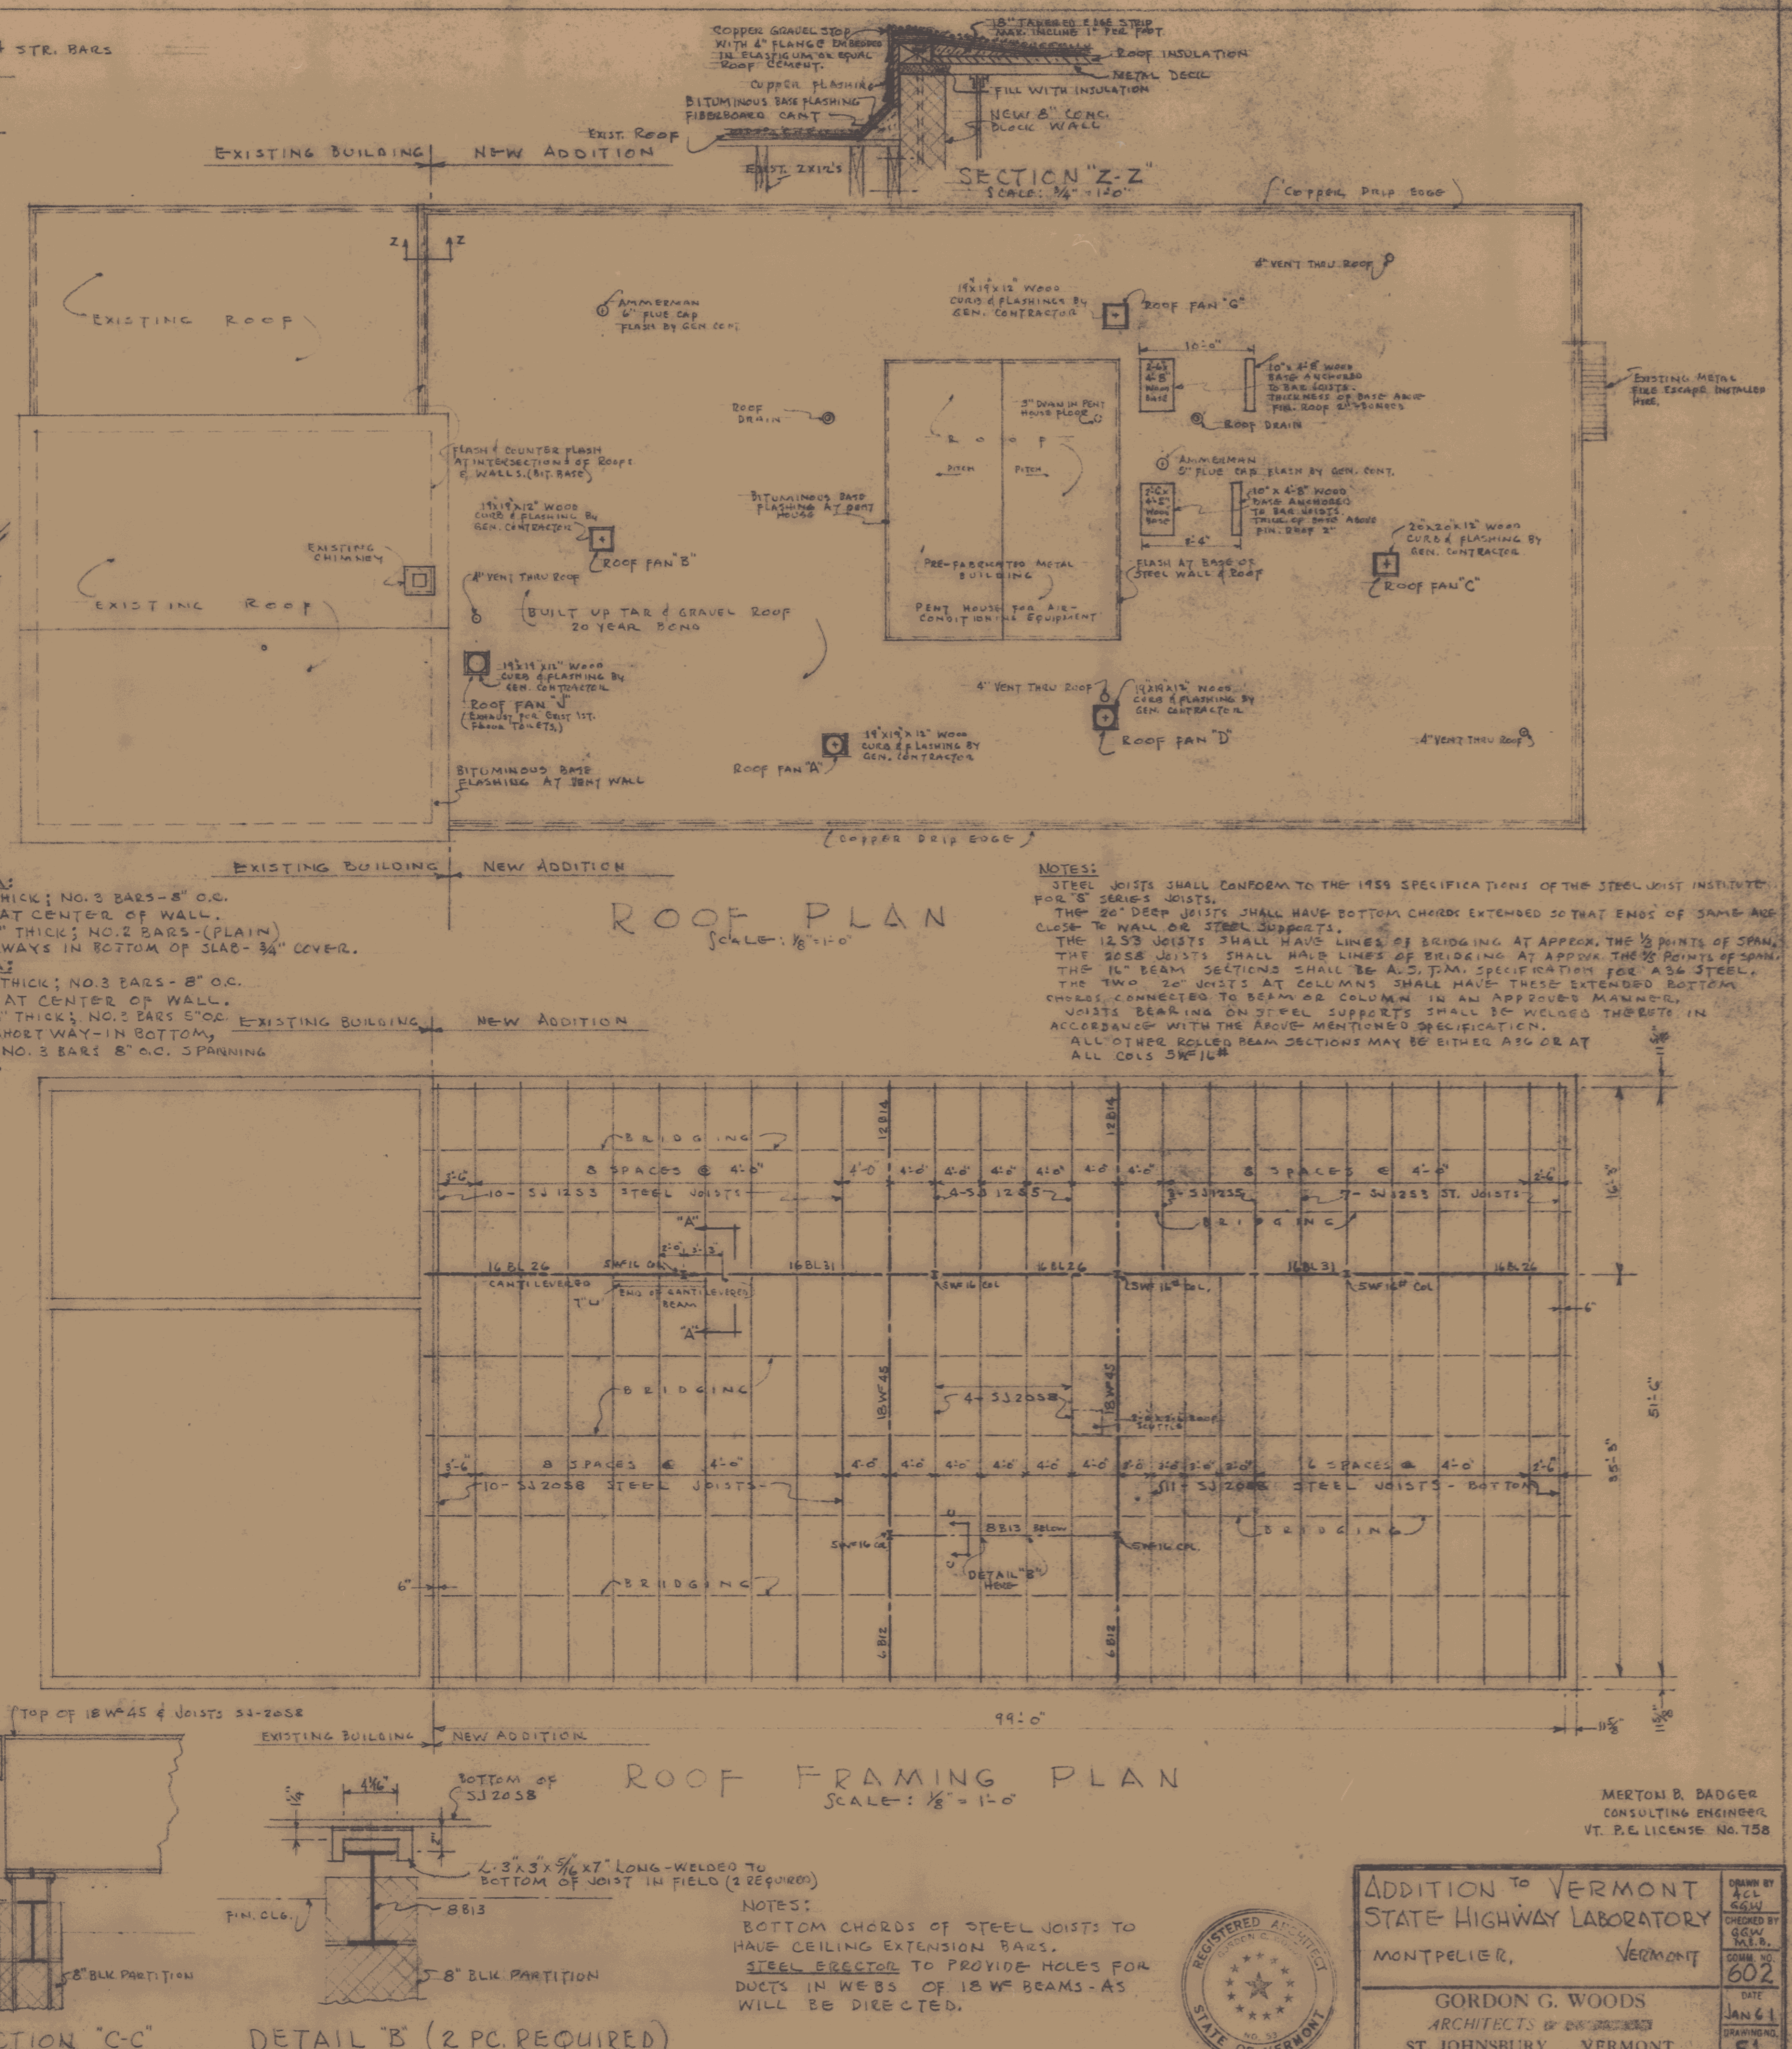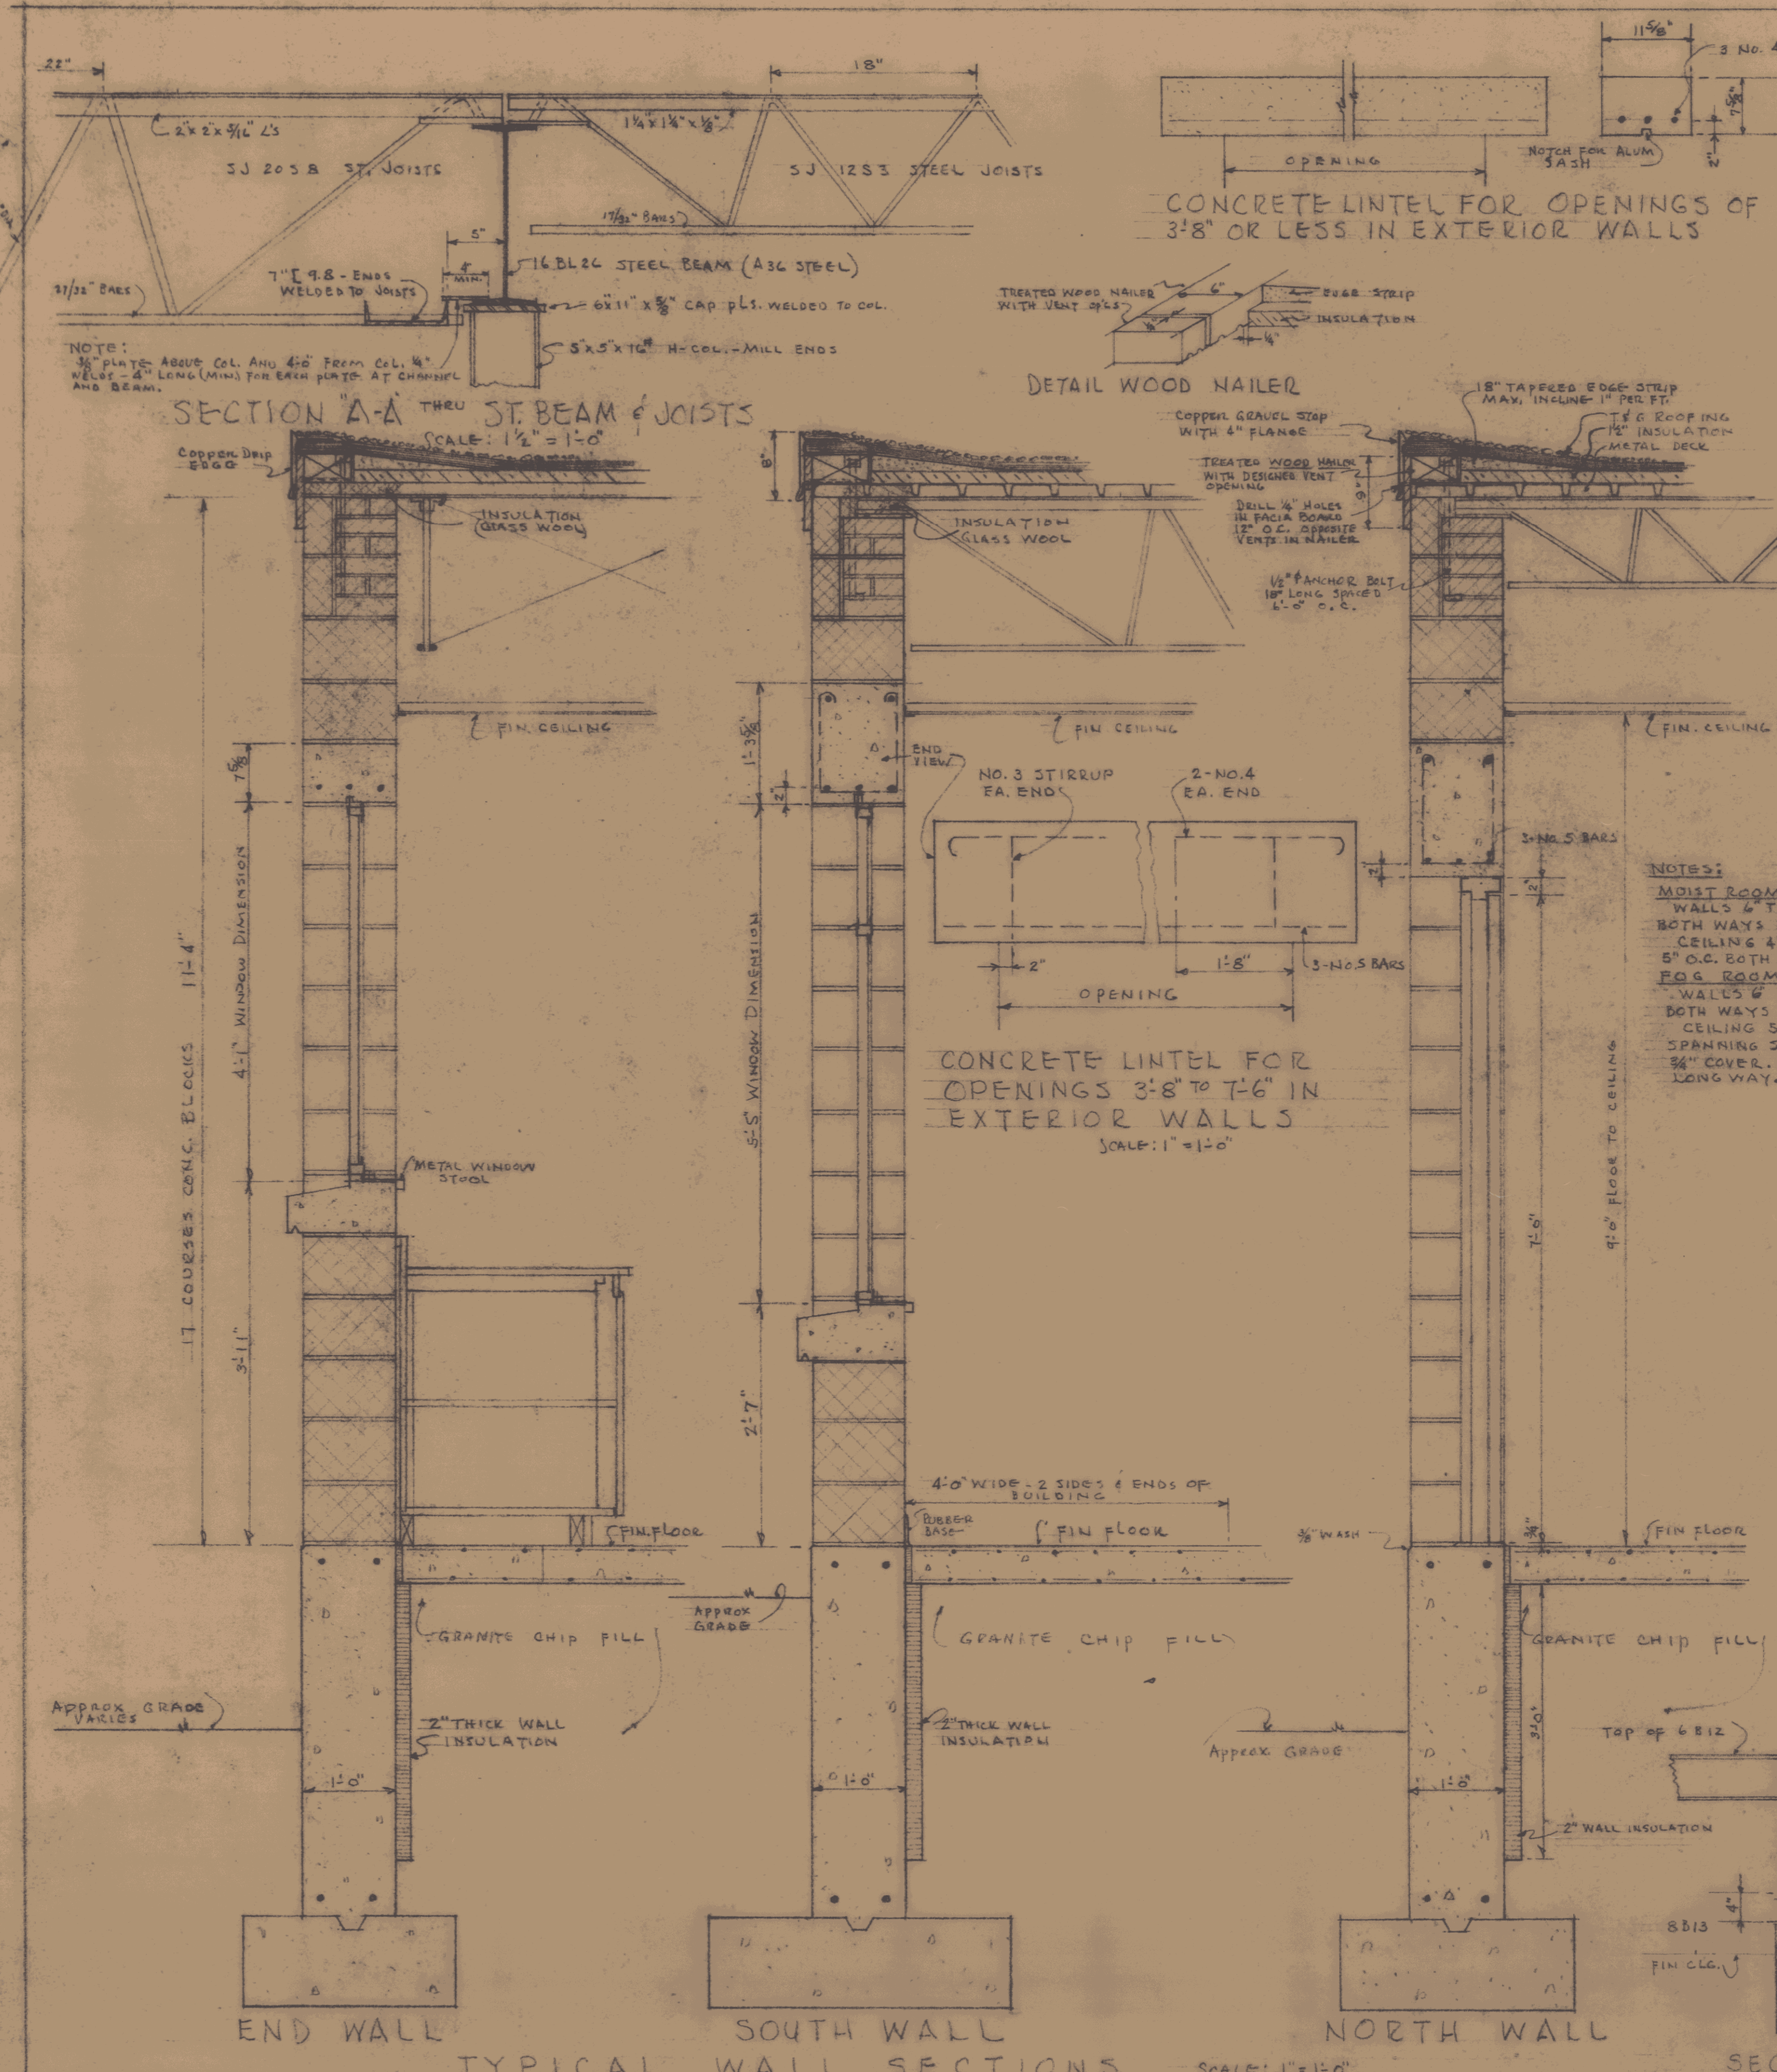


REGISTERED ARCHITECT
STATE OF VERMONT

**ADDITION TO VERMONT
STATE HIGHWAY LABORATORY**
MONTPELIER, VERMONT


GORDON G. WOODS
ARCHITECTS & ENGINEERS
ST. JOHNSBURY, VERMONT

MERTON B. BADGER
CONSULTING ENGINEER
VT. P.E. LICENSE NO. 758


DATE: JAN 61
DRAWING NO: 602
SHEET: 51

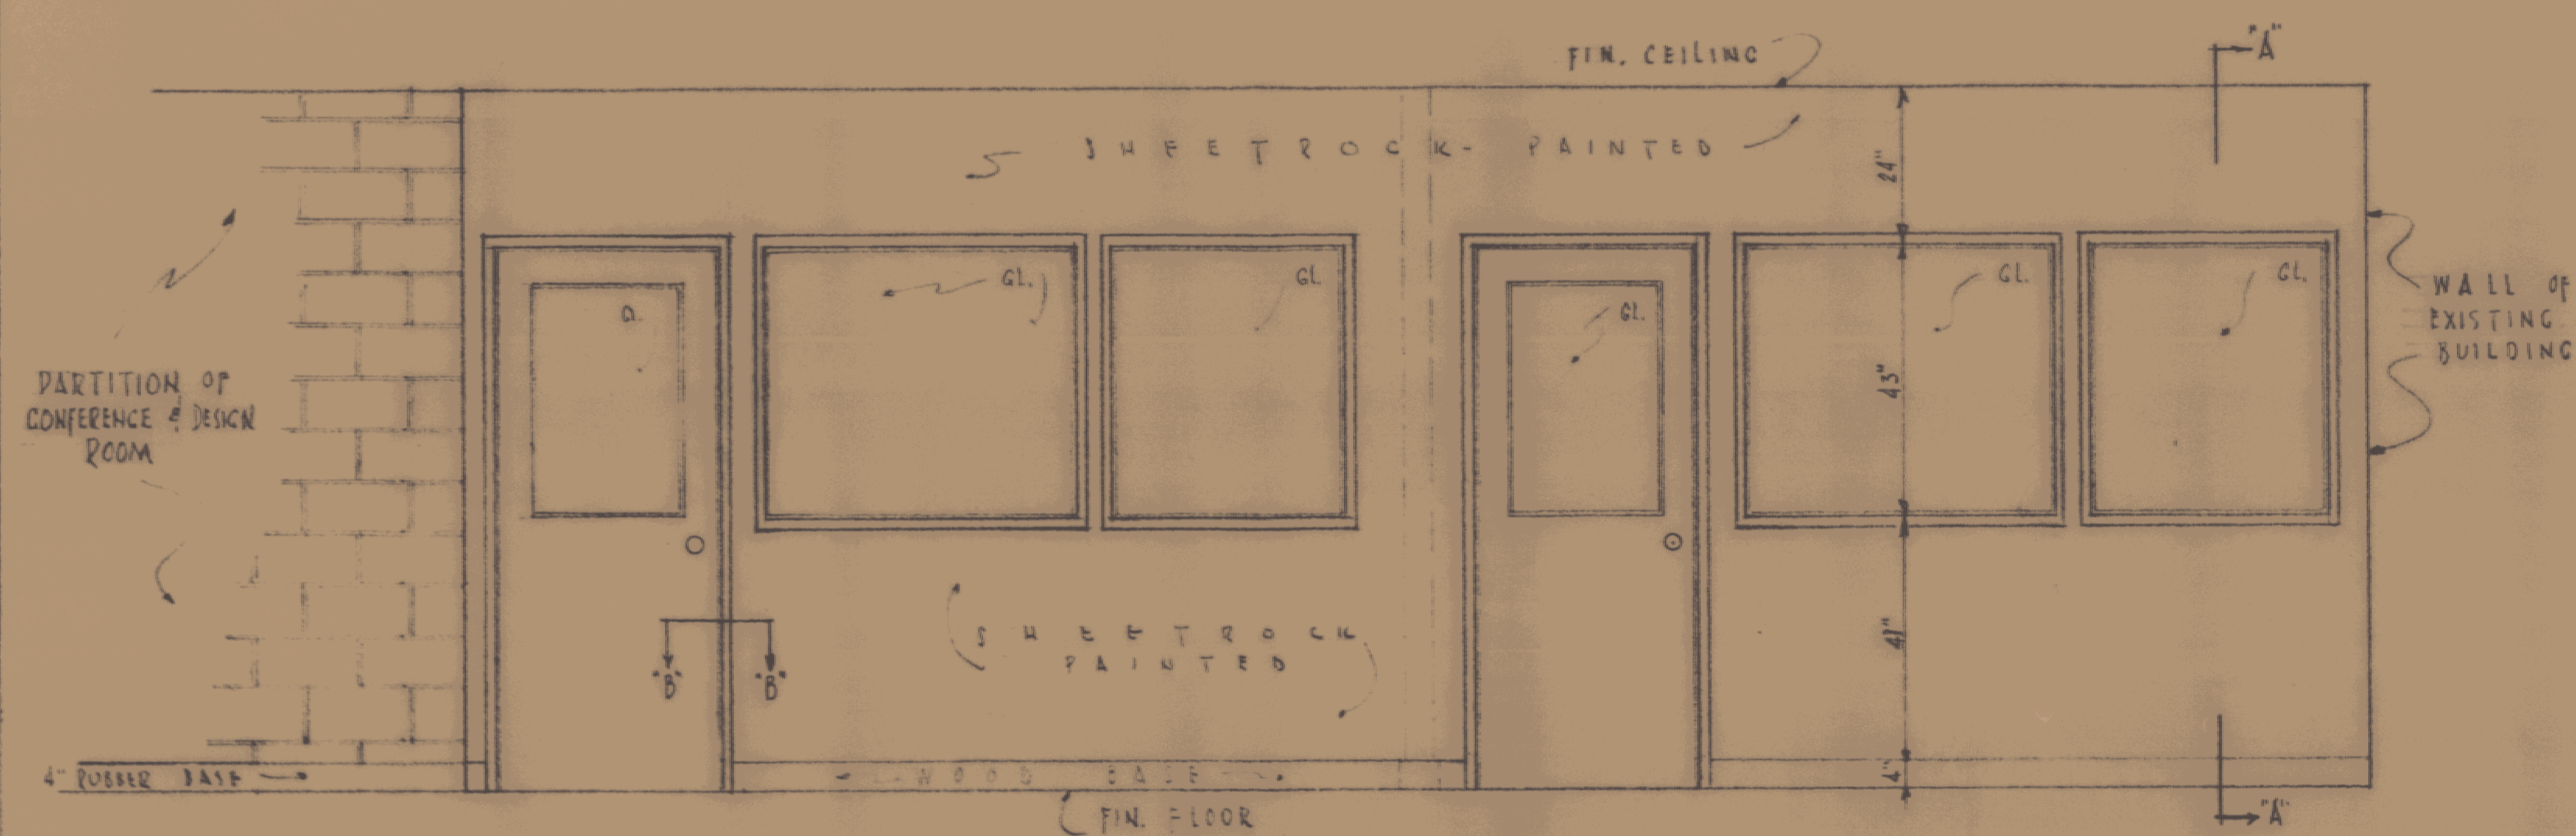


ELEVATION OF WOOD STUD PARTITION
SCALE: 1/2" = 1'-0"

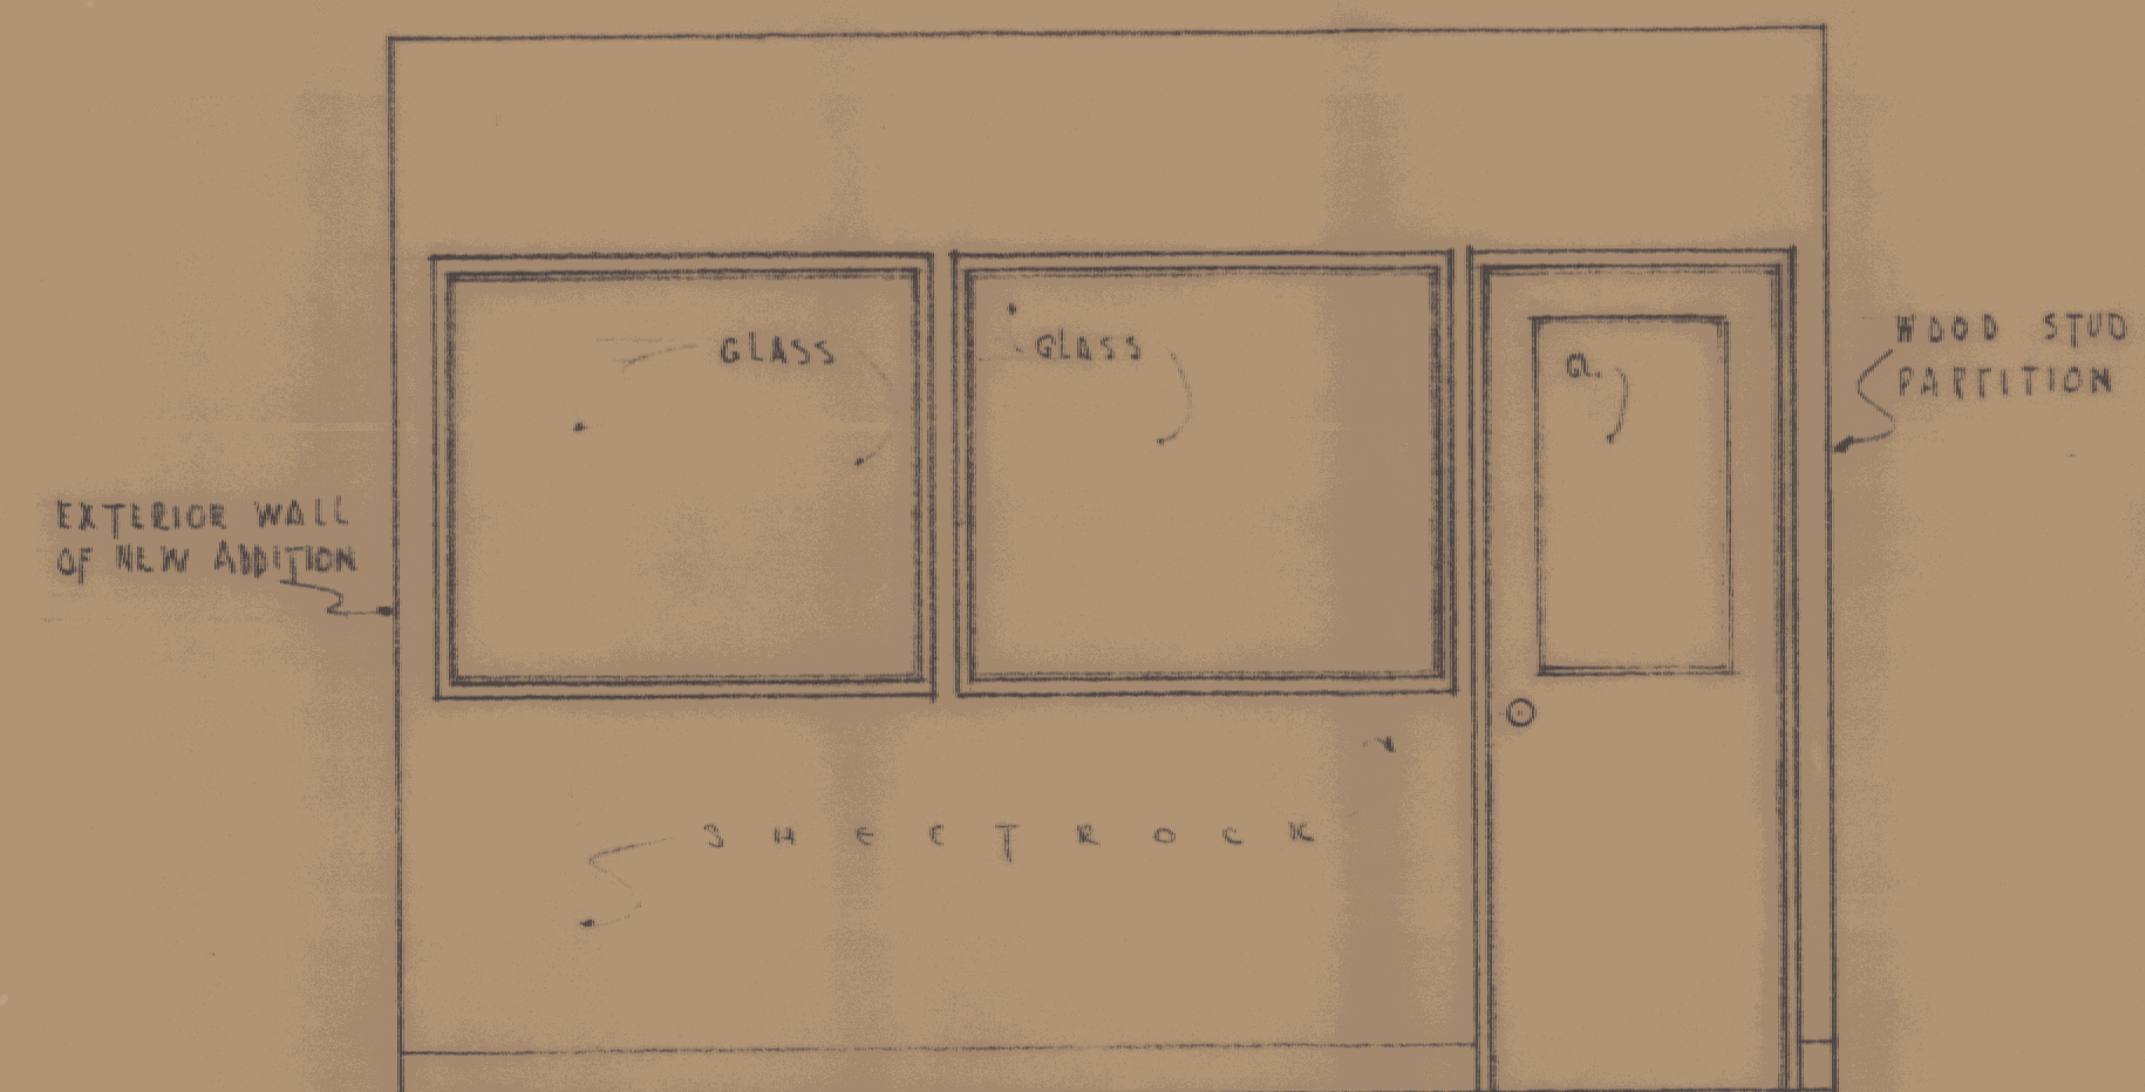


ELEVATION OF PARTITION BETWEEN OFFICE NO 2 & NO 3

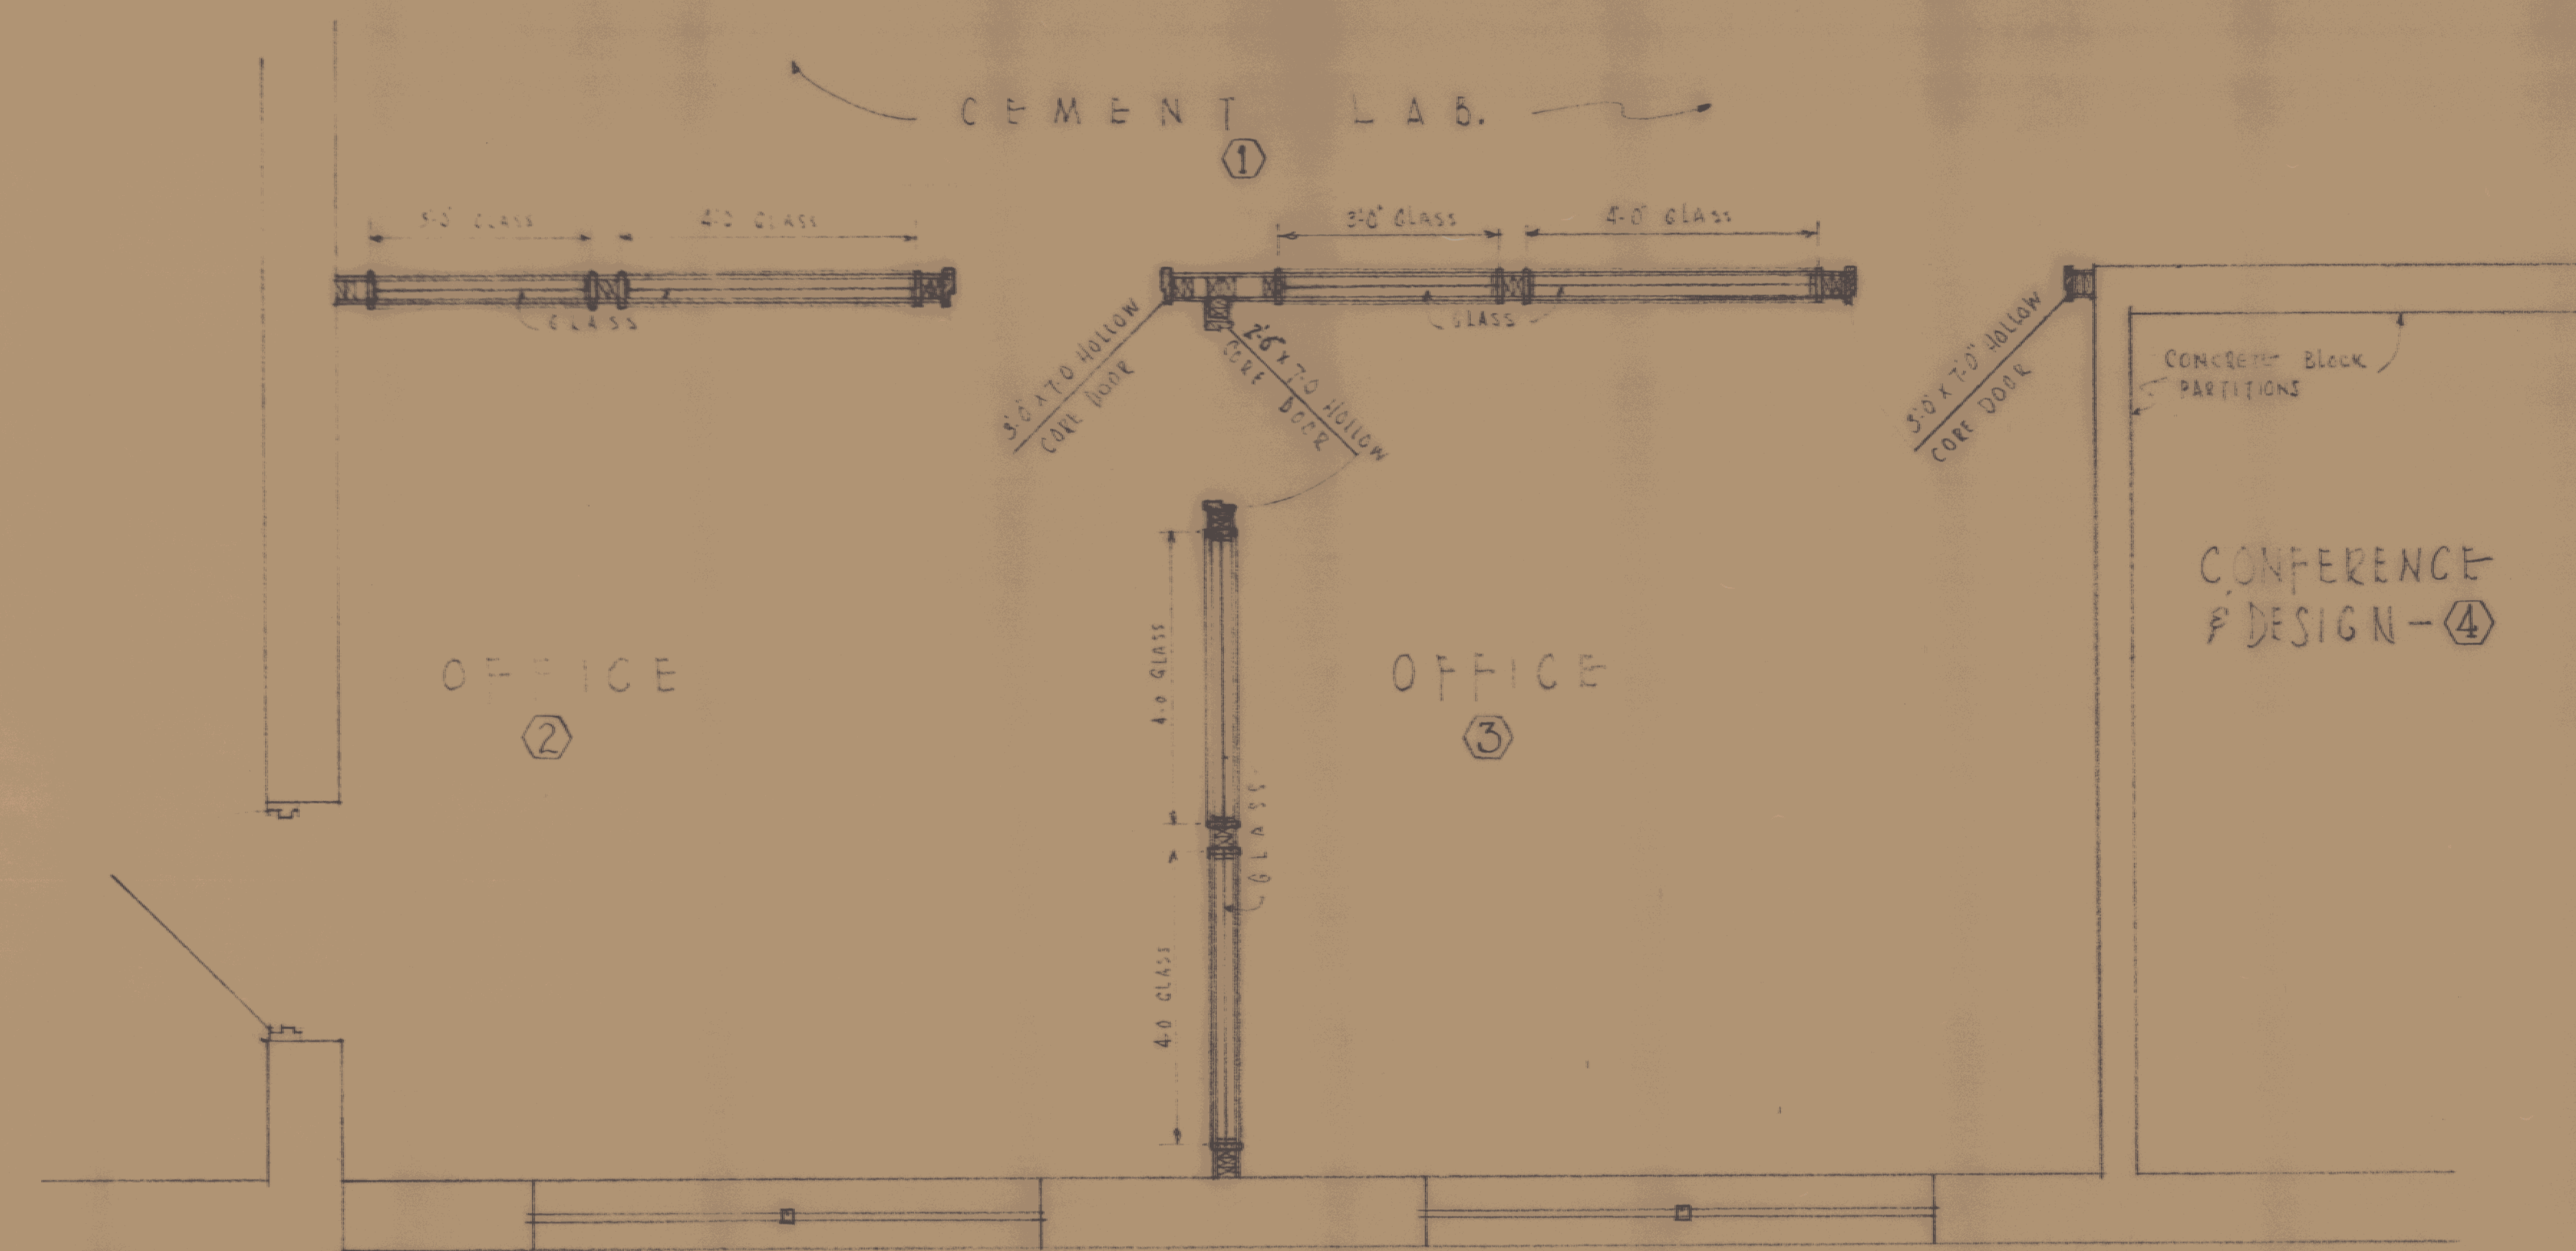

FLOOR PLAN
SCALE: 1/2" = 1'-0"

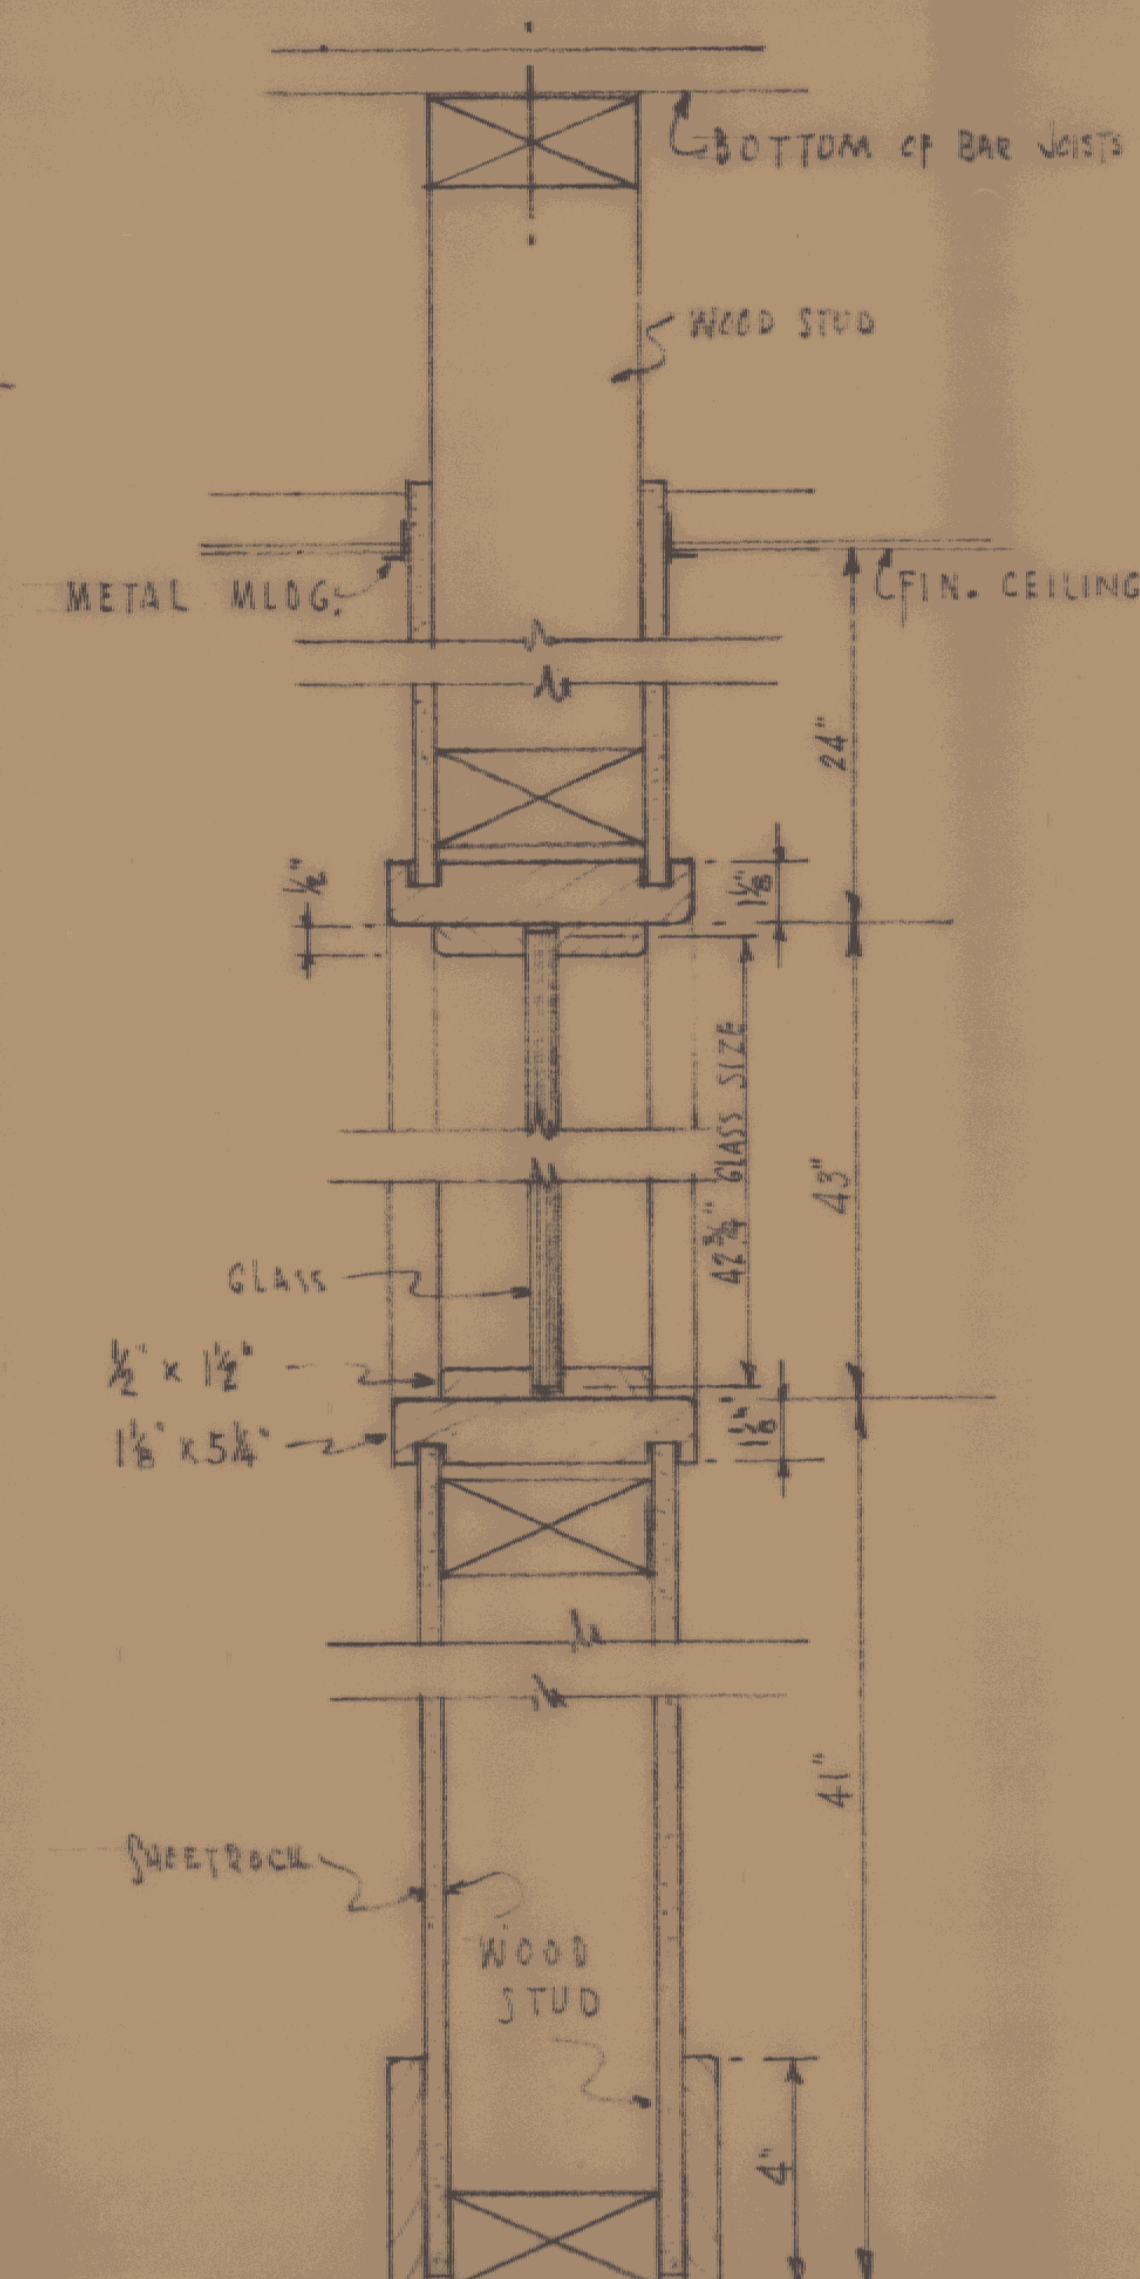


SECTION "A-A"
SCALE: 3" = 1'-0"

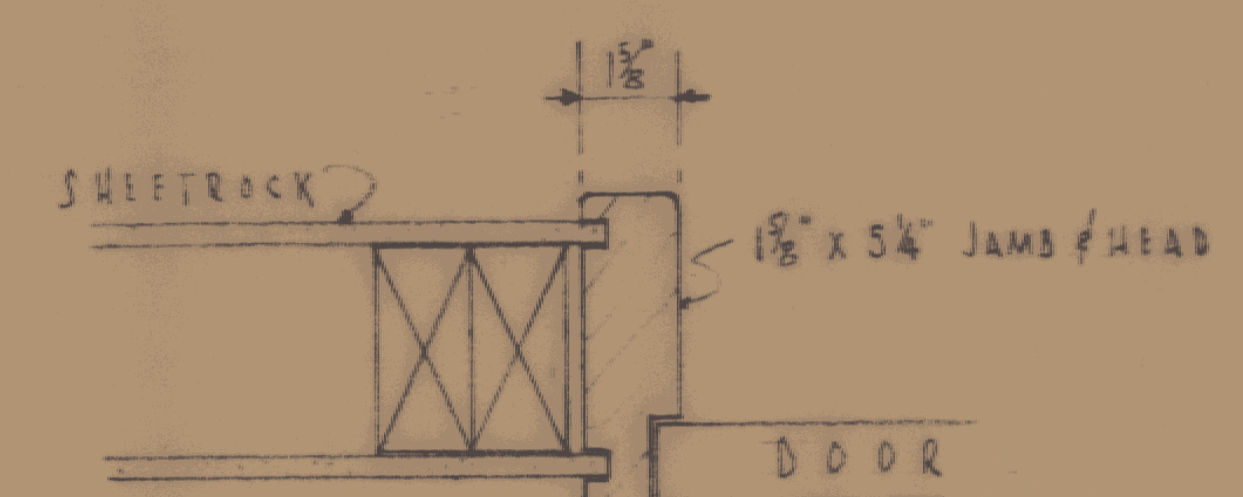


SECTION "B-B"
SCALE: 3" = 1'-0"


ADDITION TO VERMONT STATE HIGHWAY LABORATORY		DRAWN BY G.W.
MONTPELIER, VERMONT		CHECKED BY G.W.
GORDON G. WOODS ARCHITECTS		DATE FEB 62
ST. JOHNSBURY, VERMONT		PROJECT NO. 51

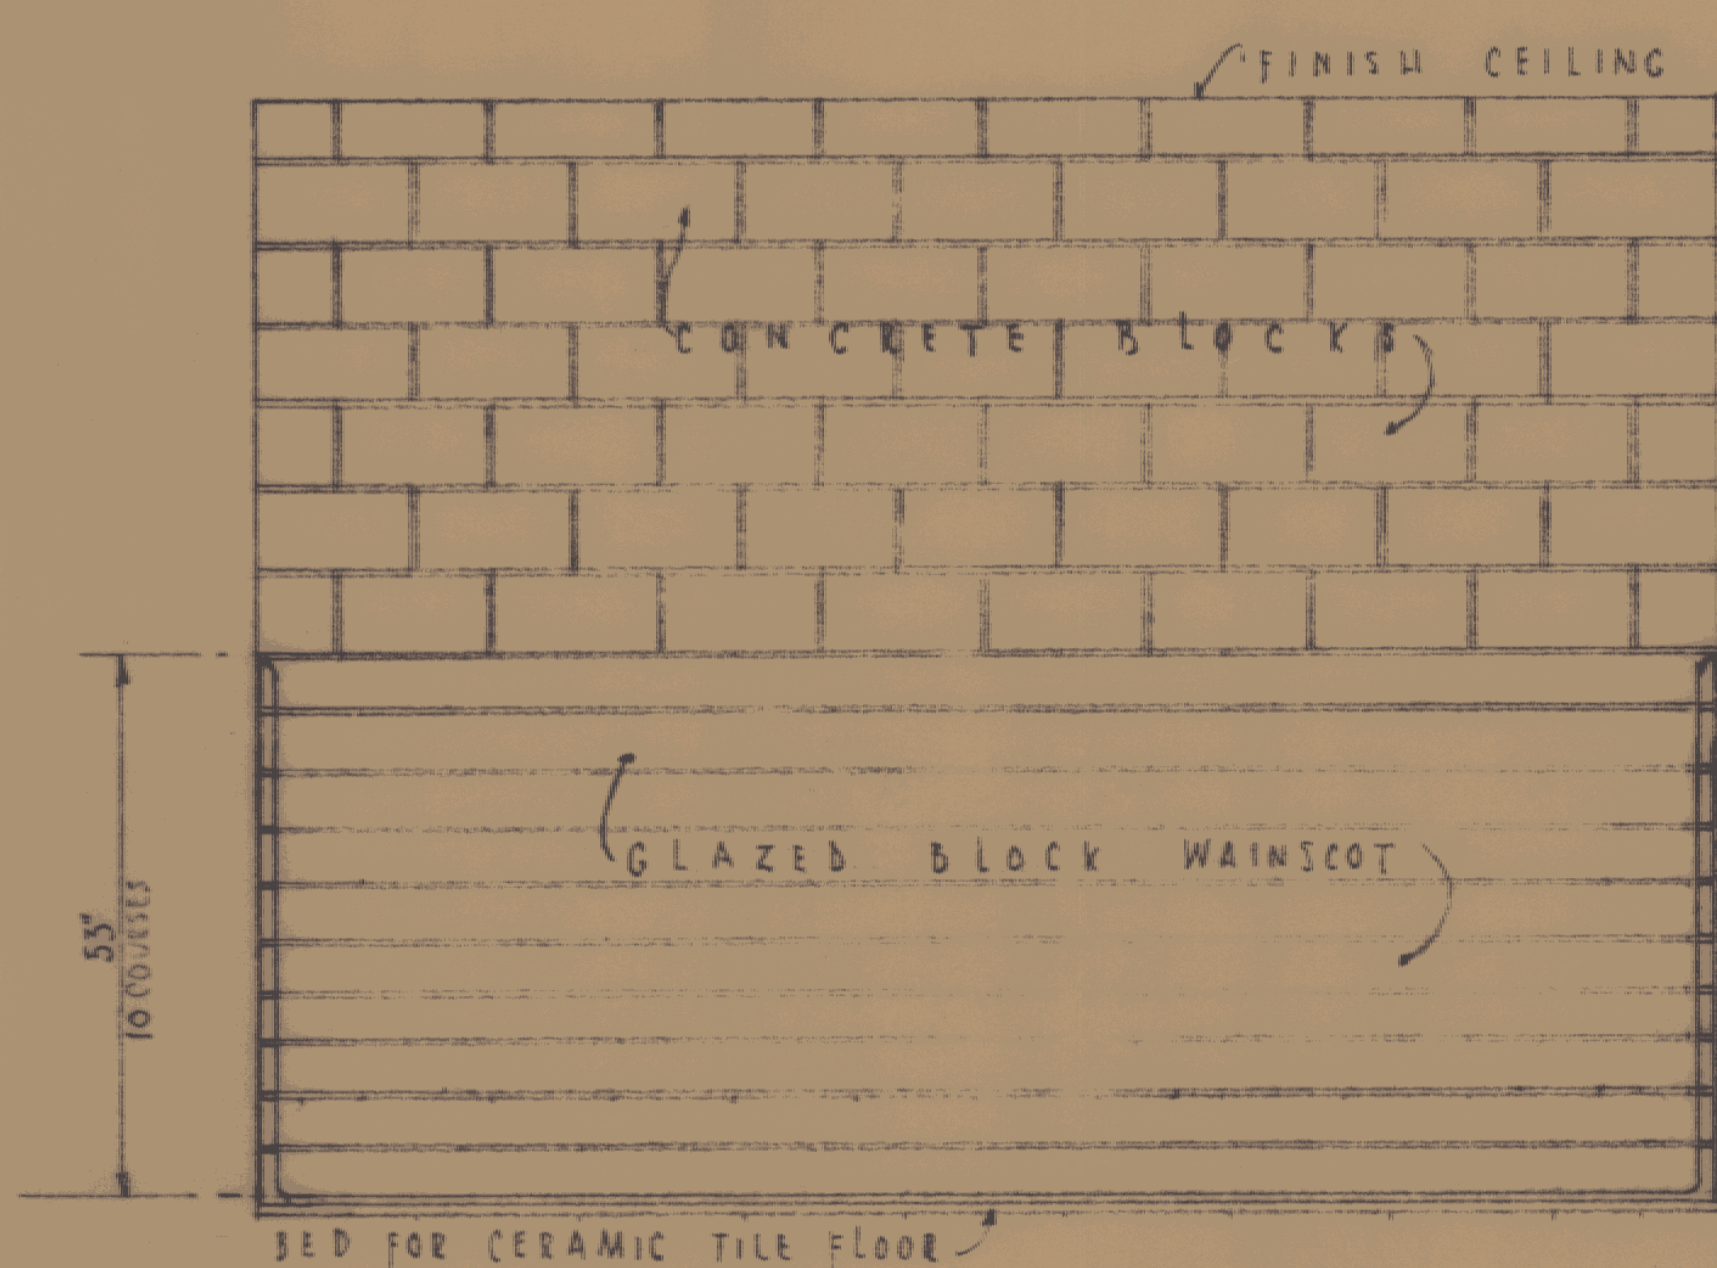


ELEV. OF LOCKER WALL

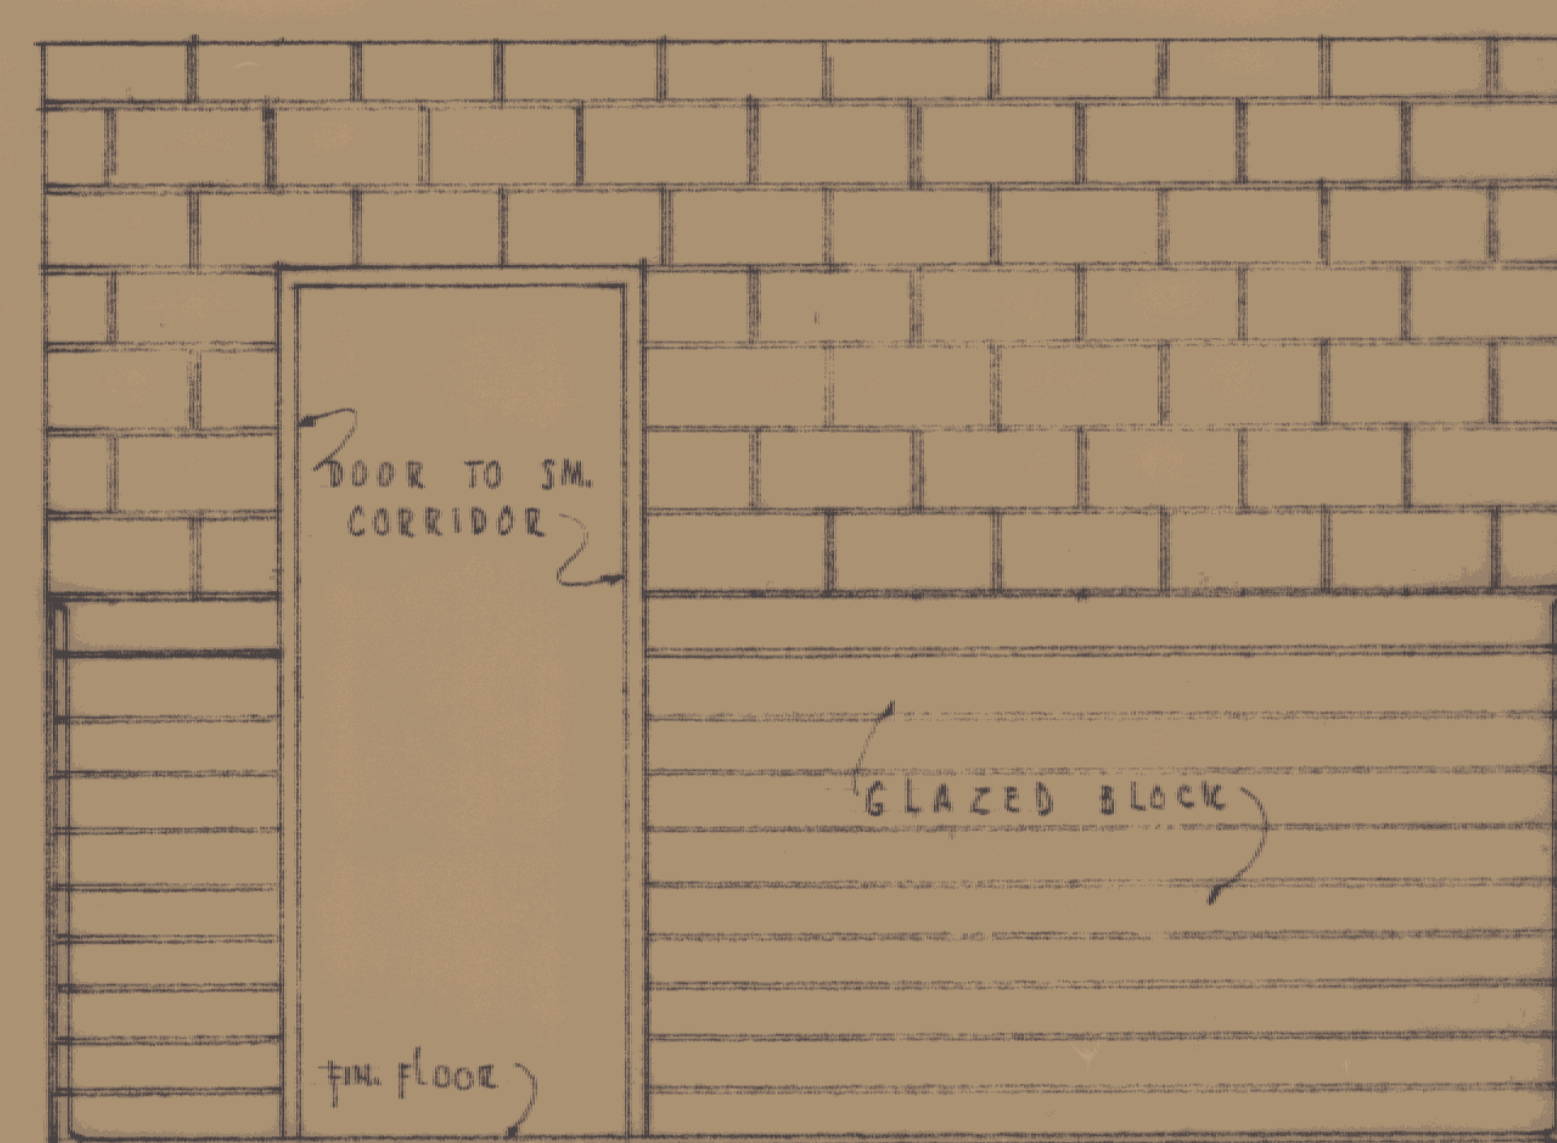

ELEV. OF DOOR WALL

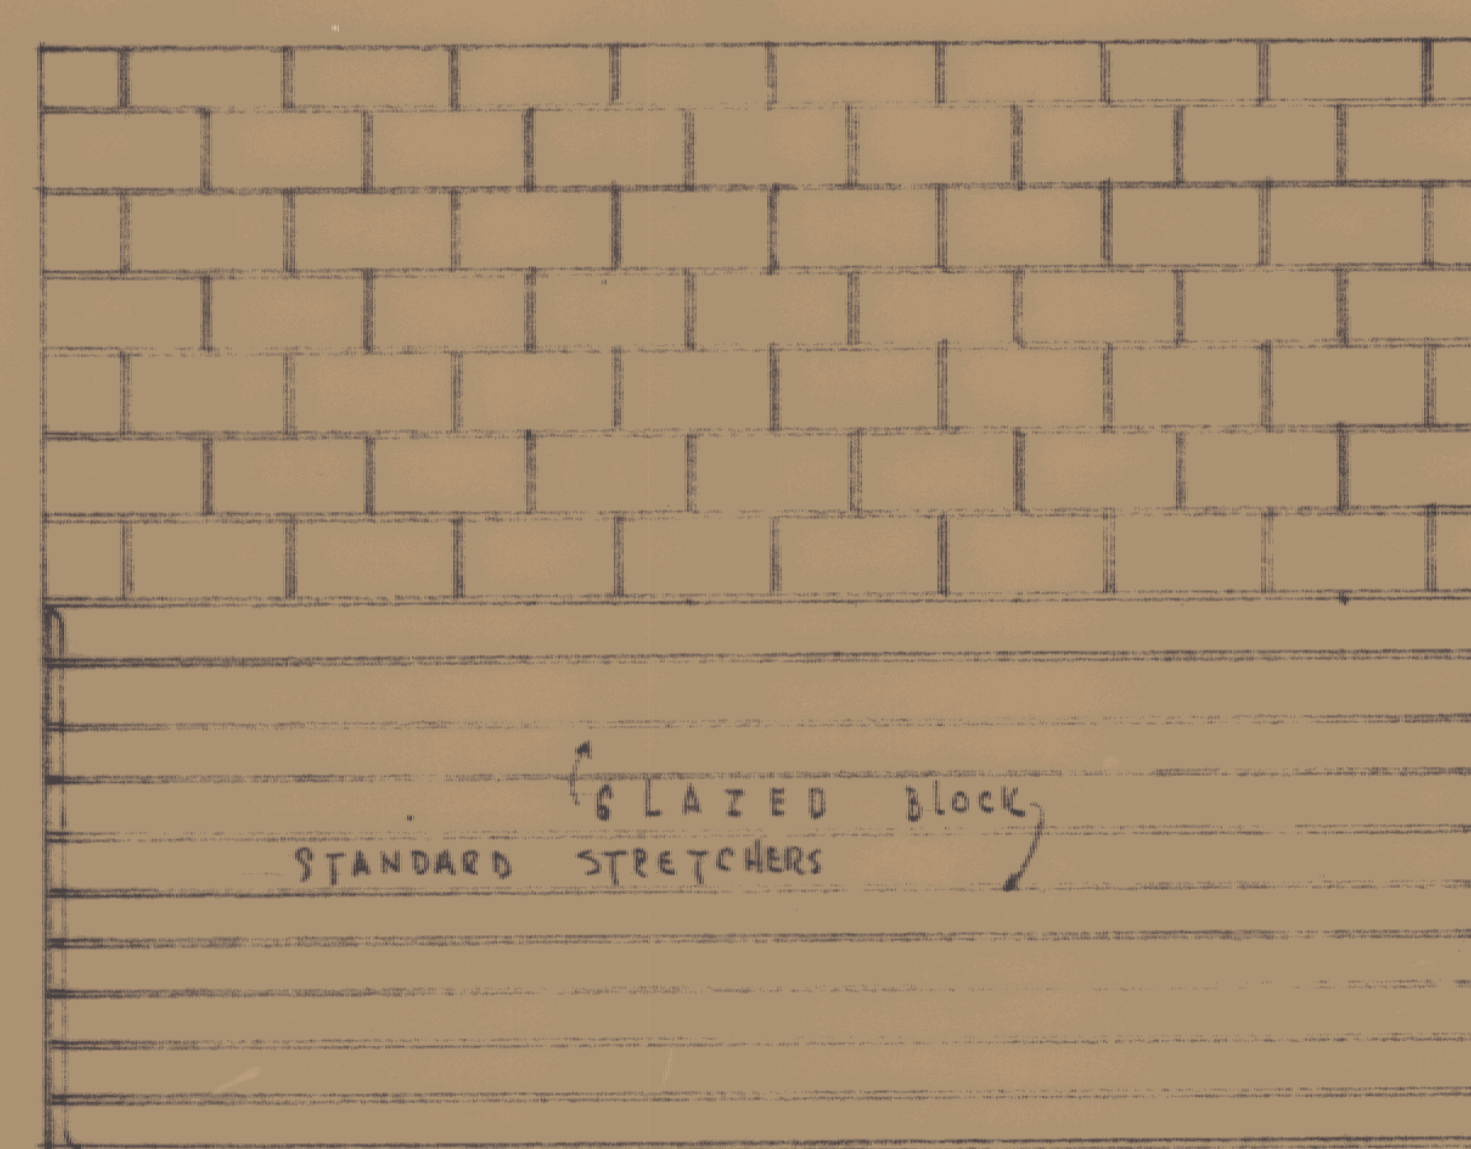


ELEV. OF FIXTURE WALL

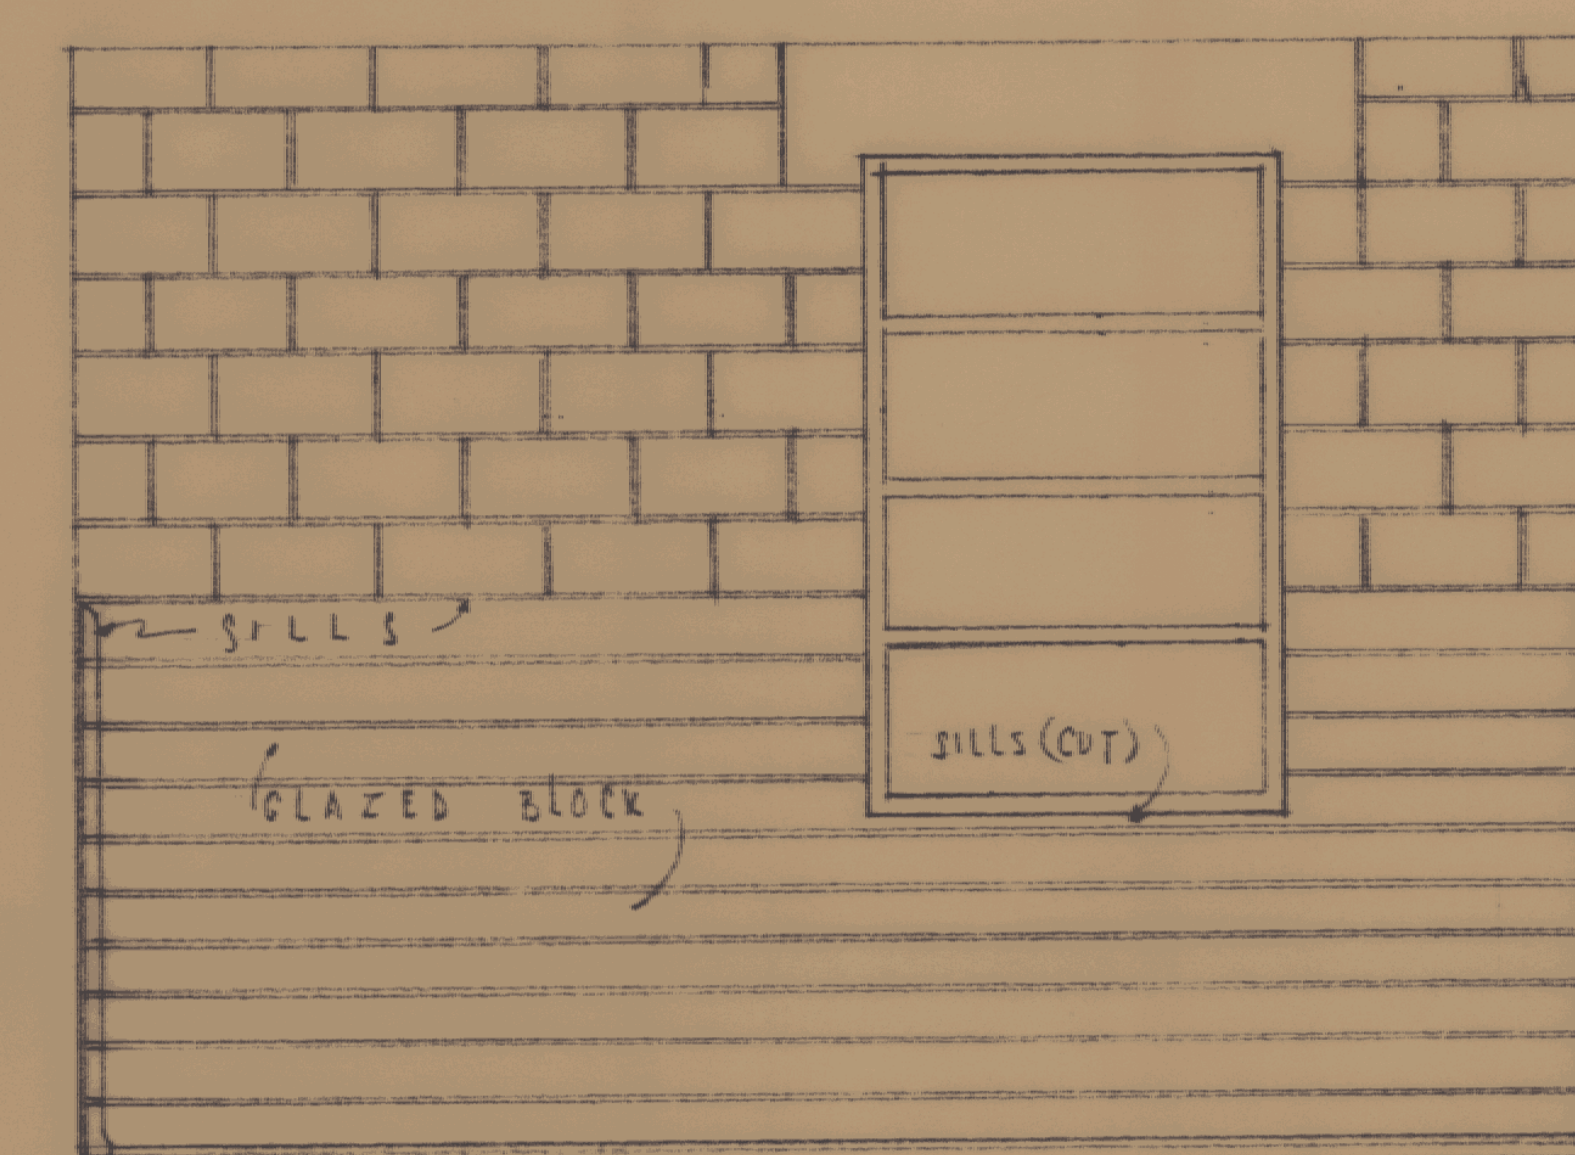

ELEV. OF WINDOW WALL

SCALE: 1/2" = 1'-0"

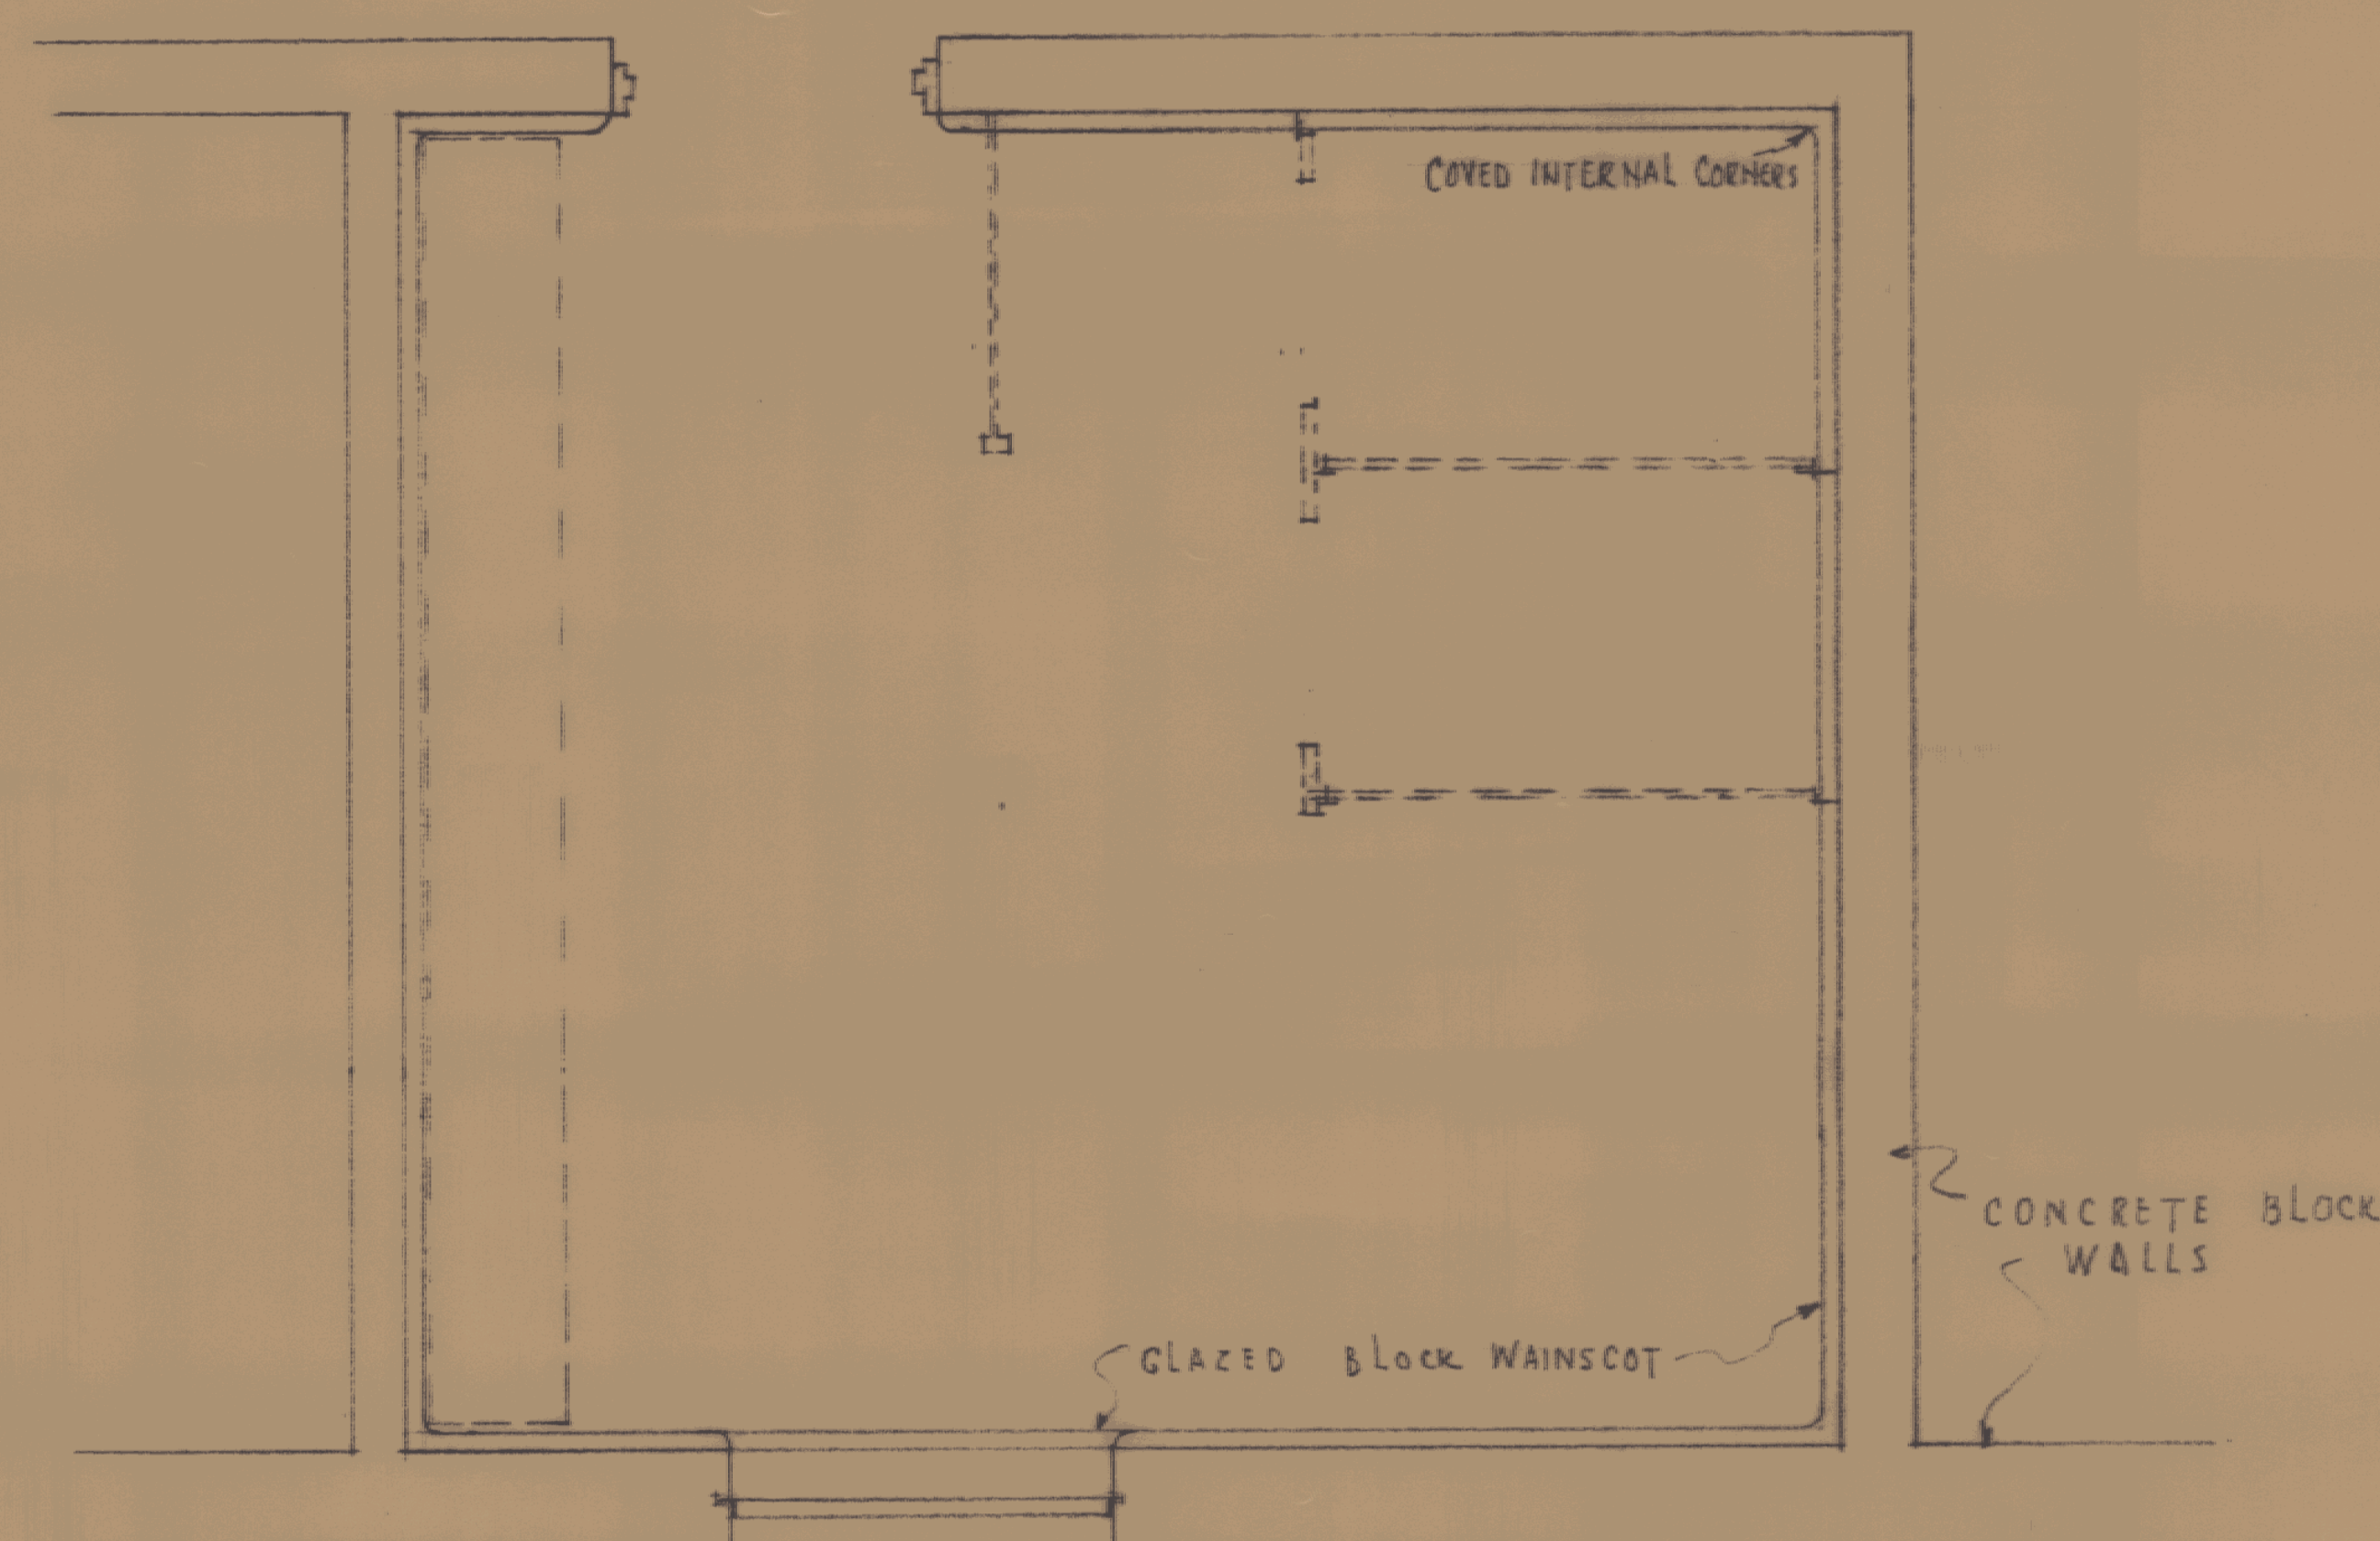


TOILET & LOCKER ROOM FLOOR PLAN - ⑤

SCALE: 1/2" = 1'-0"

SCALED DRAWING FOR GLAZED BLOCK WAINSCOT
IN TOILET AND LOCKER ROOM. NO. 5

PROGRESS PRINT 2/27/62

ADDITION TO VERMONT STATE HIGHWAY LABORATORY MONTPELIER, VERMONT		DRAWN BY G.W. CHECKED BY DATE FEB 62 DRAWING NO. 52
GORDON G. WOODS ARCHITECTS ST. JOHNSBURY, VERMONT		

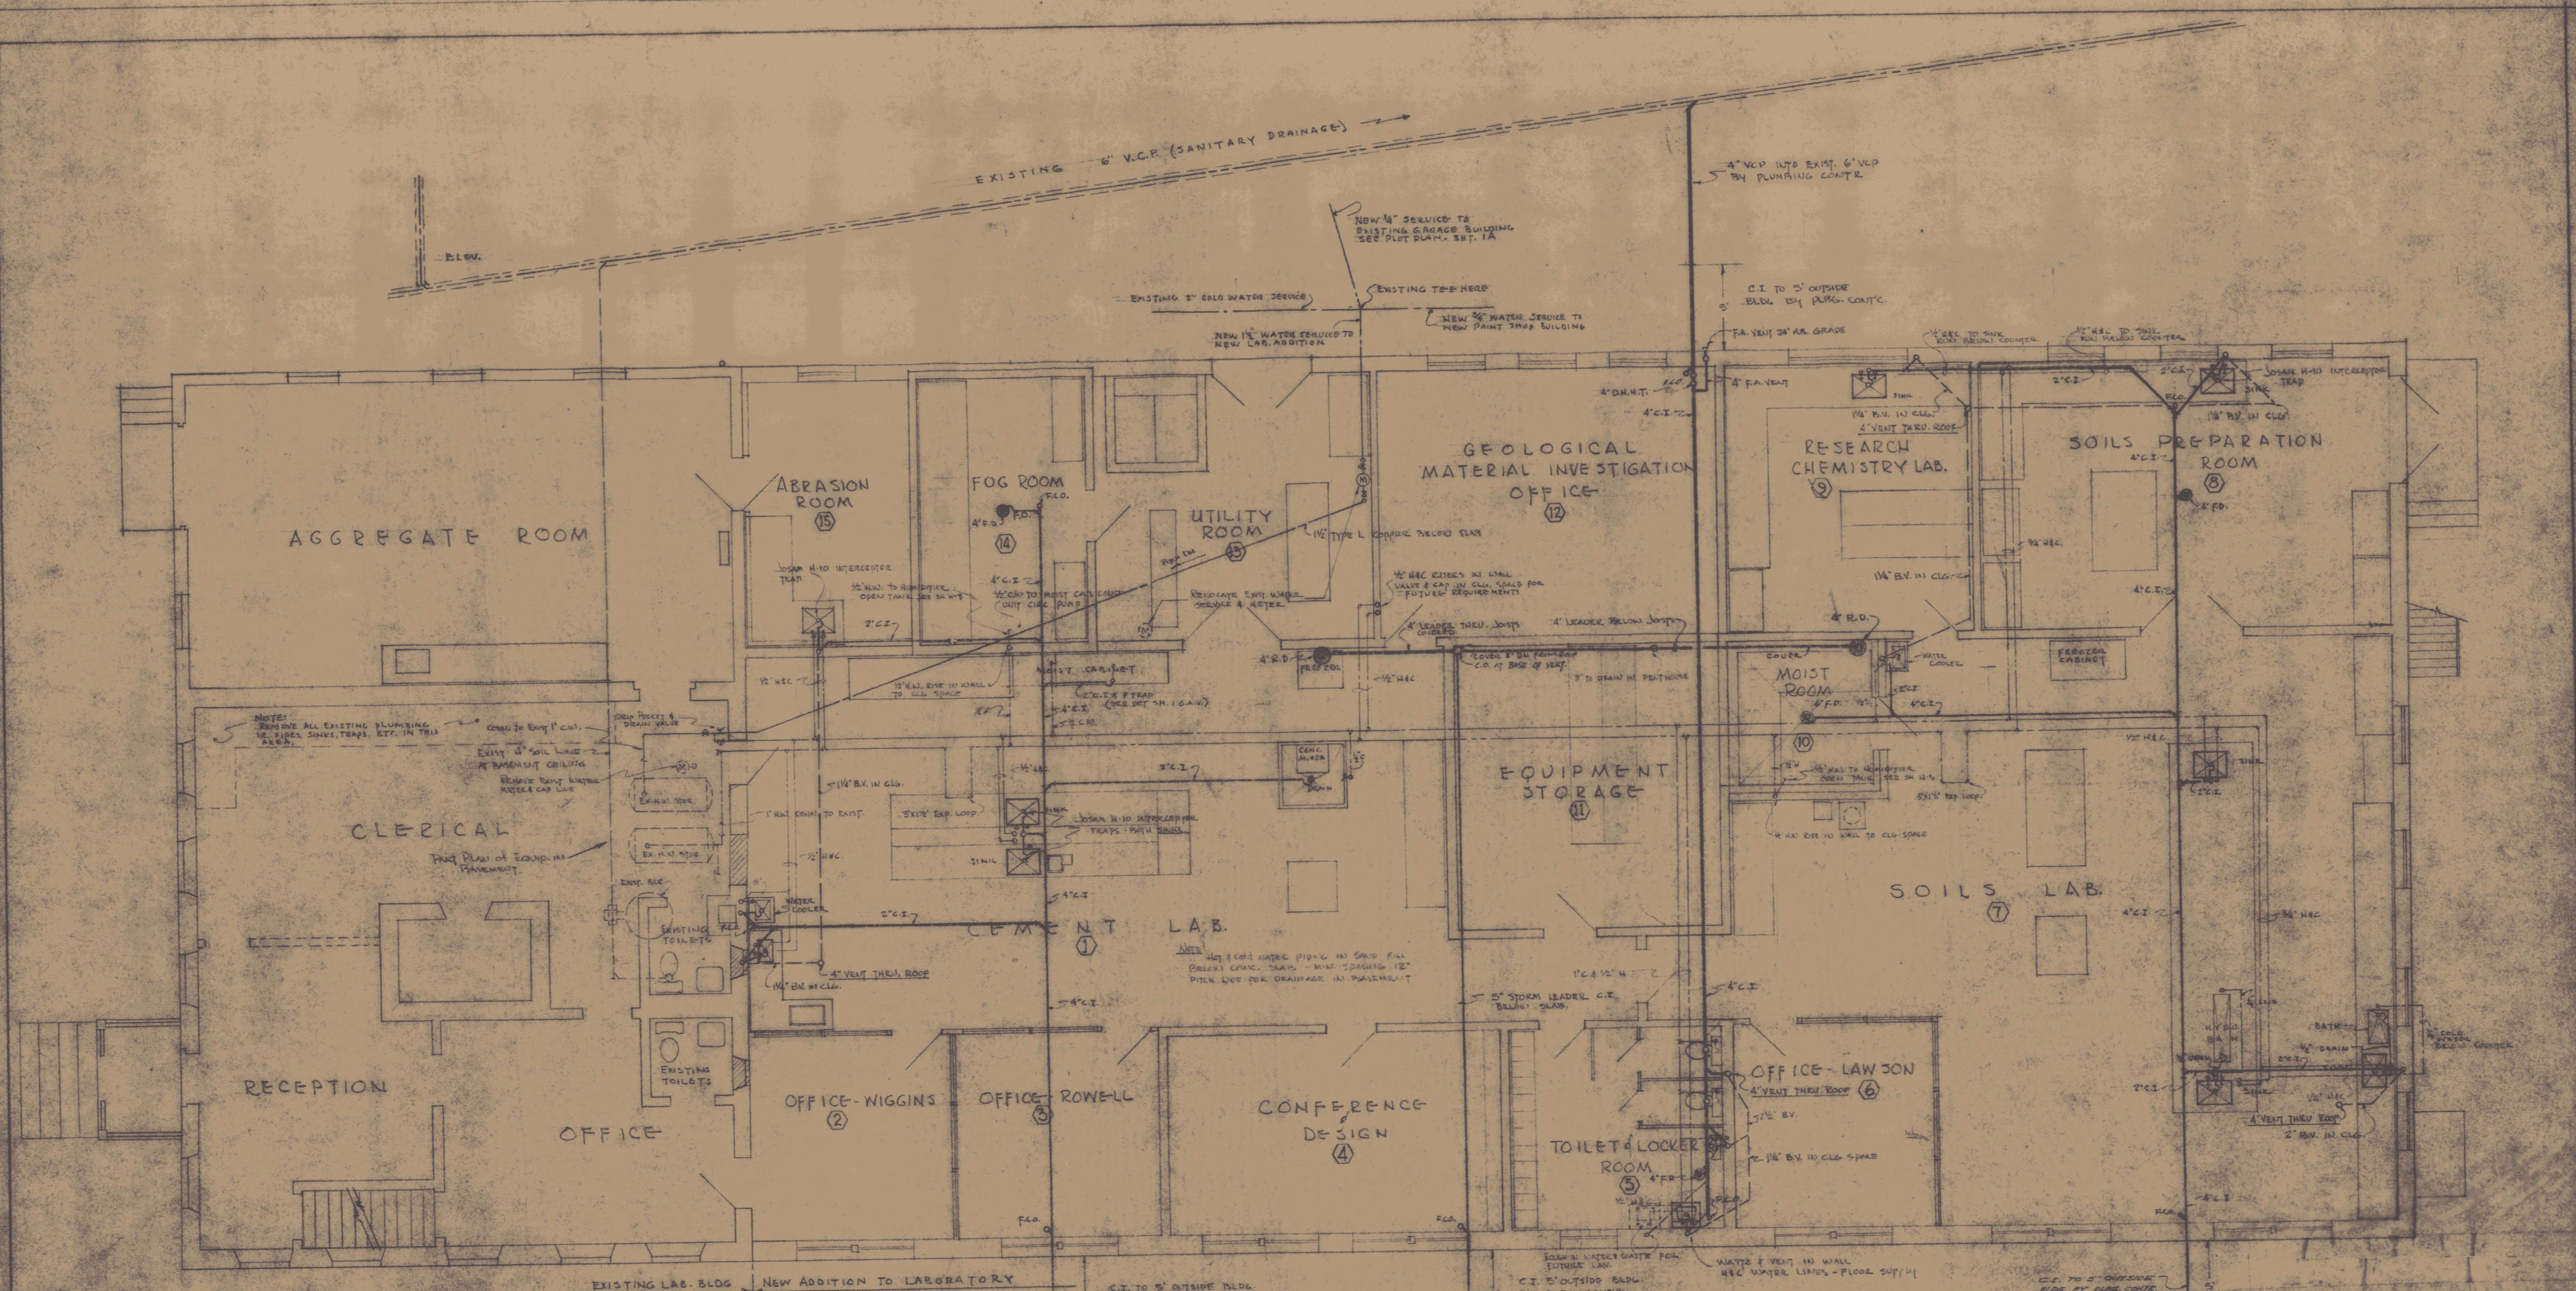

FIXTURE SCHEDULE

FIXTURES	SOIL	WASTE	TRAPS	VENT	TRAP
WATER FLOORS	4"				INT.
BATHS	2"	1"	1 1/2"	1 1/2"	INT.
LAVATORY	1 1/2"	1 1/2"	1 1/2"	1 1/2"	INT.
HYD. BATH	1 1/2"	1 1/2"	1 1/2"	1 1/2"	INT.
BATH	1 1/2"	1 1/2"	1 1/2"	1 1/2"	INT.
DRINK FOUNTAIN	1 1/2"	1 1/2"	1 1/2"	1 1/2"	INT.
LAB. SINK	1 1/2"	1 1/2"	1 1/2"	1 1/2"	INT.


FIRST FLOOR PLAN - PLUMBING
 SCALE: 1/4" = 1'-0"



JENNISON ENGINEERING INC.
 25 COLLEGE ST. BURLINGTON, VT.

**ADDITION TO VERMONT
 STATE HIGHWAY LABORATORY**
 MONT PELLEE, VERMONT


GORDON G. WOODS
 REGISTERED PROFESSIONAL ENGINEER
 ST. JOHNSBURY, VERMONT

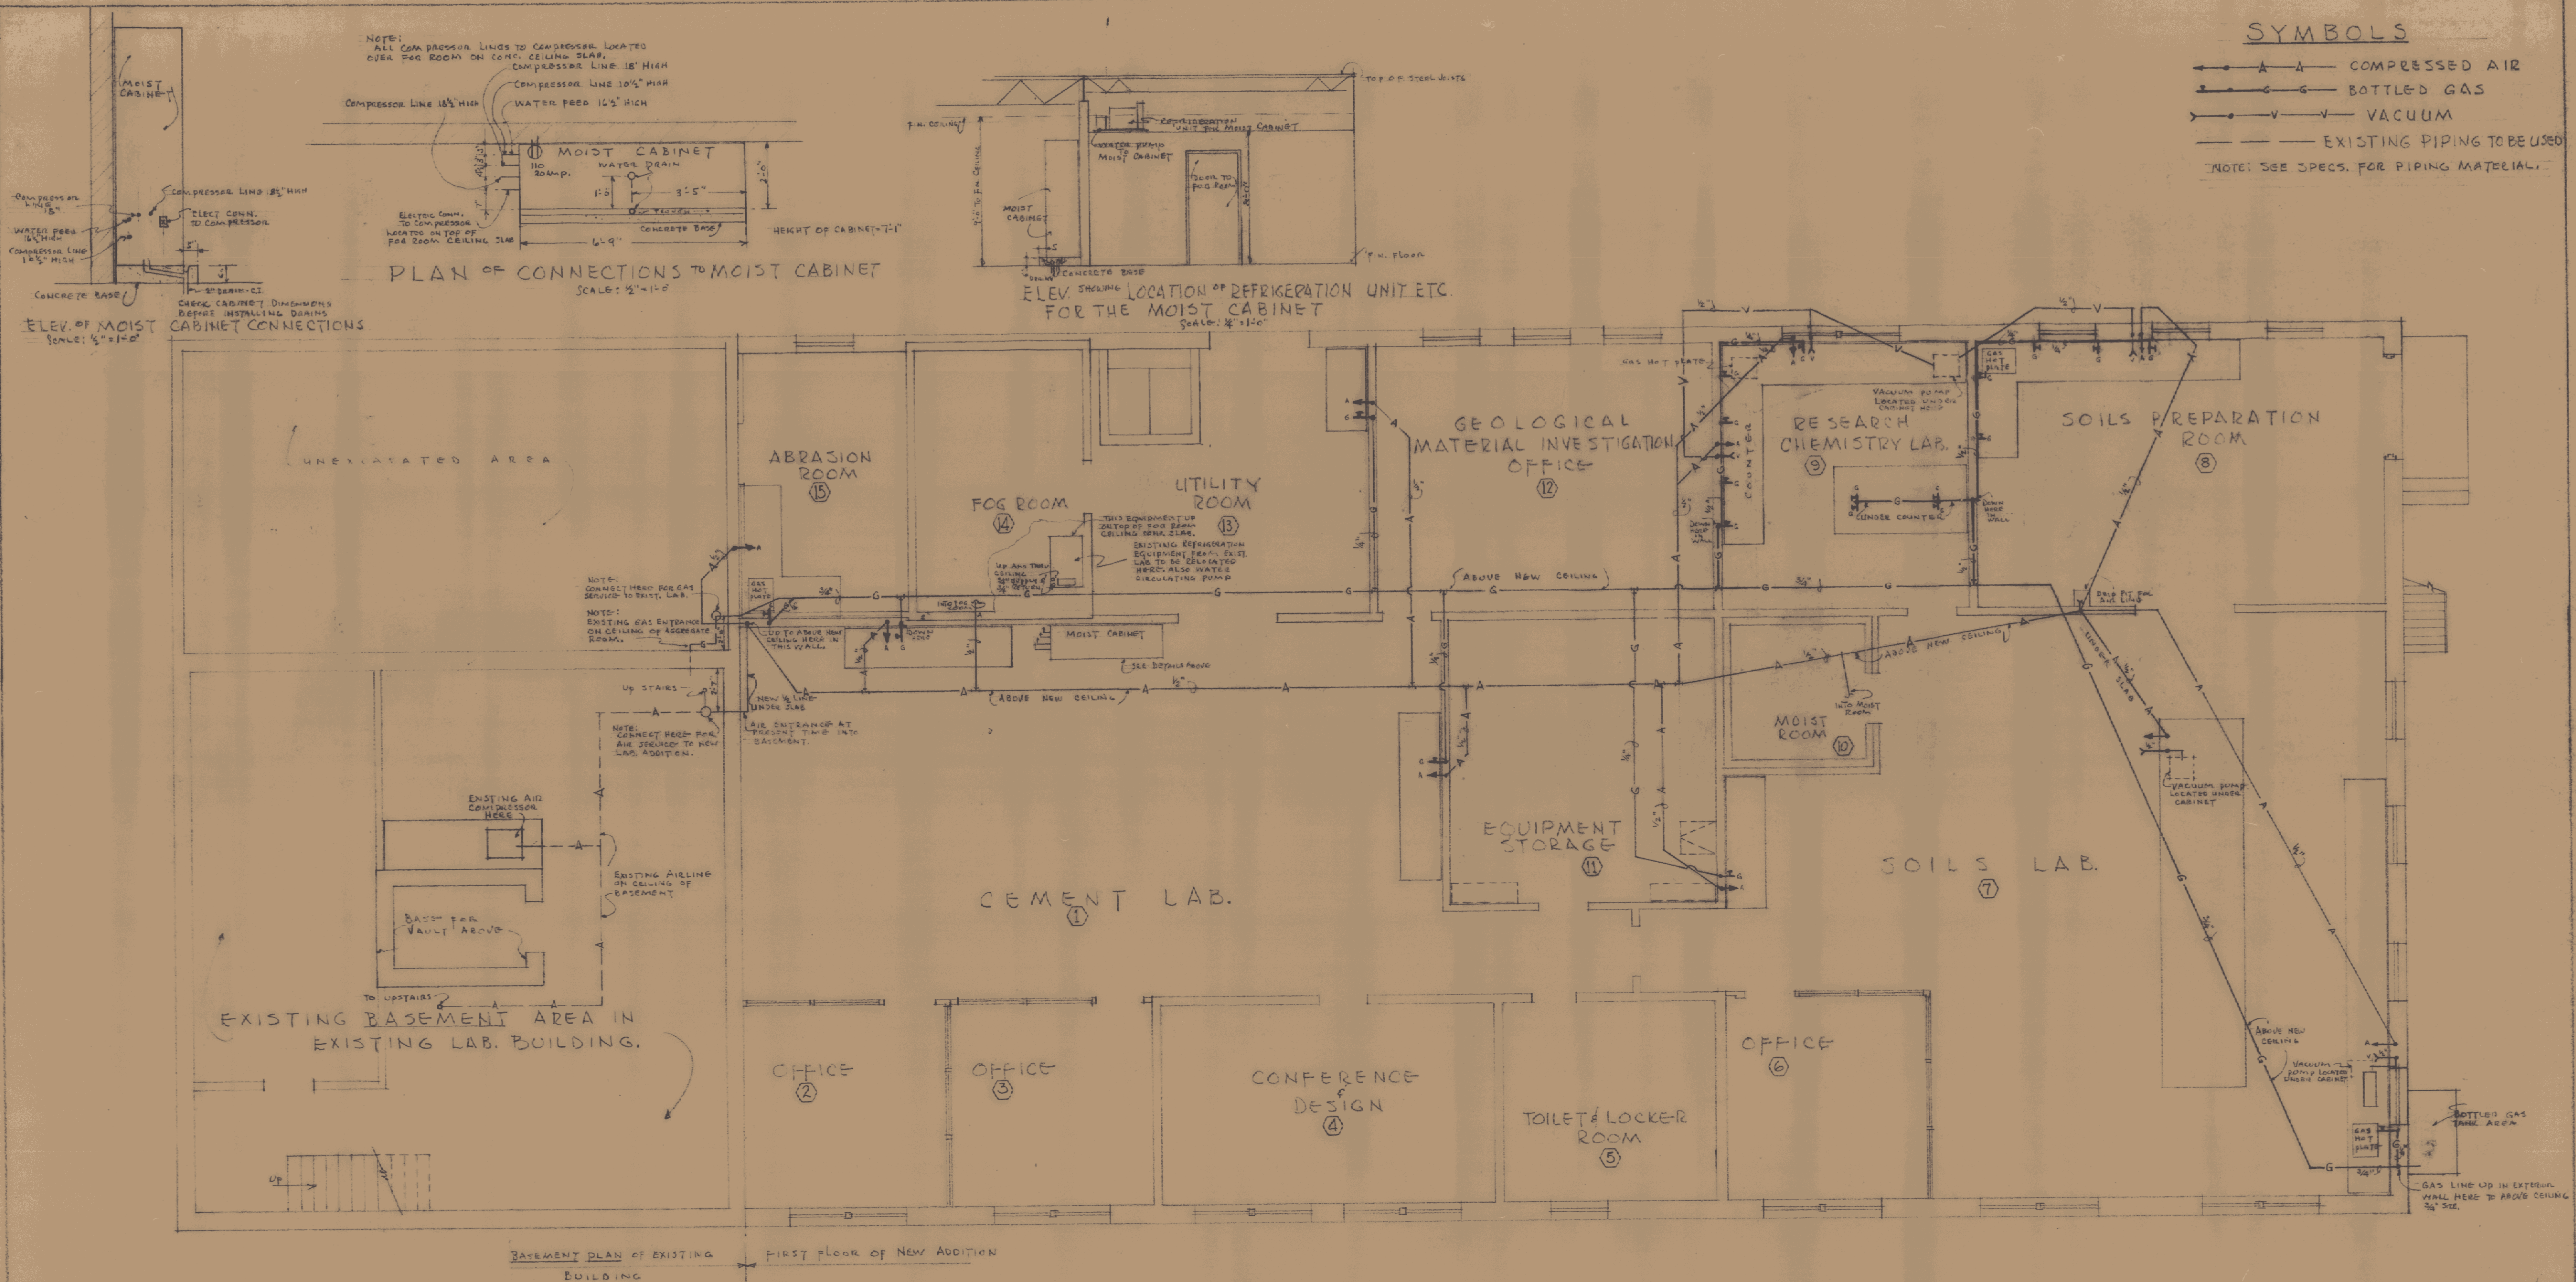


ADDITION TO VERMONT
STATE HIGHWAY LABORATORY
MONTPELIER, VERMONT

GORDON G. WOODS
ARCHITECTS BY
ST. JOHNSBURY, VERMONT

DESIGNED BY
G.W.
DRAWN BY
M.W.
CHECKED BY
I.G.V.

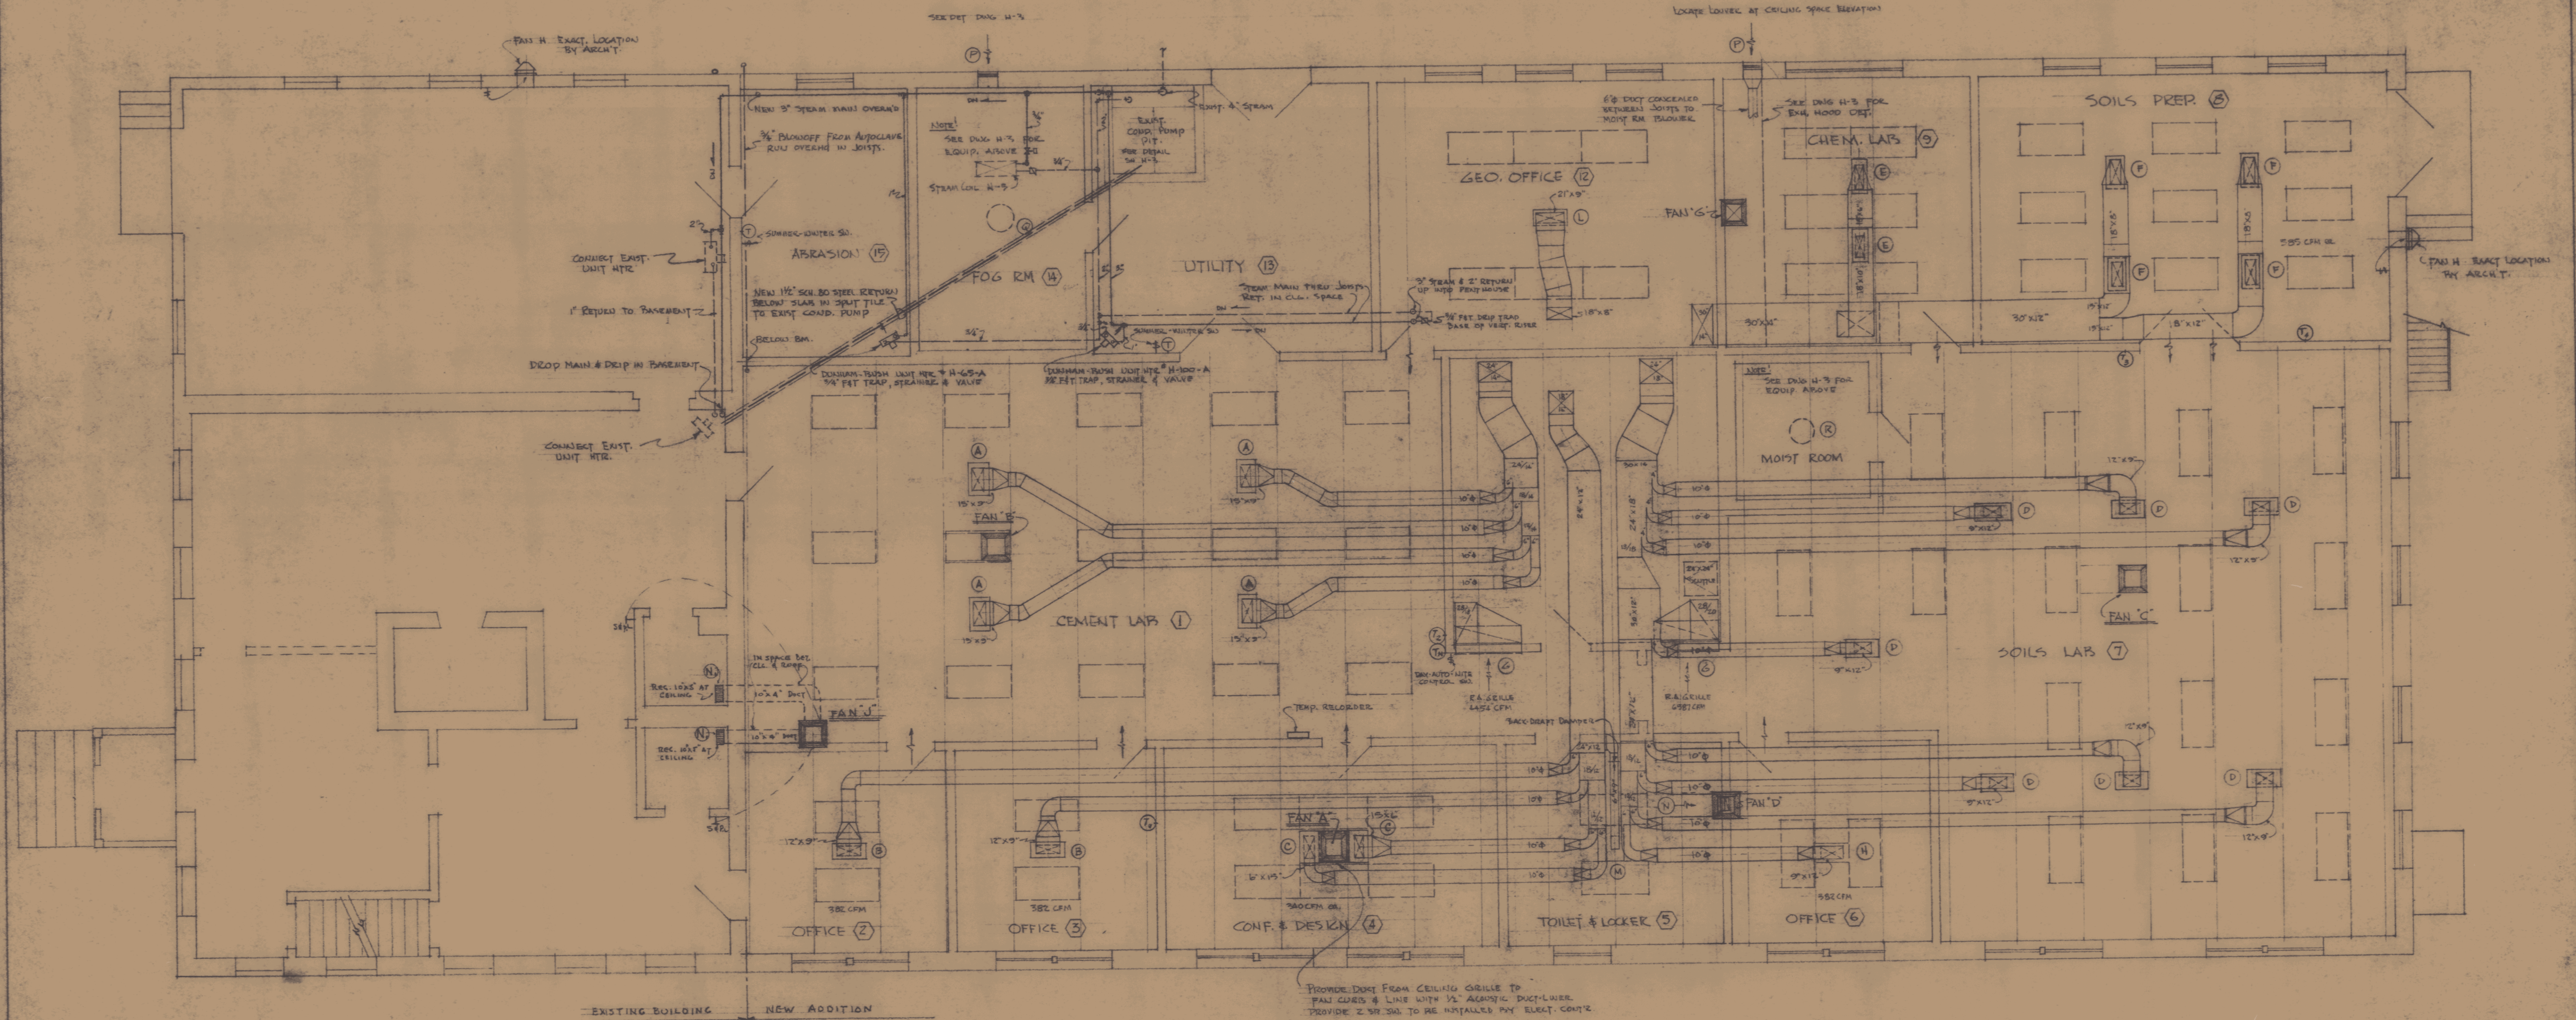

FIRST FLOOR PLAN - HEATING & AIR CONDITIONING
SCALE: 1/4" = 1'-0"

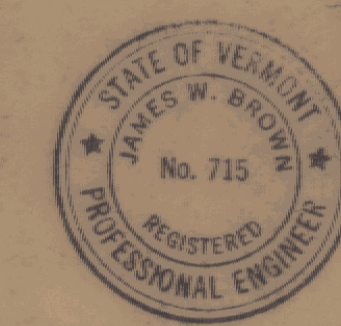


JENNISON ENGINEERING INC.
95 COLLEGE ST. FARMINGTON, VT.

ADDN TO VERMONT
STATE HIGHWAY LABORATORY
MONTPELIER, VERMONT

GORDON G. WOODS
ARCHITECTS & ENGINEERS
ST. JOHNSBURY, VERMONT


DESIGNED BY B.W.
CHECKED BY B.W.
DATE MAR-61
H-1

NOTES:
 PLUMBING CONTRACTOR SHALL PROVIDE WATER, WASTE AND CONDENSATE DRAIN FROM NEW A-C UNIT.
 ELECTRICAL CONTRACTOR SHALL PROVIDE POWER CIRCUITS TO ADDITIONAL UNIT HEATERS NOT SHOWN ON ORIGINAL DRAWING H-1, AND ALSO A 50 AMP, 3 PHASE BREAKER IN PANEL DP TO SERVICE THE 3 TON AC UNIT.
 ALL ROOF CURBS AS CALLED FOR ON ORIGINAL PLANS SHALL BE INSTALLED AND CAPPED IN THIS CONTRACT AND WALL OPENINGS PROVIDED & BLOCKED FOR FUTURE H FANS.
 WALL INTAKE LOUVER "P" FOR THE MOIST ROOM SHALL ALSO BE FRAMED IN AND SEALED AT THIS TIME, TO REMOVE THE LOUVER IN THE FUTURE.

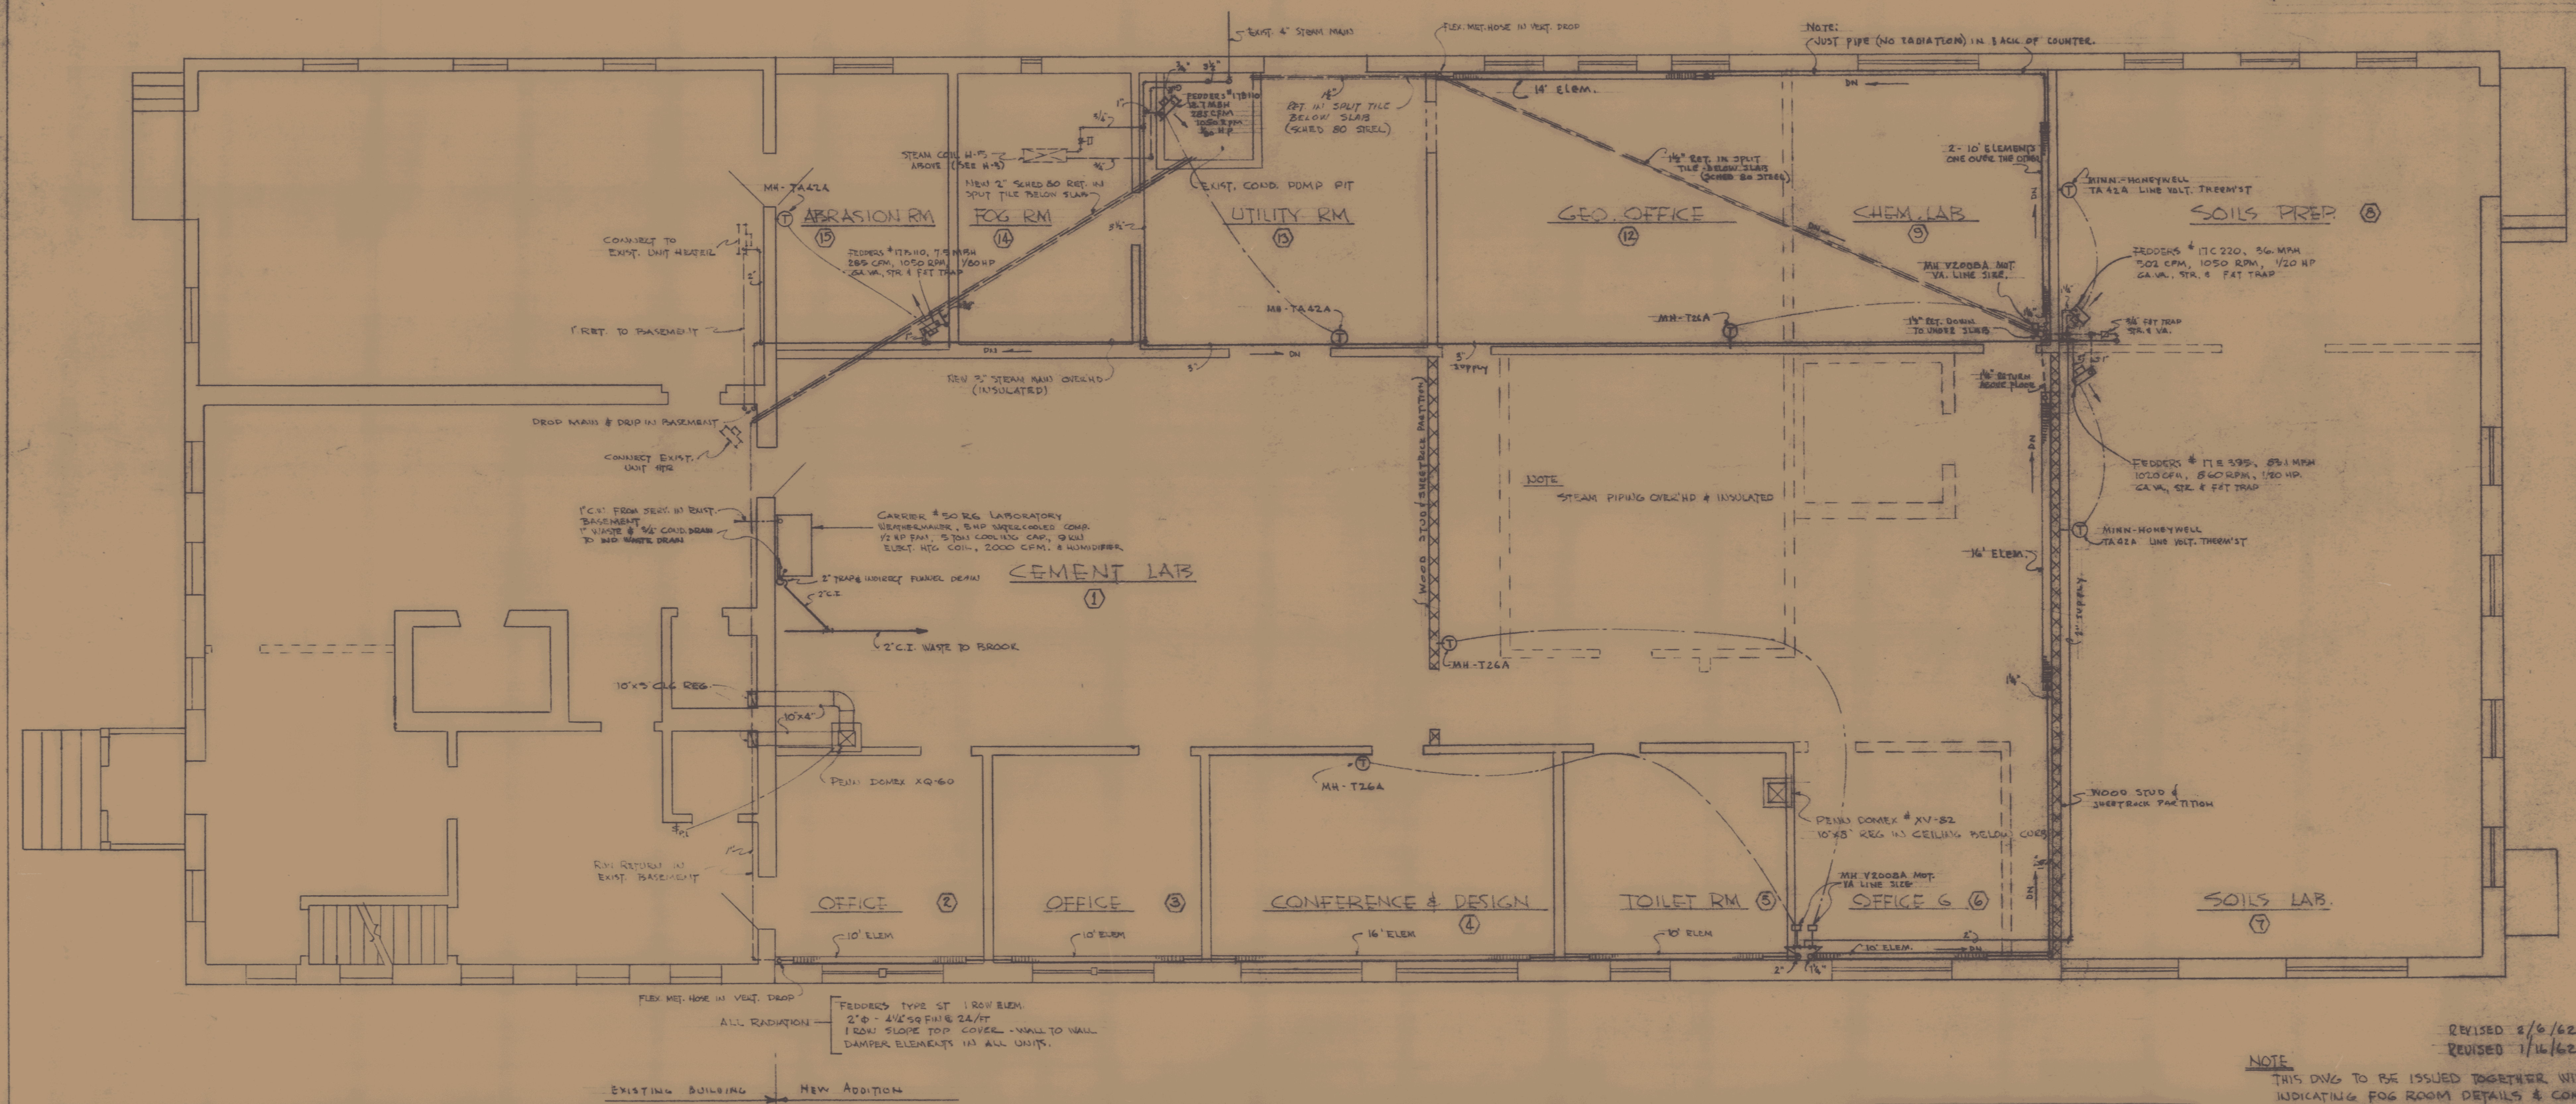


REVISD 2/6/62
 REVISD 7/16/62
 NOTE
 THIS DWG TO BE ISSUED TOGETHER WITH DWG H-3 INDICATING FOG ROOM DETAILS & COMD. PIT DETAILS & ORIGINAL SPECIFICATIONS (OMIT SECTIONS WHICH DO NOT APPLY)


ADDITION TO VERMONT
 STATE HIGHWAY LABORATORY
 MONTPELIER, VERMONT
 GORDON G. WOODS
 ARCHITECT
 ST. JOHNSBURY, VERMONT

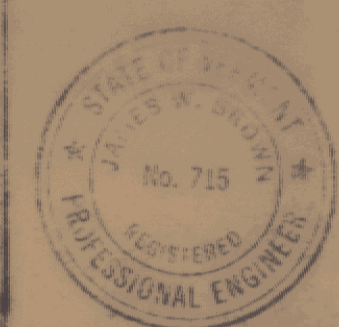


STATE HIGHWAY LABORATORY
 REVISED HEATING & AIR COND.
 WORK NO. 547
 DRAWN BY JWG
 CHECKED BY JWG
 DATE OCT 61
 JENNISON ENGINEERING INC.
 CONSULTING ENGINEERS
 85 CALVERD ST. SUITE 200, BURLINGTON, VT. TEL. 263-2000
 SHEET NO. H-1A
 DATE OCT 25, 61

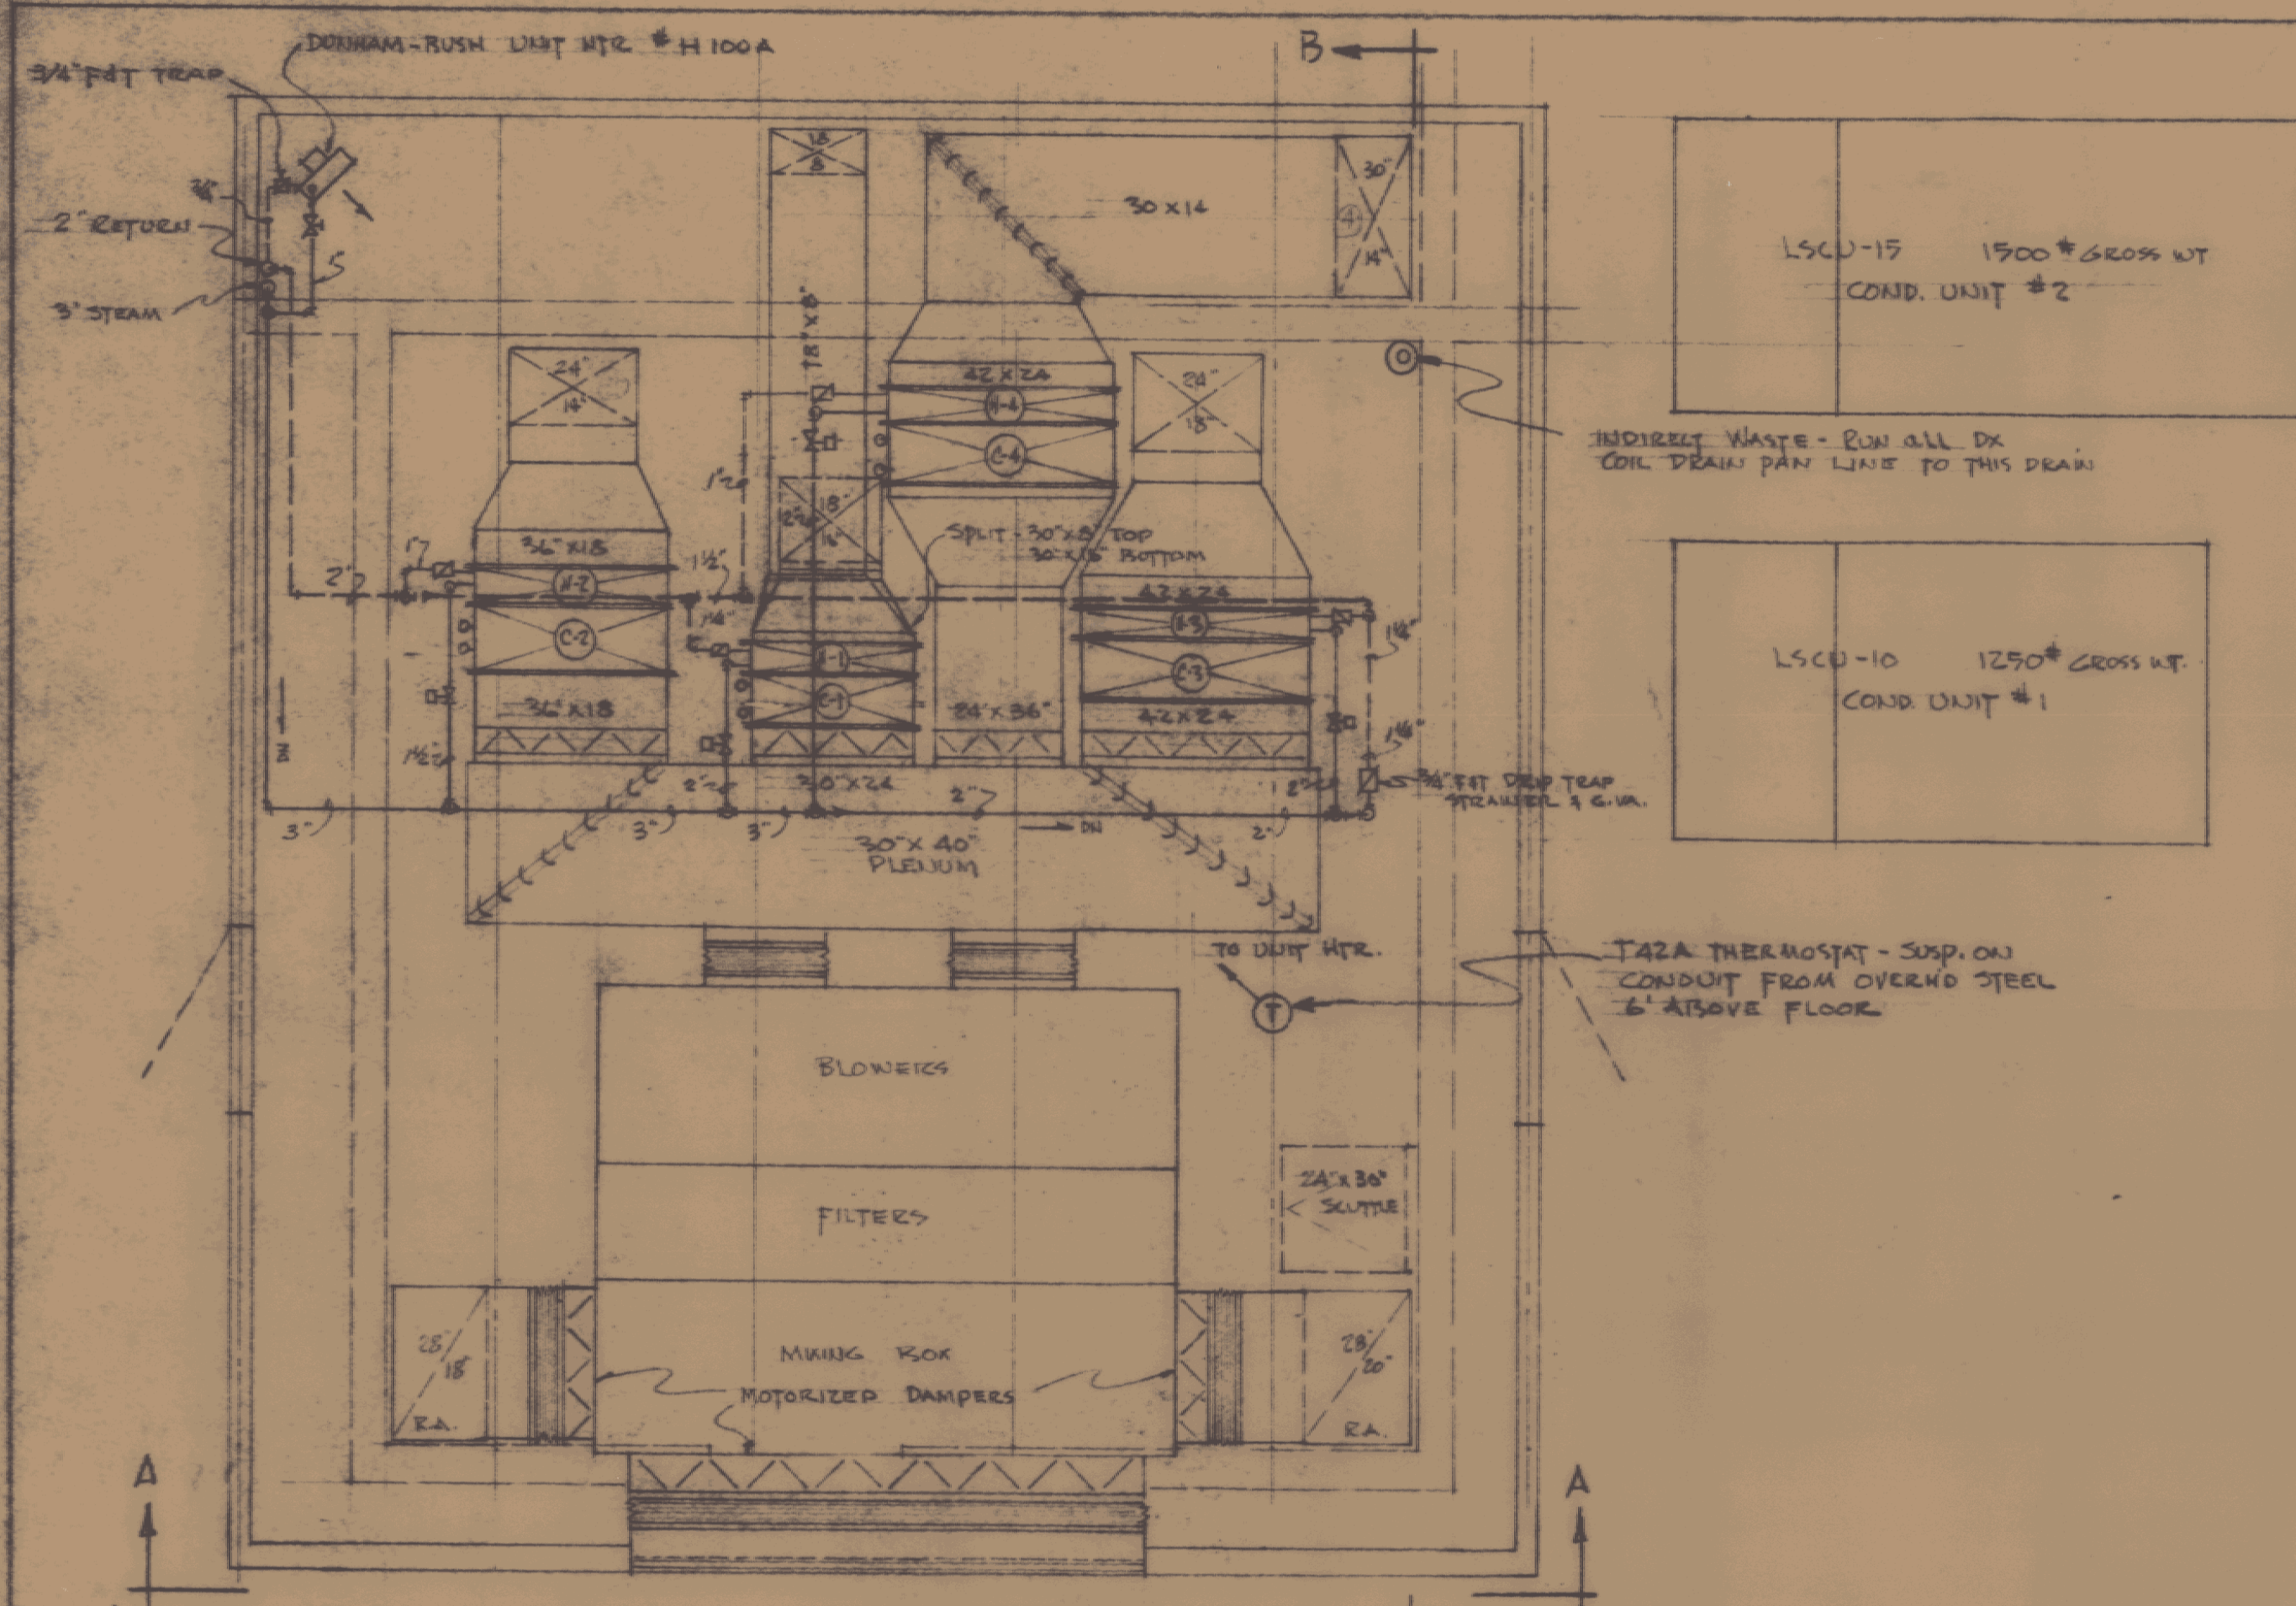


PENTHOUSE - PLAN VIEW.
SCALE: 3/8" = 1'-0"

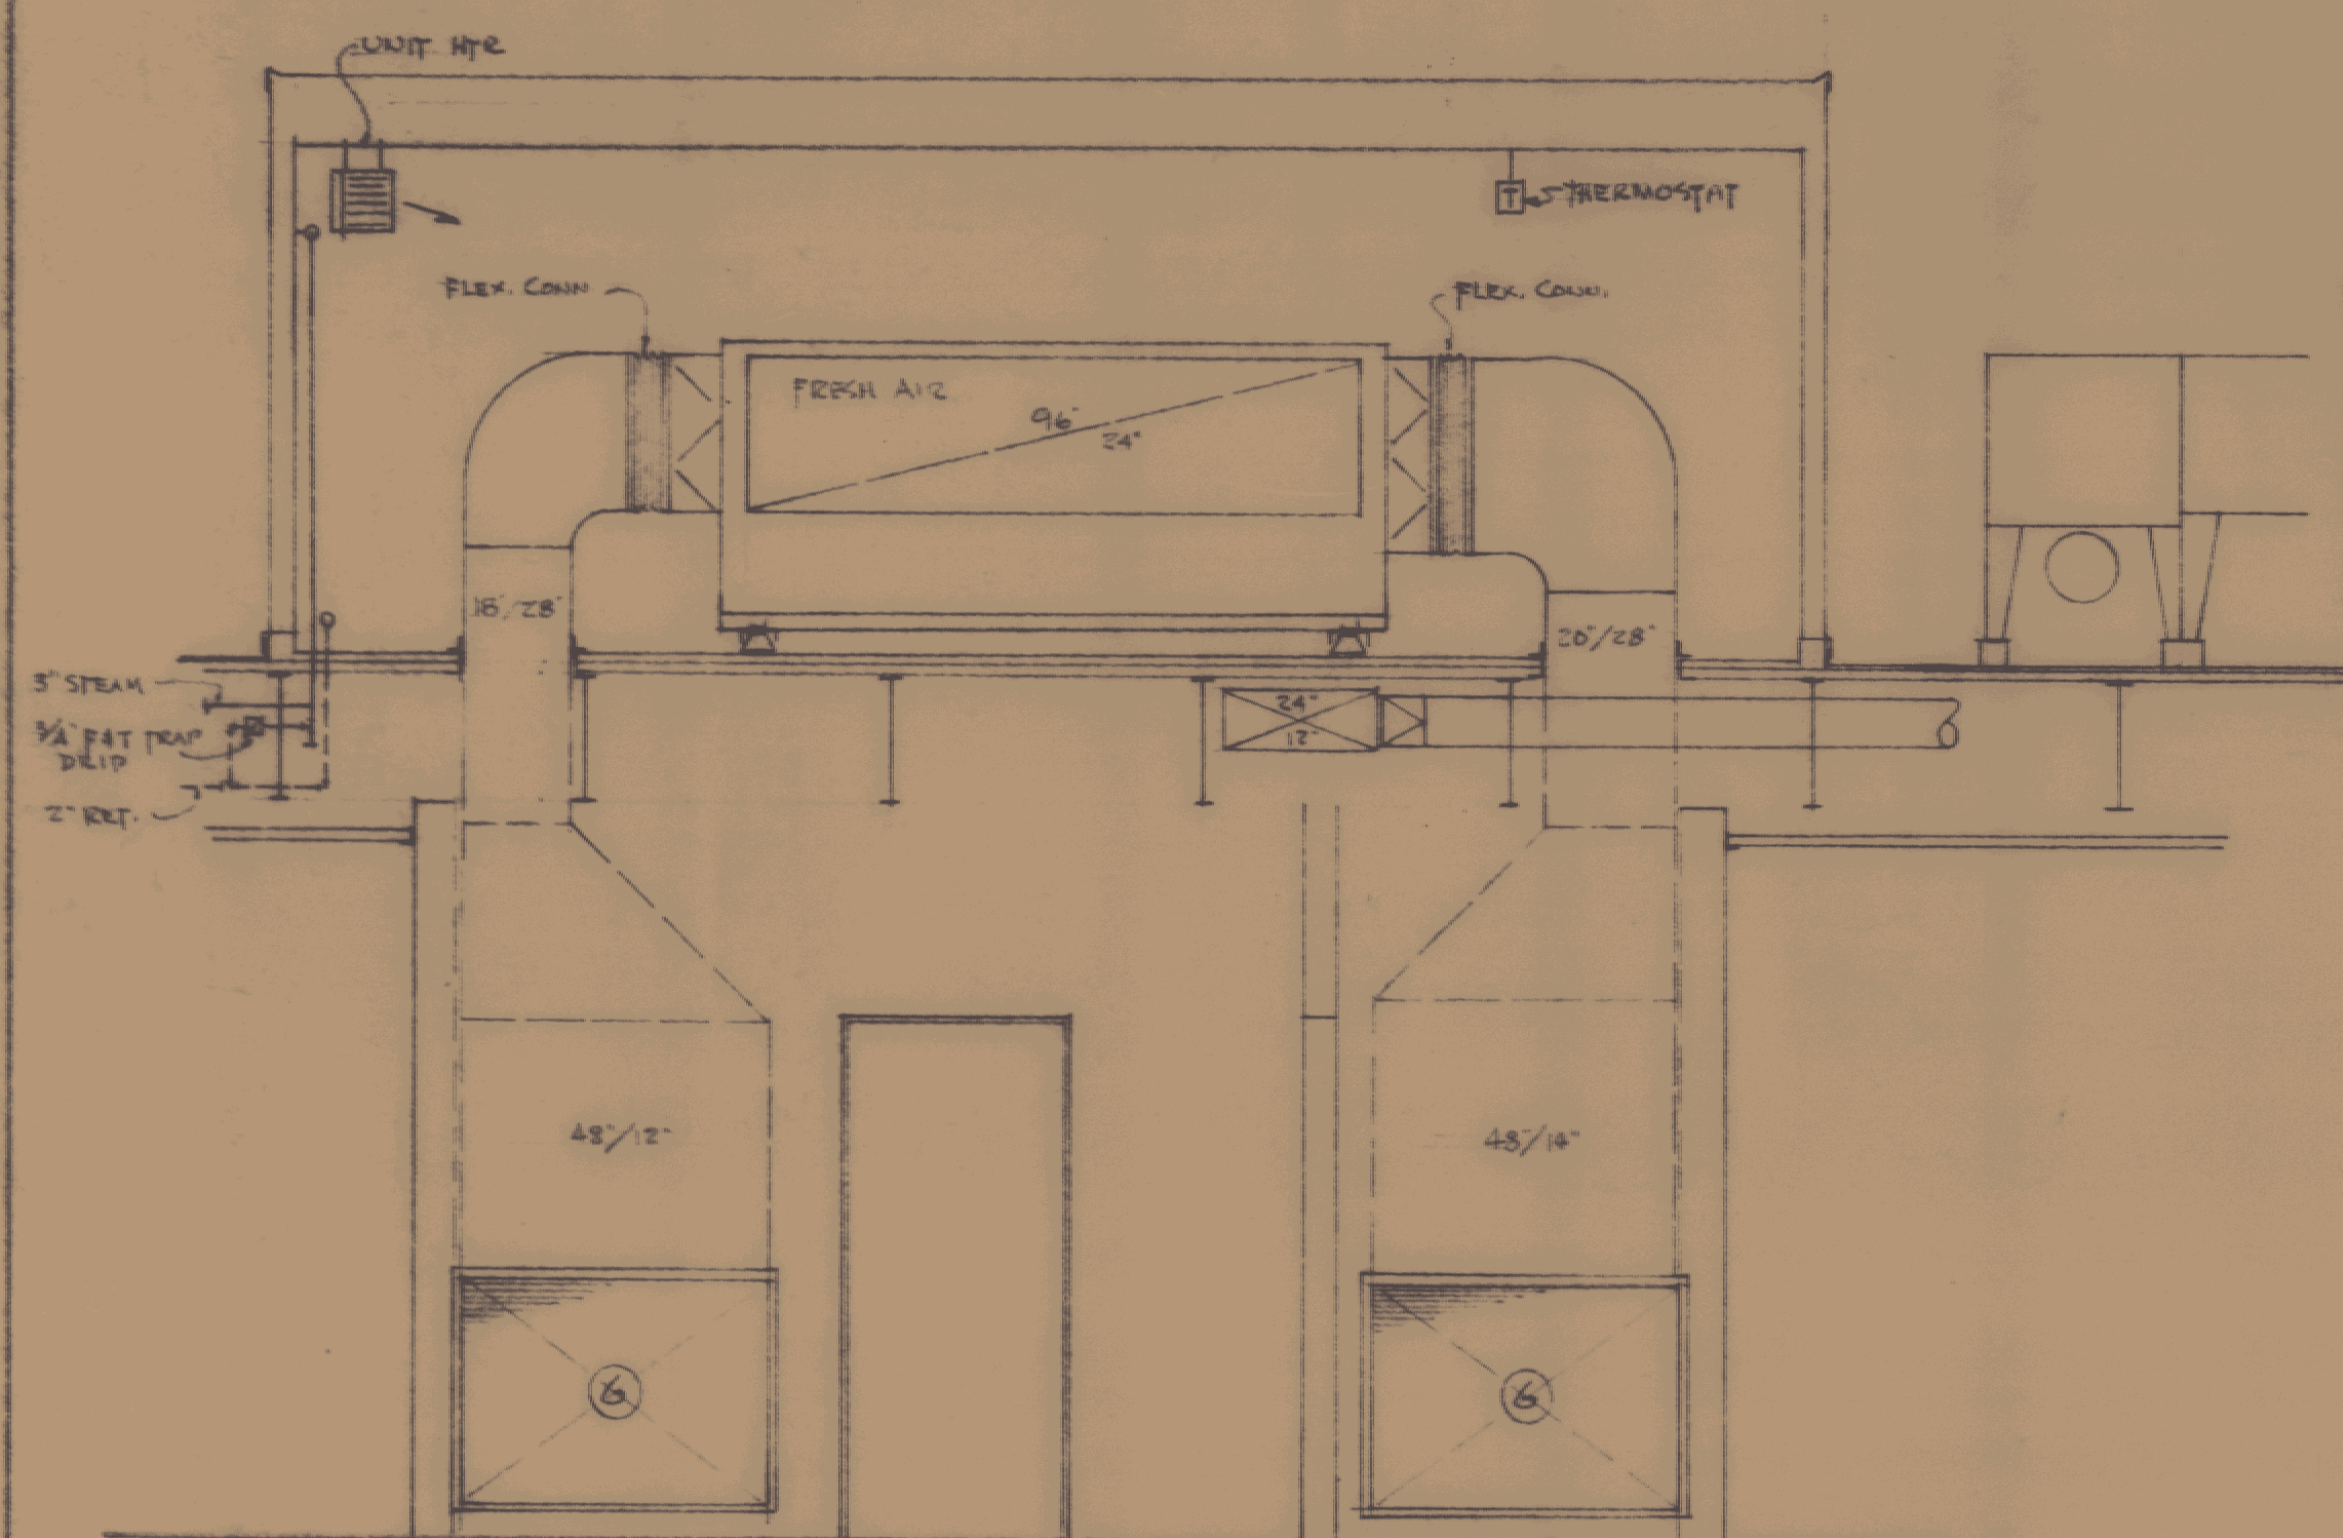

SECTION AA
SCALE: 3/8" = 1'-0"

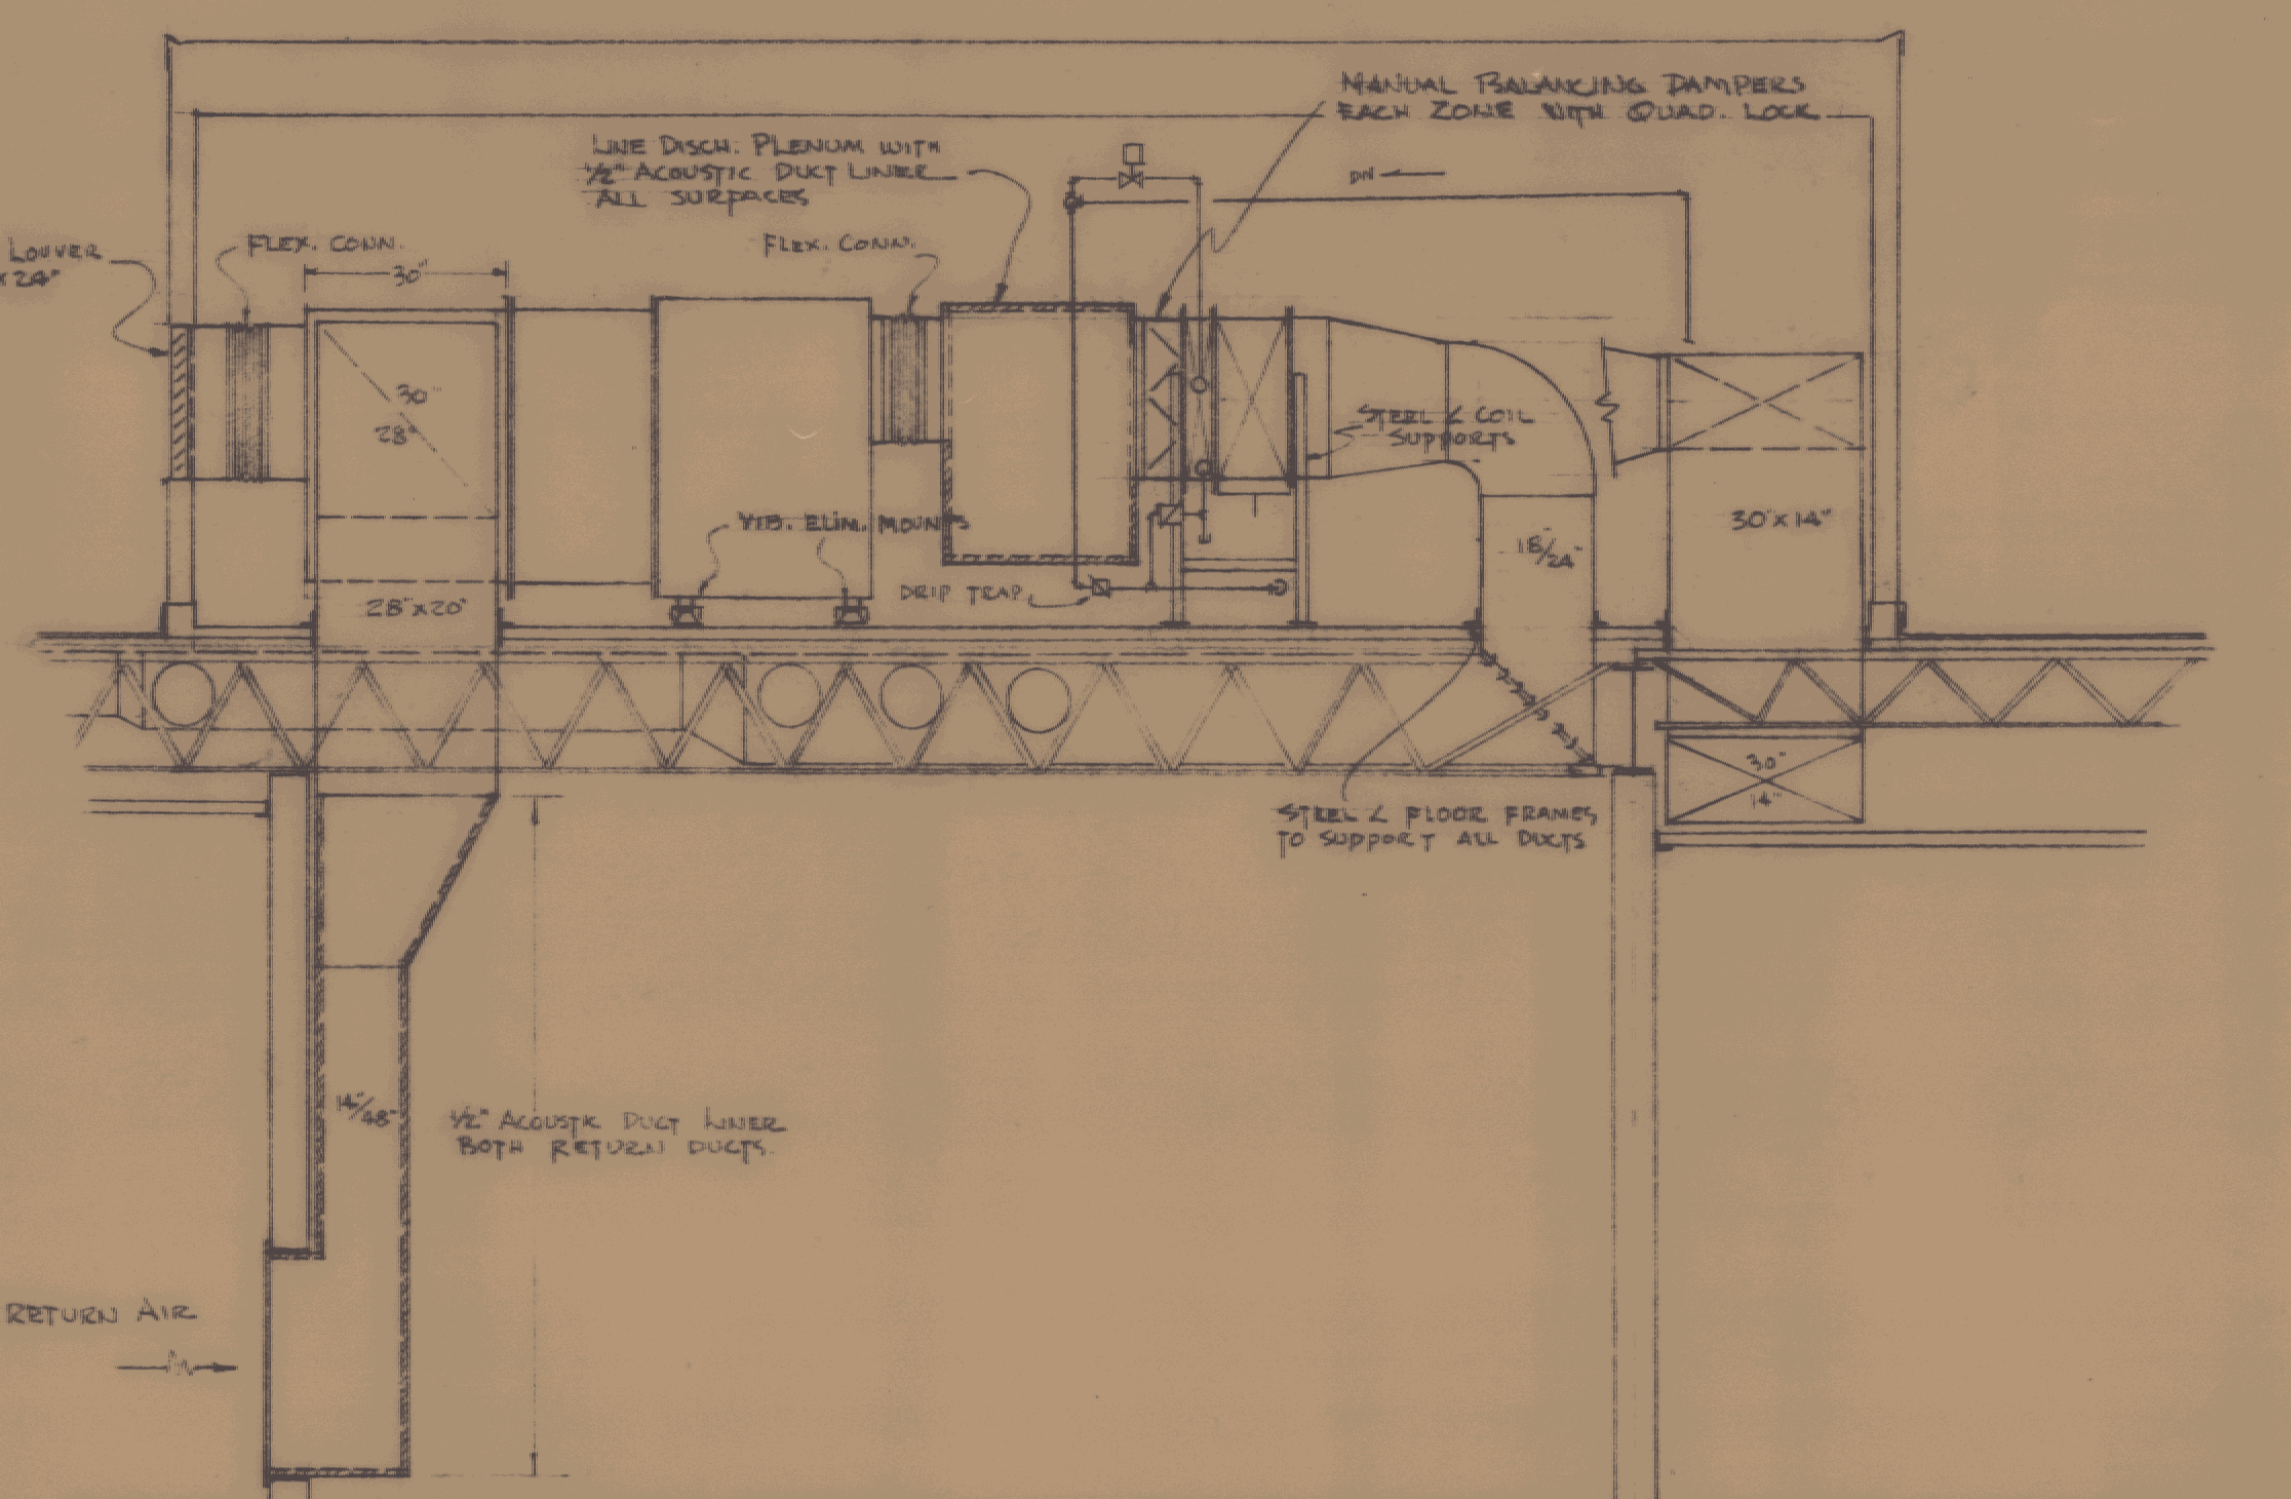


SECTION BB
SCALE: 3/8" = 1'-0"

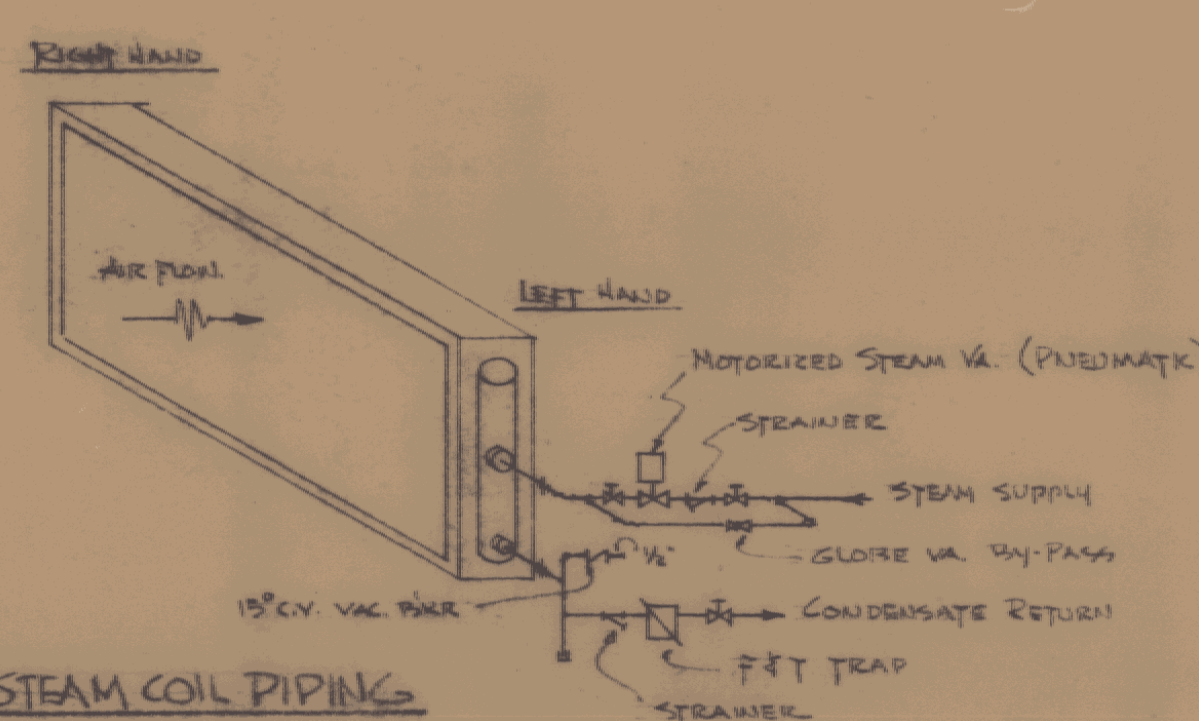

TYPICAL STEAM COIL PIPING

COIL	ZONE	MAKE	TYPE	SIZE	ROWS	FIN/VOL	CFM	#/HC	SE. VA.	FIT TRAP	COMM.
H-1	1	DUNHAM-BUSH	NFH	30" X 24"	1	8	2454	105	1"	1 1/4"	R.H.
H-2	2	"	"	34" X 18"	1	6	2000	56	3/4"	1"	R.H.
H-3	3	"	"	42" X 24"	1	8	3982	136	1 1/4"	1 1/4"	L.H.
H-4	4	"	"	42" X 24"	1	6	3205	88	1"	1"	R.H.
H-5	Fog RM	"	"	12" X 6"	2		225	31	3/4"	1/2"	R.H.

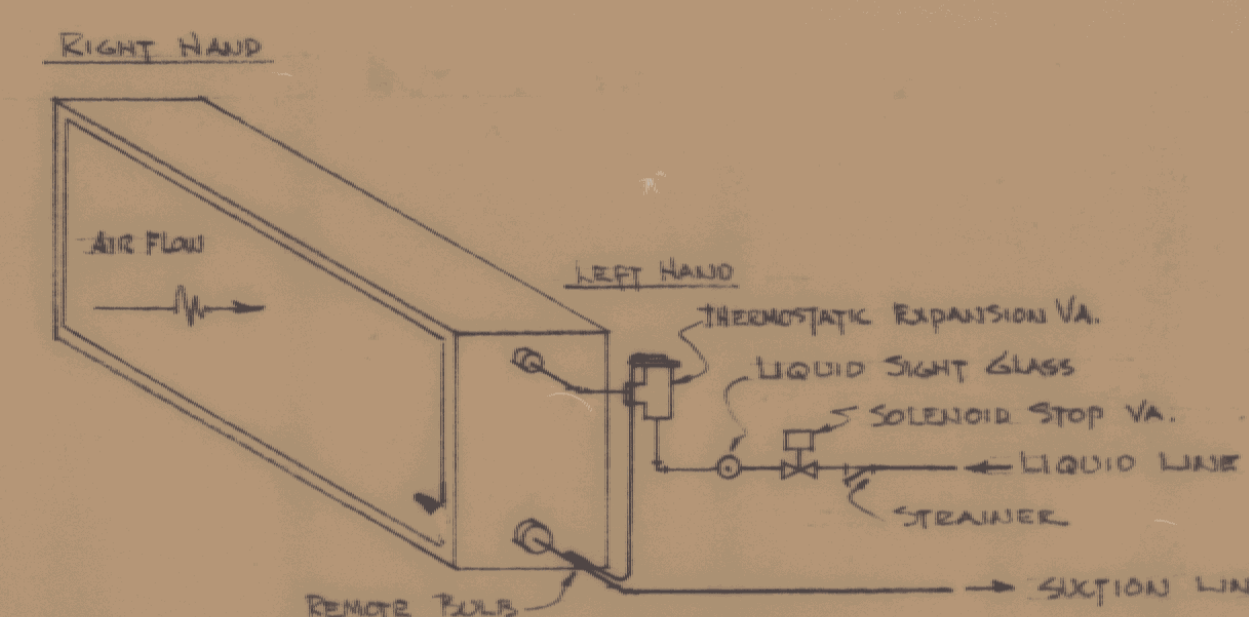

TYPICAL DX COIL PIPING

COIL	ZONE	MAKE	TYPE	SIZE	ROWS	CFM	TONS	COND. UNIT	CONN.	LIQ.	SUCT.	REFRIG.
C-1	1	DUNHAM-BUSH	DX	30" X 24"	6	2454	4.7	1	R.H.	1/2"	1 1/8"	F-22
C-2	2	"	"	34" X 18"	8	2000	4.7	1	R.H.	1/2"	1 1/8"	"
C-3	3	"	"	42" X 24"	6	3982	6.65	2	L.H.	3/8"	1 1/8"	"
C-4	4	"	"	42" X 24"	6	3205	6.4	2	R.H.	3/8"	1 1/8"	"
C-5	FOG RM	"	"	15" X 11"	17" DP	225	1.0	3	R.H.	3/8"	5/8"	F-12
C-6	MOT RM	"	"	15" X 7"	17" DP	100	.5	4	L.H.	3/8"	1/2"	F-12

REGISTER, GRILLE, DIFFUSER & LOUVER SCHEDULE

NO.	TYPE	MAKE	MODEL	SIZE	CFM	MFG. HGT.	DAMPER	REMARKS
A	DIFFUSER	AGITAIR	RCTC-42	9" X 10" NECK	500	CRILING	FULL-FLD	12" X 24" FIT T SYSTEM
B	"	"	RC-42	9" X 10" NECK	582	"	"	12" X 24" FLANGE - CENTER IN TILE
C	"	"	RCTC-32	6" X 10" NECK	340	"	"	12" X 24" FIT T SYSTEM
D	"	"	RCTC-42	9" X 10" NECK	428	"	"	12" X 24" " " "
E	"	"	RCTC-42	9" X 10" NECK	430	"	"	12" X 24" " " "
F	"	"	RCTC-32	6" X 10" NECK	335	"	"	12" X 24" " " "
G	GRILLE	TUTTLE BAILEY	T-70 DB	48" X 48"	45	NOTES	ACROSS BASE	"
H	DIFFUSER	AGITAIR	RCTC-42	9" X 10" NECK	382	CRILING	FULL-FLD	12" X 24" FIT T SYSTEM
J	"	"	RCTC-70	9" X 10" NECK	EXHAUST	"	NOISE	24" X 24" " " "
K	LOUVER	AFRCO	F-9A PLANK	14" X 24"	F.A.T.	WALL	NOISE	INSTALLED BY GEN. CONTRACTOR
L	DIFFUSER	AGITAIR	RC-42	9" X 10" NECK	700	CRILING	FULL-FLD	12" X 24" FLANGE - CENTER IN TILE
M	"	"	RCTC-42	9" X 10" NECK	110	"	"	12" X 24" FIT T SYSTEM
N	REGISTER	TUTTLE BAILEY	T-90B	12" X 8" (81)	145	7" AS FLOOR	VOL. KEY	10" X 6" DUCT IN WALL TO FAN COILS IN TWO ROOMS WITHIN SAME FLOOR
P	LOUVER	AFRCO	F-9A CANNON	14" X 12"	F.A.T.	WALL	NOISE	INSTALLED BY GEN. CONTRACTOR
Q	DIFFUSER	AGITAIR	OR	10" X 6" NECK	225	CRILING	OR - VOLUME	2" BLOCKING AT CEILING BY H.C.
R	"	"	"	8" X 5 1/2"	100	"	"	"

FAN SCHEDULE

NO.	TYPE	MAKE	MODEL	SIZE	CFM	SP	RPM	HP	VOLTS	CO. I.D.	HGT	DAMP.	REMARKS
A	ROOF FAN	DOMEX	X-82	28" X 28"	287	1/2"	1050	1/2	110	19"	11"	12"	2 SPEED - MAIN SWITCH
B	"	DYNAL	LC-19	475	1/2"	860	1/2	110	19"	11"	12"	"	AUTO-TEMP CONTROL
C	"	"	LC-16	700	1/2"	745	1/2	110	20"	13"	12"	"	"
D	"	DOMEX	XV-82	145	1/2"	1550	1/2	110	19"	11"	12"	"	LIGHT SWITCH CONTROL
E	PAWNER	TRANE	6-EY	6" X 6"	225	3/8"	1725	1/8	110	"	"	"	FOG ROOM SUPPLY
F	"	"	4-EY	4" X 6"	100	1/2"	1725	1/8	110	"	"	"	MOT ROOM SUPPLY
G	ROOF FAN	DYNAL	LC-15	475	1/2"	860	1/2	110	19"	11"	12"	"	IMPELLER - CHEM FUMG RESIST.
H	WALL	"	DOMEX	WXR-65	180	1/2"	1550	1/2	110	"	"	"	DIRECT DRIVE
J	ROOF FAN	DOMEX	XQ-60	170	1/2"	1725	1/2	120	19"	11"	12"	"	"

JENNISON ENGINEERING INC.
95 COLLEGE ST. BURLINGTON, VT.

ADDITION TO VERMONT
STATE HIGHWAY LABORATORY
MONTPELIER, VERMONT

GORDON G. WOODS
ARCHITECTS & ENGINEERS
ST. JOHNSBURY, VERMONT












DESIGNED BY
G.W.

CHECKED BY
G.W.

DATE
MAR. 61

CONTRACT NO.
602

4-2

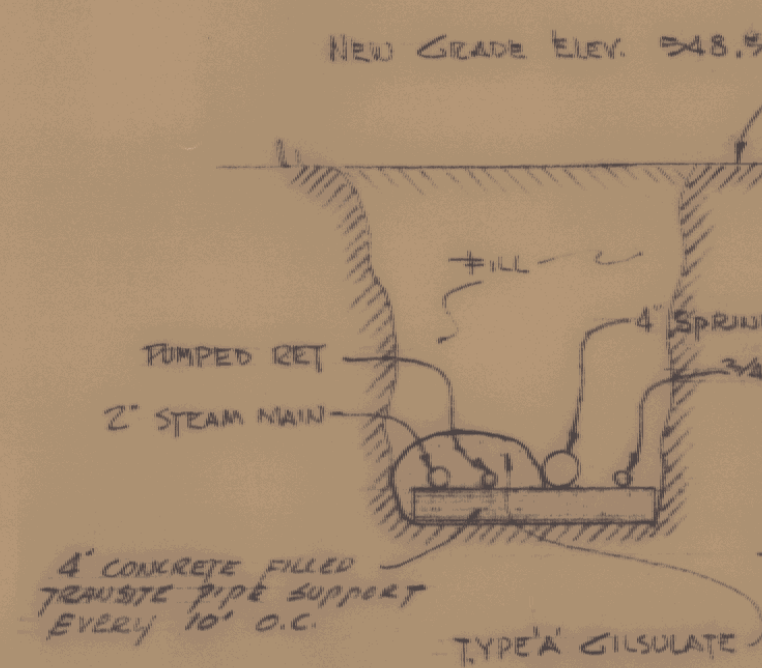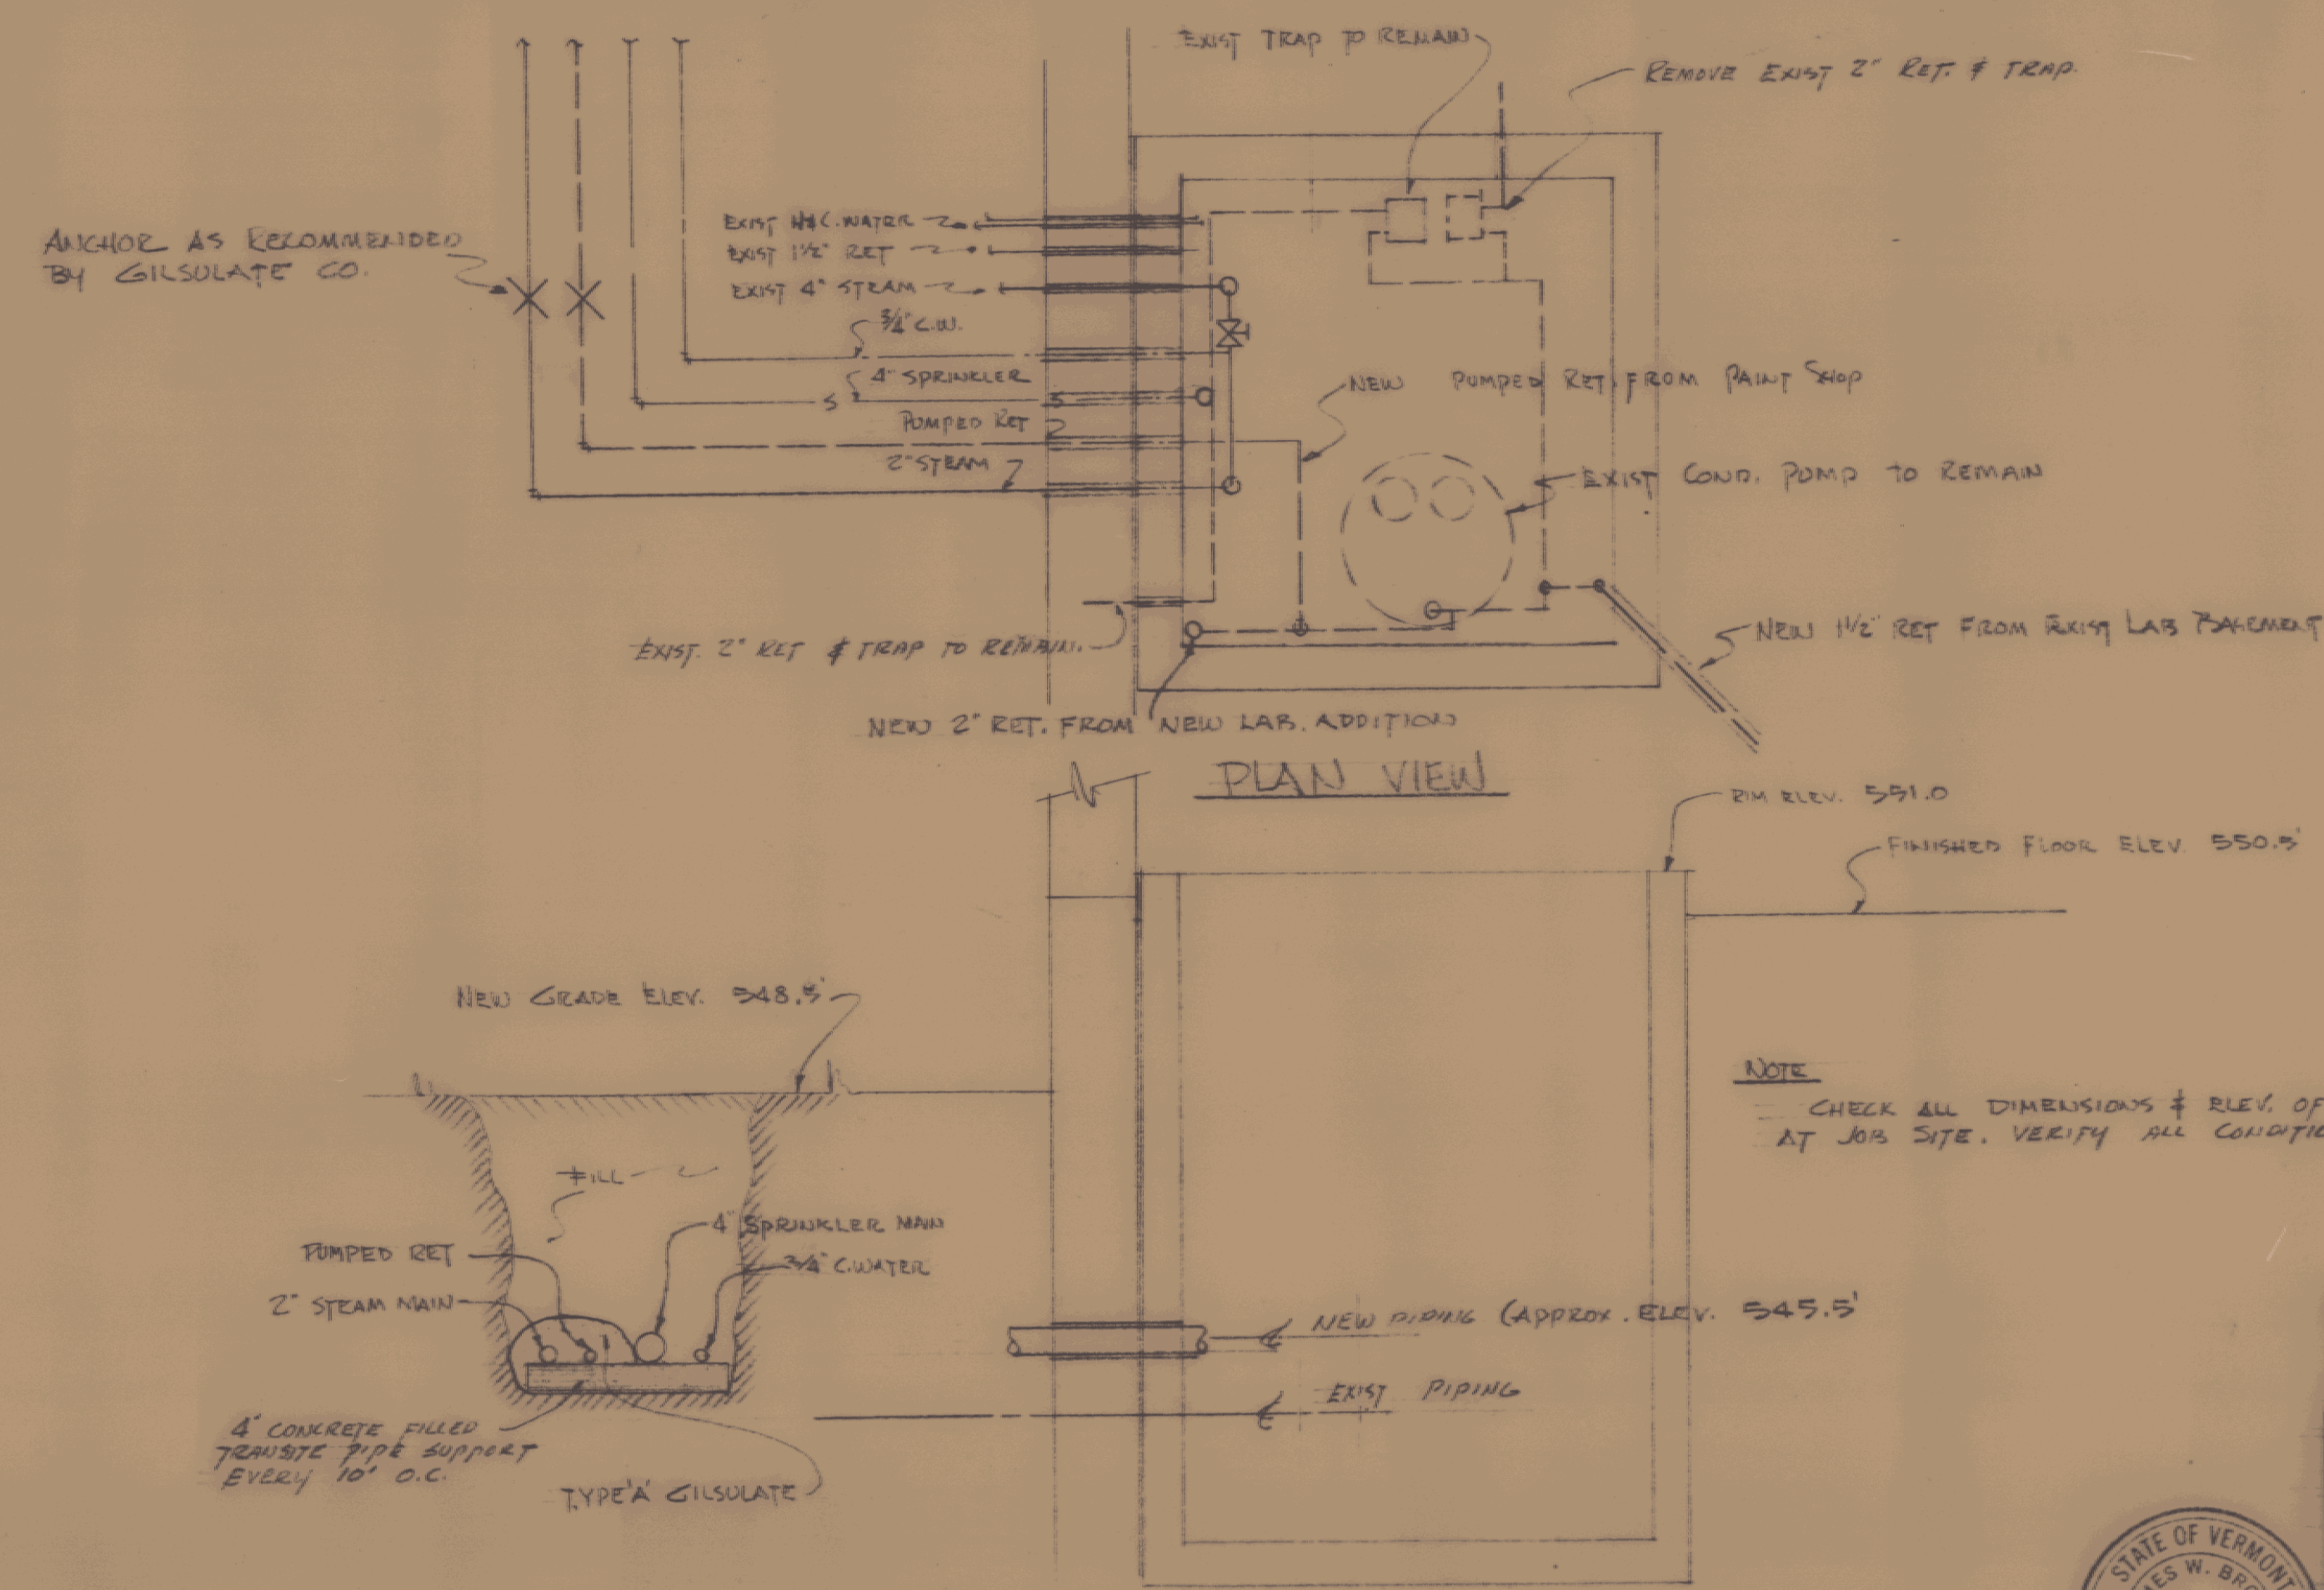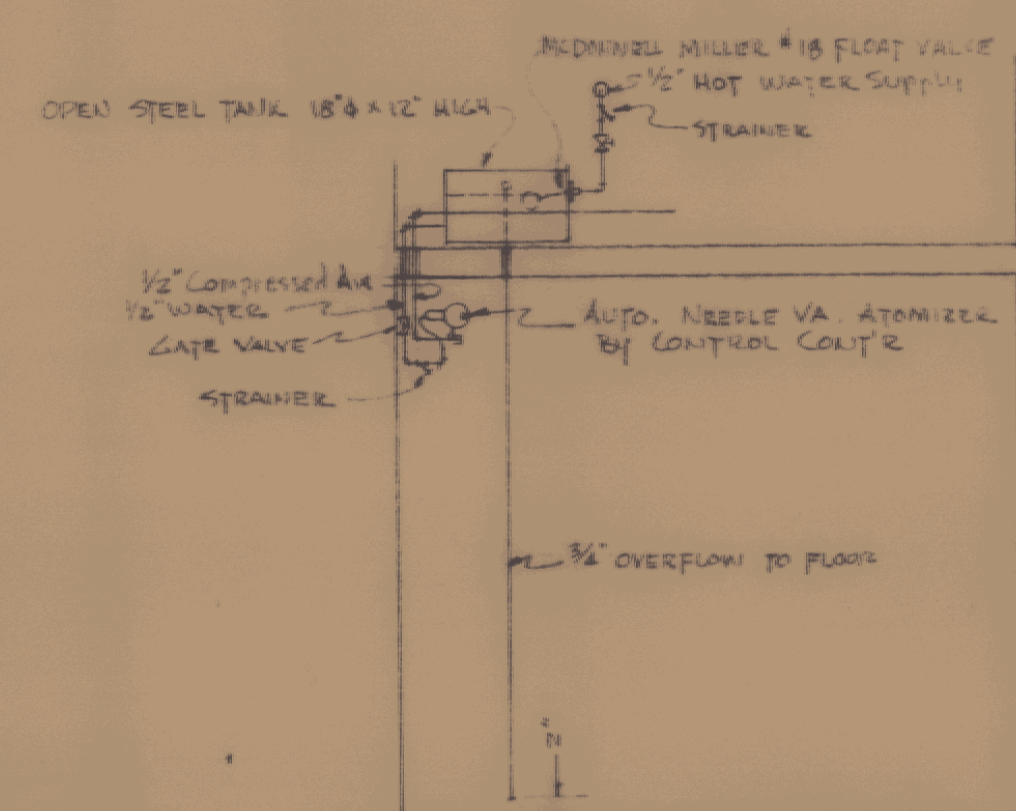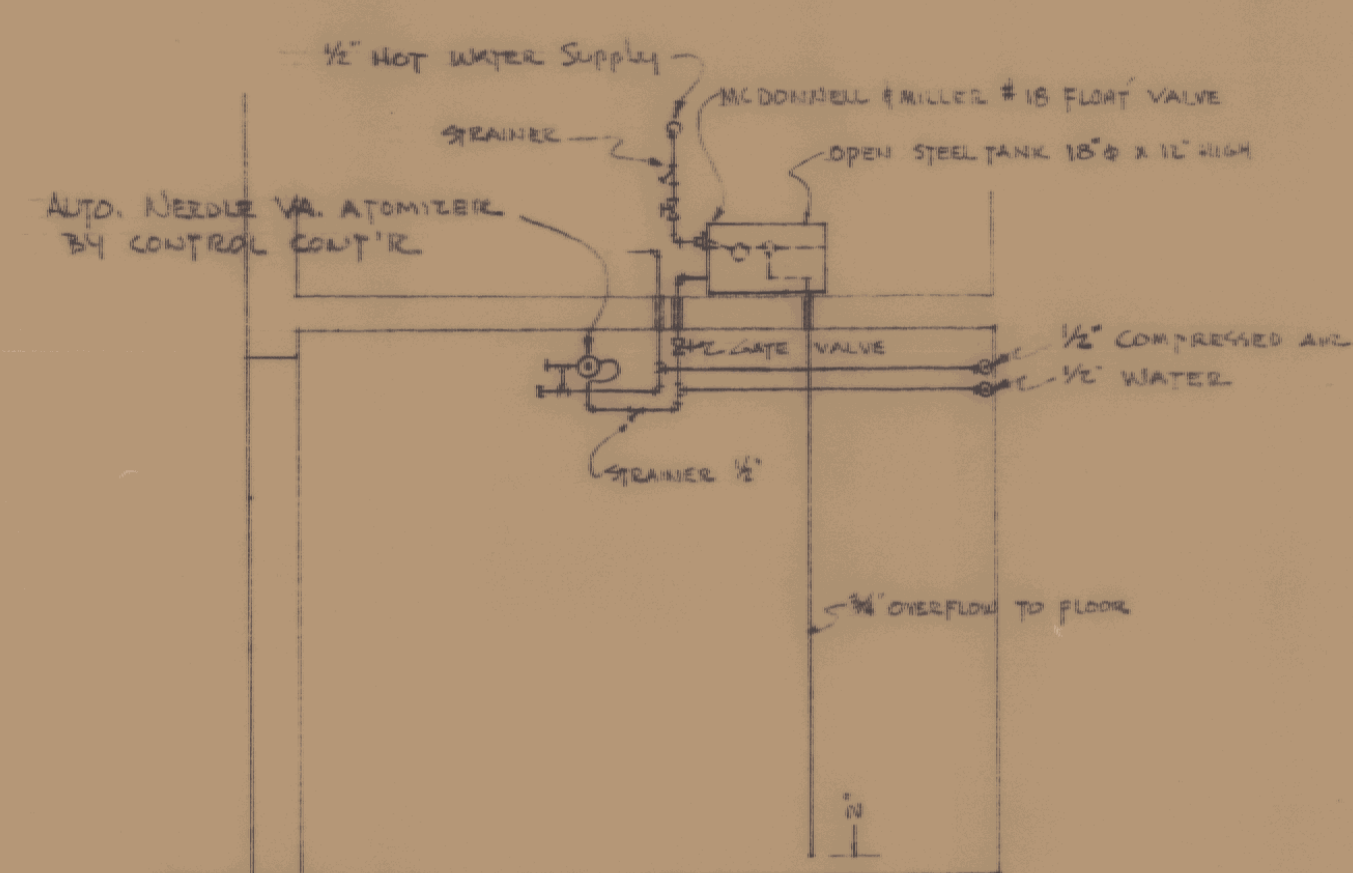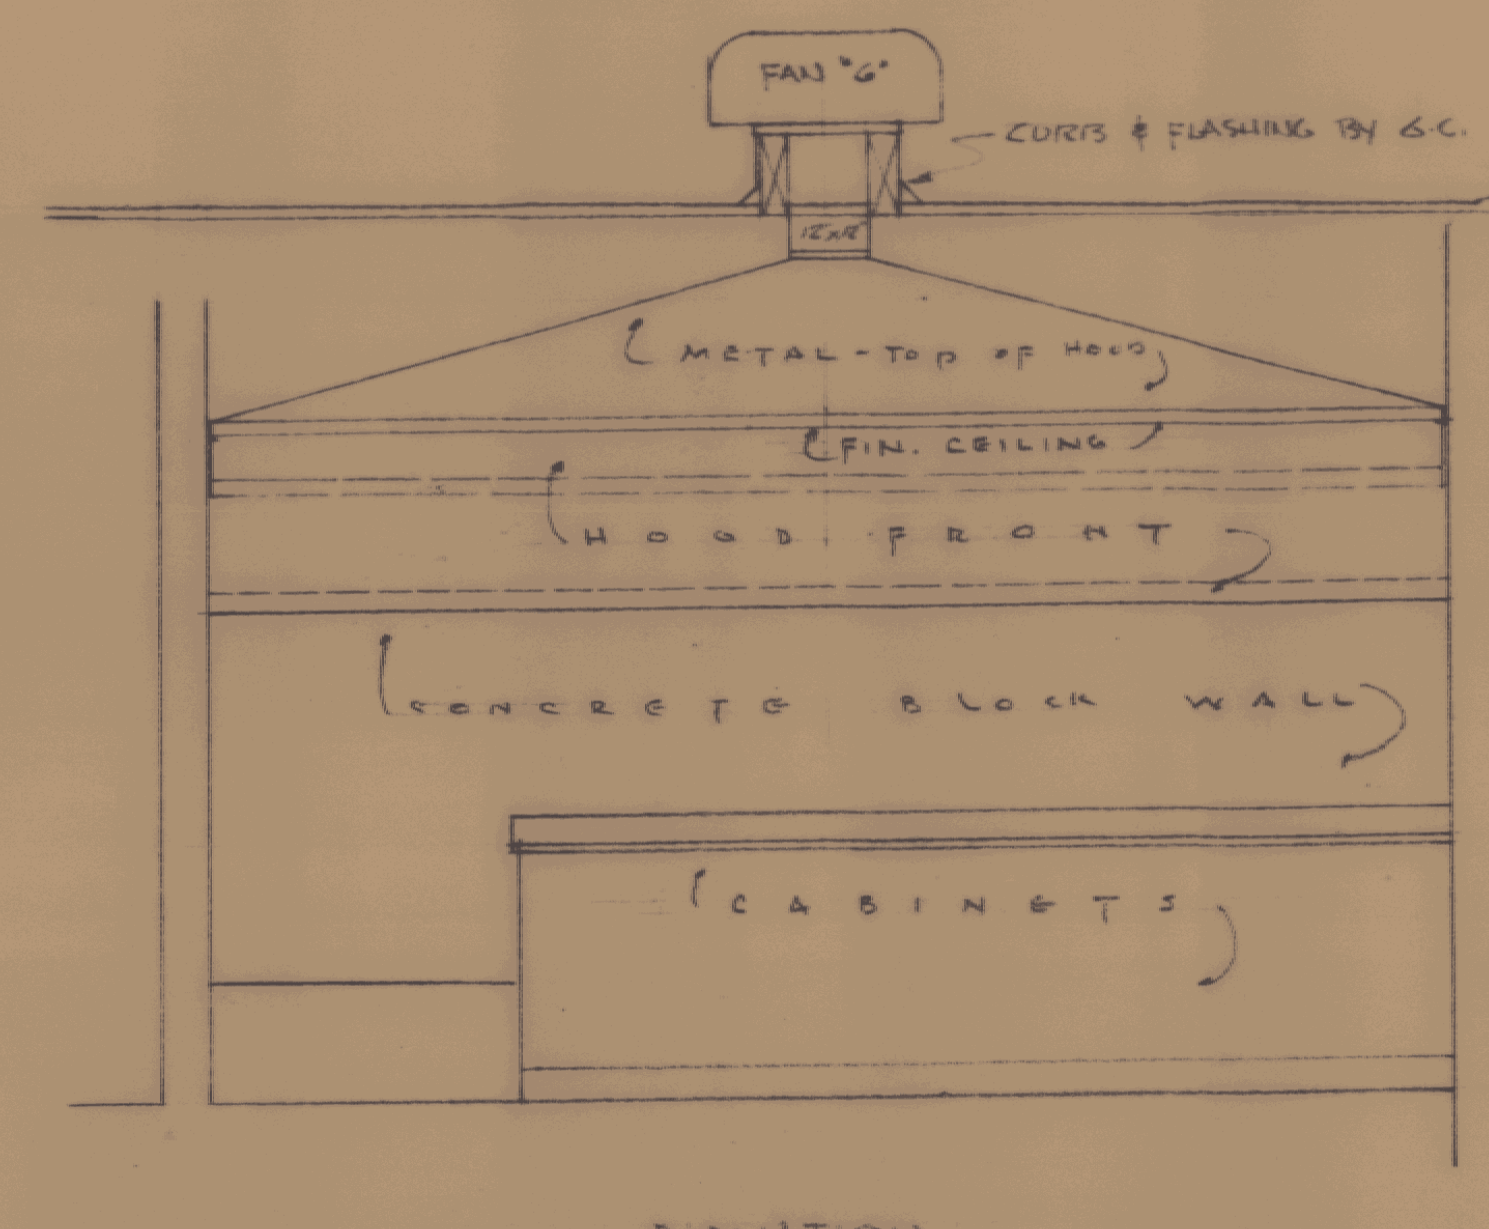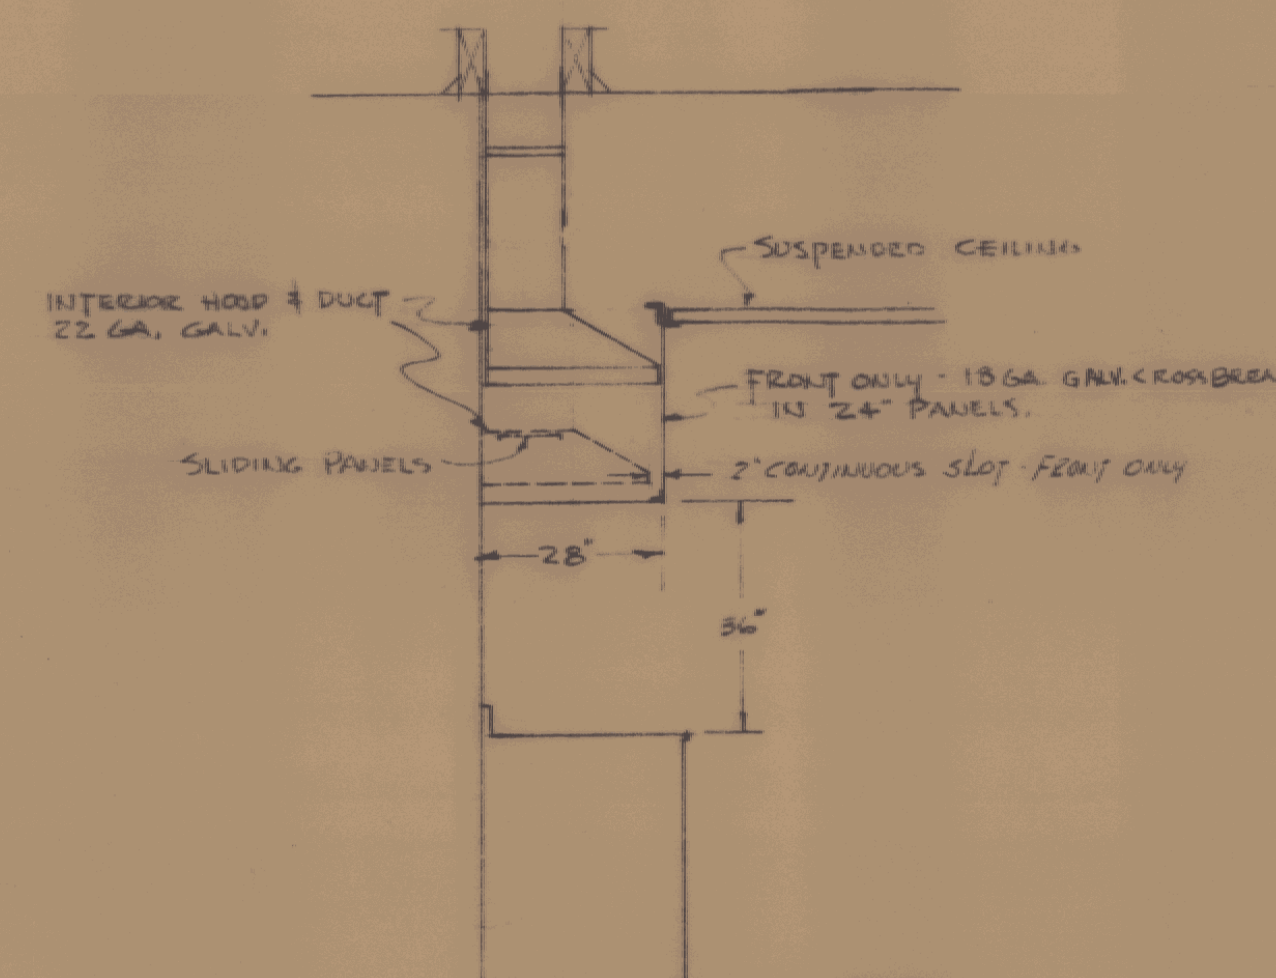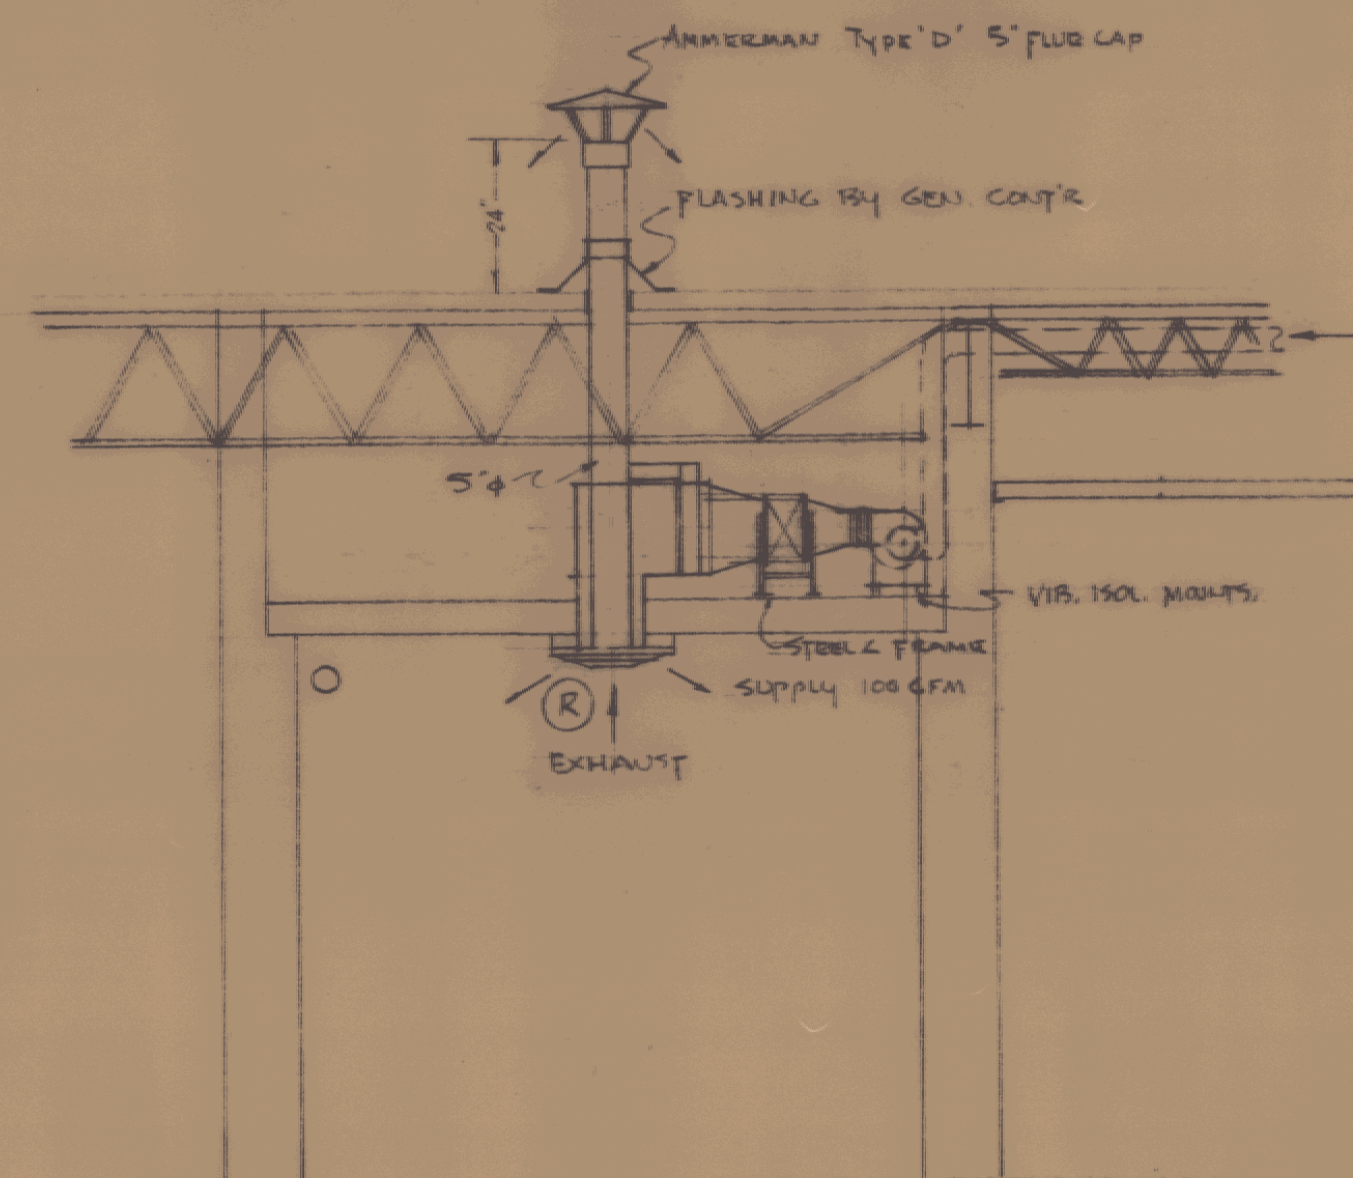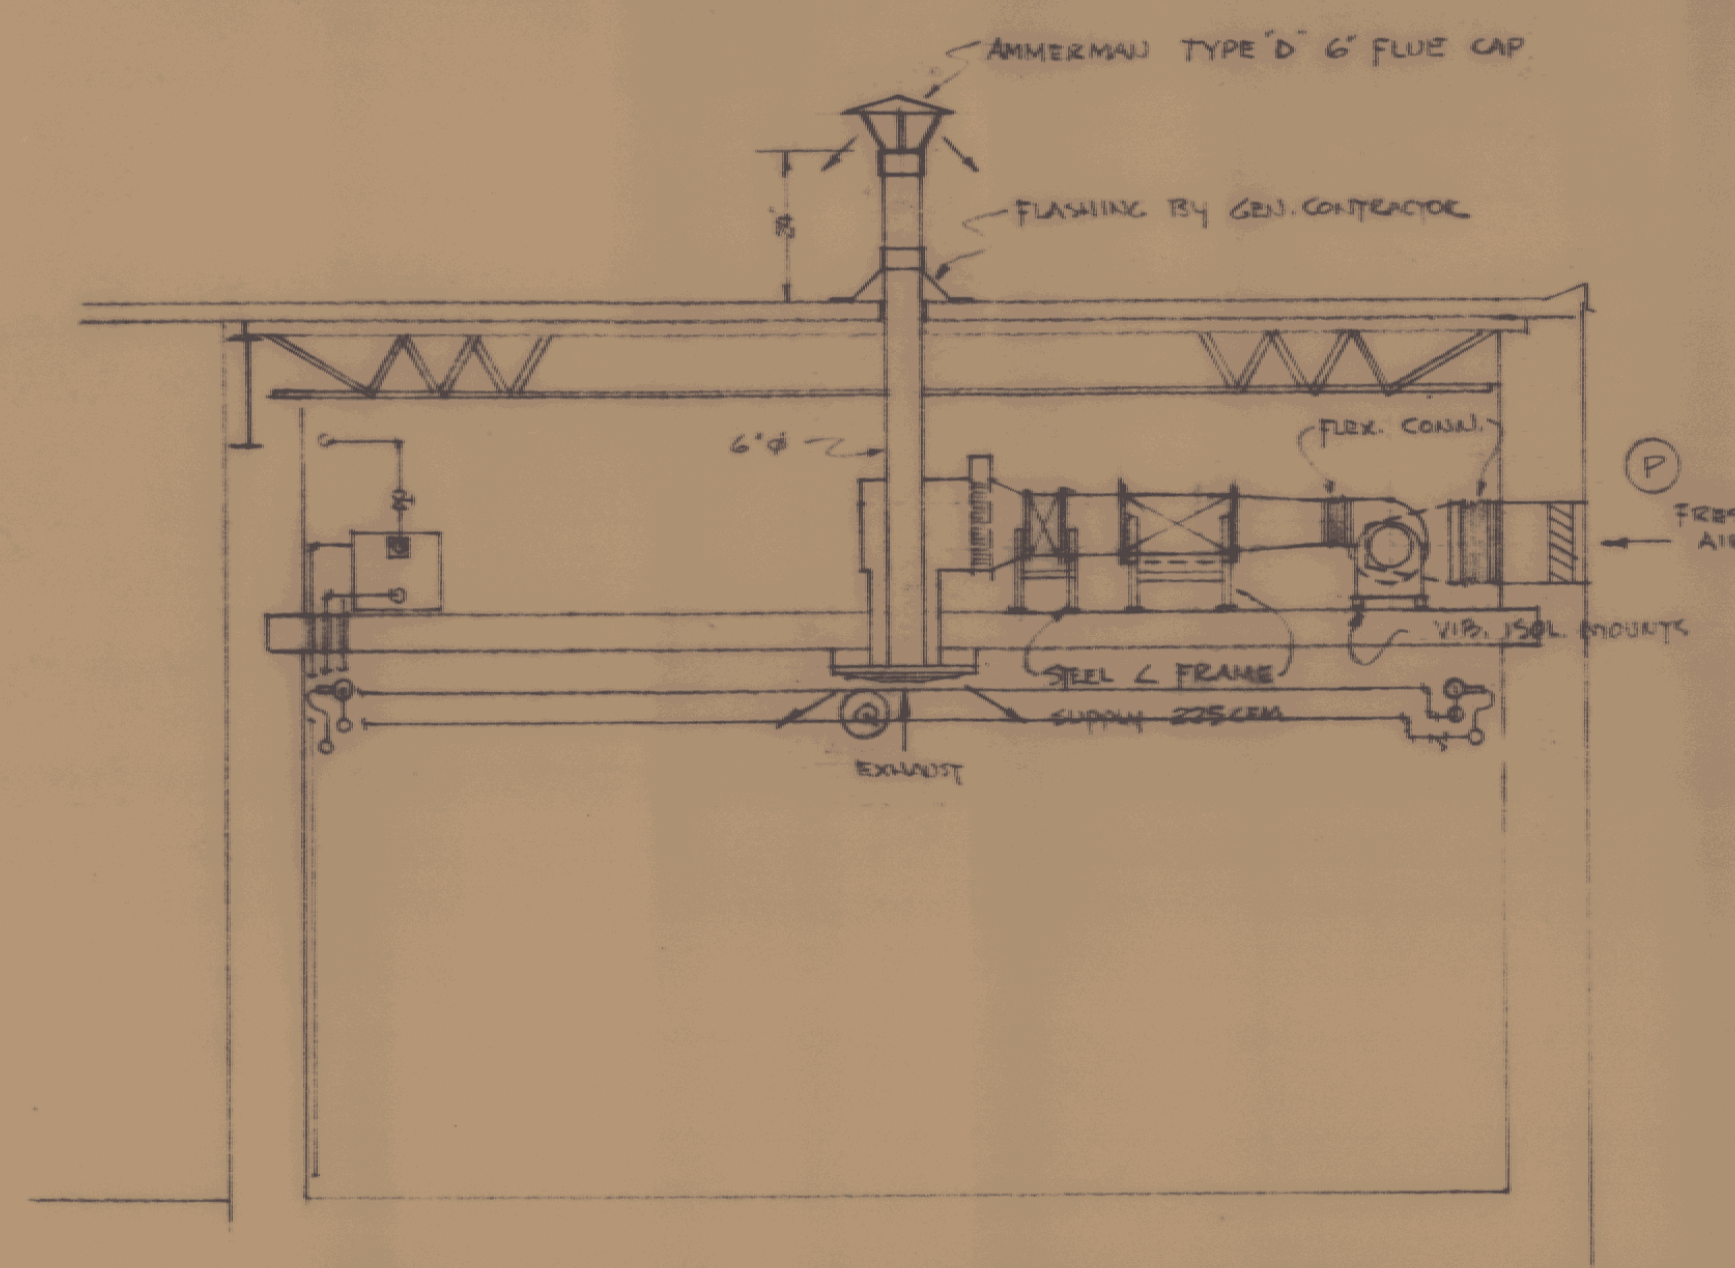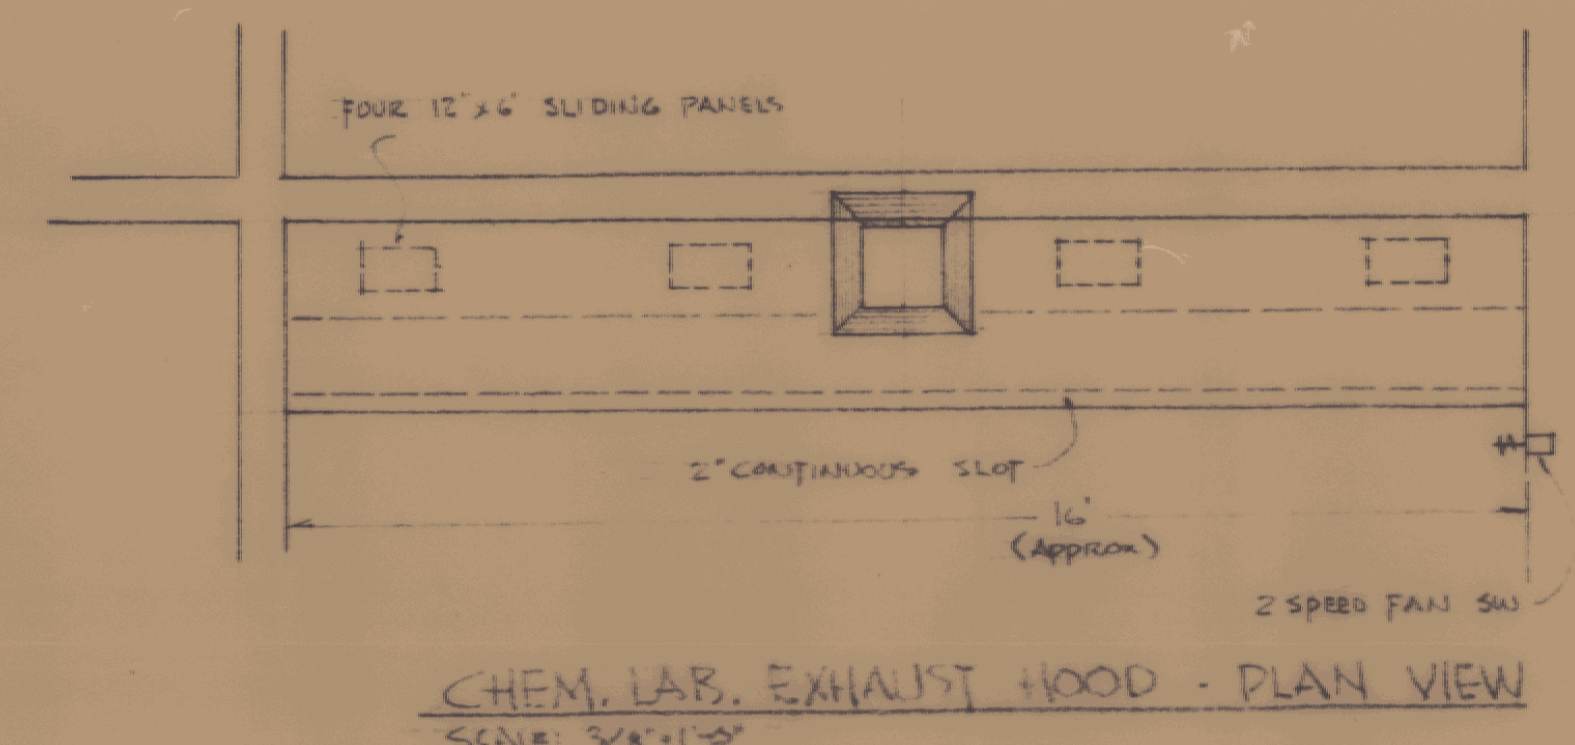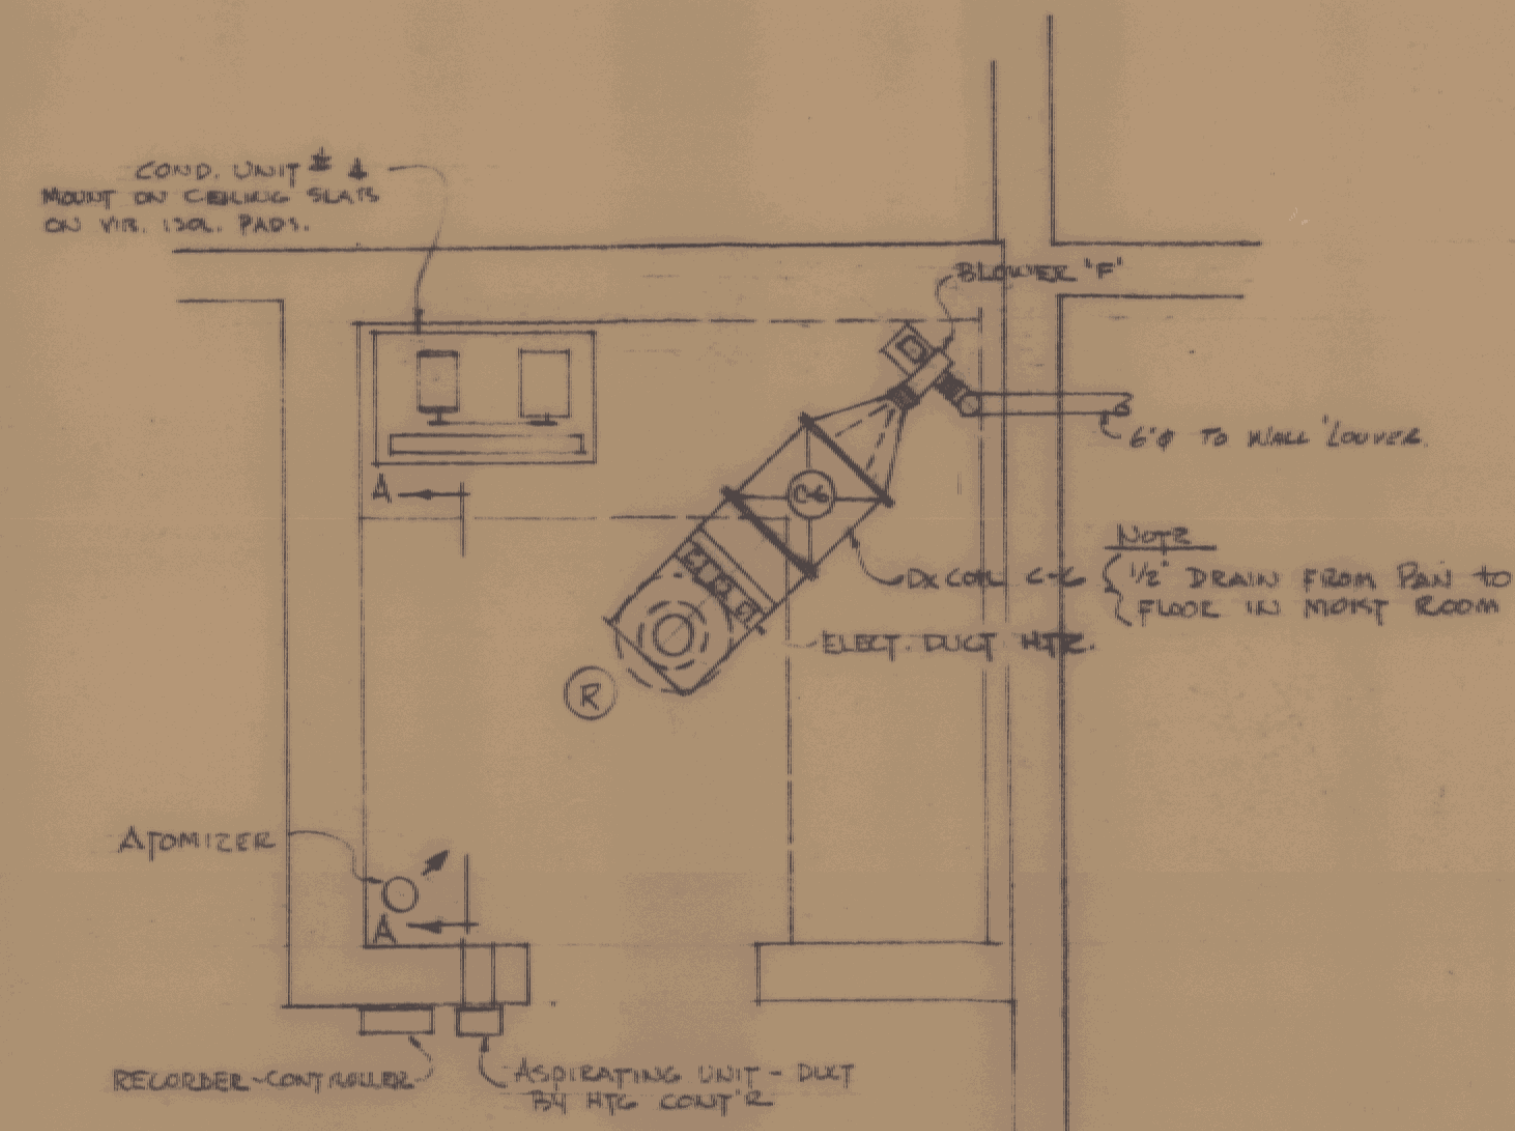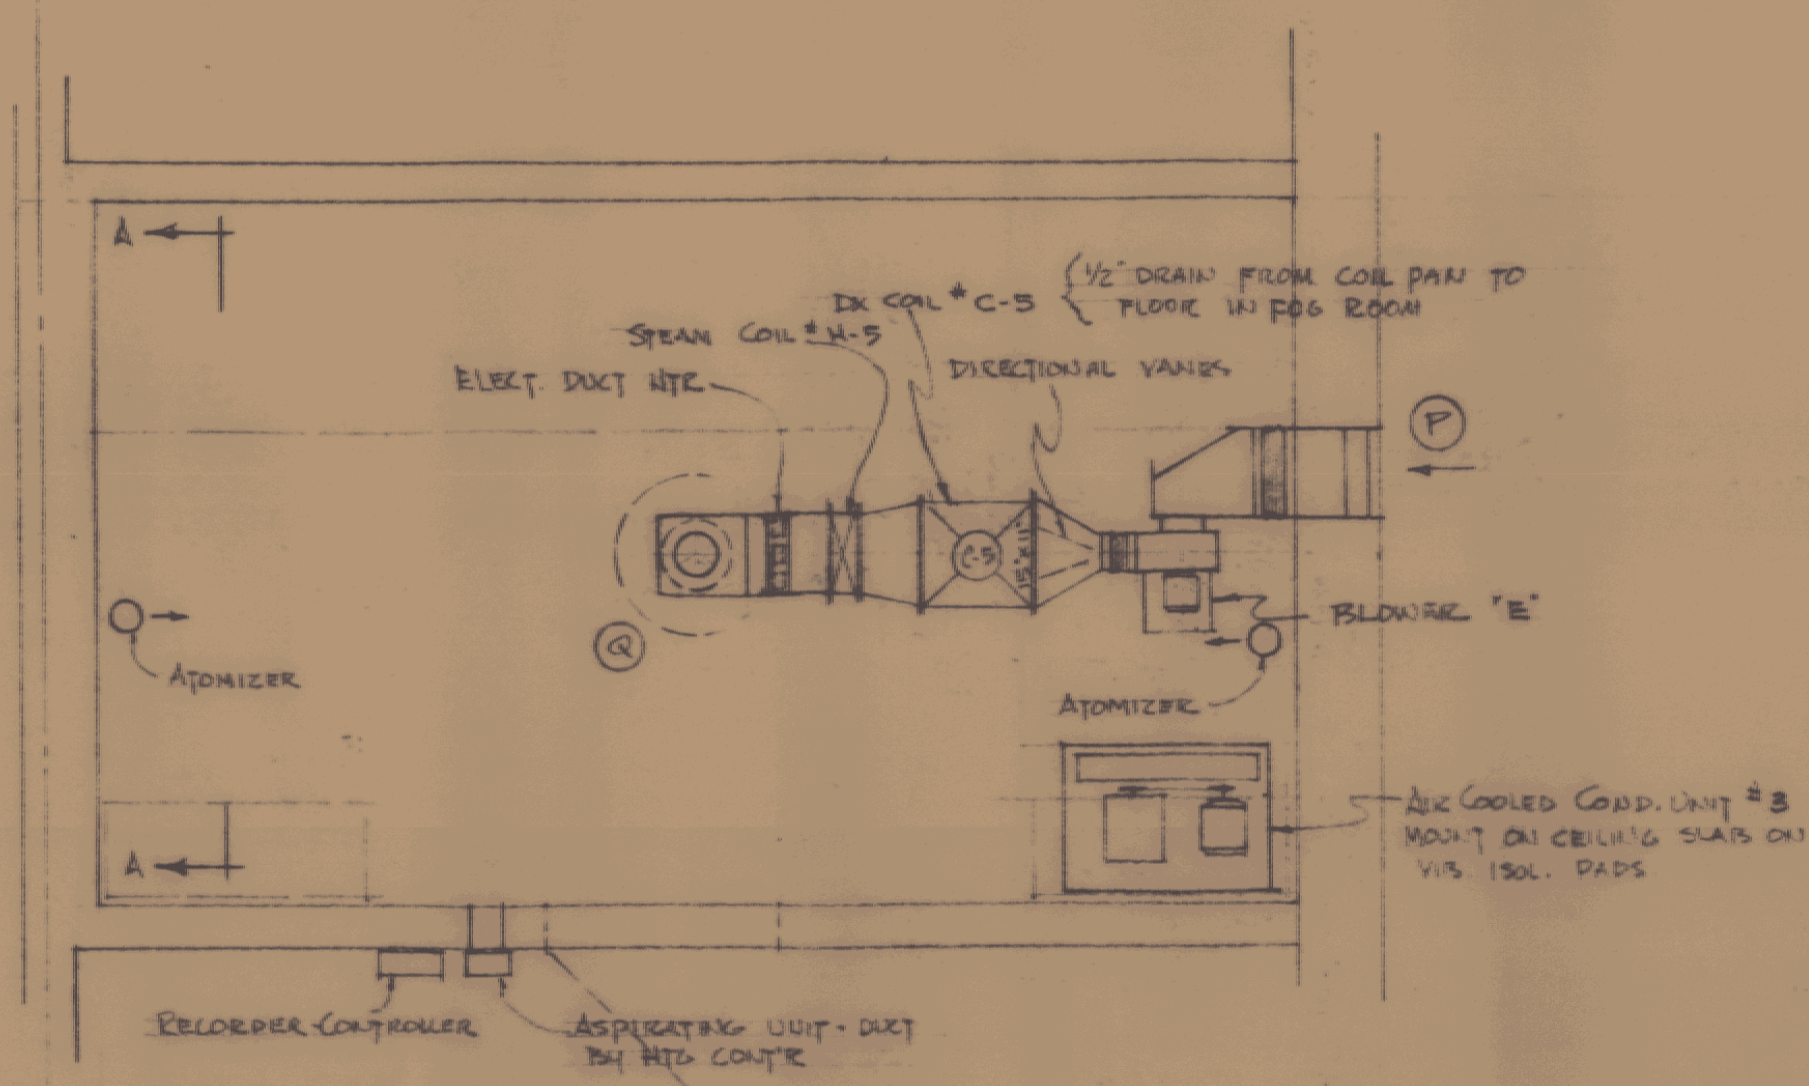


EXISTING CONDENSATE PUMP PIT
SCALE: 1/2" = 1'-0"

NOTE: CHECK ALL DIMENSIONS & ELEV. OF PIT & PIPING AT JOB SITE. VERIFY ALL CONDITIONS.




JENNISON ENGINEERING INC.
95 COLLEGE ST. BURLINGTON, VT.
ADDITION TO VERMONT
STATE HIGHWAY LABORATORY
MONTPELIER, VERMONT
GORDON G. WOODS
ARCHITECTS
ST. JOHNSBURY, VERMONT


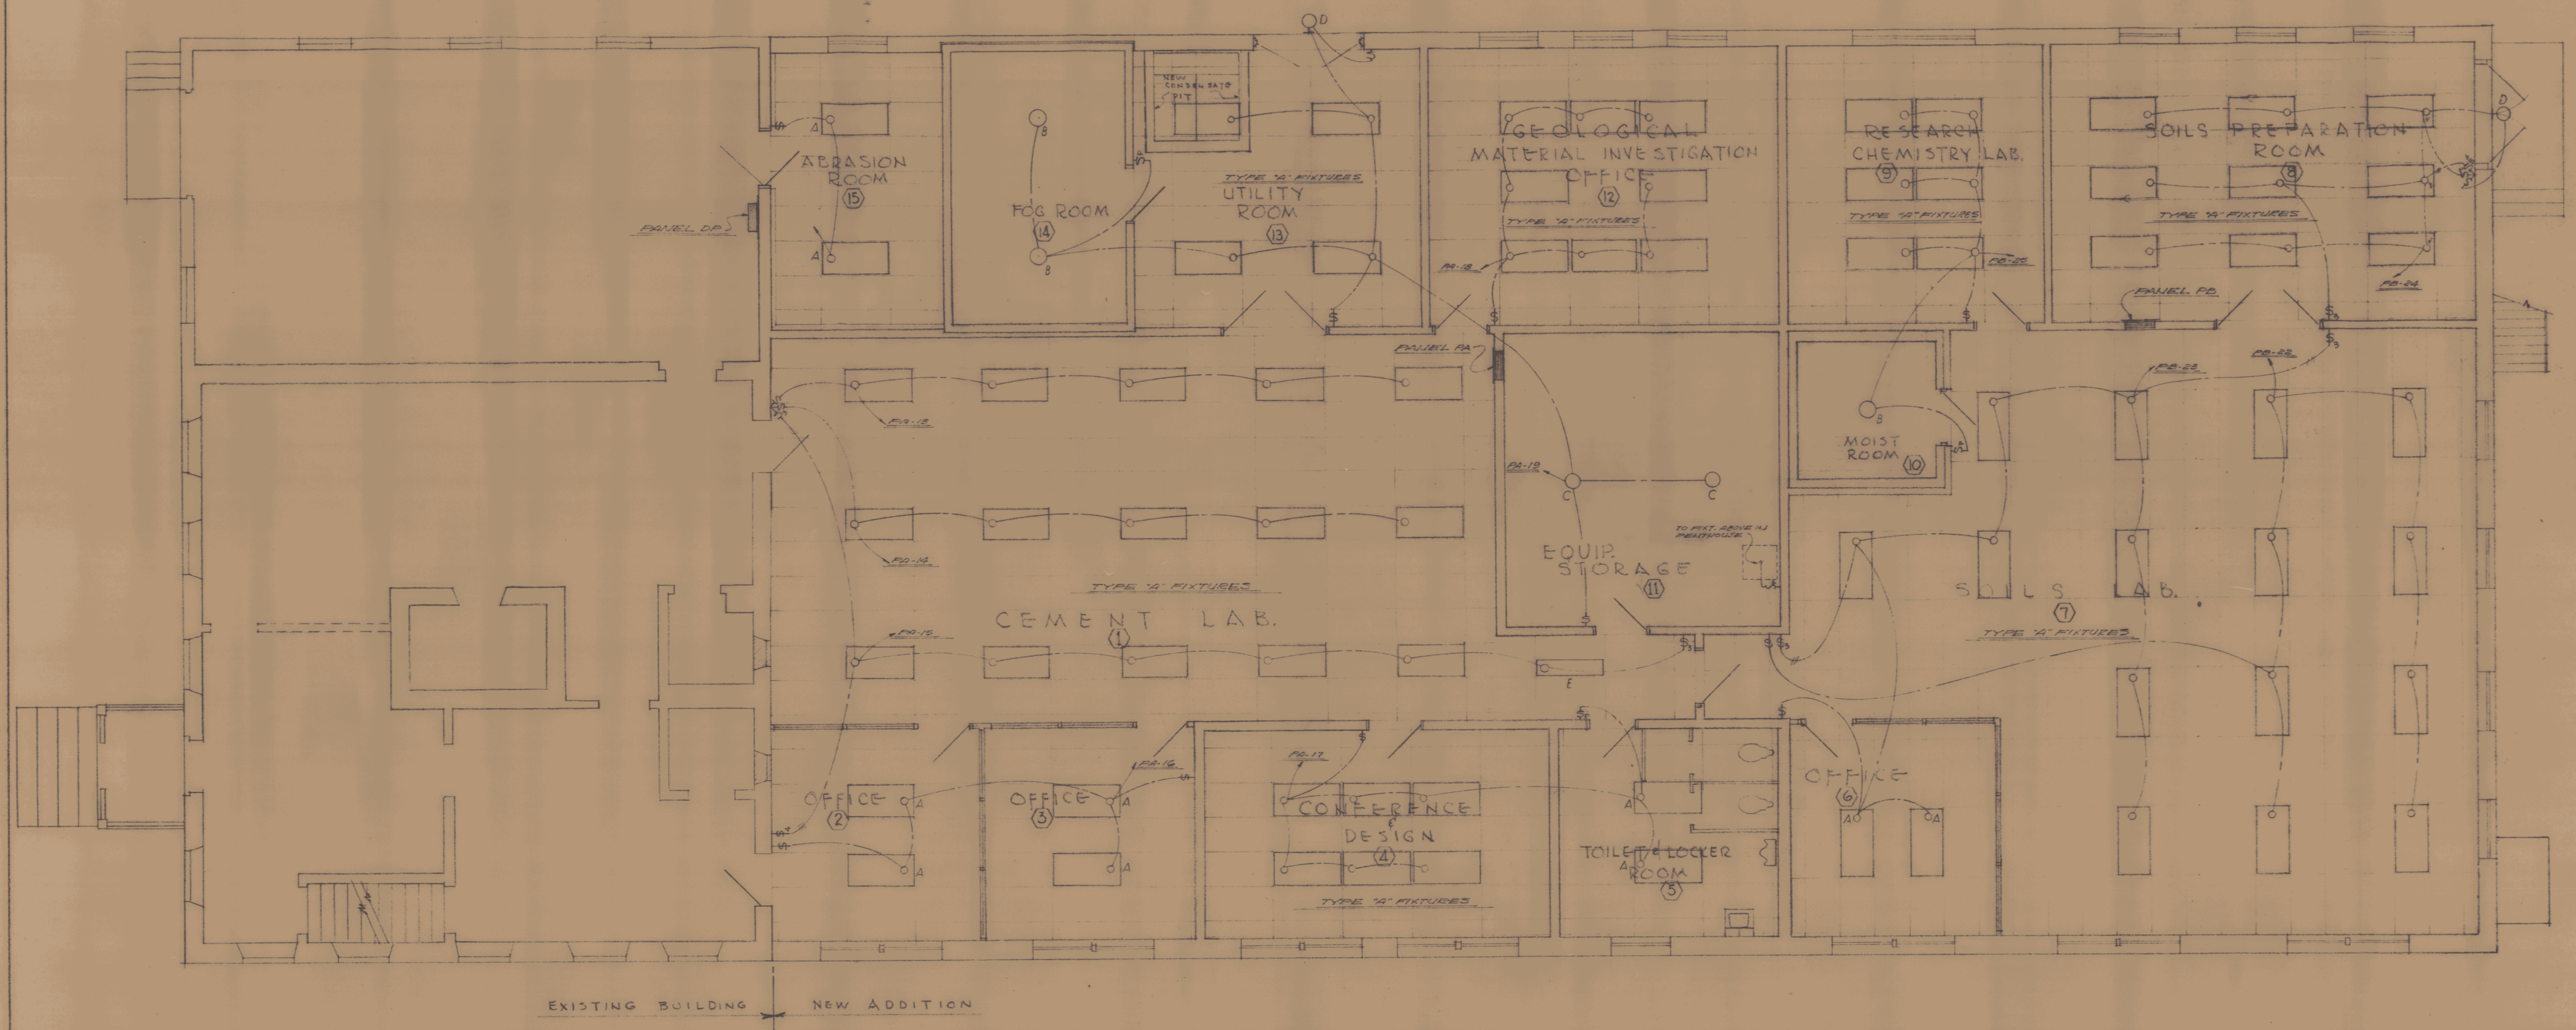


FIRST FLOOR PLAN - ELECTRICAL LIGHTING LAYOUT

SCALE: 1/4" = 1'-0"

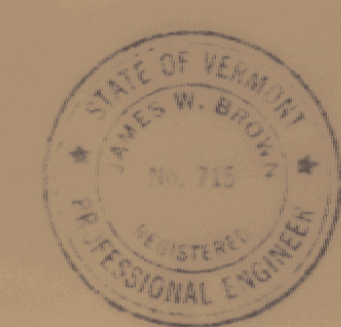

JENNISON ENGINEERING INC.	
95 COLLEGE ST.	BURLINGTON, VT.
ADDITION TO VERMONT STATE HIGHWAY LABORATORY	
MONTPELIER, VERMONT	
GORDON G. WOODS	DATE MAY '61
ARCHITECT	PROJECT E-2
ST. JOHNSBURY, VERMONT	

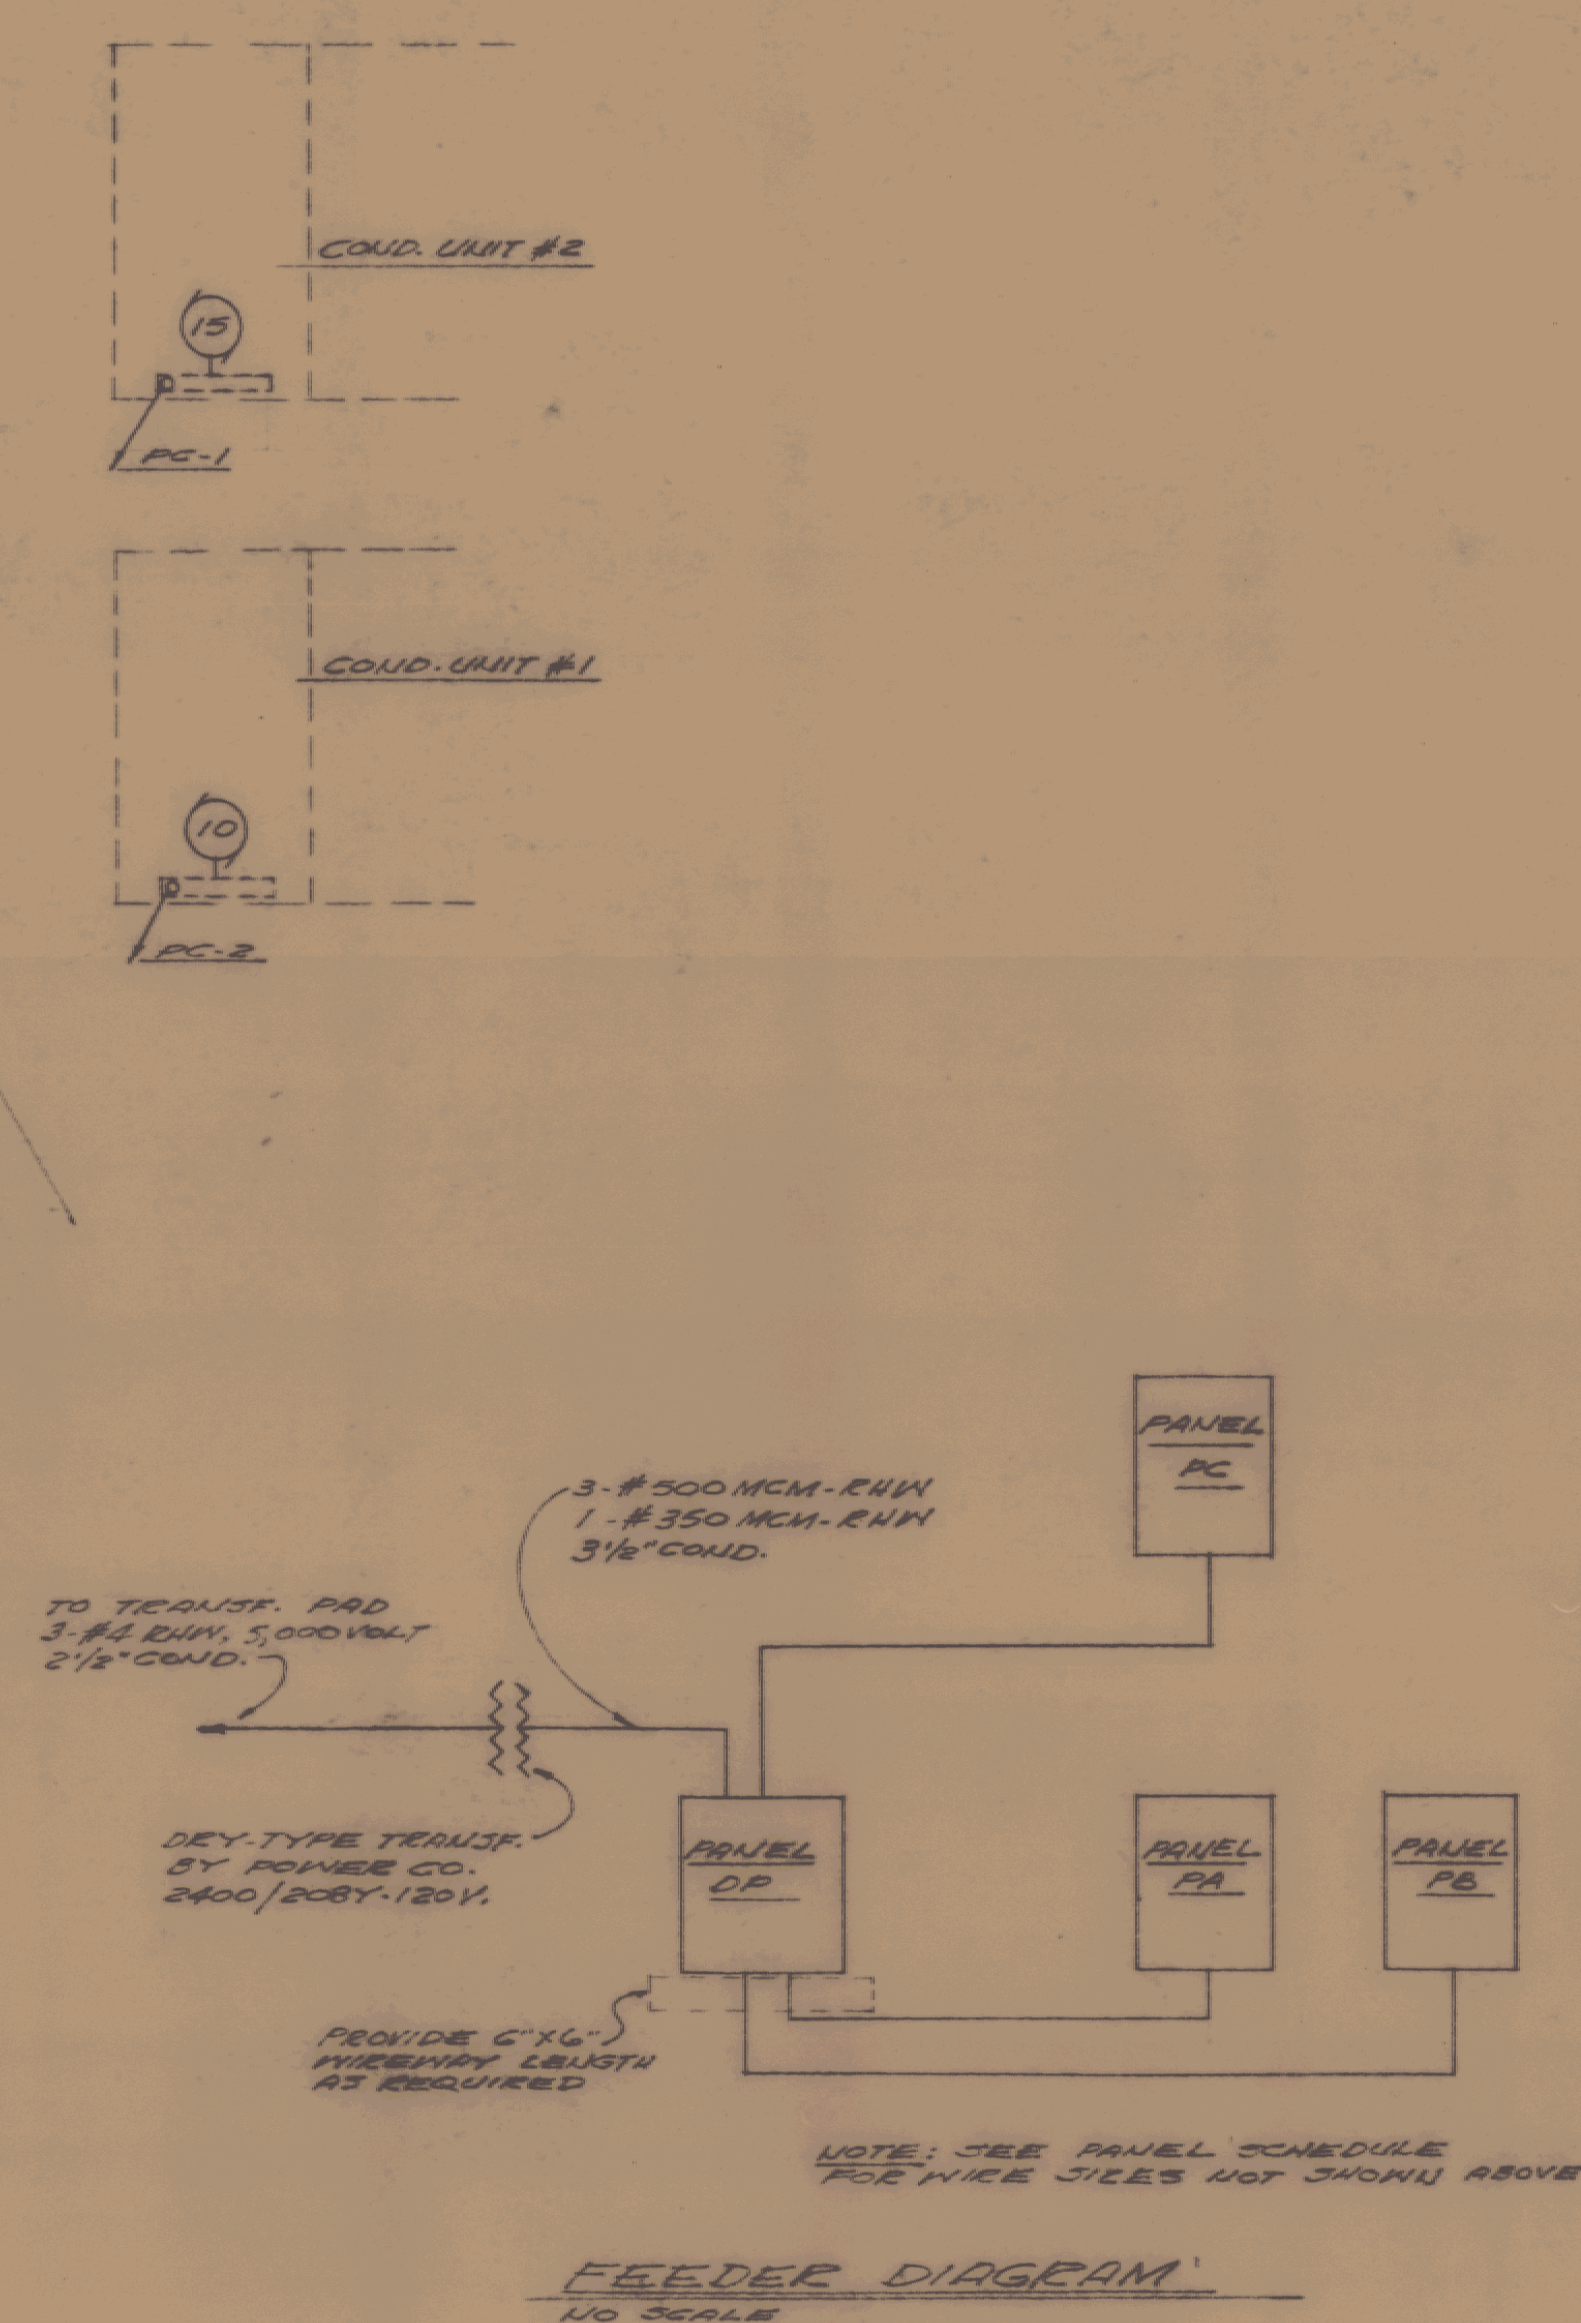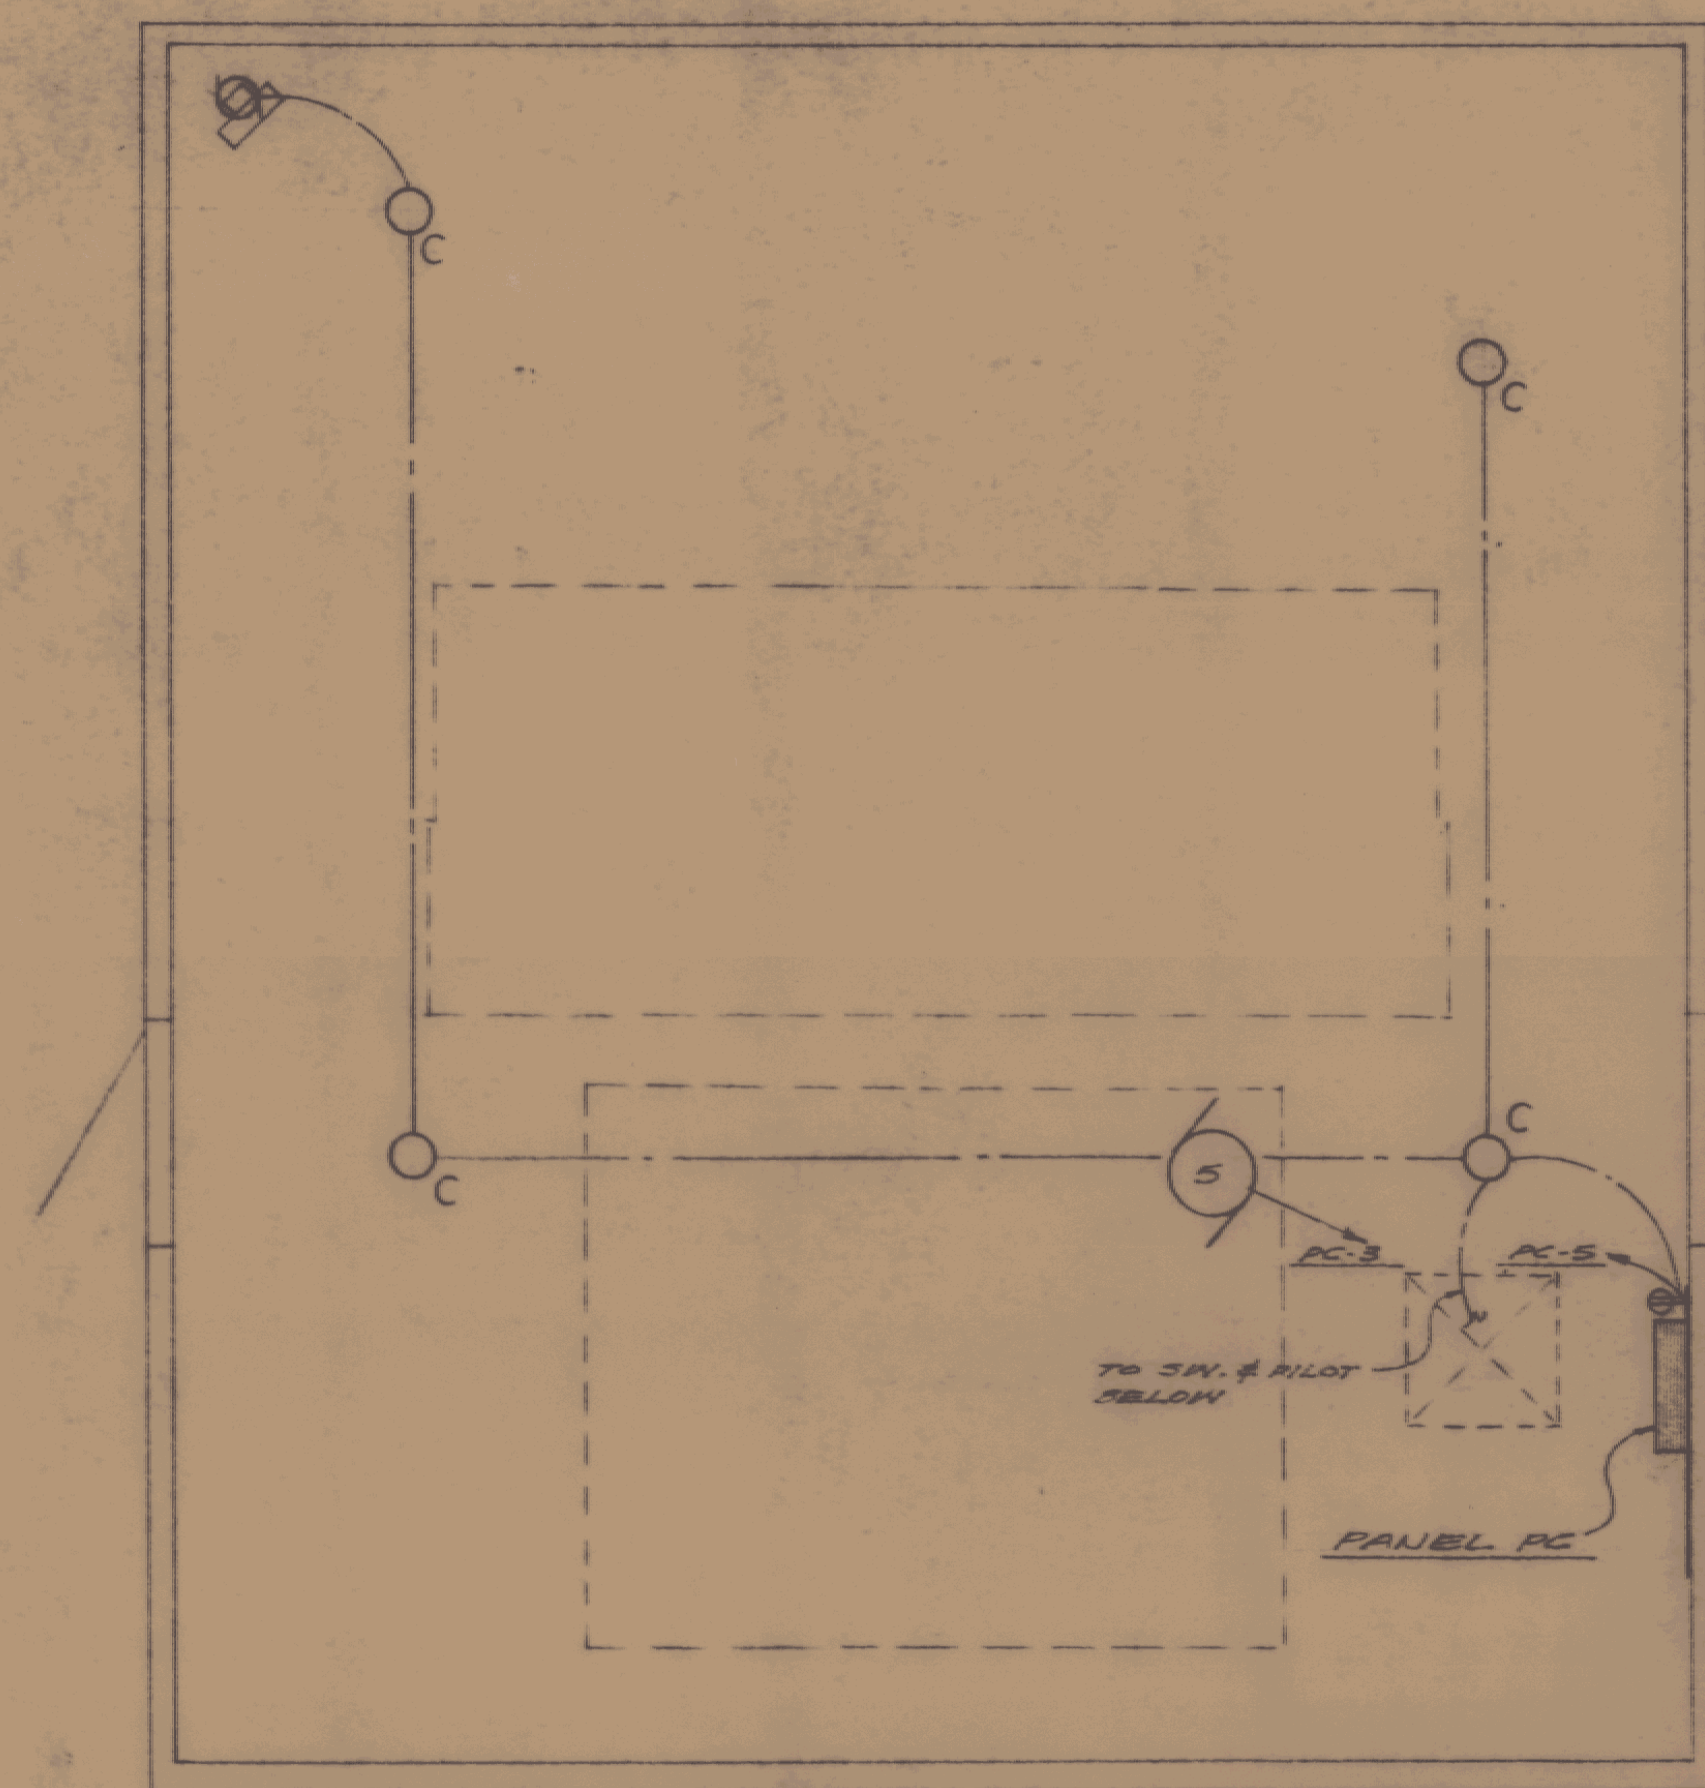

PANEL PA Circuit Breaker Type NALB, 120/208 vac., 3-phase, 4-wire, 3U, 225 amp. Mains Lugs only Flush mount

BRANCH CIRCUIT					LOCATION	EQUIPMENT	WIRING
N.O.	BREAKER RATED AMP.	WIRE SIZE	CIRCUIT LOAD KVA	WIRE TYPE			COND. WIRE
1	1	20	1.3		CEMENT LAB.	AUTOCLAVE	2" 2-#12
2	1	20	1.4		"	ALUMINUM	"
3	1	20	1.5		"	HOIST CAB.	"
4-9	1	20	1.7		RM'S. 1, 12 & 13	FREESTER & RECAP.	3-#12
10	1	20	1.8		CEMENT LAB.	ALUMINUM	2-#12
11	1	20	1.2		"	CEMENT MIXER	"
12	1	20	1.2		"	ALUMINUM	3-#12
13	1	20	1.6		RM'S. 1, 2, 3 & 4	RECEPTACLES	2-#12
14	1	20	1.4		CEMENT LAB.	RECEPTACLES	"
15	1	20	1.4		ROOM-12	"	"
16-19	1	20	1.7		RM'S. 12, 13, 14, 15, 16 & 17	FIXTURES	"
20	1	20	1	2-#12	UTILITY ROOM	EXIST. COND. PUMPS	"
21	1	20	1	1-#12	ROOM-14	BLOWER	"
22-23	3	20	3.4	1	"	ELEC. COIL & COMPRESSOR	3-#12
24	2	40	1	2-#12	UTILITY ROOM	TEST. MACHINE	1" 3-#8
25-29	1	20	1			SPEARS	

PANEL PB Circuit Breaker Type NALB, 120/208 vac., 3-phase, 4-wire, 3U, 225 amp. Mains Lugs only Flush mount

BRANCH CIRCUIT					LOCATION	EQUIPMENT	WIRING
N.O.	BREAKER RATED AMP.	WIRE SIZE	CIRCUIT LOAD KVA	WIRE TYPE			COND. WIRE
1	1	20	1.6		SOILS LAB.	ALUMINUM	1-#12
2	1	20	1.8		"	OVEN	"
3	1	20	1.8		"	OVEN	"
4	1	20	1.6		"	ALUMINUM	"
5	1	20	1.8		"	"	"
6	1	20	1.8		"	"	"
7	1	20	1	1/2"	"	VAC. PUMP	"
8	1	20	1	1/2"	"	EJECTOR	"
9	1	20	1	1/2"	"	TEV. SHED	"
10	1	20	1.3		"	ALUMINUM	"
11	1	20	1.7		"	RECEPTACLES	"
12	1	20	1.6		"	RESECTEE	"
13	2	20	1.0		"	HYDRO. BATH	"
14	1	20	1.4		SOILS PREP. ROOM	ALUMINUM	1/2" 2-#12
15	1	20	1.7		"	"	"
16	2	20	1.4		"	OVEN	3-#12
17	2	20	1.4		"	"	"
18	1	20	1.7		RESEARCH CHEM. LAB.	ALUMINUM	2-#12
19	1	20	1.5		"	AUTO. CLAVE	"
20	1	20	1	1/2"	"	VAC. PUMP	"
21	1	20	1.7		"	OVEN	"
22-25	1	20	1.4		RM'S. 6, 7, 8 & 9	FIXTURES	"
26	2	100	1.2		EXTERIOR	TRAILER LAB. OUTLET	1/2" 2-#12
27	1	20	1	1/2"	RM'S. 9 & 10	EXH. FANS D & G	1/2" 2-#12
28, 29	1	20	1	1/2"	ROOM-10	COMPRESSOR & BLOWER	"
30-34	1	20	1			SPEARS	

PANEL PC Circuit Breaker Type NALB, 120/208 vac., 3-phase, 4-wire, 3U, 100 amp. Mains Lugs only Surface mount

BRANCH CIRCUIT					LOCATION	EQUIPMENT	WIRING
N.O.	BREAKER RATED AMP.	WIRE SIZE	CIRCUIT LOAD KVA	WIRE TYPE			COND. WIRE
1	3	700	3	1/2"	PENTHOUSE	COND. UNIT #2	2" 2-#12
2	3	700	3	1/2"	"	"	1/2" 2-#12
3	3	700	3	1/2"	"	BLOWER	3/4" 3-#10
4	1	200	1	1/2"	ROOF	EXH. FANS D & G	1/2" 2-#12
5	1	200	1	1/2"	REP. PENTHOUSE	FIXTURES, UNIT #1 & 2	1/2" 2-#12
6-8	1	200	1			SPEARS	

PANEL PD Circuit Breaker Type NALB, 120/208 vac., 3-phase, 4-wire, 3U, 400 amp. Main Breaker Surface mount

BRANCH CIRCUIT					LOCATION	EQUIPMENT	WIRING
N.O.	BREAKER RATED AMP.	WIRE SIZE	CIRCUIT LOAD KVA	WIRE TYPE			COND. WIRE
1	3	1000	3	3/2"	CEMENT LAB.	PANEL PA	2" 2-#12
2	3	1000	3	3/2"	SOILS PREP. RM.	PANEL PB	2 1/2" 2-#12
3	3	1000	3	3/2"	PENTHOUSE	PANEL PC	2" 2-#12
4	1	200	1	1/2"	ROOM-15	DEVIL	1/2" 2-#12
5	1	200	1	1/2"	"	"	"
6	2	200	1	1	"	L.D. REACTION	3-#12
7	1	200	1	1/2"	"	RECEPTACLE	2-#12
8	2	1000	1	1/2"	EXIST. PENTHOUSE	EXIST. PENTHOUSE	3-#12
9	2	600	1	5/8"	"	"	1" 3-#10
10	2	700	1	1 1/4"	"	"	1 1/4" 3-#10
11	2	700	1	1 1/4"	"	"	"
12	1	200	1	1/2"	EXIST. REACTION	EXIST. PENTHOUSE	1/2" 2-#12
13, 14	1	200	1	1/2"	EXIST. REACTION	TEL. EQUIP. & AIR COMP.	"
15-18	1	200	1			SPEARS	
19-20	3	700	3			REDUCTION	

- LEGEND:**
- FLUORESCENT FIXTURE, LETTER DENOTES FIXTURE TYPE
 - INCANDESCENT FIXTURE, LETTER DENOTES FIXTURE TYPE
 - INCANDESCENT FIXTURE, WALL SOCKET, LETTER DENOTES FIXTURE TYPE
 - DUPLEX RECEPTACLE, GROUNDING TYPE, MOUNT 16" ABOVE FIN. FL. UNLESS OTHERWISE INDICATED, SEE SPECIFICATIONS
 - ALUMINUM 2000, WITH NEMA GROUND RECEPTACLES, MOUNTING HEIGHT AS SHOWN ON THE DRAWINGS; SEE SPECIFICATIONS
 - MOTOR
 - JOINT BOX
 - SWITCH, SINGLE POLE, 20 AMP., MOUNT 4'-0" ABOVE FIN. FL. SEE SPECIFICATIONS
 - SWITCH, THREE-WAY, 20 AMP., MOUNT 4'-0" ABOVE FIN. FL. SEE SPECIFICATIONS
 - SWITCH, FOUR-WAY, 20 AMP., MOUNT 4'-0" ABOVE FIN. FL. SEE SPECIFICATIONS
 - SWITCH, 20 AMP., MOUNT 4'-0" ABOVE FIN. FL. SEE SPECIFICATIONS
 - TELEPHONE OUTLET, WALL OR FLOOR OUTLET AS INDICATED ON DRAWINGS; FLOOR OUTLET TO BE LEVY NO. 5353B, 1/2" TAPPING
 - POWER OUTLET, GROUND-WINDS NO. 45-1081 RECEPTACLE, 3-WIRE, 3-POLE, WITH GROUNDING CONDUIT BOX & 1/2" J-BOX PLUG, MOUNT AS SHOWN ON THE DRAWINGS
 - POWER OUTLET, 20 AMP., 250V., 1/2" & 1/4" NO. 8140-G, MOUNT AS SHOWN ON DRAWINGS
 - CLOSE OUTLET, 1/2" & 1/4" NO. 8140-G, MOUNT AS SHOWN ON DRAWINGS
 - MOTOR SWITCH, WESTINGHOUSE CLASS 10-088 WITH HEATERS, BY HEATING CONTRACTOR



JENNISON ENGINEERING INC.
25 COLLEGE ST. BURLINGTON, VT.

ADDITION TO VERMONT
STATE HIGHWAY LABORATORY
MONTPELIER, VERMONT

GORDON G. WOODS
ARCHITECTS
ST. JOHNSBURY, VERMONT

CHECKED BY
G.G.W.
DATE
6-2-61
E-3