




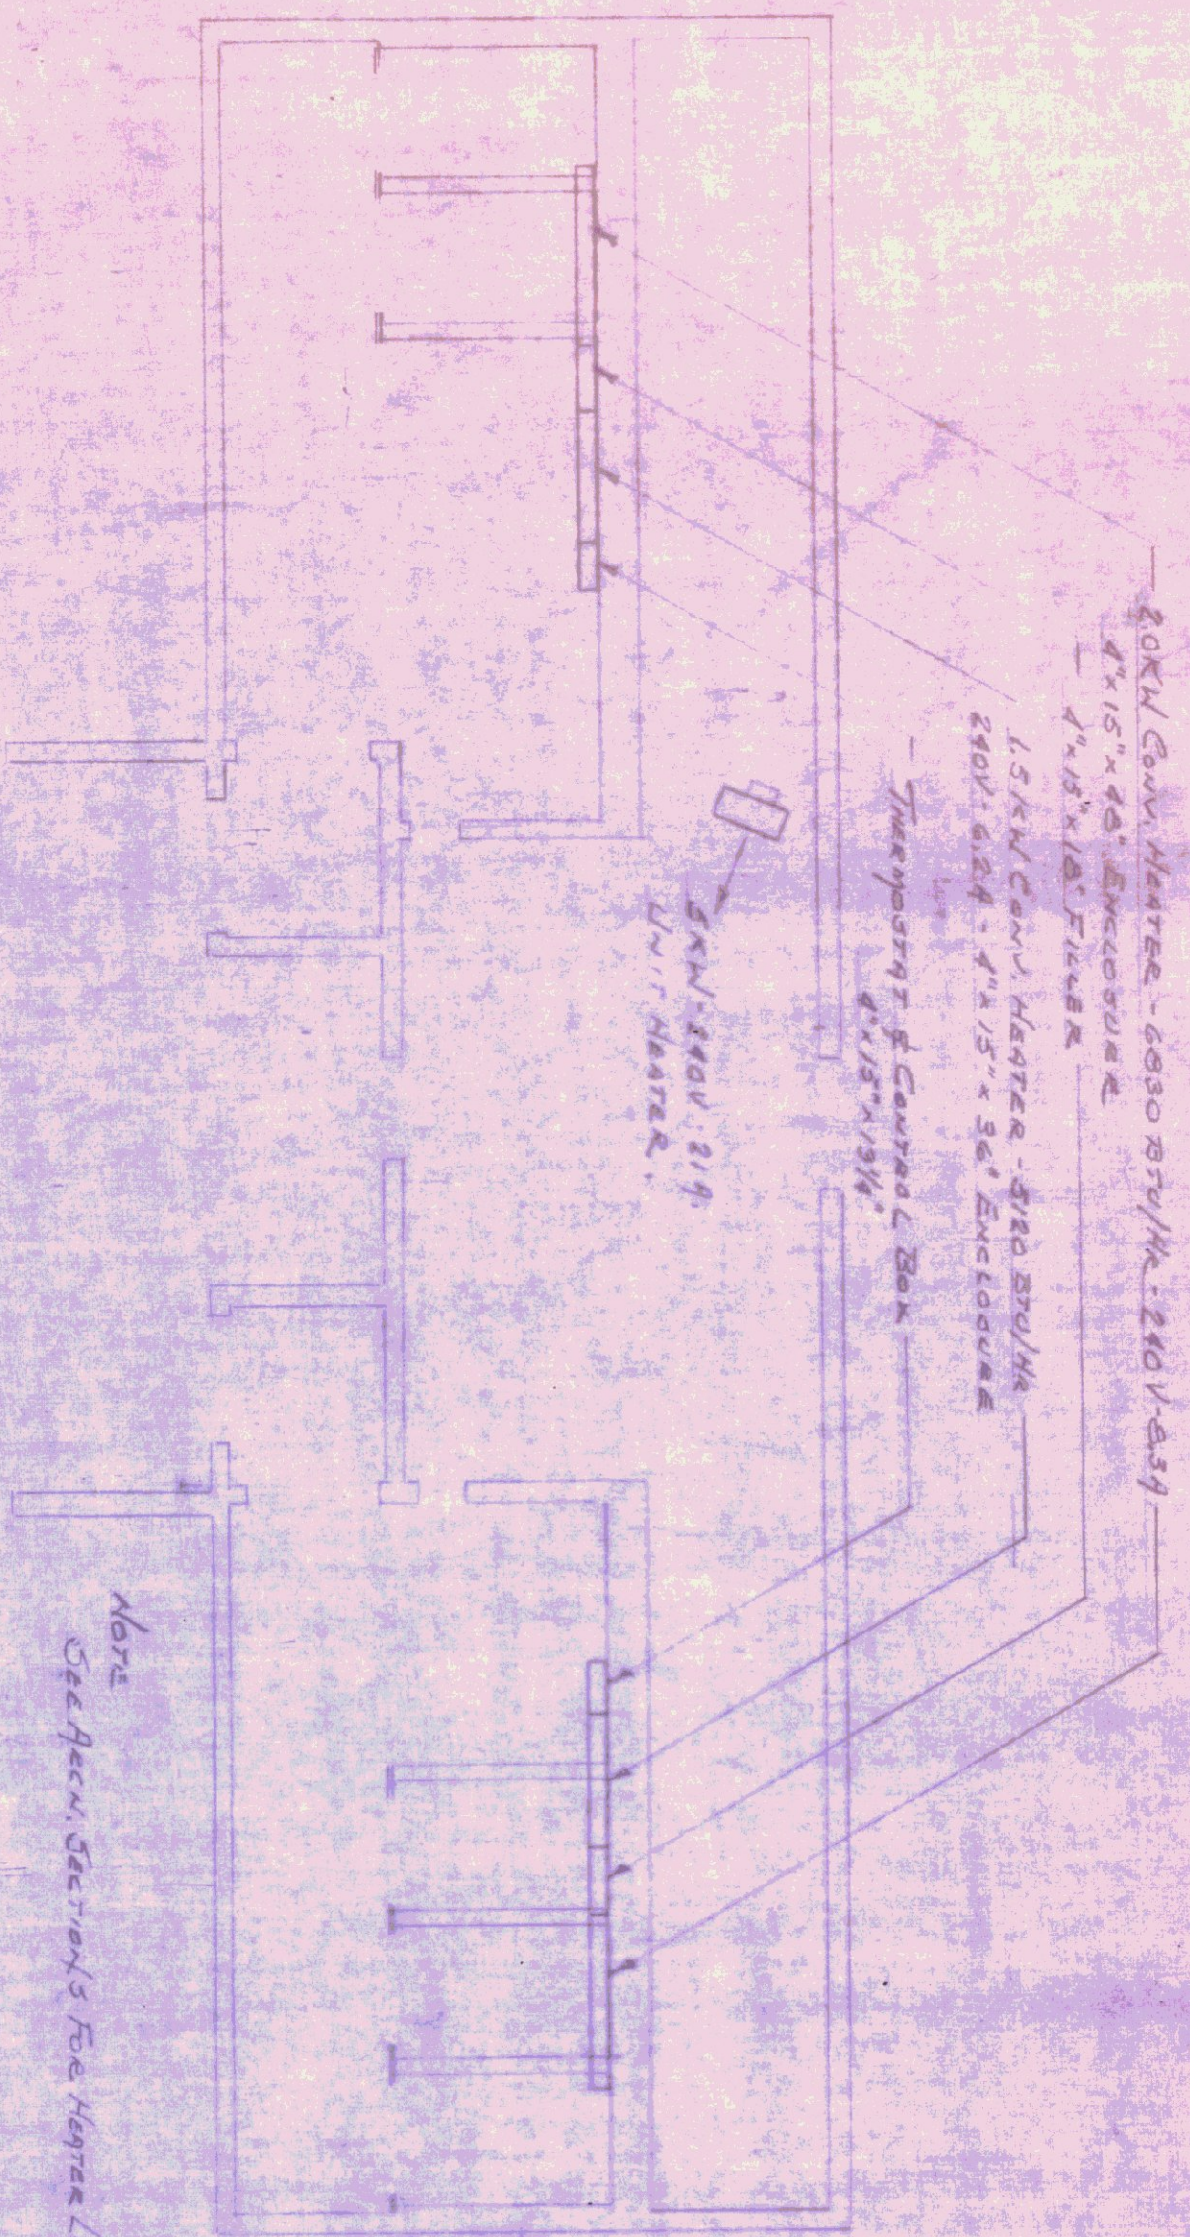


Note
See Arch. Section's For Heater Locations

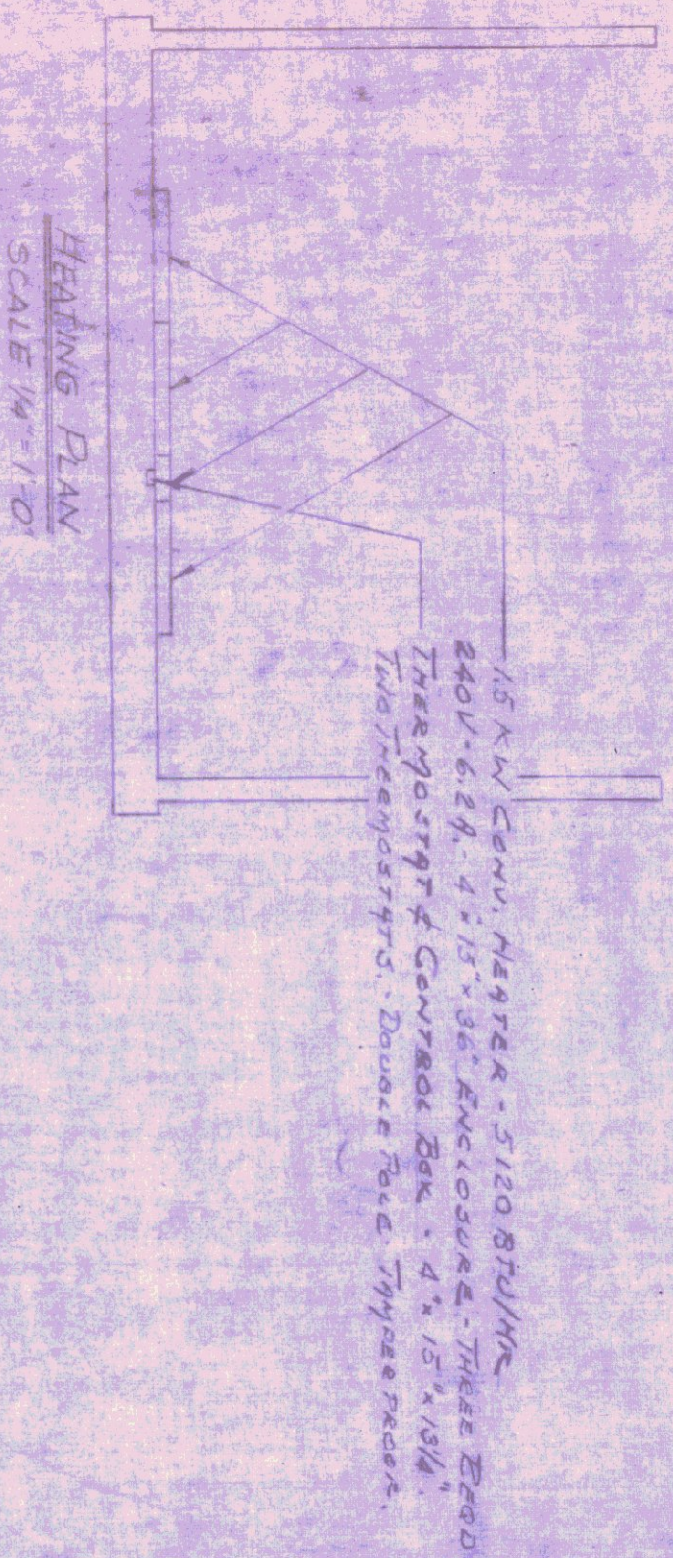


HEATING PLAN
SCALE 1/4" = 1'-0"

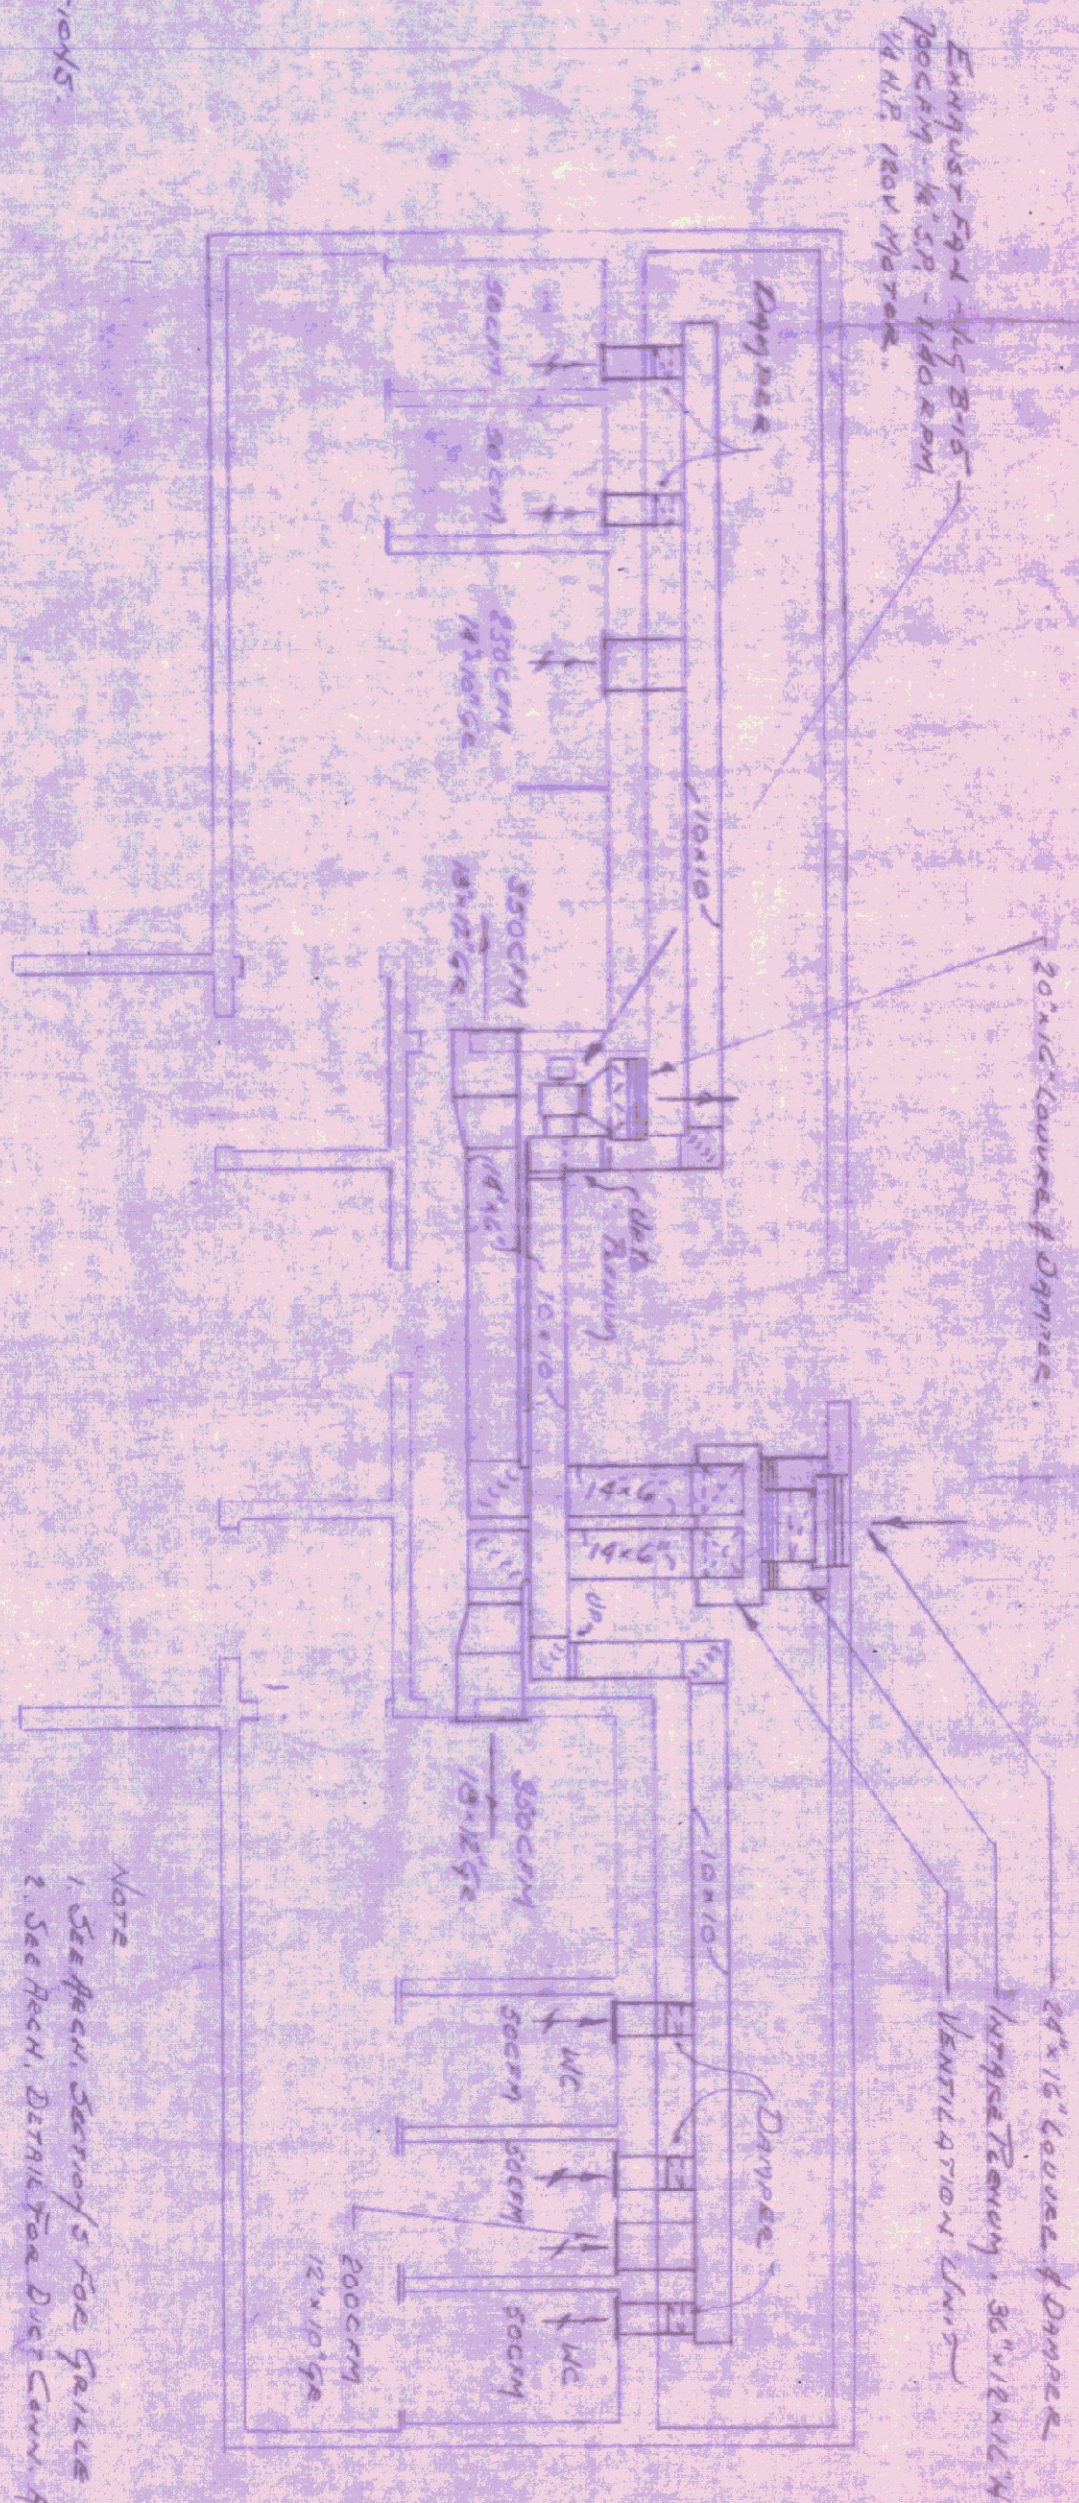


Note
1. See Arch. Section's For Heater Locations.
2. See Arch. Section's For Heater Locations.

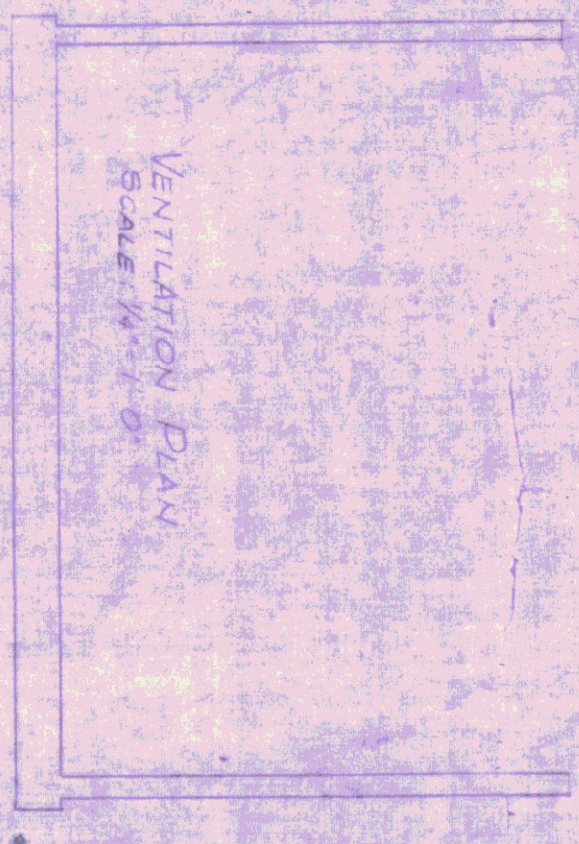

VENTILATION PLAN
SCALE 1/4" = 1'-0"

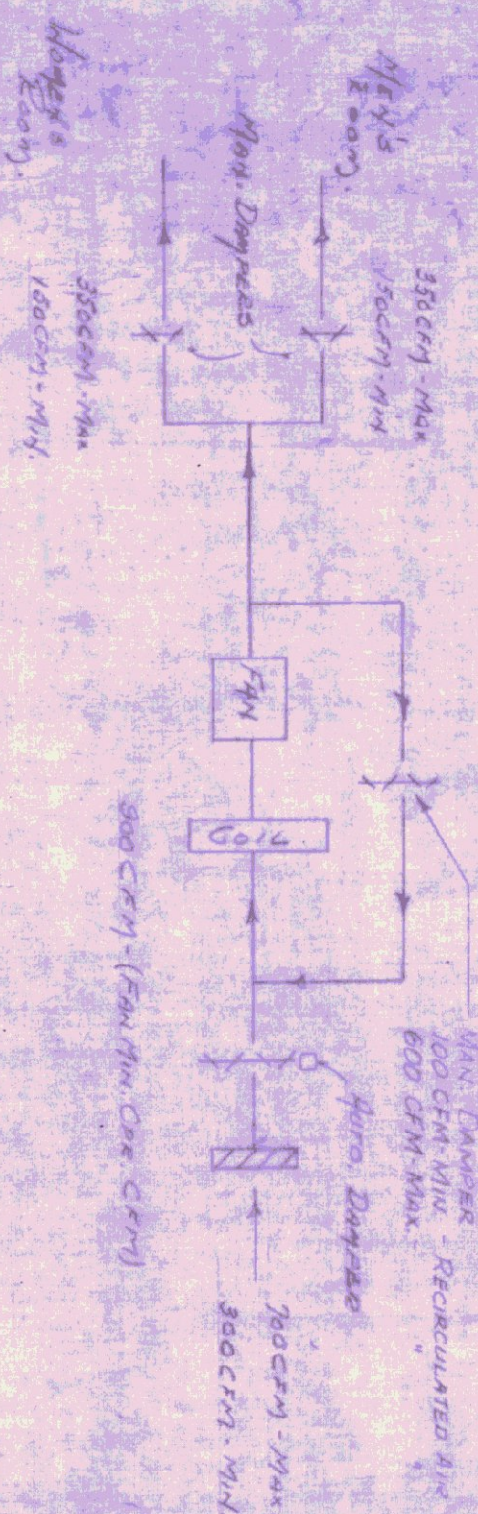

VENTILATION SYSTEM
SCHEMATIC

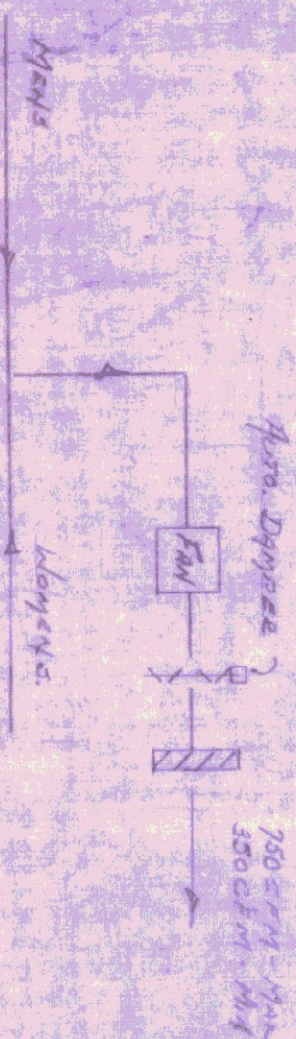

VENTILATION SYSTEM
SCHEMATIC

FLUE DISCHARGE
SCALE 1/4" = 1'-0"

STATE OF VERMONT
DEPARTMENT OF HIGHWAYS

HIGHGATE REST FACILITY
HEATING & VENTILATION (GC-48-005, 4/60)
PROJECT LISTING 89-3(3)
SCALE: AS SHOWN SHEET 16 OF 40